


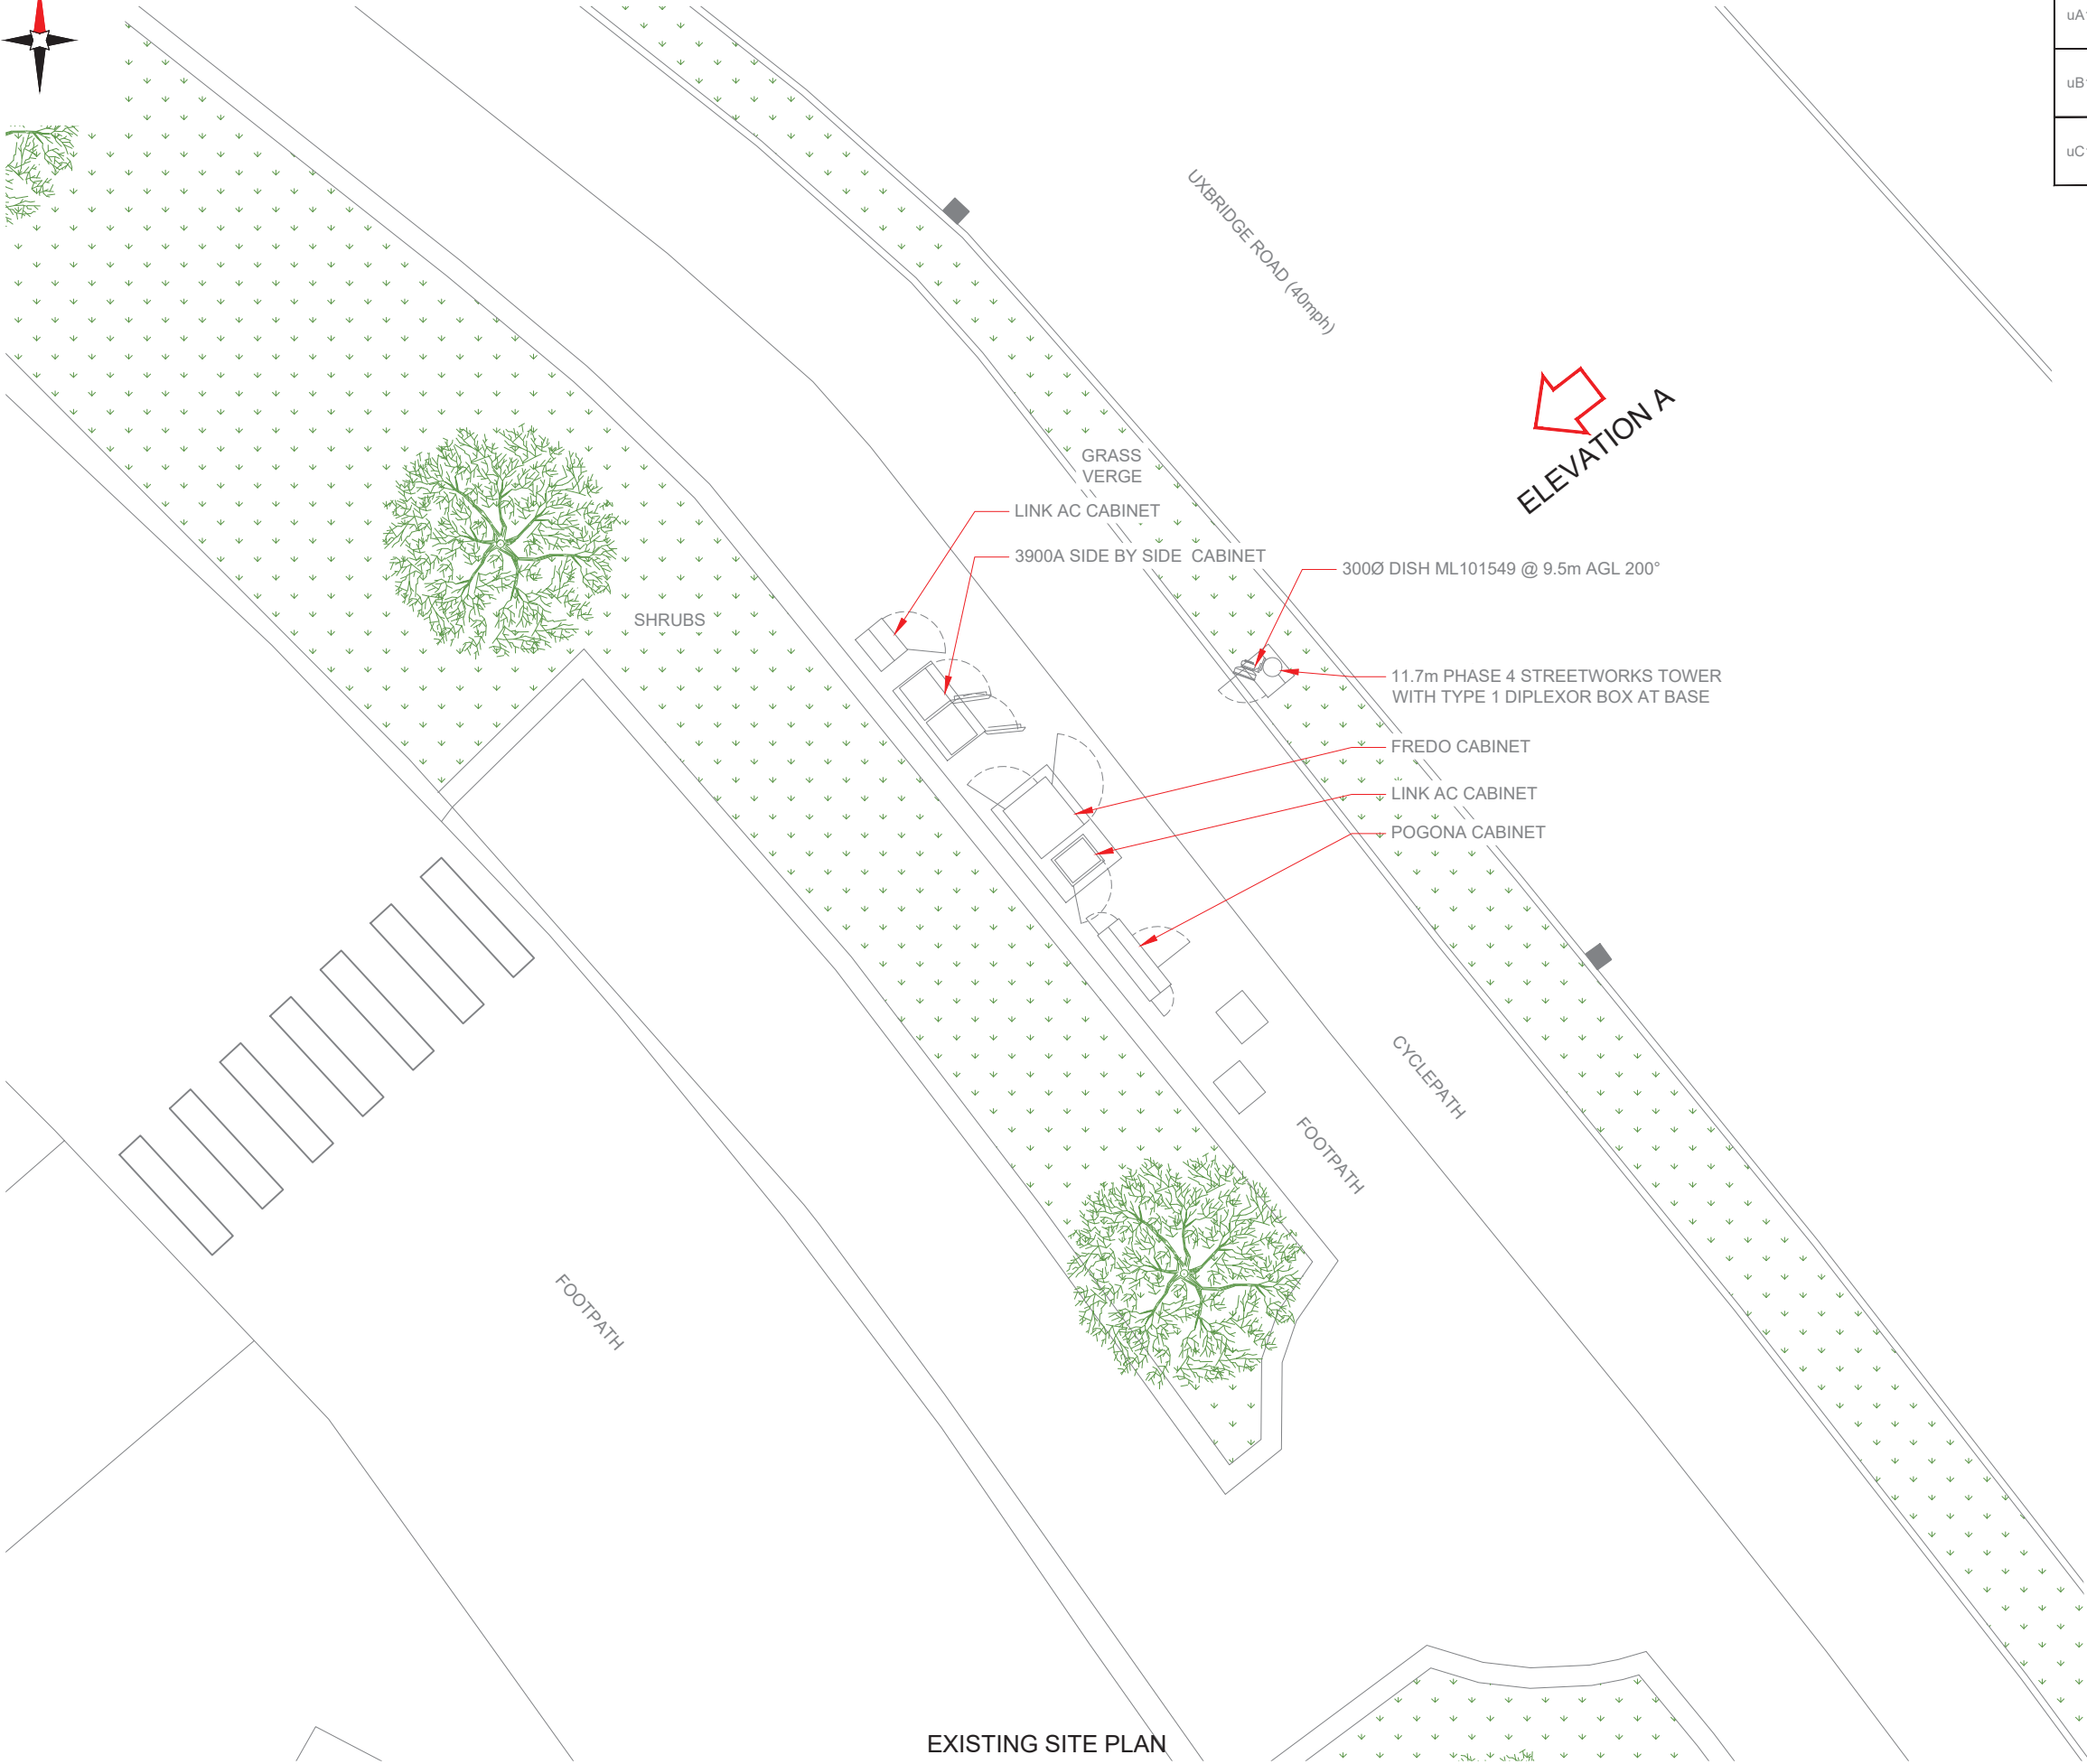

3G Antenna ID	Existing 3G Bearing
uA1	0°
uB1	120°
uC1	240°

NOTES:

1. ALL DIMENSIONS IN MM UNLESS OTHERWISE NOTED.

Master:	MBNL / EE / H3G:	Project:	Purpose of Issue:	Issue:
M001	MBNL	T&A	Planning	A
Date:	28/01/2020	Revision / Upgrade Description:		
Drawn:	S. Mohan	First Issue		
Checked:	T. Clifford			
Approved:	M. Venner			

Hutchison 3G UK Limited
Star House, 20 Grenfell Road
Maidenhead, SL6 1EH
Tel: 01628 765 000
Fax: 01628 765 001

H3G Base Station Information line:
0845 6043000
Available 8am-8pm Monday to Friday

Hatfield Business Park
Hatfield
Hertfordshire
AL10 9BW

Tel: 01707 315000
Fax: 01707 319001

Mobile Broadband Network Limited
Sixth Floor, Thames Tower, Station Road, Reading, RG1 1LX

UNIT E3 PITTS CLEAVE INDUSTRIAL ESTATE, TAVISTOCK, DEVON, PL19 0PW
sales@beaconcomms.co.uk
Tel: +44 (0)1822 610610

Site Name:

LOMBARDY RETAIL PARK DNS

Site ID:

998808

Address:

LOMBARDY RETAIL PARK DNS
UXBRIDGE ROAD
HAYES LONDON
HILLINGDON
UB4 0JA

Title:

100 EXISTING SITE PLAN

Project:

T & A

Purpose of Issue:

GENERAL ARRANGEMENT


EE Cell ID:	MBNL Cell ID:	3UK Cell ID:
50677	HGN004	UB0124

Master Drawing No:

998808_HGN004_50677_UB0124_M001

Issue:

A

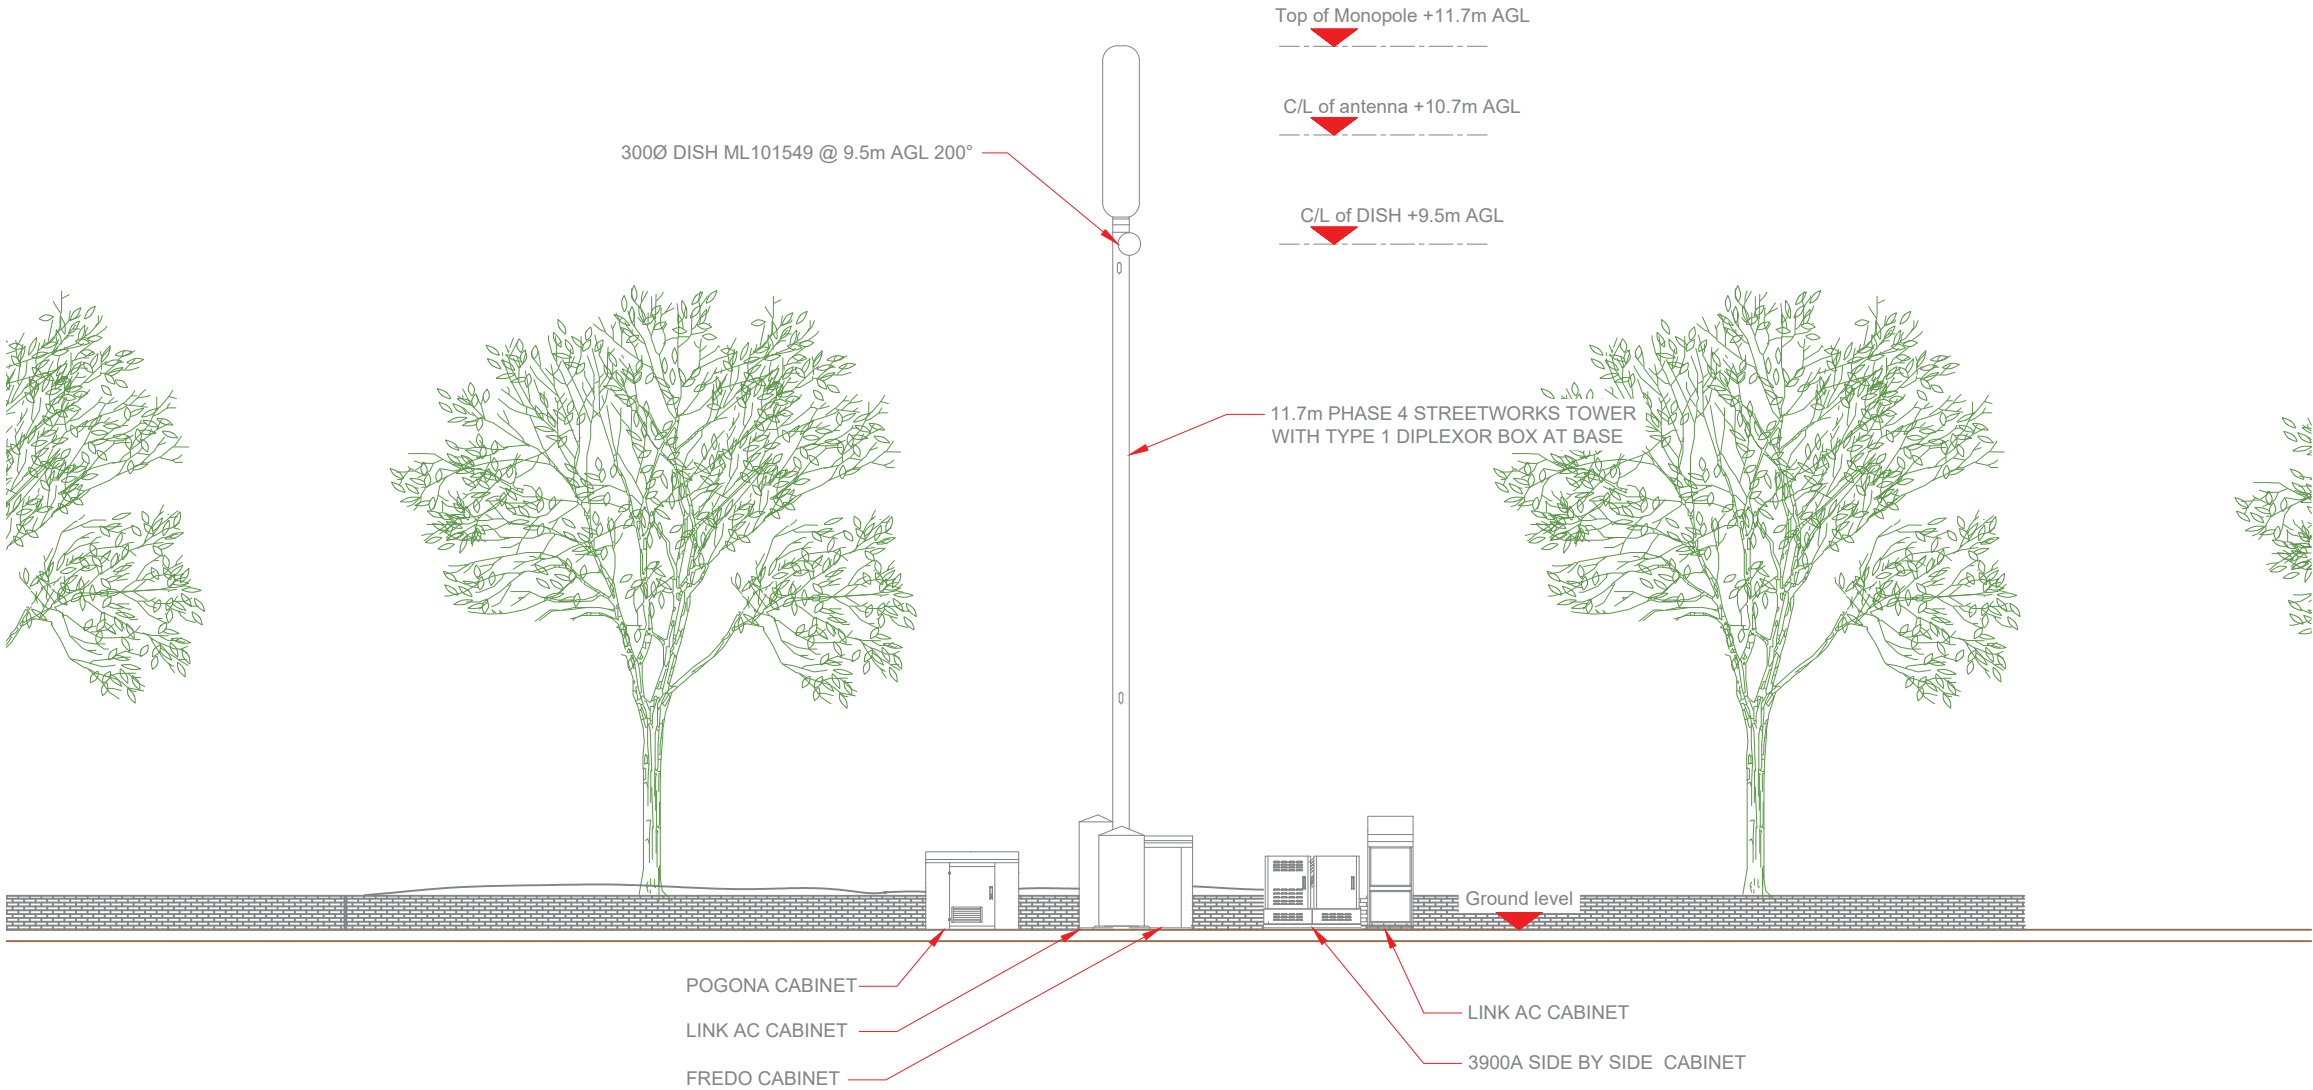

3G Antenna ID	Existing 3G Bearing
uA1	0°
uB1	120°
uC1	240°

NOTES:

1. ALL DIMENSIONS IN MM UNLESS OTHERWISE NOTED.


Master: M001	MBNL / EE / H3G:	Project: T&A	Purpose of Issue: Planning	Issue: A
Date: 28/01/2020	Drawn: S. Mohan	Revision / Upgrade Description: First Issue		
Checked: T. Clifford	Approved: M. Venner			
 Hutchison 3G UK Limited Star House, 20 Grenfell Road Maidenhead, SL6 1EH Tel: 01628 765 000 Fax: 01628 765 001 H3G Base Station Information line: 0845 6043000 Available 8am-8pm Monday to Friday		 Hatfield Business Park Hatfield Hertfordshire AL10 9BW Tel: 01707 315000 Fax: 01707 319001		
Mobile Broadband Network Limited Sixth Floor, Thames Tower, Station Road, Reading, RG1 1LX				
 UNIT E3 PITTS CLEAVE INDUSTRIAL ESTATE, TAVISTOCK, DEVON, PL19 0PW sales@beaconcomms.co.uk Tel: +44 (0)1822 610610				
Site Name: LOMBARDY RETAIL PARK DNS				
Site ID: 998808				
Address: LOMBARDY RETAIL PARK DNS UXBRIDGE ROAD HAYES LONDON HILLINGDON UB4 0JA				
Title: 150 EXISTING ELEVATION A				
Project: T & A				
Purpose of Issue: GENERAL ARRANGEMENT				
EE Cell ID: 50677		MBNL Cell ID: HGN004		3UK Cell ID: UB0124
Master Drawing No: 998808_HGN004_50677_UB0124_M001				Issue: A




NOTE:
EXISTING SINGLE PHASE 100A SUPPLY TO BE UPGRADED TO 3 PHASE
100A SUPPLY WITHIN MK5 CABINET.
EXISTING BT & TX EQUIPMENT TO BE RELOCATED WITHIN MK5 CABINET

Antenna Aperture ID	Proposed 4G/5G Bearing	Operator: Shared/ EE/H3G
A1	0°	EE
A2	0°	H3G
A3	0°	EE/H3G
A4	0°	EE/H3G
B1	120°	EE
B2	120°	H3G
B3	120°	EE/H3G
B4	120°	EE/H3G
C1	240°	EE
C2	240°	H3G
C3	240°	EE/H3G
C4	240°	EE/H3G

NOTES:
1. ALL DIMENSIONS IN MM UNLESS OTHERWISE NOTED.

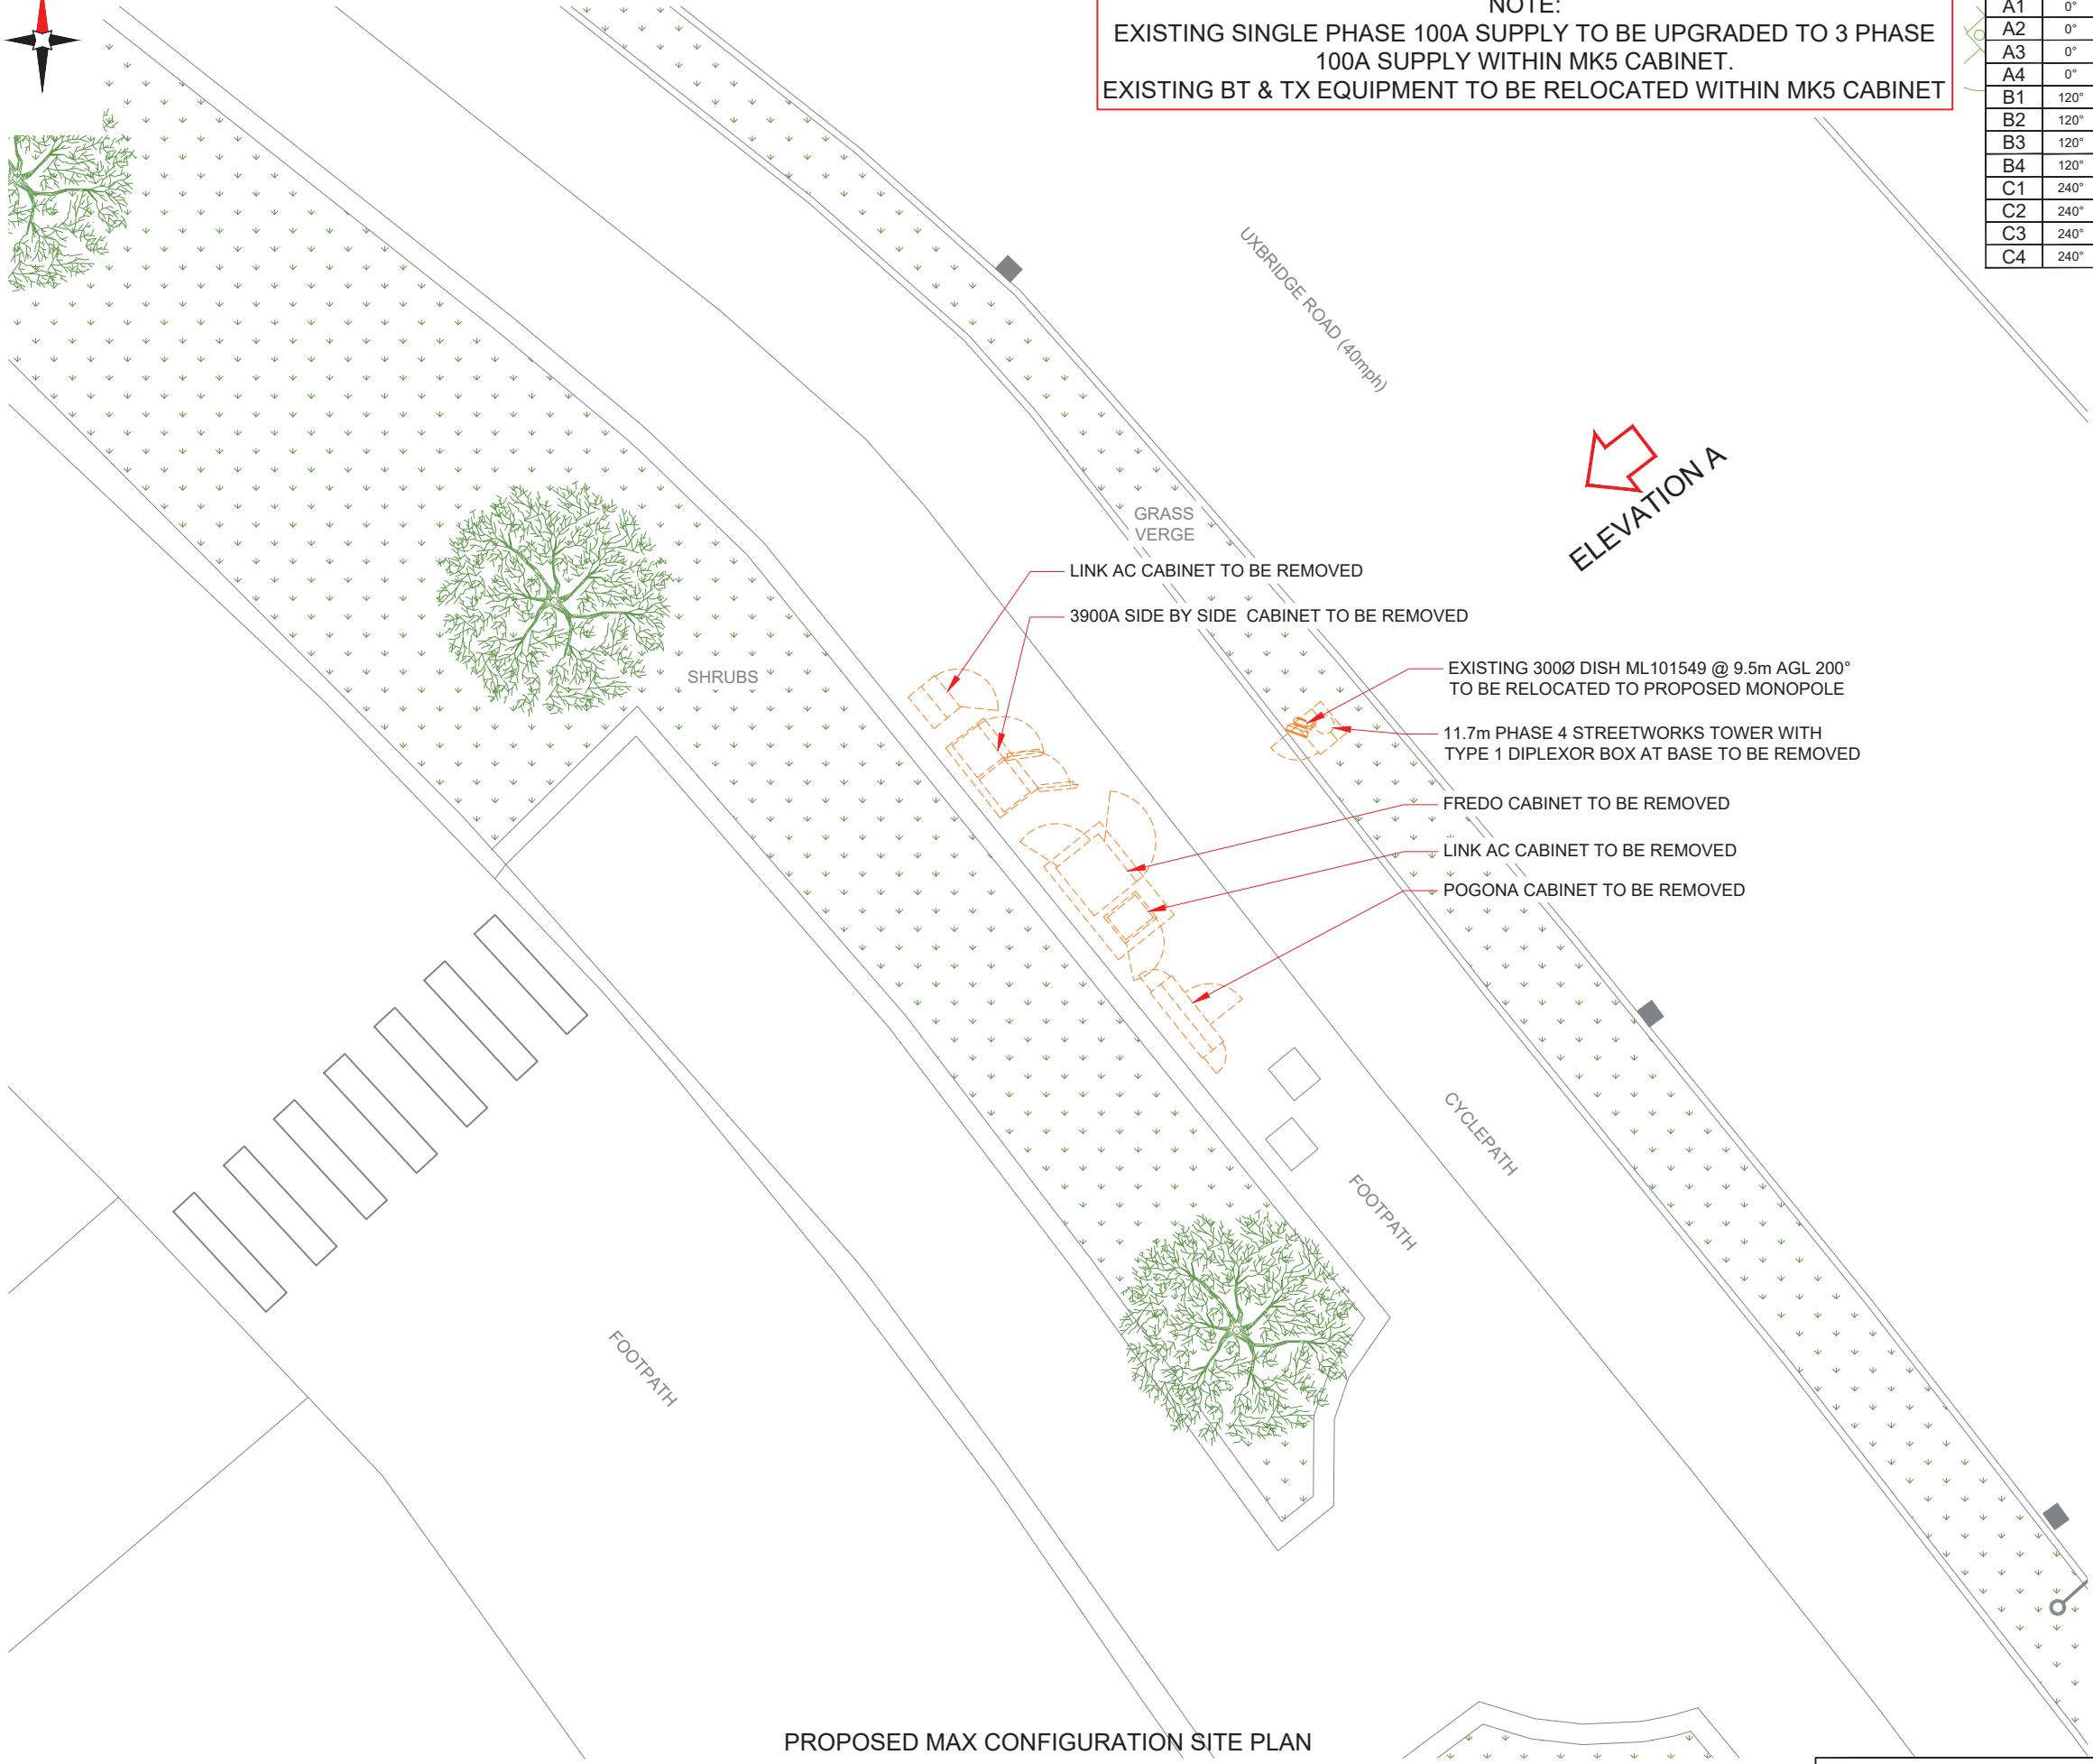

PROPOSED MAX CONFIGURATION SITE PLAN

 

SITE CAPACITY & LEAD OPERATOR			
A	B	C	LEAD
HS2	HS2	HS2	EE

Master: M001

Date: 28/01/2020

Drawn: S. Mohan

Checked: T. Clifford

Approved: M. Venner

MBNL / EE / H3G:

MBNL

Revision / Upgrade Description:

First Issue

Project: T&A

Purpose of Issue: Planning

Issue: A

Hutchison 3G UK Limited
Star House, 20 Grenfell Road
Maidenhead, SL6 1EH
Tel: 01628 765 500
Fax: 01628 765 501

H3G Base Station Information line:
0845 6043000
Available 8am-8pm Monday to Friday

Hatfield Business Park
Hatfield
Hertfordshire
AL10 9BW

Tel: 01707 315000
Fax: 01707 319001

MBNL Mobile Broadband Network Limited
Sixth Floor, Thames Tower, Station Road, Reading, RG1 1LX

BEACONCOMMS

UNIT E3 PITTS CLEAVE INDUSTRIAL ESTATE, TAVISTOCK, DEVON, PL19 0PW
sales@beaconcomms.co.uk

Tel: +44 (0)1822 610610

Site Name:
LOMBARDY RETAIL PARK DNS

Site ID:
998808

Address:
LOMBARDY RETAIL PARK DNS
UXBRIDGE ROAD
HAYES LONDON
HILLINGDON
UB4 0JA

Title:
215 MAX CONFIGURATION SITE PLAN
- SHEET 1

Project:
T & A

Purpose of Issue:
GENERAL ARRANGEMENT

EE Cell ID:
50677

MBNL Cell ID:
HGN004

3UK Cell ID:
UB0124

Master Drawing No:
998808_HGN004_50677_UB0124_M001

Issue:
A



NOTE:
EXISTING SINGLE PHASE 100A SUPPLY TO BE UPGRADED TO 3 PHASE
100A SUPPLY WITHIN MK5 CABINET.
EXISTING BT & TX EQUIPMENT TO BE RELOCATED WITHIN MK5 CABINET

Antenna Aperture ID	Proposed 4G/5G Bearing	Operator: Shared/ EE/H3G
A1	0°	EE
A2	0°	H3G
A3	0°	EE/H3G
A4	0°	EE/H3G
B1	120°	EE
B2	120°	H3G
B3	120°	EE/H3G
B4	120°	EE/H3G
C1	240°	EE
C2	240°	H3G
C3	240°	EE/H3G
C4	240°	EE/H3G

NOTES:
1. ALL DIMENSIONS IN MM UNLESS OTHERWISE NOTED.

EXISTING LAMP POST

GRASS AREA

EXISTING 300Ø DISH ML101549 @ 9.5m AGL 200°
TO BE RELOCATED TO PROPOSED MONOPOLE

PROPOSED 1No. MK5 LINK AC CABINET TO BE
INSTALLED ON PROPOSED CONCRETE PLINTH

PROPOSED 1No. HUAWEI CABINET TO BE
INSTALLED ON PROPOSED CONCRETE PLINTH

PROPOSED 1No. WILTSHIRE CABINET TO BE
INSTALLED ON PROPOSED CONCRETE PLINTH

PROPOSED 12No. ANTENNA APERTURES TO BE INSTALLED
ON PROPOSED STREETWORKS MONOPOLE

PROPOSED 20m HIGH STREETWORKS MONOPOLE,
TO BE INSTALLED APPROXIMATELY 14.8m FROM THE
EXISTING LOCATION AT NGR E: 510924 N: 180975

PROPOSED DIPLEXER CABINET TO BE
INSTALLED ON PROPOSED CONCRETE PLINTH

PROPOSED 2No. HUAWEI CABINETS TO BE
INSTALLED ON PROPOSED CONCRETE PLINTH

 
PROPOSED 1No. APM5930 CABINET TO BE
INSTALLED ON PROPOSED CONCRETE PLINTH

PROPOSED 1No. POGONA CABINET TO BE
INSTALLED ON PROPOSED CONCRETE PLINTH

ELEVATION A

UXBRIDGE ROAD (40mph)

PROPOSED MAX CONFIGURATION SITE PLAN



SITE CAPACITY & LEAD OPERATOR			
A	B	C	LEAD
HS2	HS2	HS2	EE



Hutchison 3G UK Limited
Star House, 20 Grenfell Road
Maidenhead, SL6 1EH
Tel: 01628 765 500
Fax: 01628 765 501

H3G Base Station Information line:
0845 6043000
Available 8am-8pm Monday to Friday



Hatfield Business Park
Hatfield
Hertfordshire
AL10 9BW

Tel: 01707 315000
Fax: 01707 319001



Mobile Broadband Network Limited
Sixth Floor, Thames Tower, Station Road, Reading, RG1 1LX



BEACONCOMMS

UNIT E3 PITTS CLEAVE INDUSTRIAL ESTATE, TAVISTOCK, DEVON, PL19 0PW
sales@beaconcomms.co.uk
Tel: +44 (0)1822 610610

Site Name:
LOMBARDY RETAIL PARK DNS

Site ID:
998808

Address:
LOMBARDY RETAIL PARK DNS
UXBRIDGE ROAD
HAYES LONDON
HILLINGDON
UB4 0JA

Title: 216 MAX CONFIGURATION SITE PLAN
- SHEET 2

Project:
T & A


Purpose of Issue:
GENERAL ARRANGEMENT

EE Cell ID: 50677	MBNL Cell ID: HGN004	3UK Cell ID: UB0124
----------------------	-------------------------	------------------------

Master Drawing No:
998808_HGN004_50677_UB0124_M001

Issue:
A

NOTE:
EXISTING SINGLE PHASE 100A SUPPLY TO BE UPGRADED TO 3 PHASE
100A SUPPLY WITHIN MK5 CABINET.
EXISTING BT & TX EQUIPMENT TO BE RELOCATED WITHIN MK5 CABINET

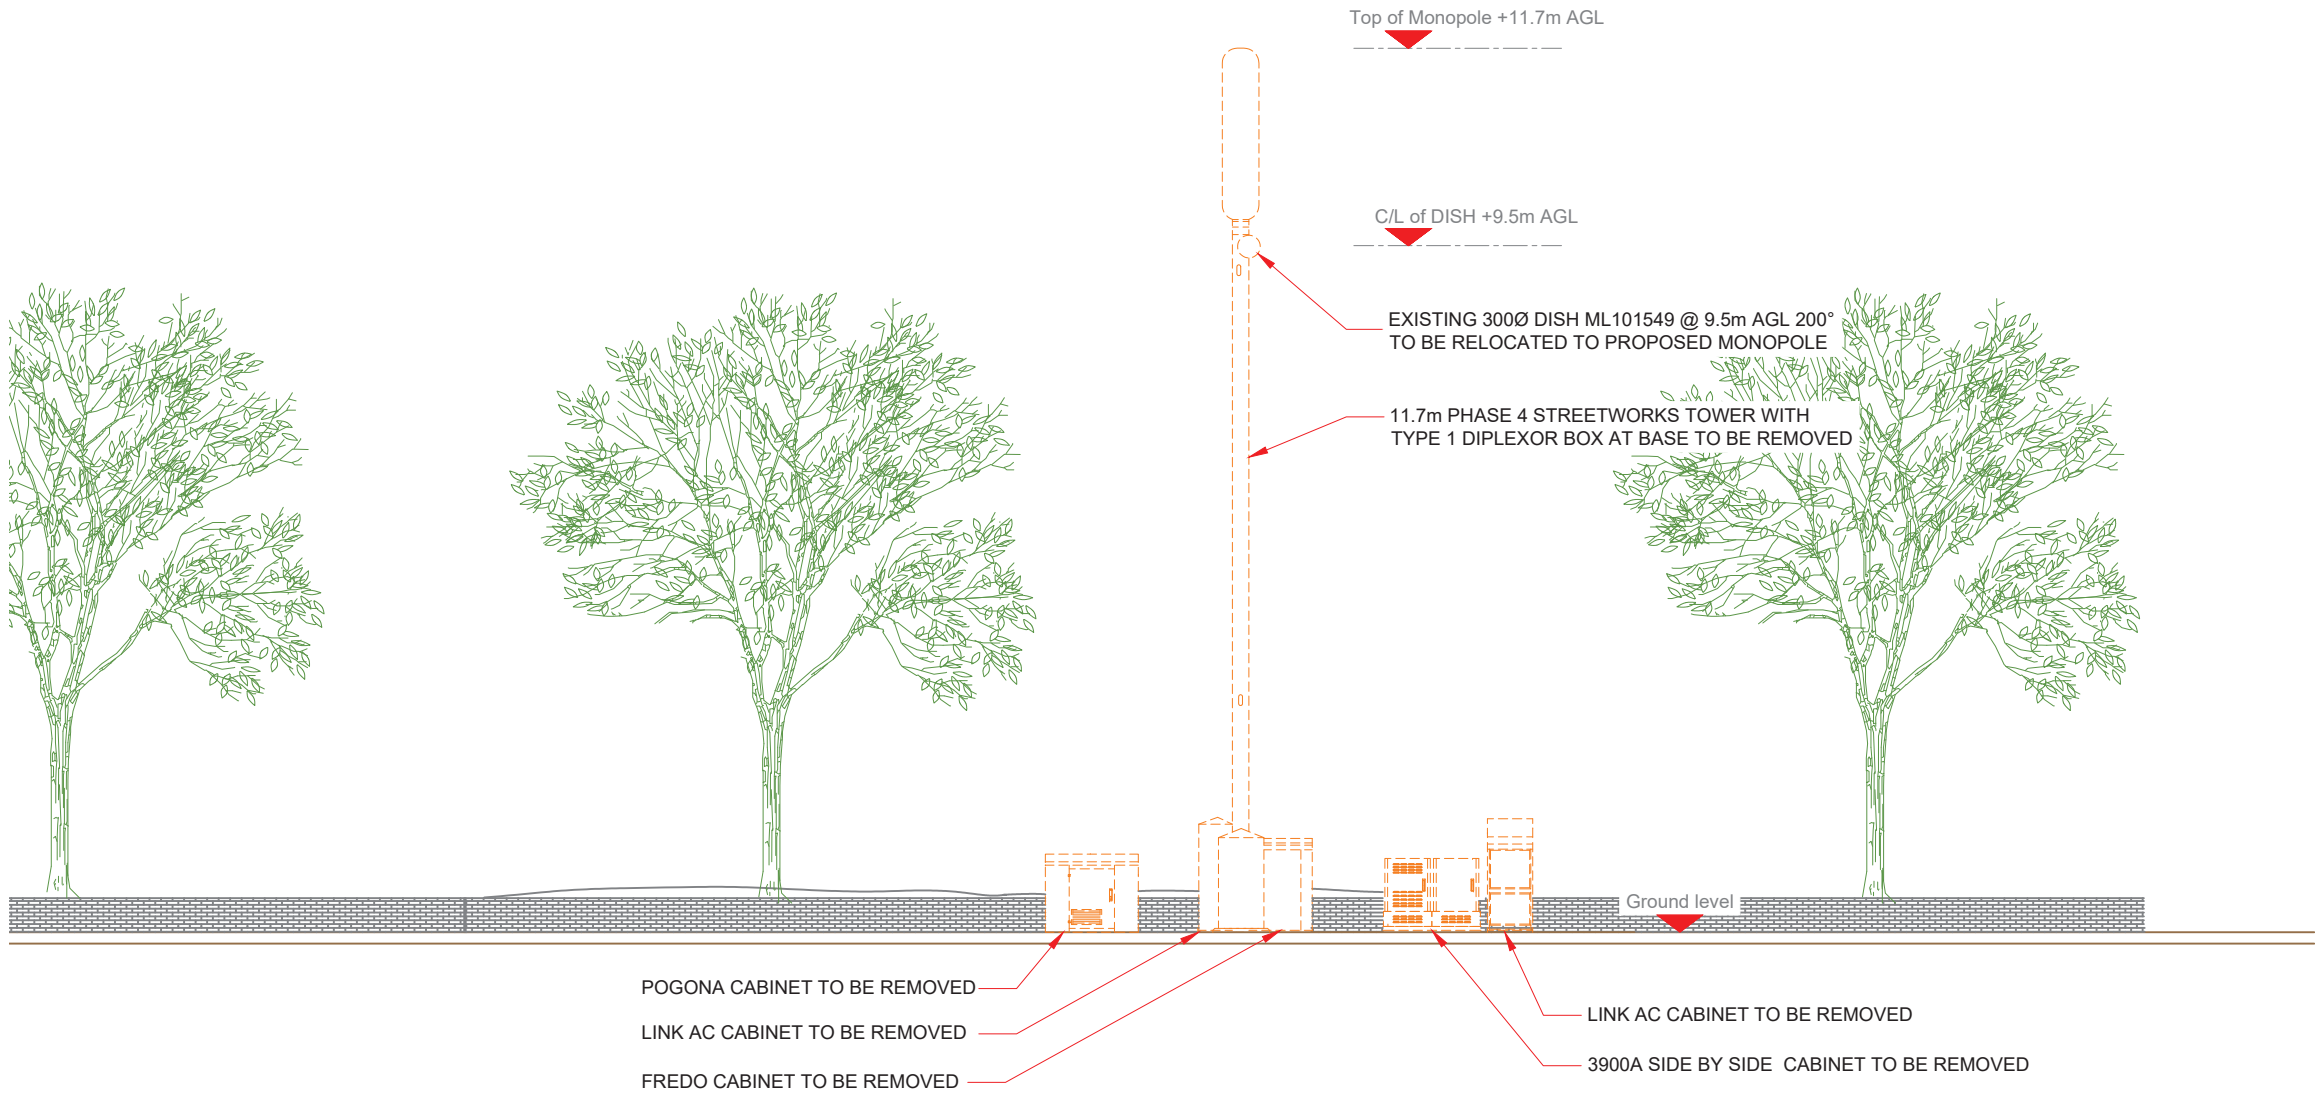

Antenna Aperture ID	Proposed 4G/5G Bearing	Operator: Shared/ EE/H3G
A1	0°	EE
A2	0°	H3G
A3	0°	EE/H3G
A4	0°	EE/H3G
B1	120°	EE
B2	120°	H3G
B3	120°	EE/H3G
B4	120°	EE/H3G
C1	240°	EE
C2	240°	H3G
C3	240°	EE/H3G
C4	240°	EE/H3G

NOTES:
1. ALL DIMENSIONS IN MM UNLESS OTHERWISE NOTED.

Master: M001

MBNL / EE / H3G:

Project: T&A

Purpose of Issue: Planning

Issue: A

Date: 28/01/2020

Drawn: S. Mohan

Checked: T. Clifford

Approved: M. Venner

Revision / Upgrade Description: First Issue



Hutchison 3G UK Limited
Star House, 20 Grenfell Road
Maidenhead, SL6 1EH
Tel: 01628 765 000
Fax: 01628 765 001

H3G Base Station Information line:
0845 6043000
Available 8am-8pm Monday to Friday



Hatfield Business Park
Hatfield
Hertfordshire
AL10 9BW

Tel: 01707 315000
Fax: 01707 319001

MBNL Mobile Broadband Network Limited
Sixth Floor, Thames Tower, Station Road, Reading, RG1 1LX



UNIT E3 PITTS CLEAVE INDUSTRIAL ESTATE, TAVISTOCK, DEVON, PL19 0PW
sales@beaconcomms.co.uk



Tel: +44 (0)1822 610610

Site Name:
LOMBARDY RETAIL PARK DNS

Site ID:
998808

Address:
LOMBARDY RETAIL PARK DNS
UXBRIDGE ROAD
HAYES LONDON
HILLINGDON
UB4 0JA

Title:
265 MAX CONFIGURATION ELEVATION -
SHEET 1

Project:
T & A


Purpose of Issue:
GENERAL ARRANGEMENT

EE Cell ID: 50677	MBNL Cell ID: HGN004	3UK Cell ID: UB0124
----------------------	-------------------------	------------------------

Master Drawing No: 998808_HGN004_50677_UB0124_M001	Issue: A
---	-------------

SITE CAPACITY & LEAD OPERATOR			
A	B	C	LEAD
HS2	HS2	HS2	EE

NOTE:
EXISTING SINGLE PHASE 100A SUPPLY TO BE UPGRADED TO 3 PHASE
100A SUPPLY WITHIN MK5 CABINET.
EXISTING BT & TX EQUIPMENT TO BE RELOCATED WITHIN MK5 CABINET

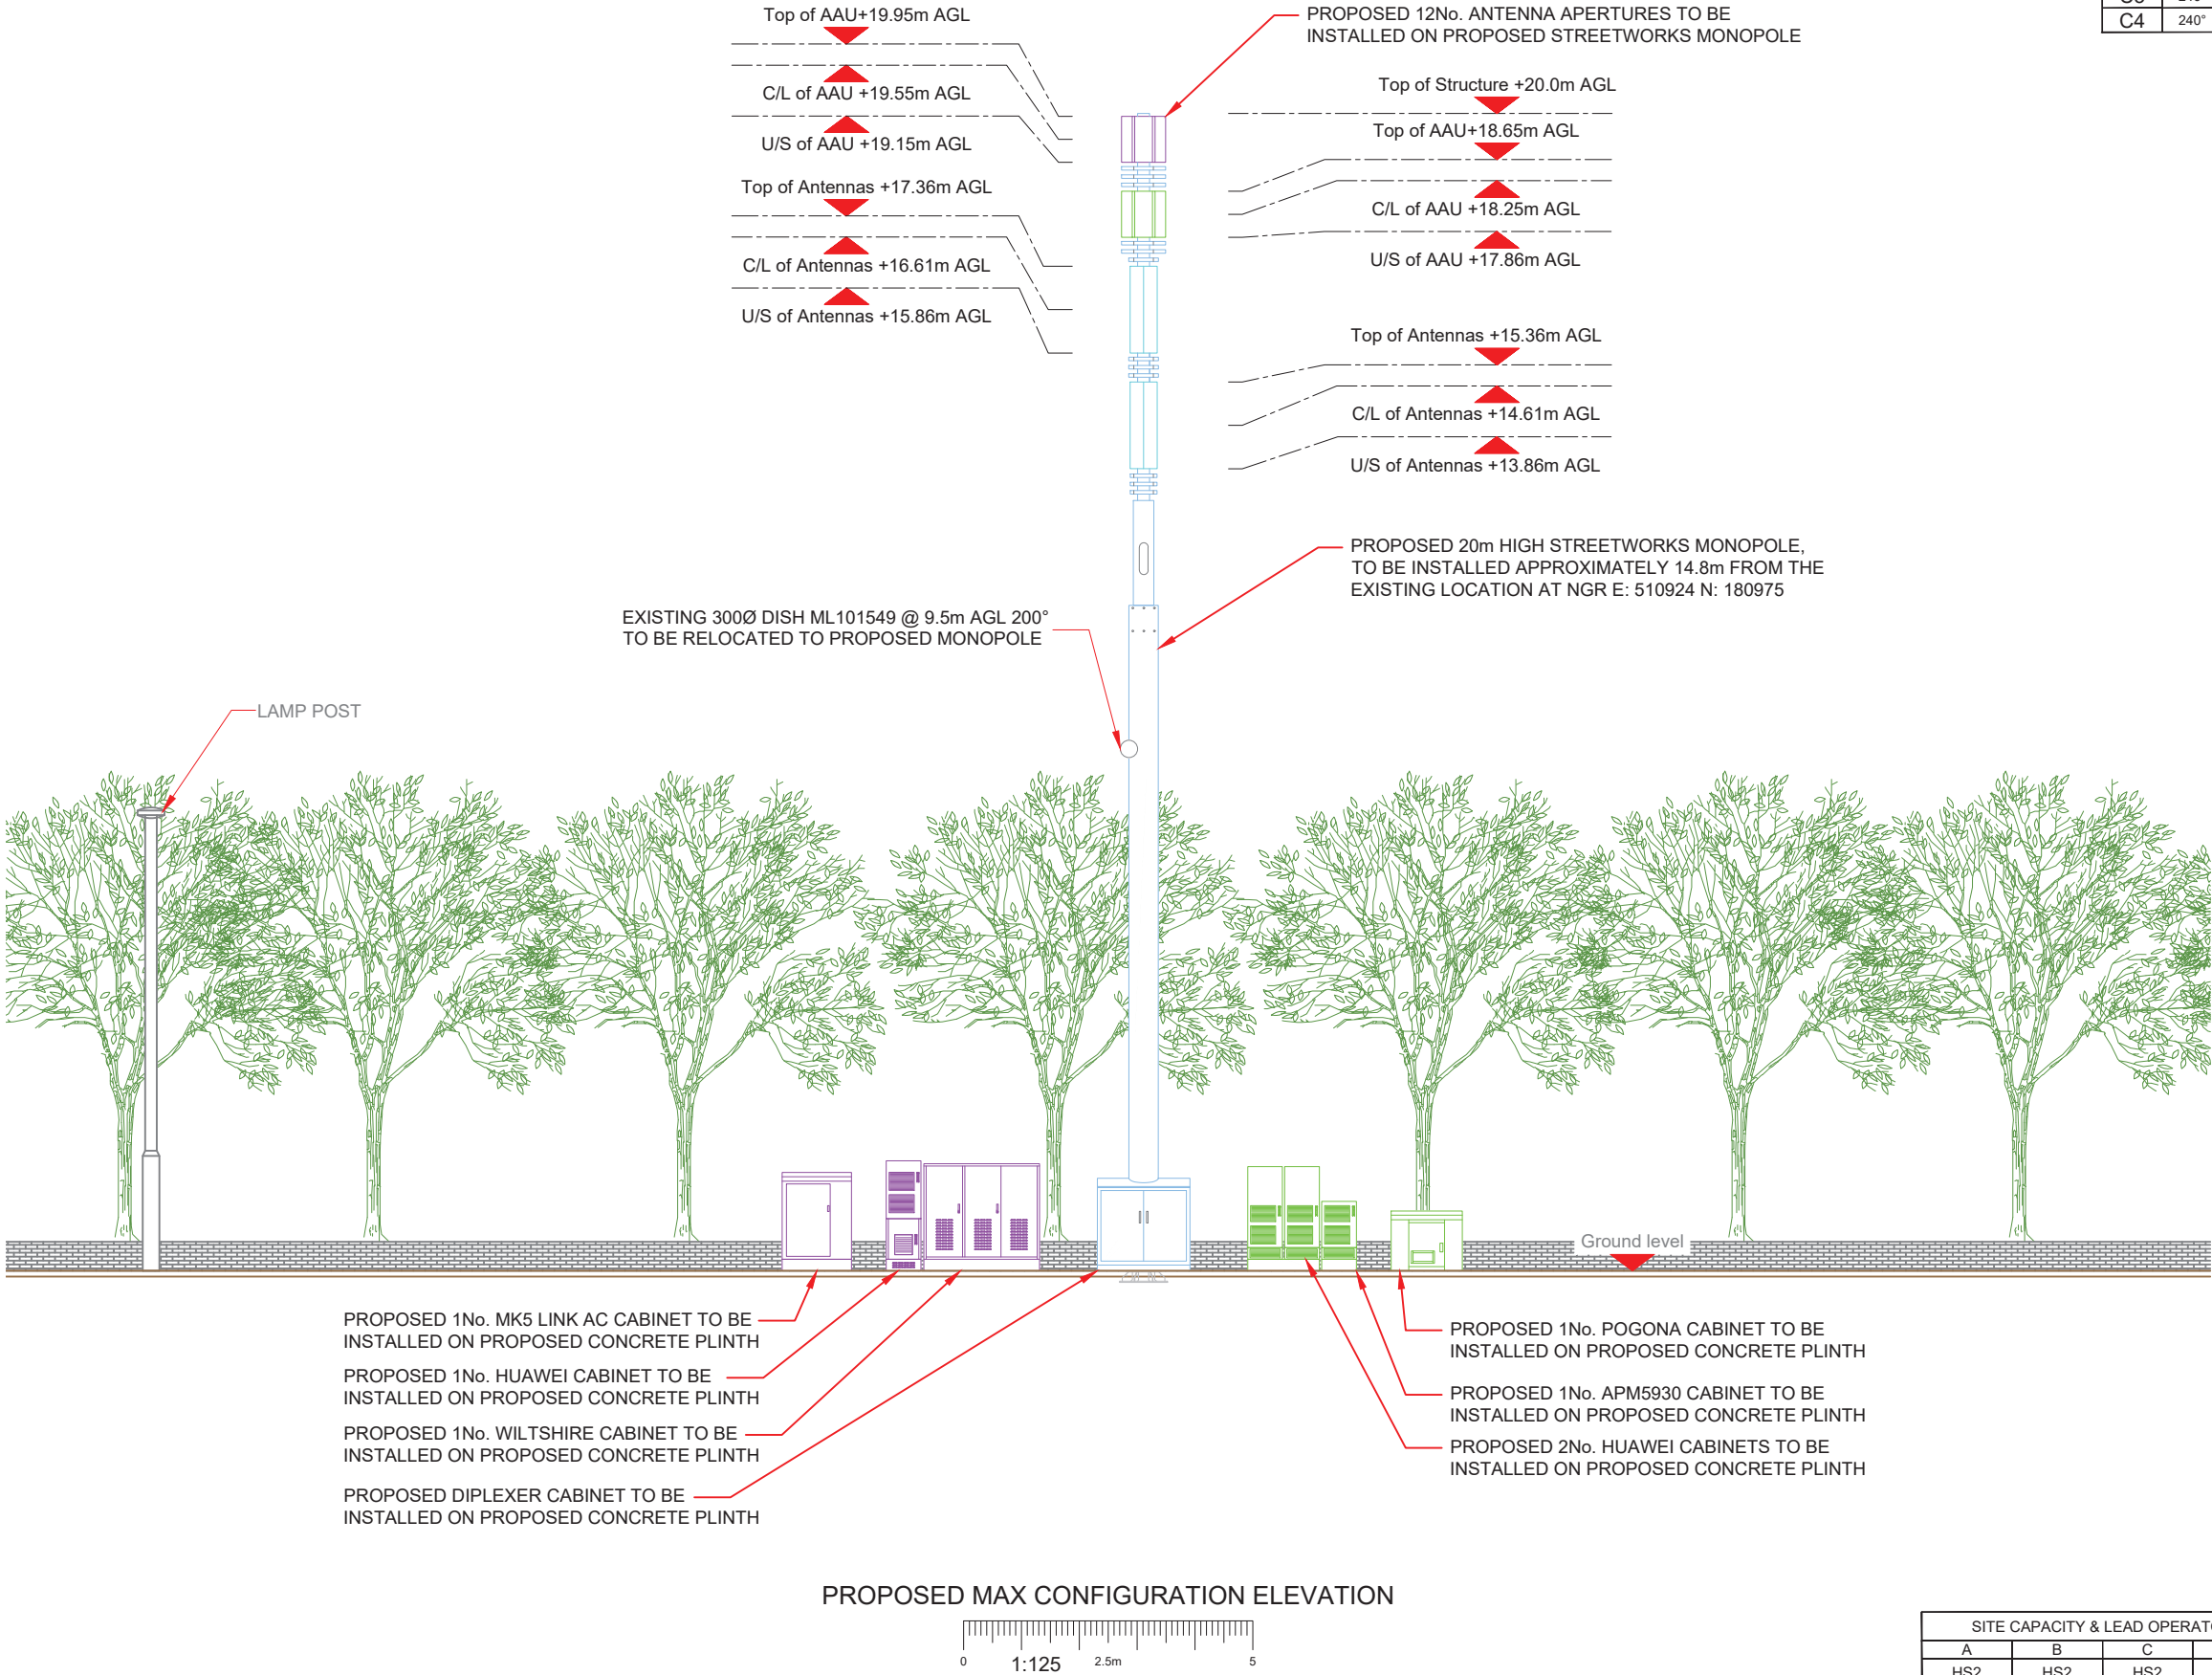

NOTES:
1. ALL DIMENSIONS IN MM UNLESS OTHERWISE NOTED.

Master:	MBNL / EE / H3G:	Project:	Purpose of Issue:	Issue:
M001	MBNL	T&A	Planning	A
Date:	28/01/2020	Revision / Upgrade Description:		
Drawn:	S. Mohan	First Issue		
Checked:	T. Clifford			
Approved:	M. Venner			



Hutchison 3G UK Limited
Star House, 20 Grenfell Road
Maidenhead, SL6 1EH
Tel: 01628 765 000
Fax: 01628 765 001



Hatfield Business Park
Hatfield
Hertfordshire
AL10 9BW

Tel: 01707 315000
Fax: 01707 319001



Mobile Broadband Network Limited
Sixth Floor, Thames Tower, Station Road, Reading, RG1 1LX



UNIT E3 PITTS CLEAVE INDUSTRIAL ESTATE, TAVISTOCK, DEVON, PL19 0PW
sales@beaconcomms.co.uk

Tel: +44 (0)1822 610610

Site Name:	LOMBARDY RETAIL PARK DNS		
Site ID:	998808		
Address:	LOMBARDY RETAIL PARK DNS UXBRIDGE ROAD HAYES LONDON HILLINGDON UB4 0JA		
Title:	266 MAX CONFIGURATION ELEVATION - SHEET 2		
Project:	T & A		
Purpose of Issue:	GENERAL ARRANGEMENT		
EE Cell ID:	50677	MBNL Cell ID:	HGN004
		3UK Cell ID:	UB0124
Master Drawing No:	998808_HGN004_50677_UB0124_M001		Issue:
			A

SITE CAPACITY & LEAD OPERATOR			
A	B	C	LEAD
HS2	HS2	HS2	EE