
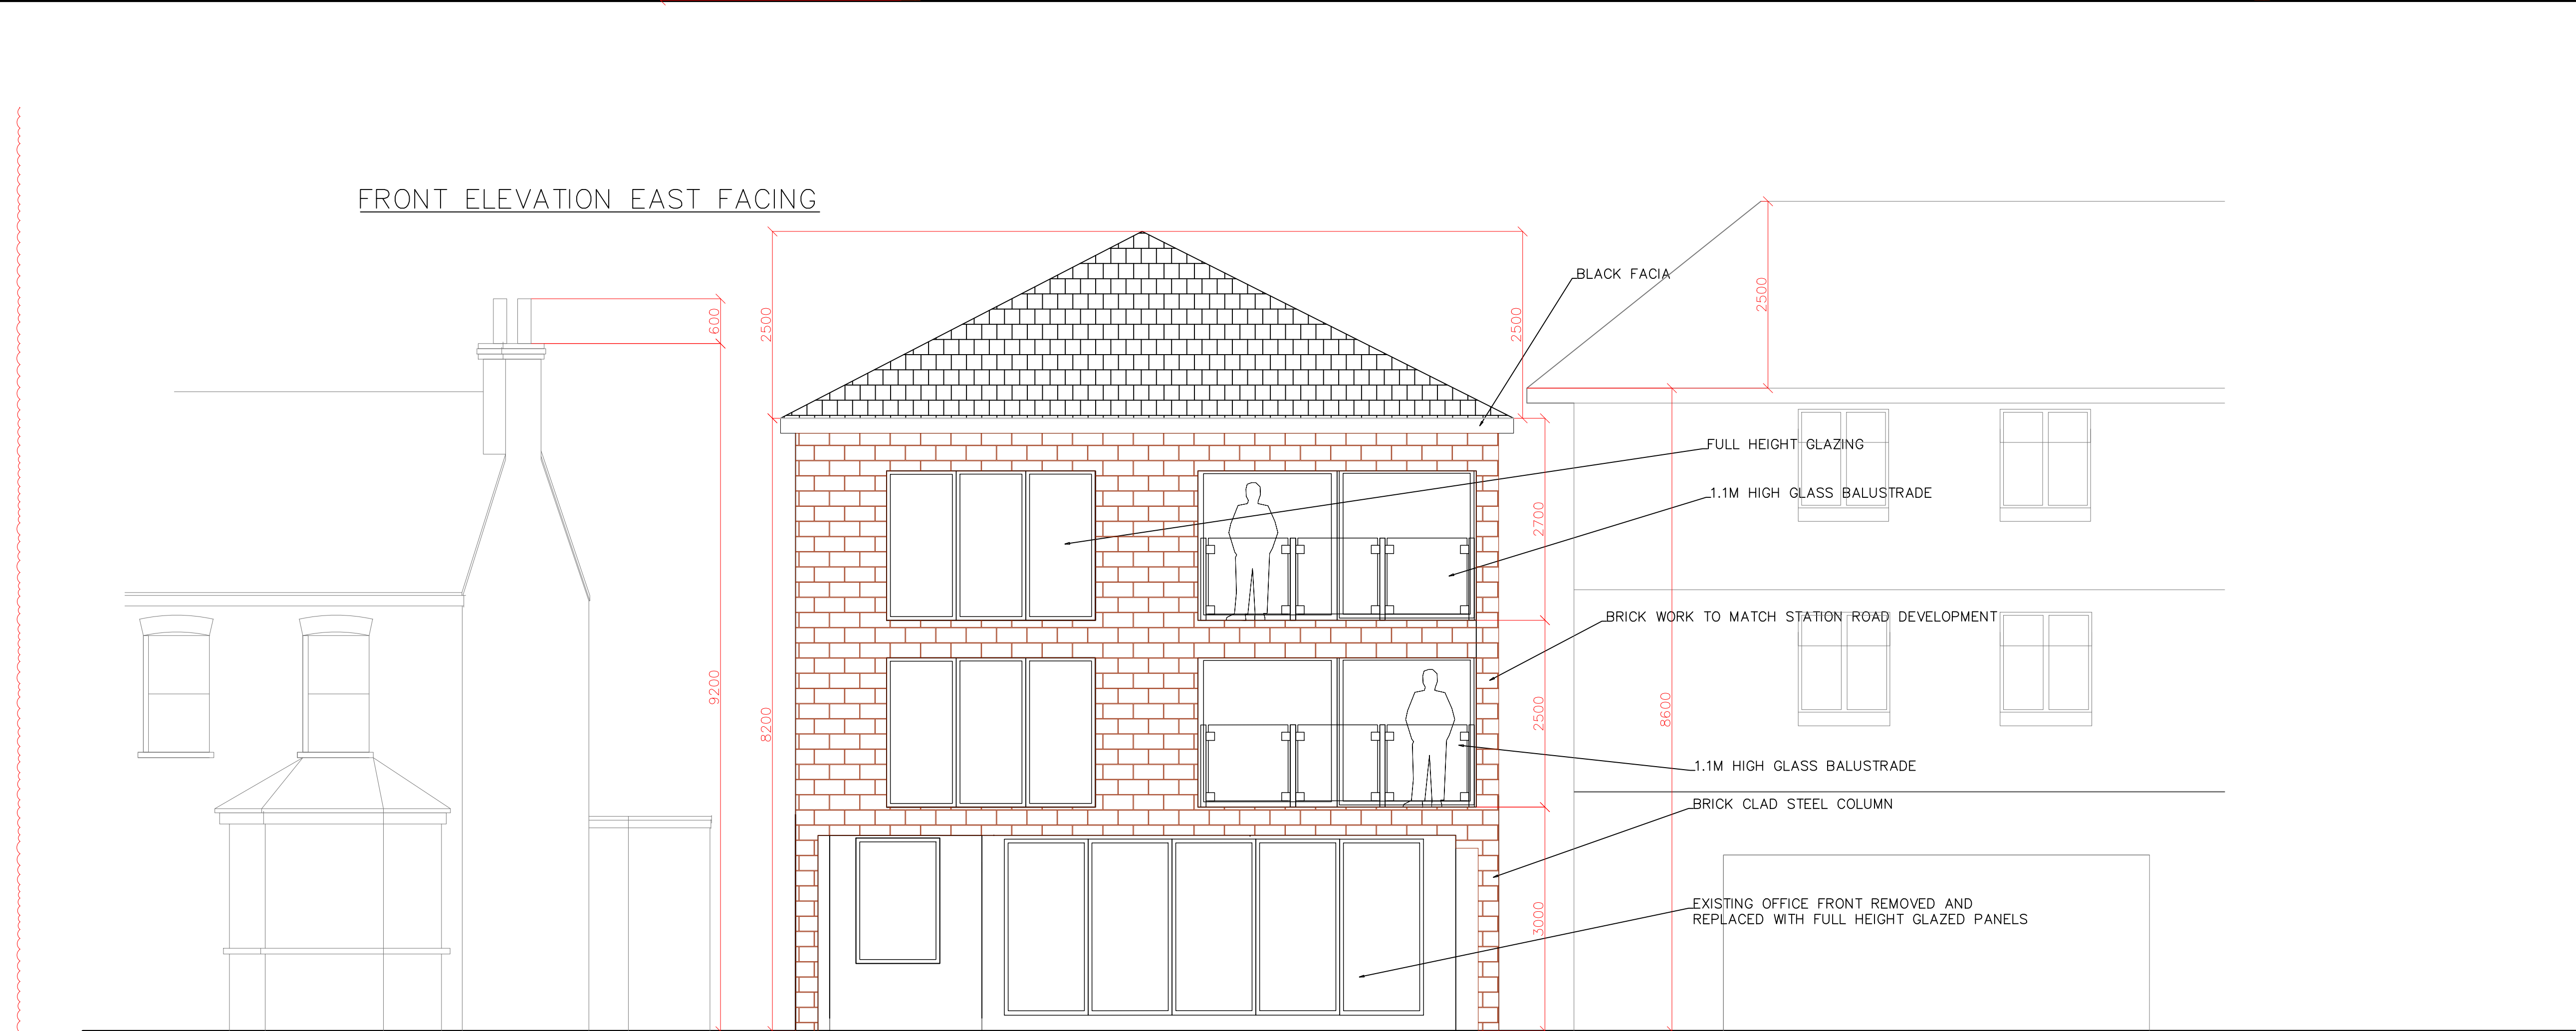


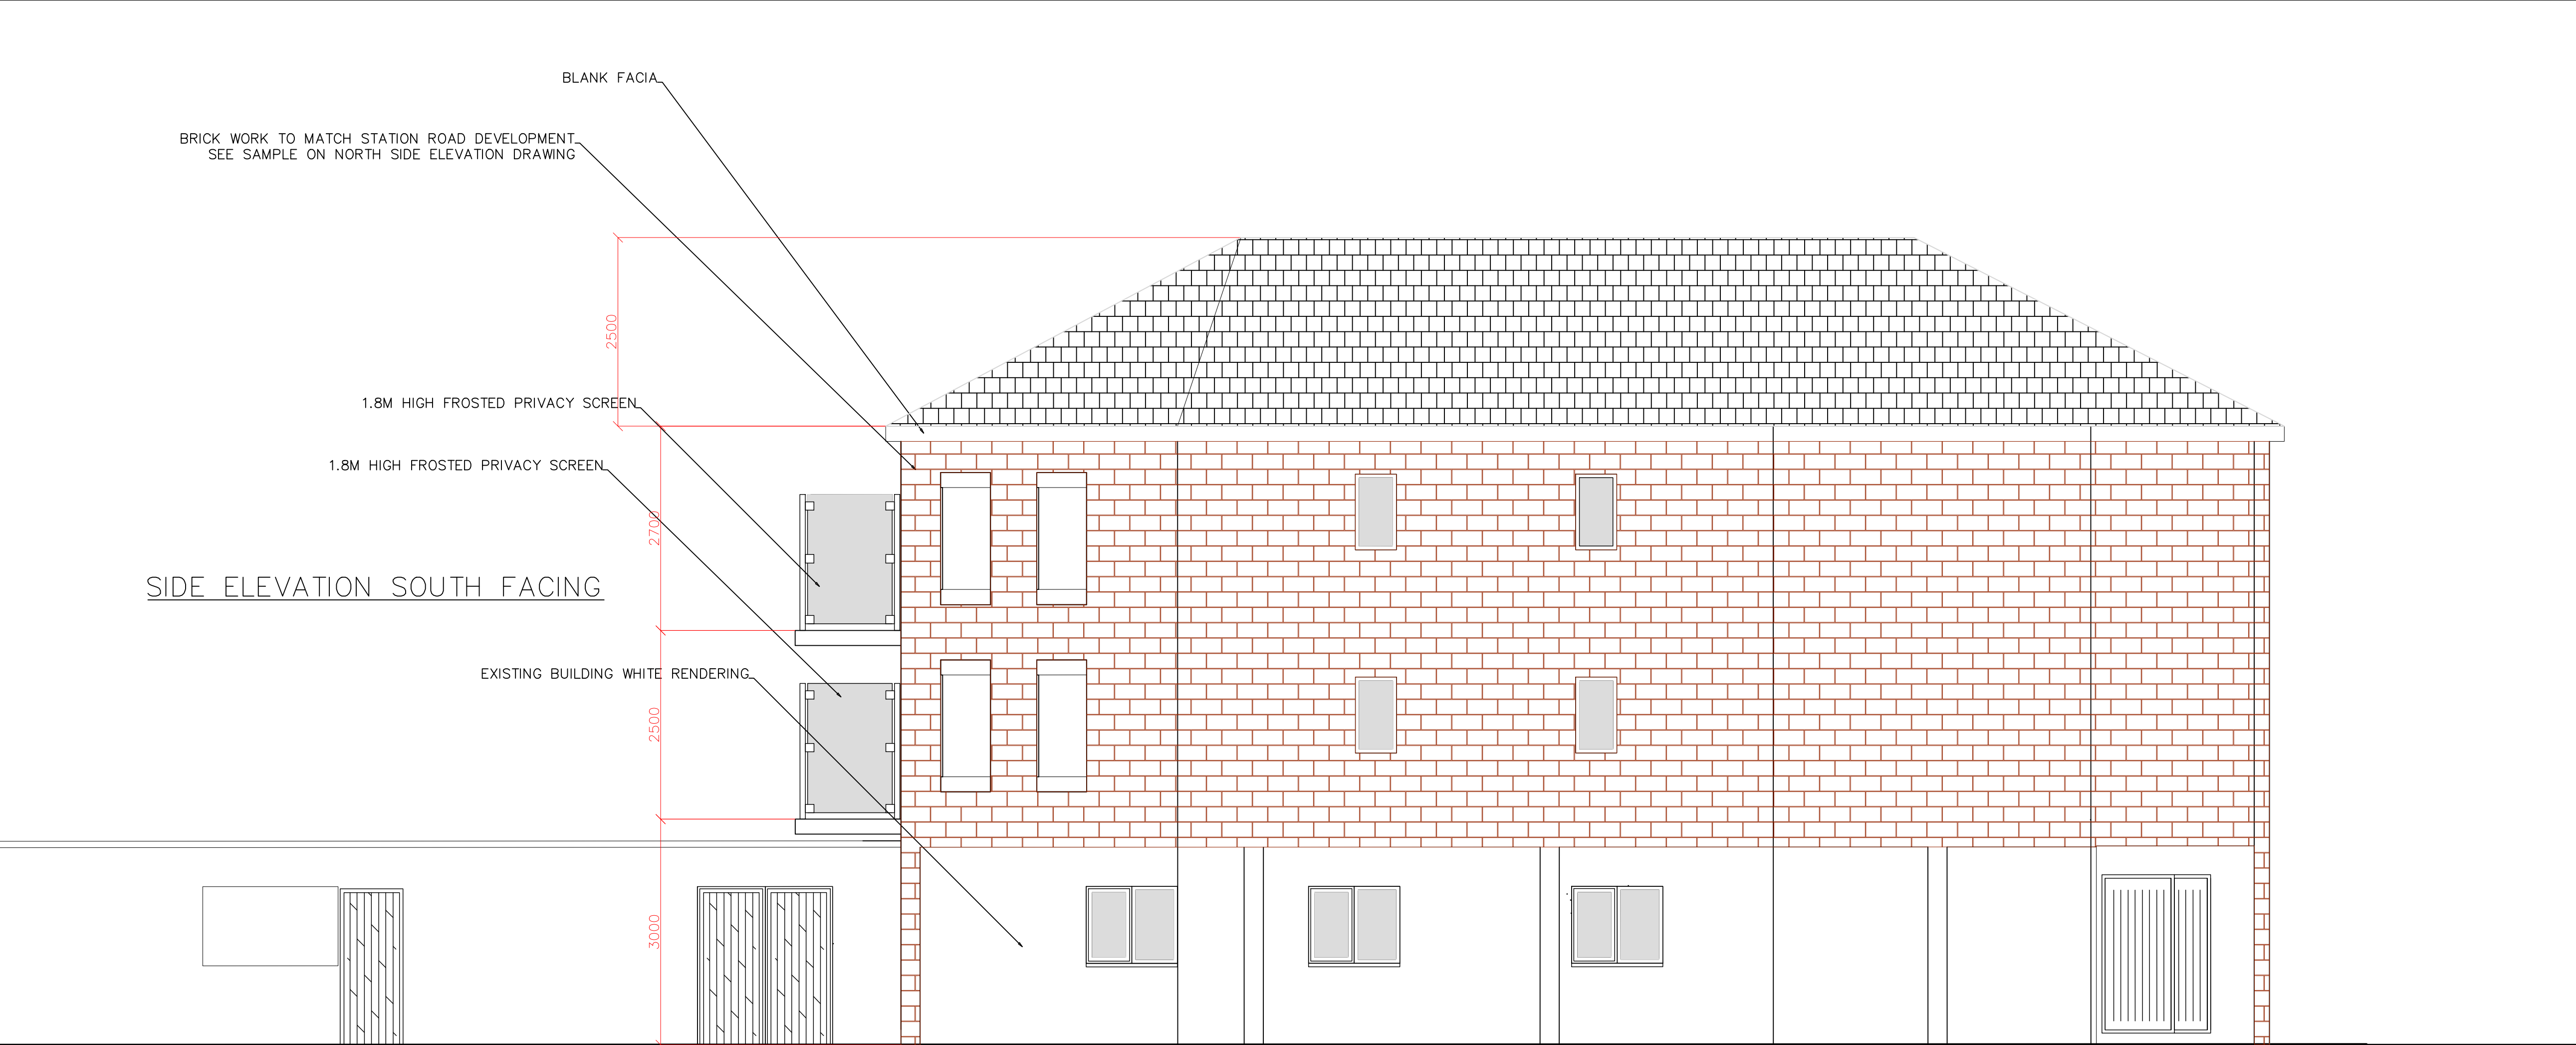

9 WARWICK ROAD

11 WARWICK ROAD

PULLMAN COURT

PROPOSED

Legend

Client:

SOUTHBOURNE ELECTRICAL



SOUTHBOURNE ELECTRICAL SERVICES LIMITED

11, WARWICK ROAD, WEST DRAYTON

MIDDLESEX UB7 9BT

TEL: 01895 847417

CAD DEPARTMENT: JAMES@SOUTHBOURNE-ELECTRICAL.CO.UK

Project:

000

11 WARWICK ROAD

WEST DRAYTON

Title:

EAST AND SOUTH ELEVATIONS

PROPOSED FLATS

OPTION 1

Drawn by:

JR

Checked by:

JF

Scale:

1:50@A1

Revision:

2

Date:

10.01.22

Drawing no.:

SES-000-1-ESE