 


Initial Issue based on Architects Draw No. A102-100-B				Initial
No	Date	Revision		





COLD CARE
Air Conditioning & Ventilation Engineers


Unit 1
The Broadway Industrial Estate
Marsfield
Northamptonshire
NN3 7JH
Telephone 01623 428276
Fax 01623 653865
Email enquiries@hvaccare.com
Web www.hvaccare.com

Client
Lawrence Baker

Approved
Hay Associates

Job No.
New Care Home
Ryefield Care Home
Hillingdon
UB10 9DE

Scale 1:100(A4) 1:200(A3)	Date -	Drawn by -	Checked -
Drawn Date North Elevation Plan			
PRELIMINARY			

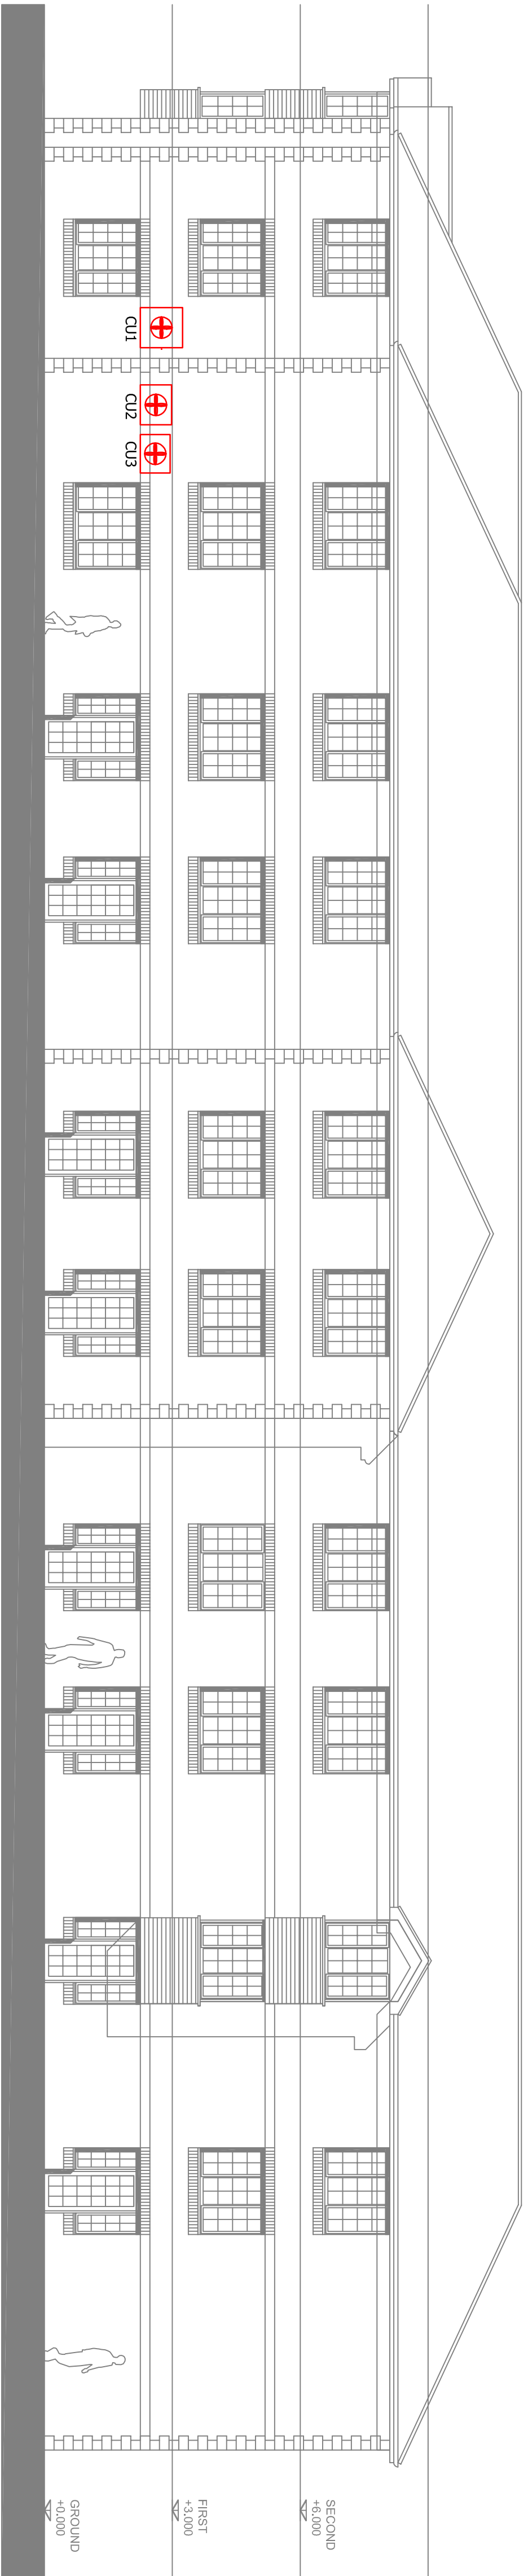

AC Schedule			
Indoor Units	Dimensions H/W/D	weight	Outdoor Unit
Power Required by others			
Basement			
FCU 1	FTXS20	289*780*215	8
			CU 2
			CCL to provide
GF			
FCU 2	FTXS20	289*780*215	8
			CU2
FCU 3	FCOHG50F	204*950*950	19
			CCL to provide
FCU 4	FCOHG50F	204*950*950	19
			CU1
			CCL to provide
FF			
FCU 5	FTXS20	289*780*215	8
			CU2
			CCL to provide
SF			
FCU 6	FCOHG71F	204*950*950	21
			CU3
FCU 7	FTXS20	289*780*215	8
			CU2
			CCL to provide
Outdoor Units			
			dB(A)
CU 1	RZOSG100L	1430*940*320	102 KG
			52
CU 2	4MXS88F	735*936*300	58 KG
			49
CU3	RZOSG71L	990*940*320	78 KG
			49
			20 amp 230V/1ph/50Hz
Ref			
Piping Schedule	wiring schedule		Joint Schedule
CU1	Condensate Drain		J1
			KHRQ22M20T
C2	5/8" & 3/8"	3 + E 2.5mm SY	
B2	1/2" & 1/4"	3 + E 1.5mm SY	
A2	3/8" & 1/4"	3 + E 1.5mm SY	

DRAWING STATUS

PRELIMINARY STATUS ISSUE IS TO ALLOW AGREEMENT OF THE DESIGN CONCEPT, PIPEWORK ROUTES AND RADIATOR LOCATIONS.

FOR APPROVAL STATUS DRAWINGS WILL BE ISSUED UPON AGREEMENT OF DESIGN CONCEPT, PIPEWORK ROUTES AND RADIATOR POSITIONS.

CONSTRUCTION STATUS DRAWINGS WILL BE ISSUED ONCE COMMENTS FROM FOR APPROVAL STATUS HAVE BEEN RECEIVED FROM ALL PARTIES.