

LEGEND

- Indicates proposed foul water drainage run.
- Indicates proposed surface water drainage run.
- Indicates existing foul water drainage run.
- Indicates existing surface water drainage run.

Means of escape opening light. See Notes.

Smoke Detector

Heat Detector

Mechanical Extract Fan

SVP 100mm Soil & Vent Pipe

SS 100mm Stub Stack

Back liner Gully

Foul Water Waste Pipe

75mm² RWP & gully


68mm² RWP & gully

Indicates load bearing timber stud partition.


Indicates non-load bearing timber stud partition.

Indicates thermally insulated plasterboard.


The Rooflight Company CR09-2
Rooflight type:

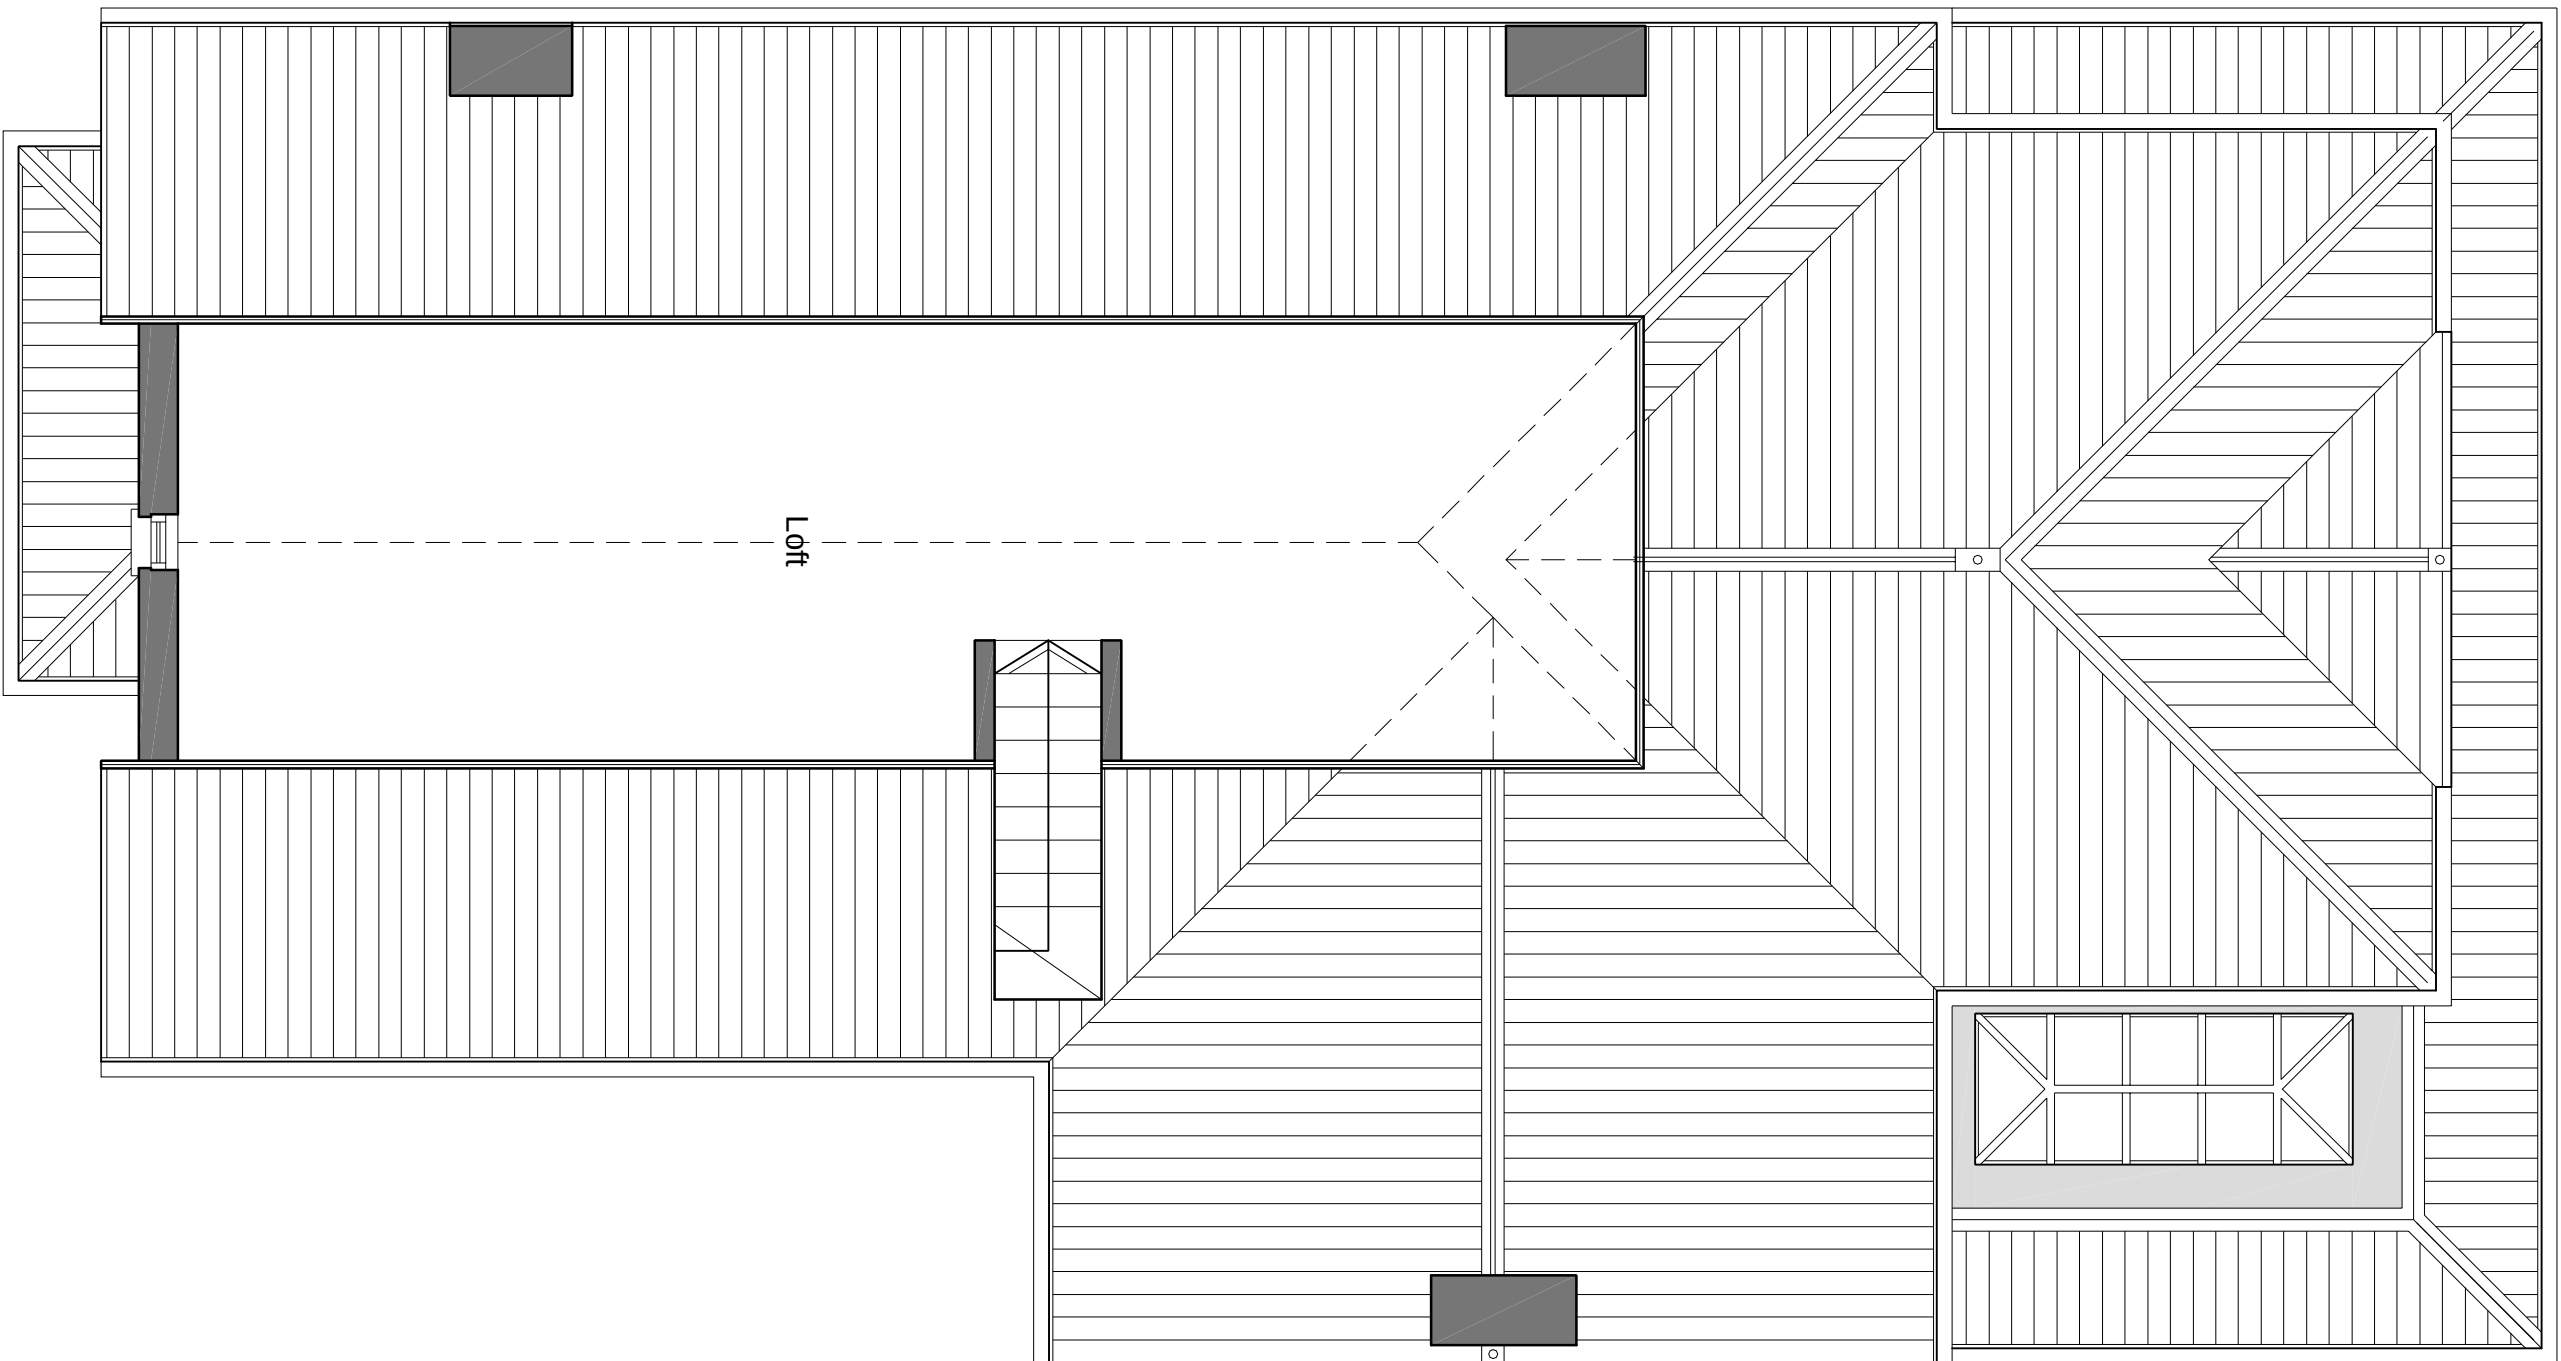


EXISTING LOFT PLAN

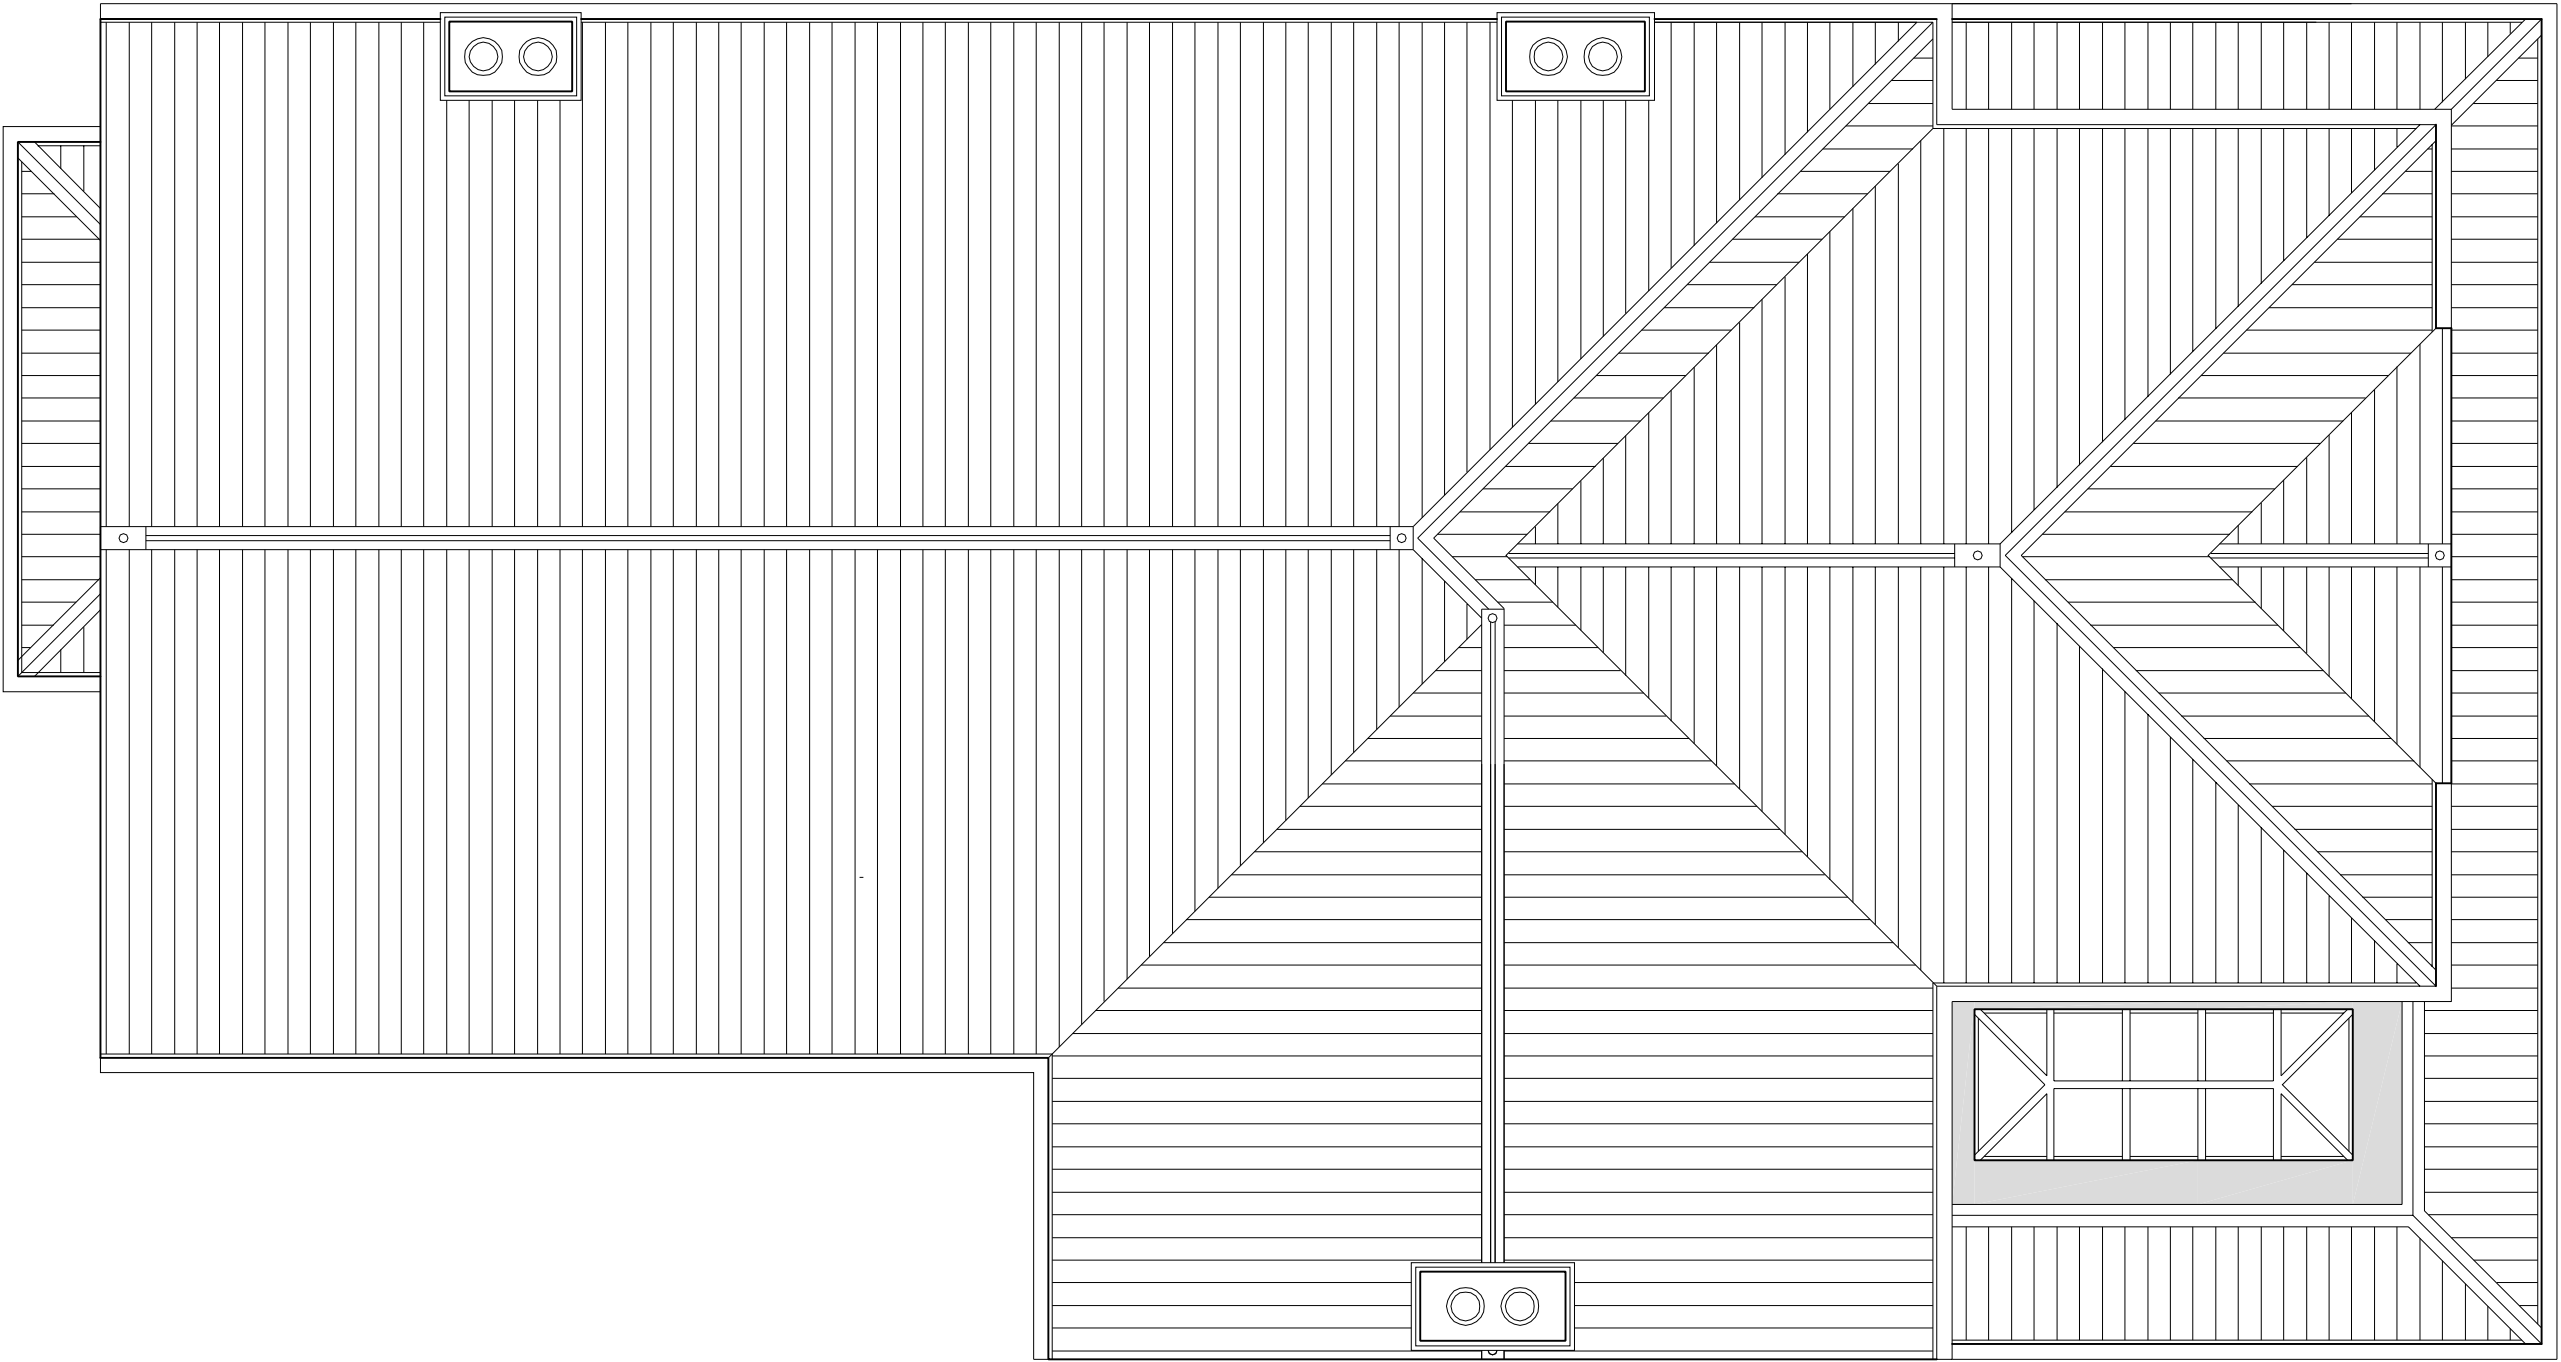

EXISTING ROOF PLAN

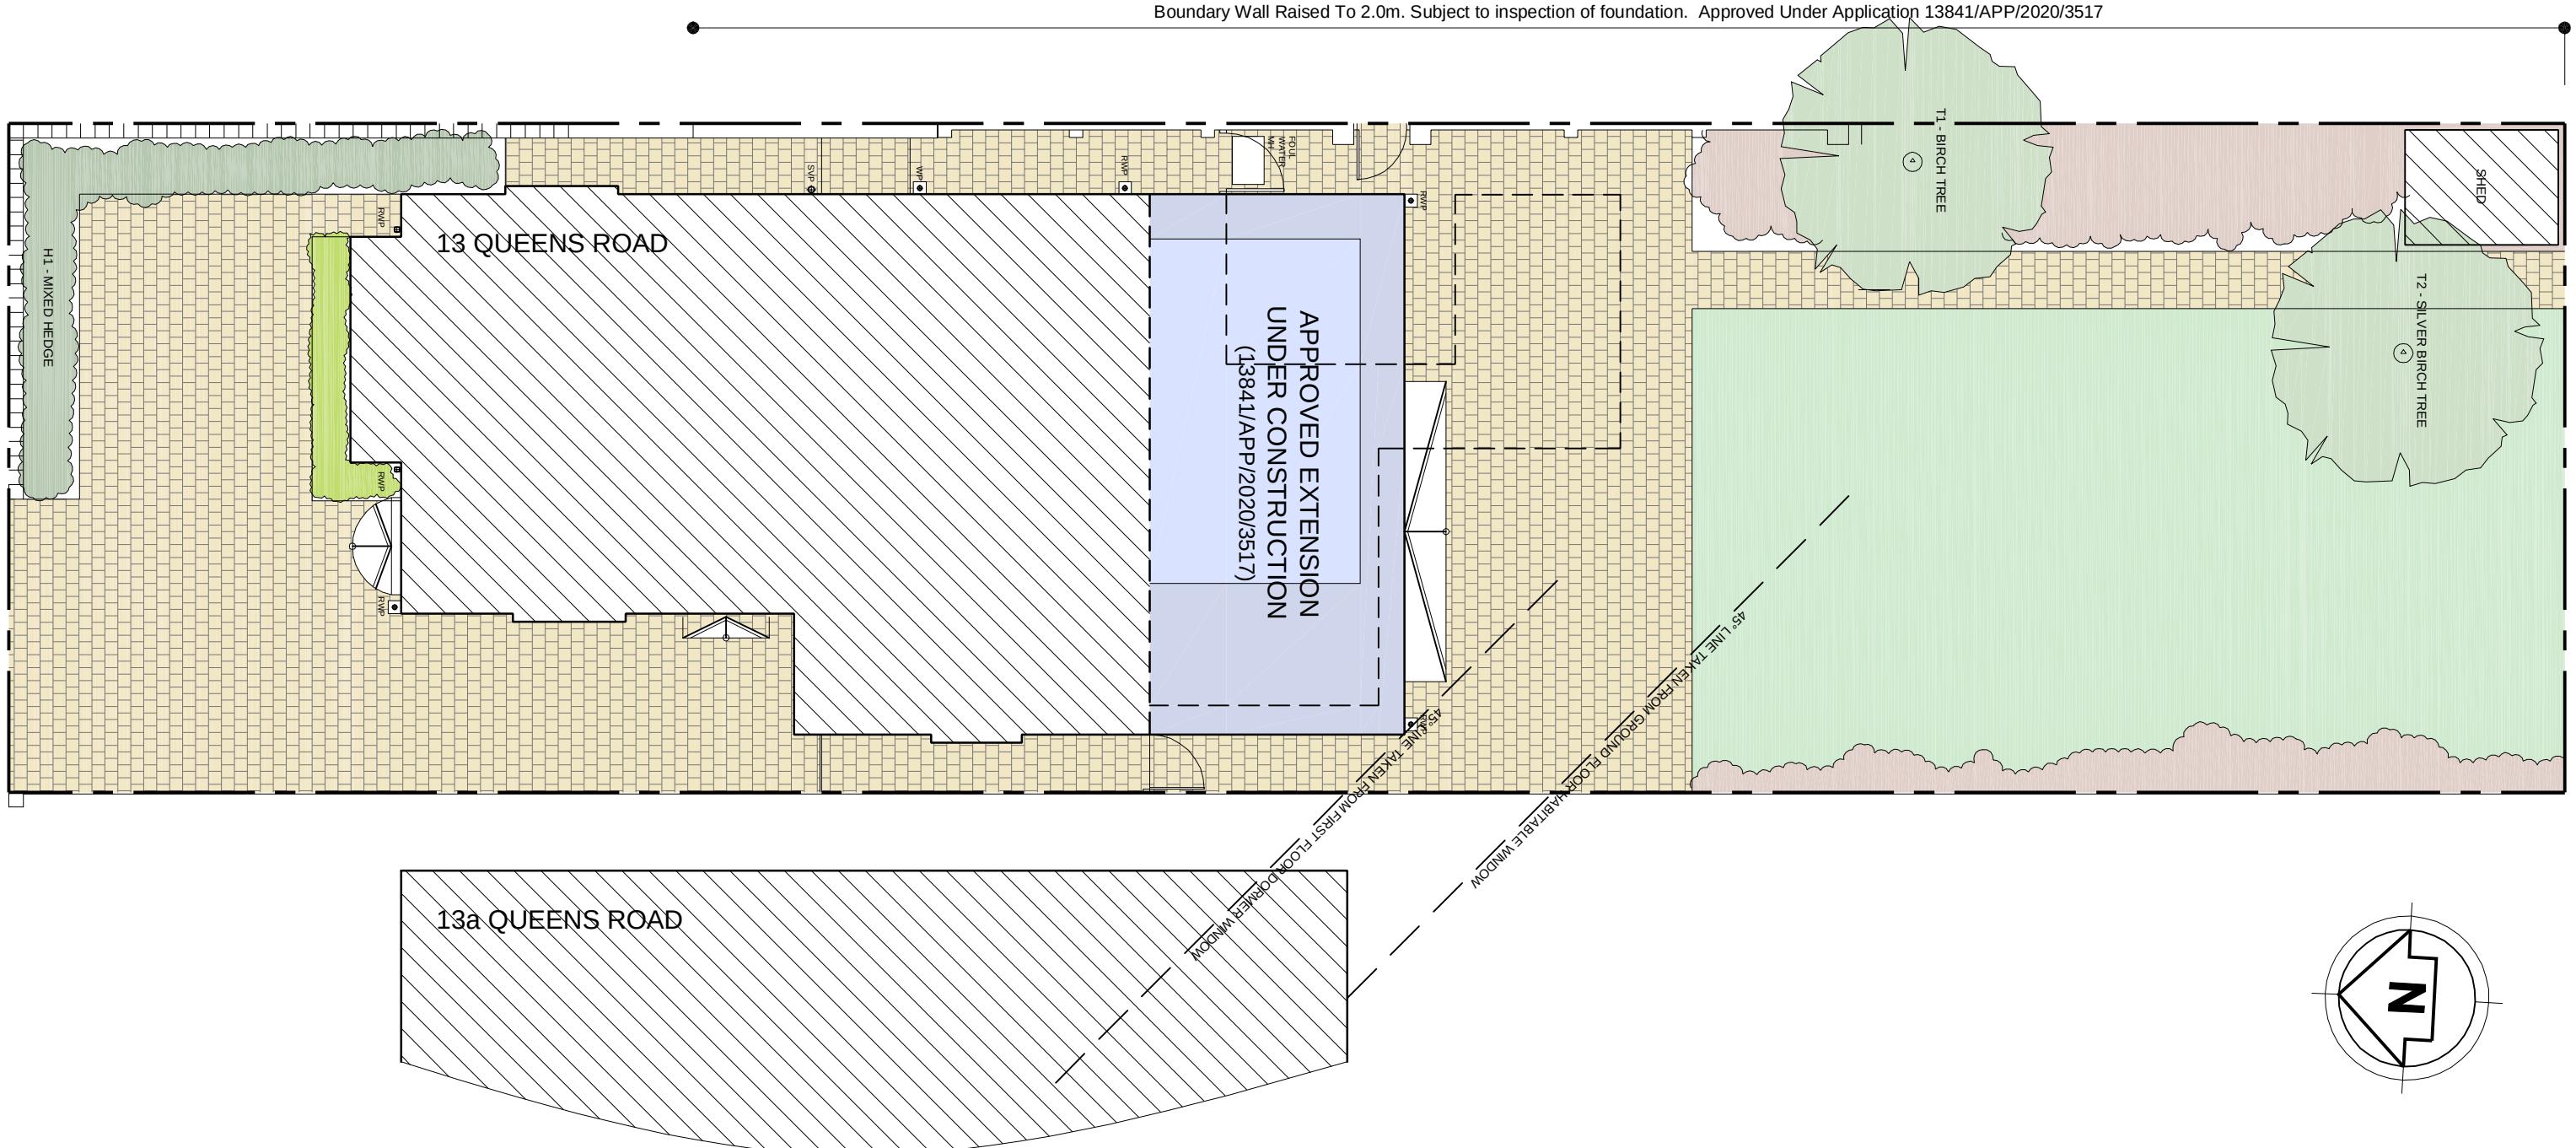

EXISTING BLOCK PLAN (Scale 1:100) (NO CHANGE)

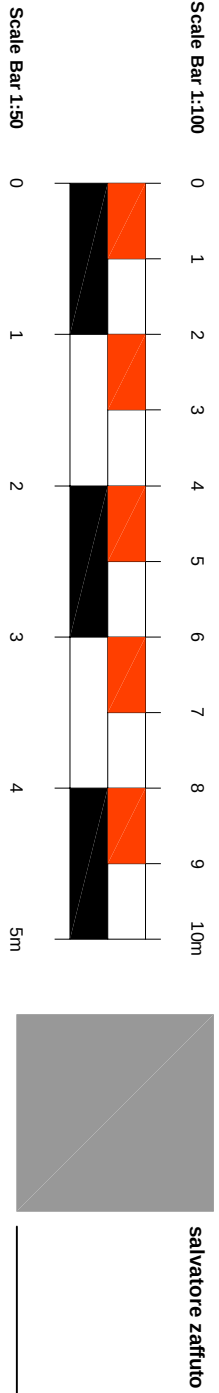

salvatore zaidoo	architecture
DATE: 04.03.2022	TITLE: Proposed Rooflights
SCALE: 1:50 (2/1)	EXISTING: Existing Loft/roof & Block Plan.
CLIENT: Mr P. Harris	DRAWING NO: 0-659-011
13 Queens Road, Uxbridge, UB8 3NN	