



LEGEND


- Indicates proposed foul water drainage run
- Indicates proposed surface water drainage run
- Indicates existing foul water drainage run
- Indicates existing surface water drainage run
- Means of escape opening light. See Notes.
- Smoke Detector
- Heat Detector
- Mechanical Extract Fan
- 100mm Soil & Vent Pipe
- 100mm Stub Stack
- Back liner Gully
- Foul Water Waste Pipe
- 75mm² RWP & gully
- 68mm RWP & gully
- Indicates load bearing timber stud partition.
- Indicates non-load bearing timber stud partition.
- Indicates thermally insulated plasterboard.
- The Rooflight Company CR09-2
Rooflight type.

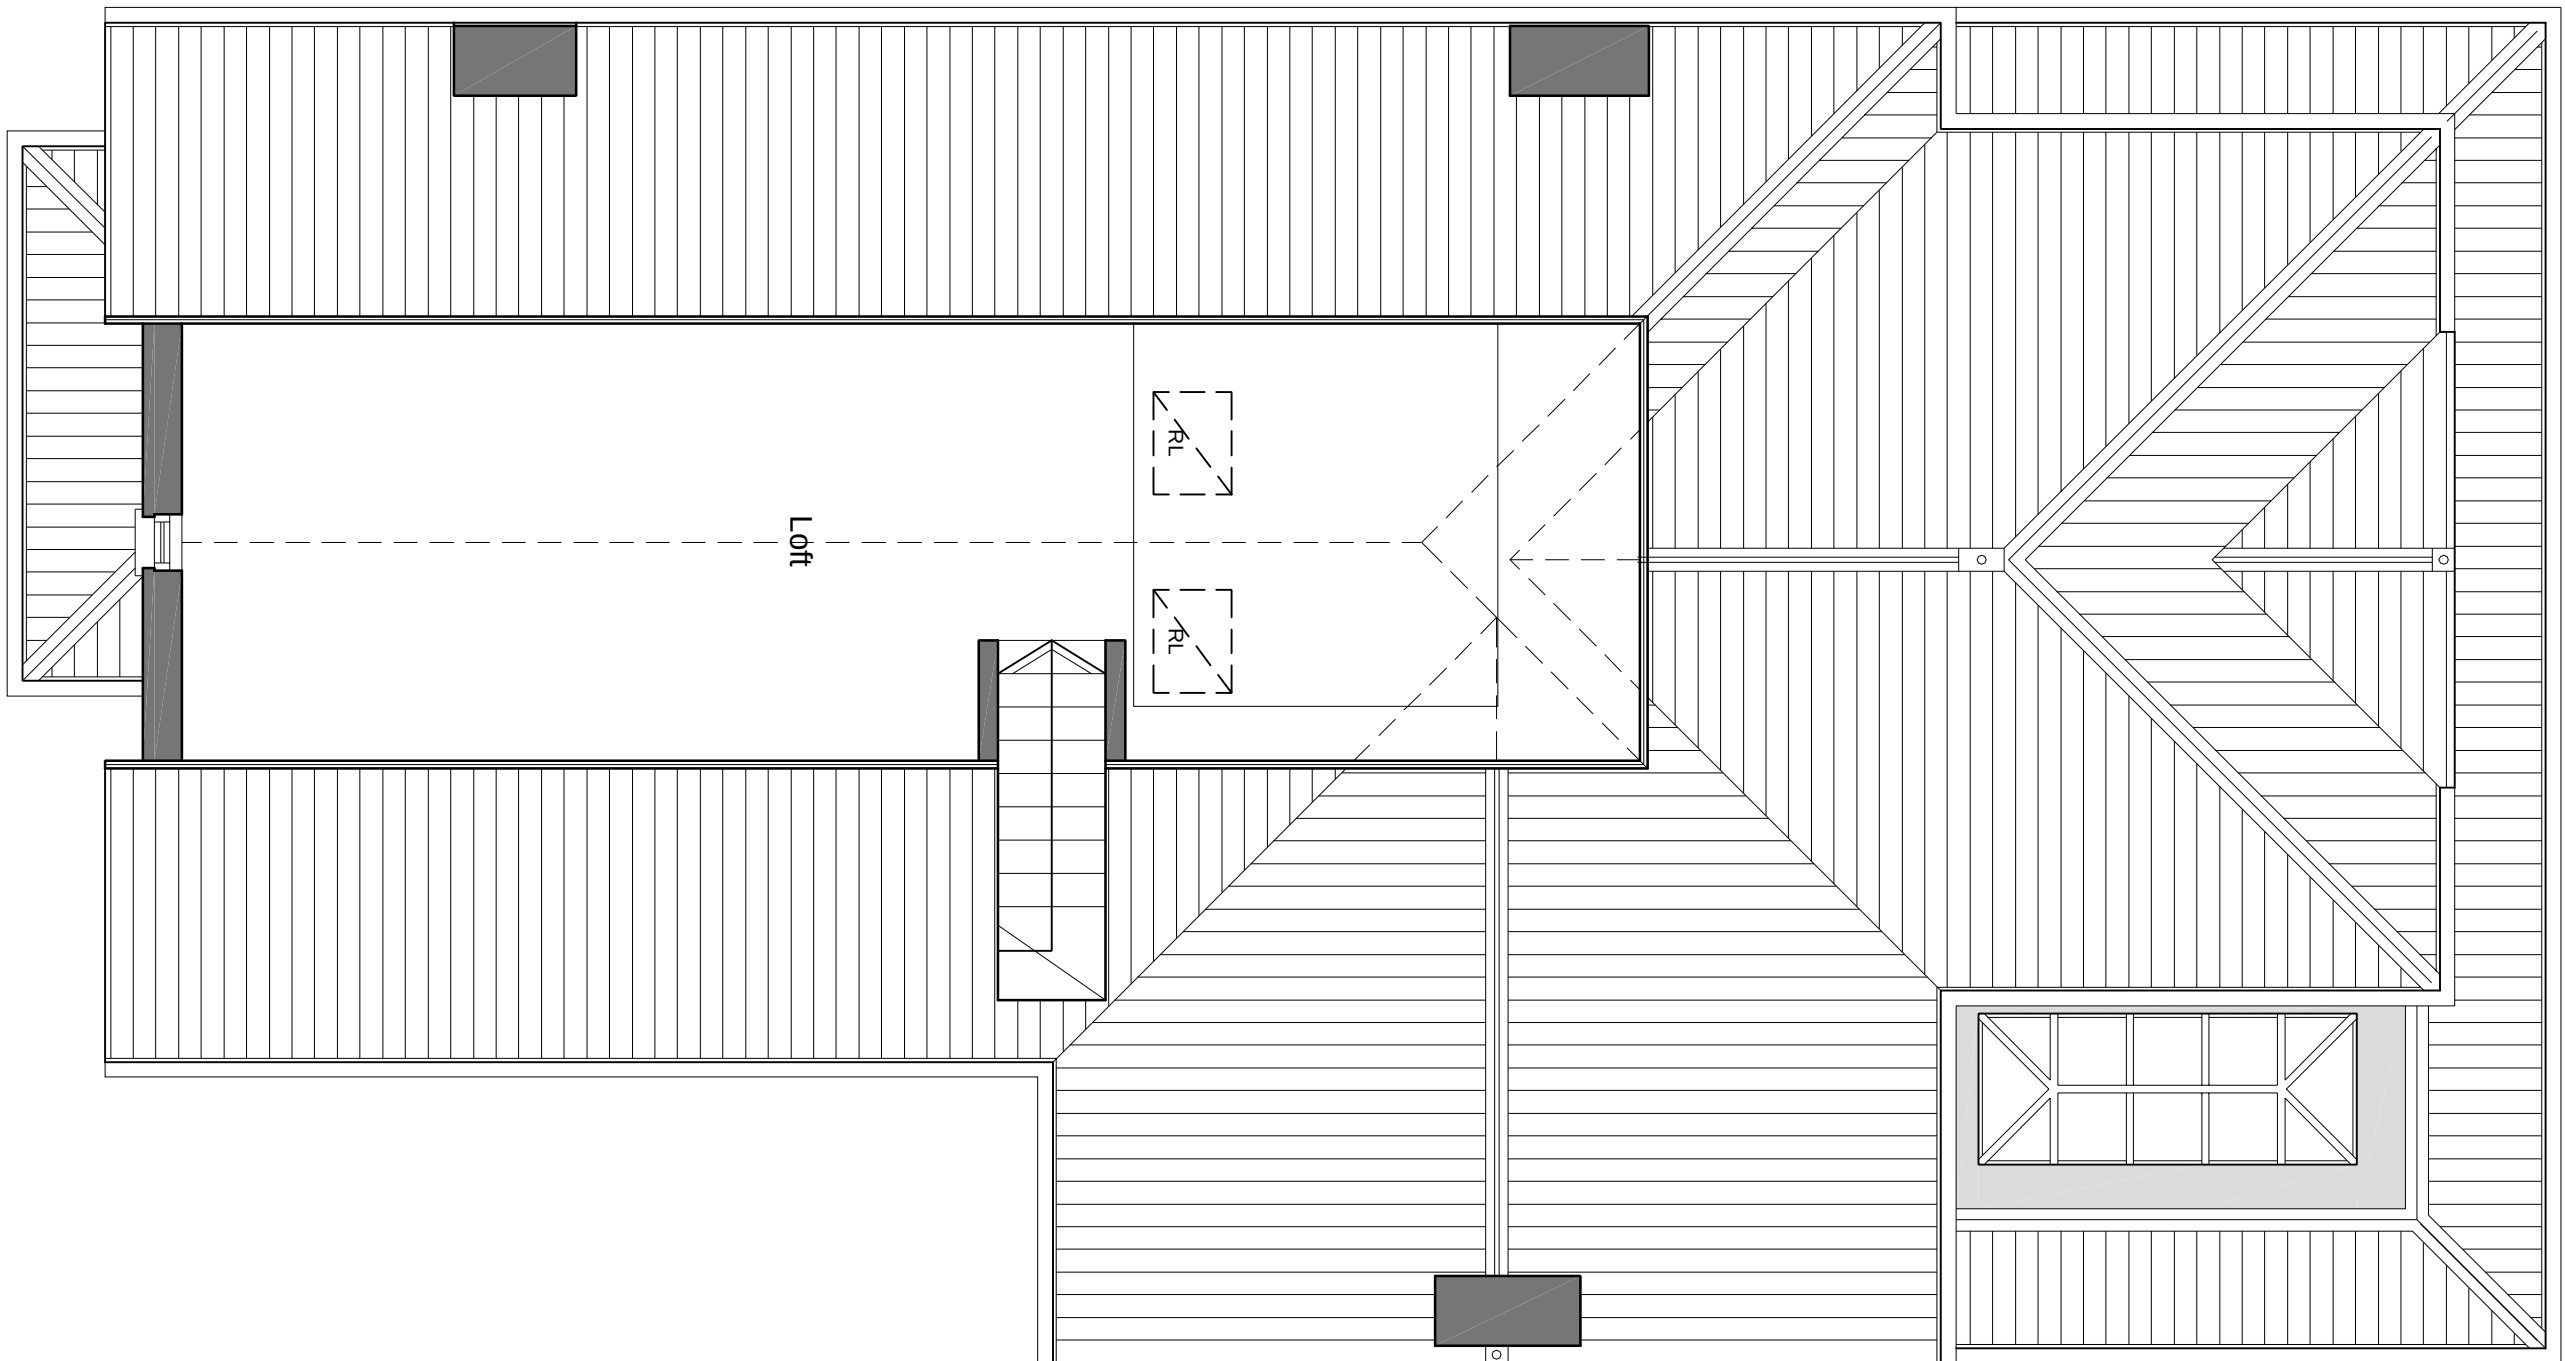



PROPOSED LOFT PLAN

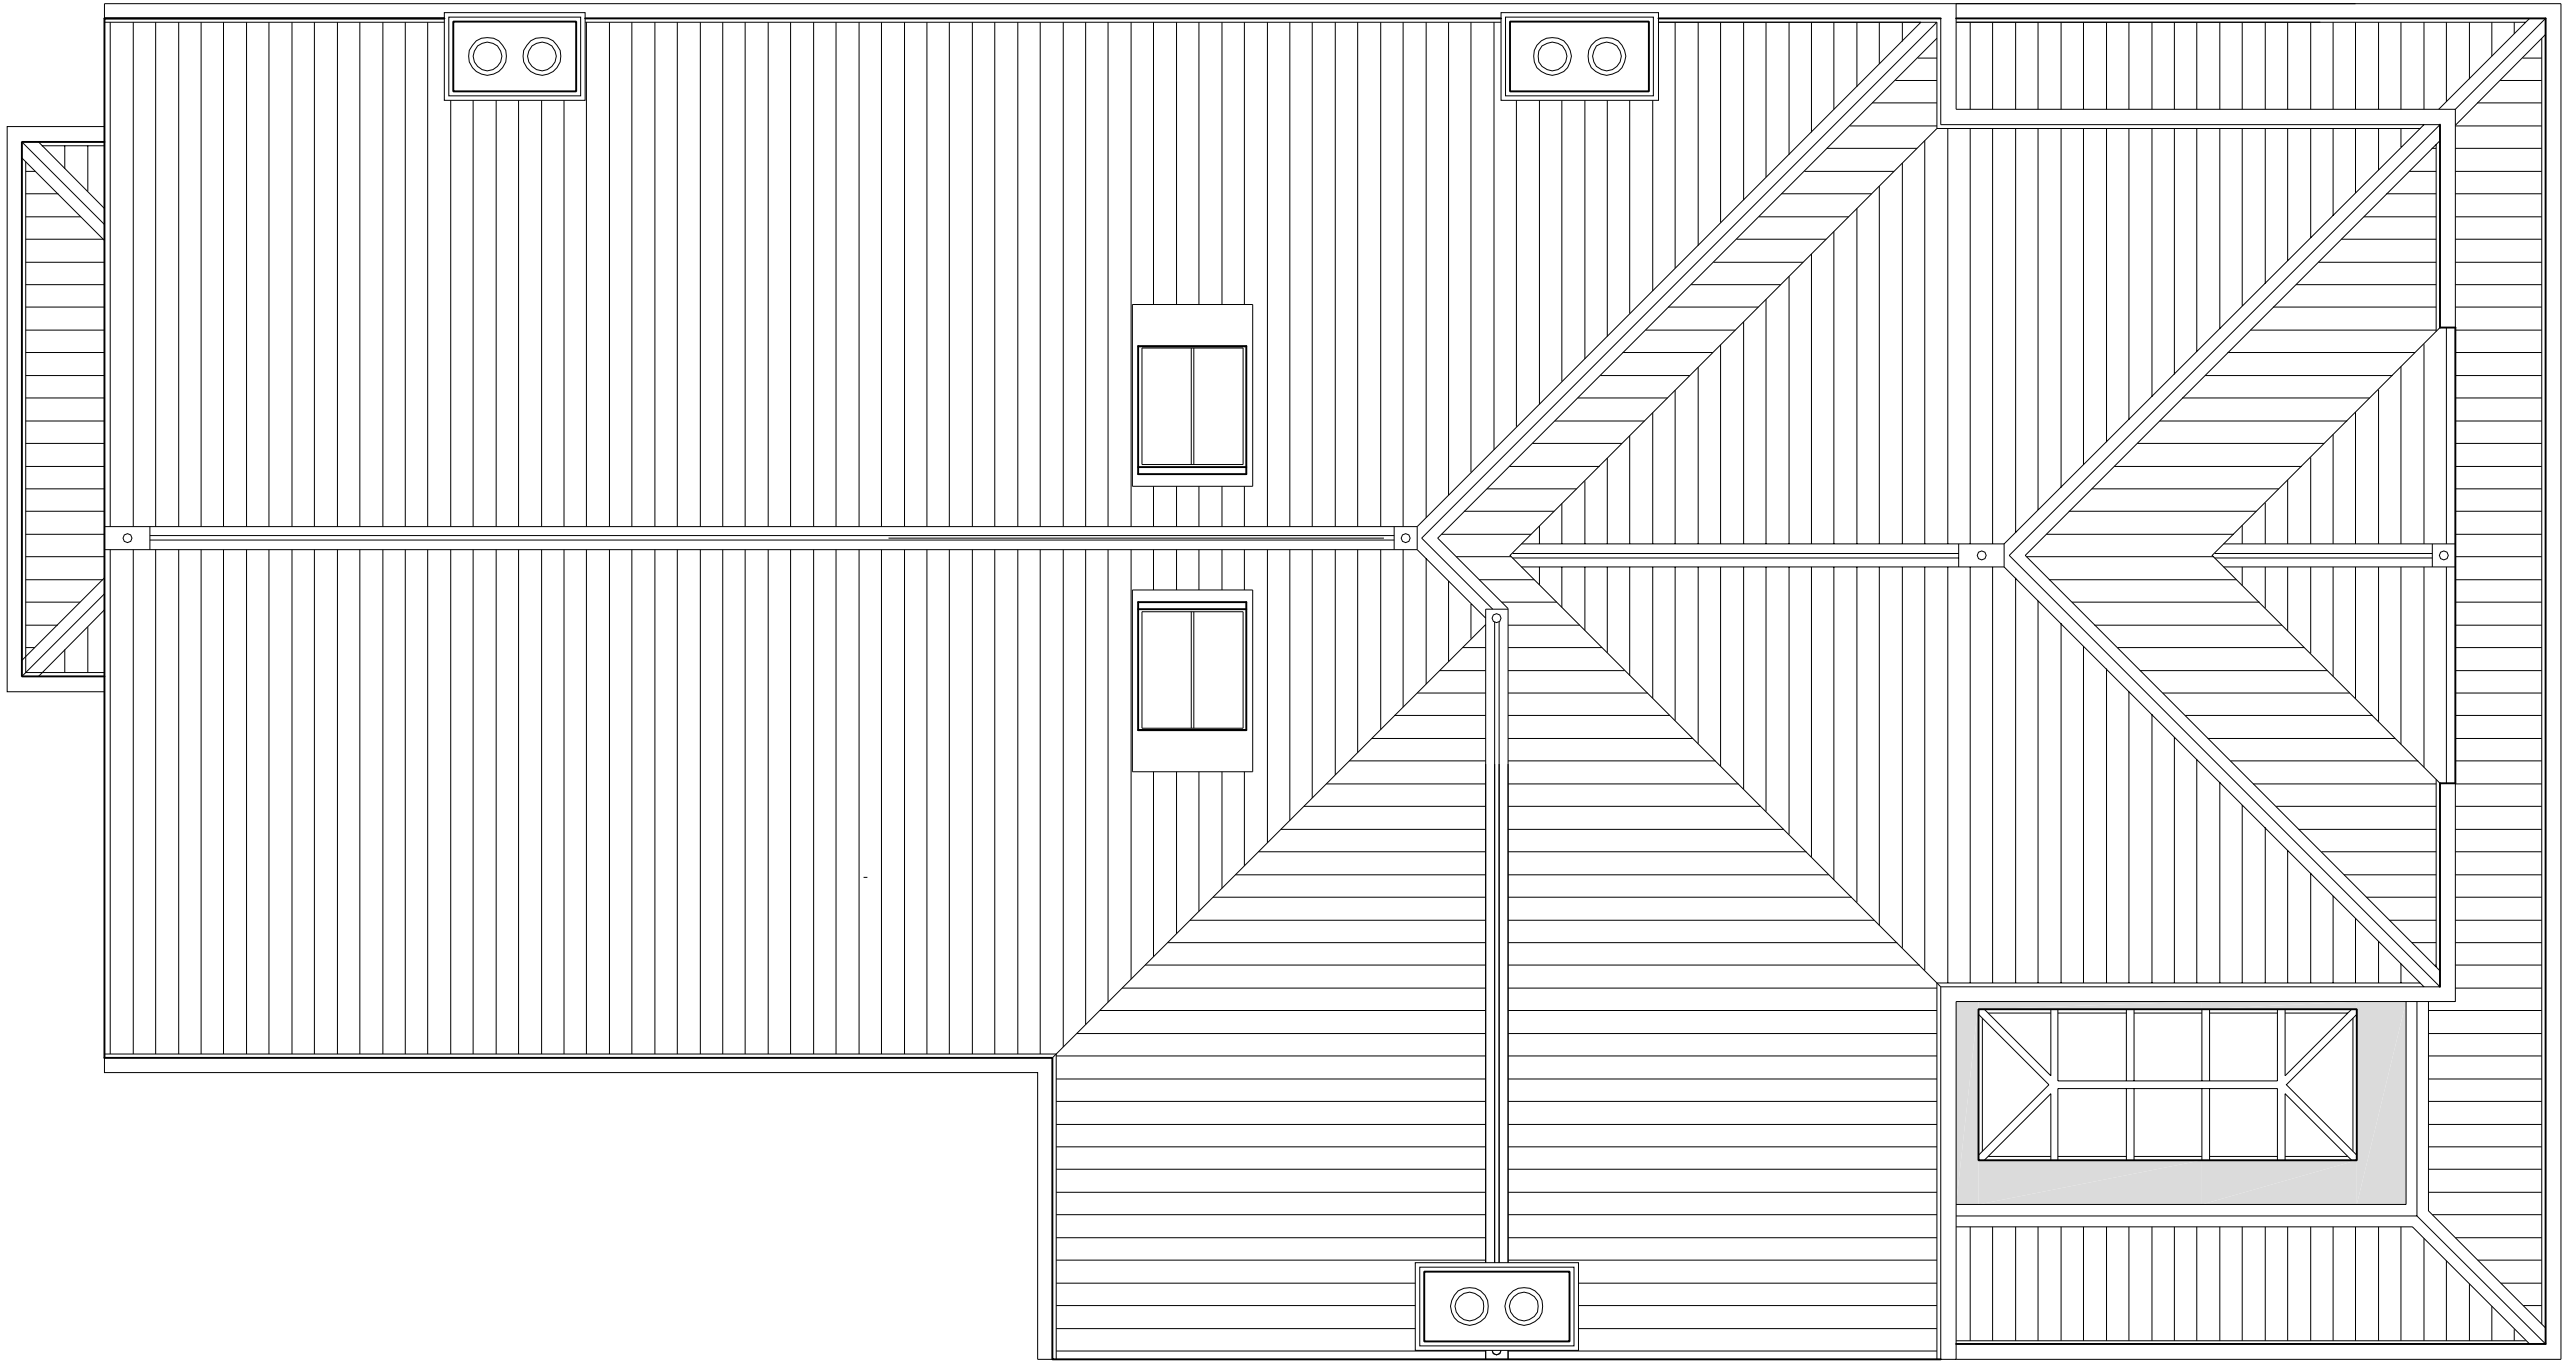

PROPOSED ROOF PLAN

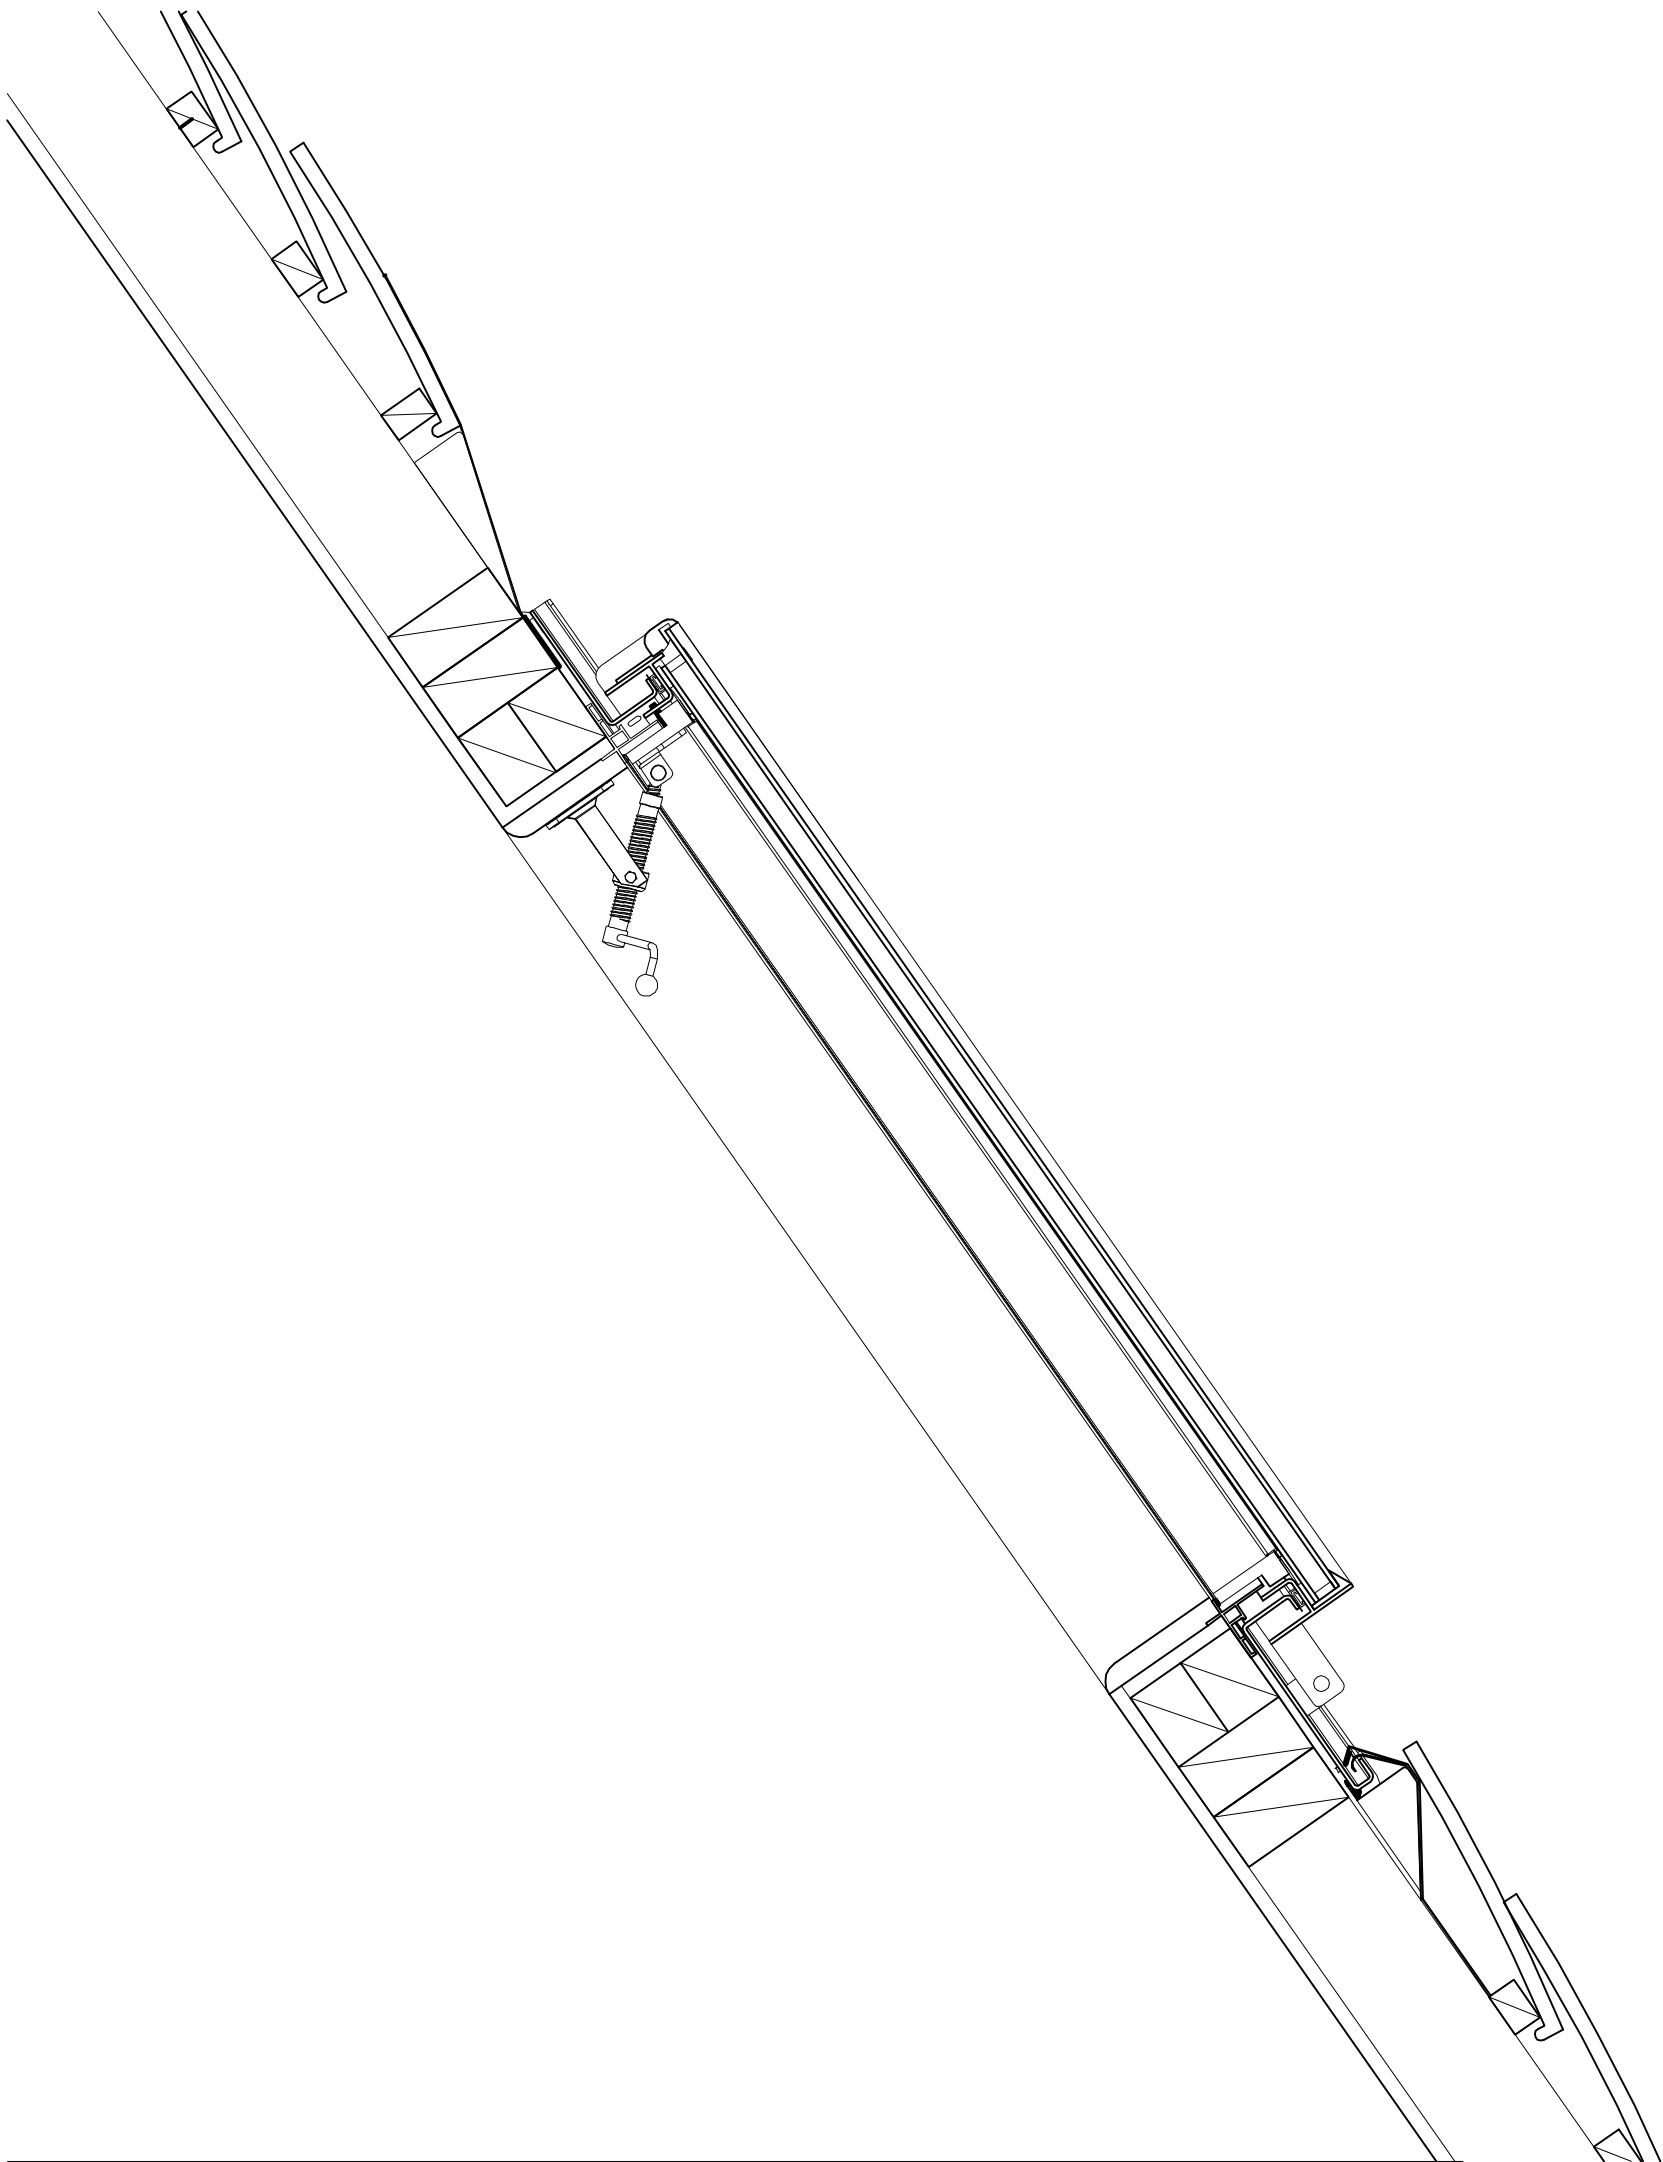

PROPOSED DETAIL 'Z'-SECTION THRU ROOFLIGHT
(Scale 1:5)

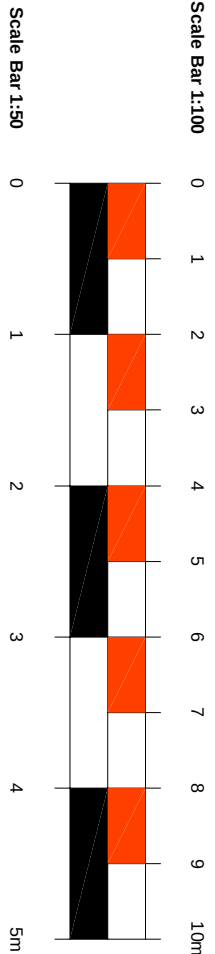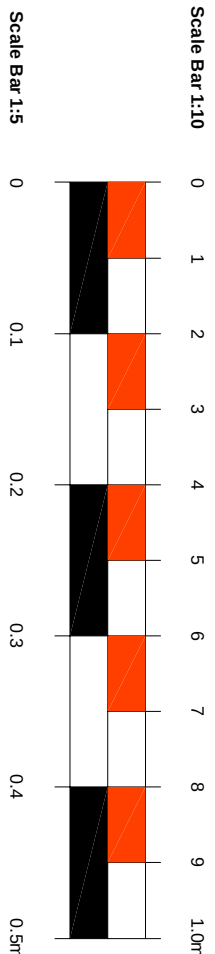

salvatore zaffino

architecture

date	04.03.2022
scale	1:500 / A1
drawn	SAZ
client	Mr P. Murray 13 Queens Road, Luton, LU3 2YN

title	Proposed Rooflights Proposed Loft/roof Plans & Detail 'Z'
drawing no.	0-69-013