


Electrical and mechanical fittings and/or appliances, conduits, pipes, cables, etc. are indicated for tendering purposes. Guidance & compilation of installation drawings, exact positions and routes shall be settled on site in relation to other services and fixtures and to the architect's detailed room layouts where issued or appropriate except where dimensions are given. (In the drawing or in the specification.) Final positions of lighting points, mechanical and electrical fittings, fixtures and appliances must be checked with the contract administrator before proceeding.

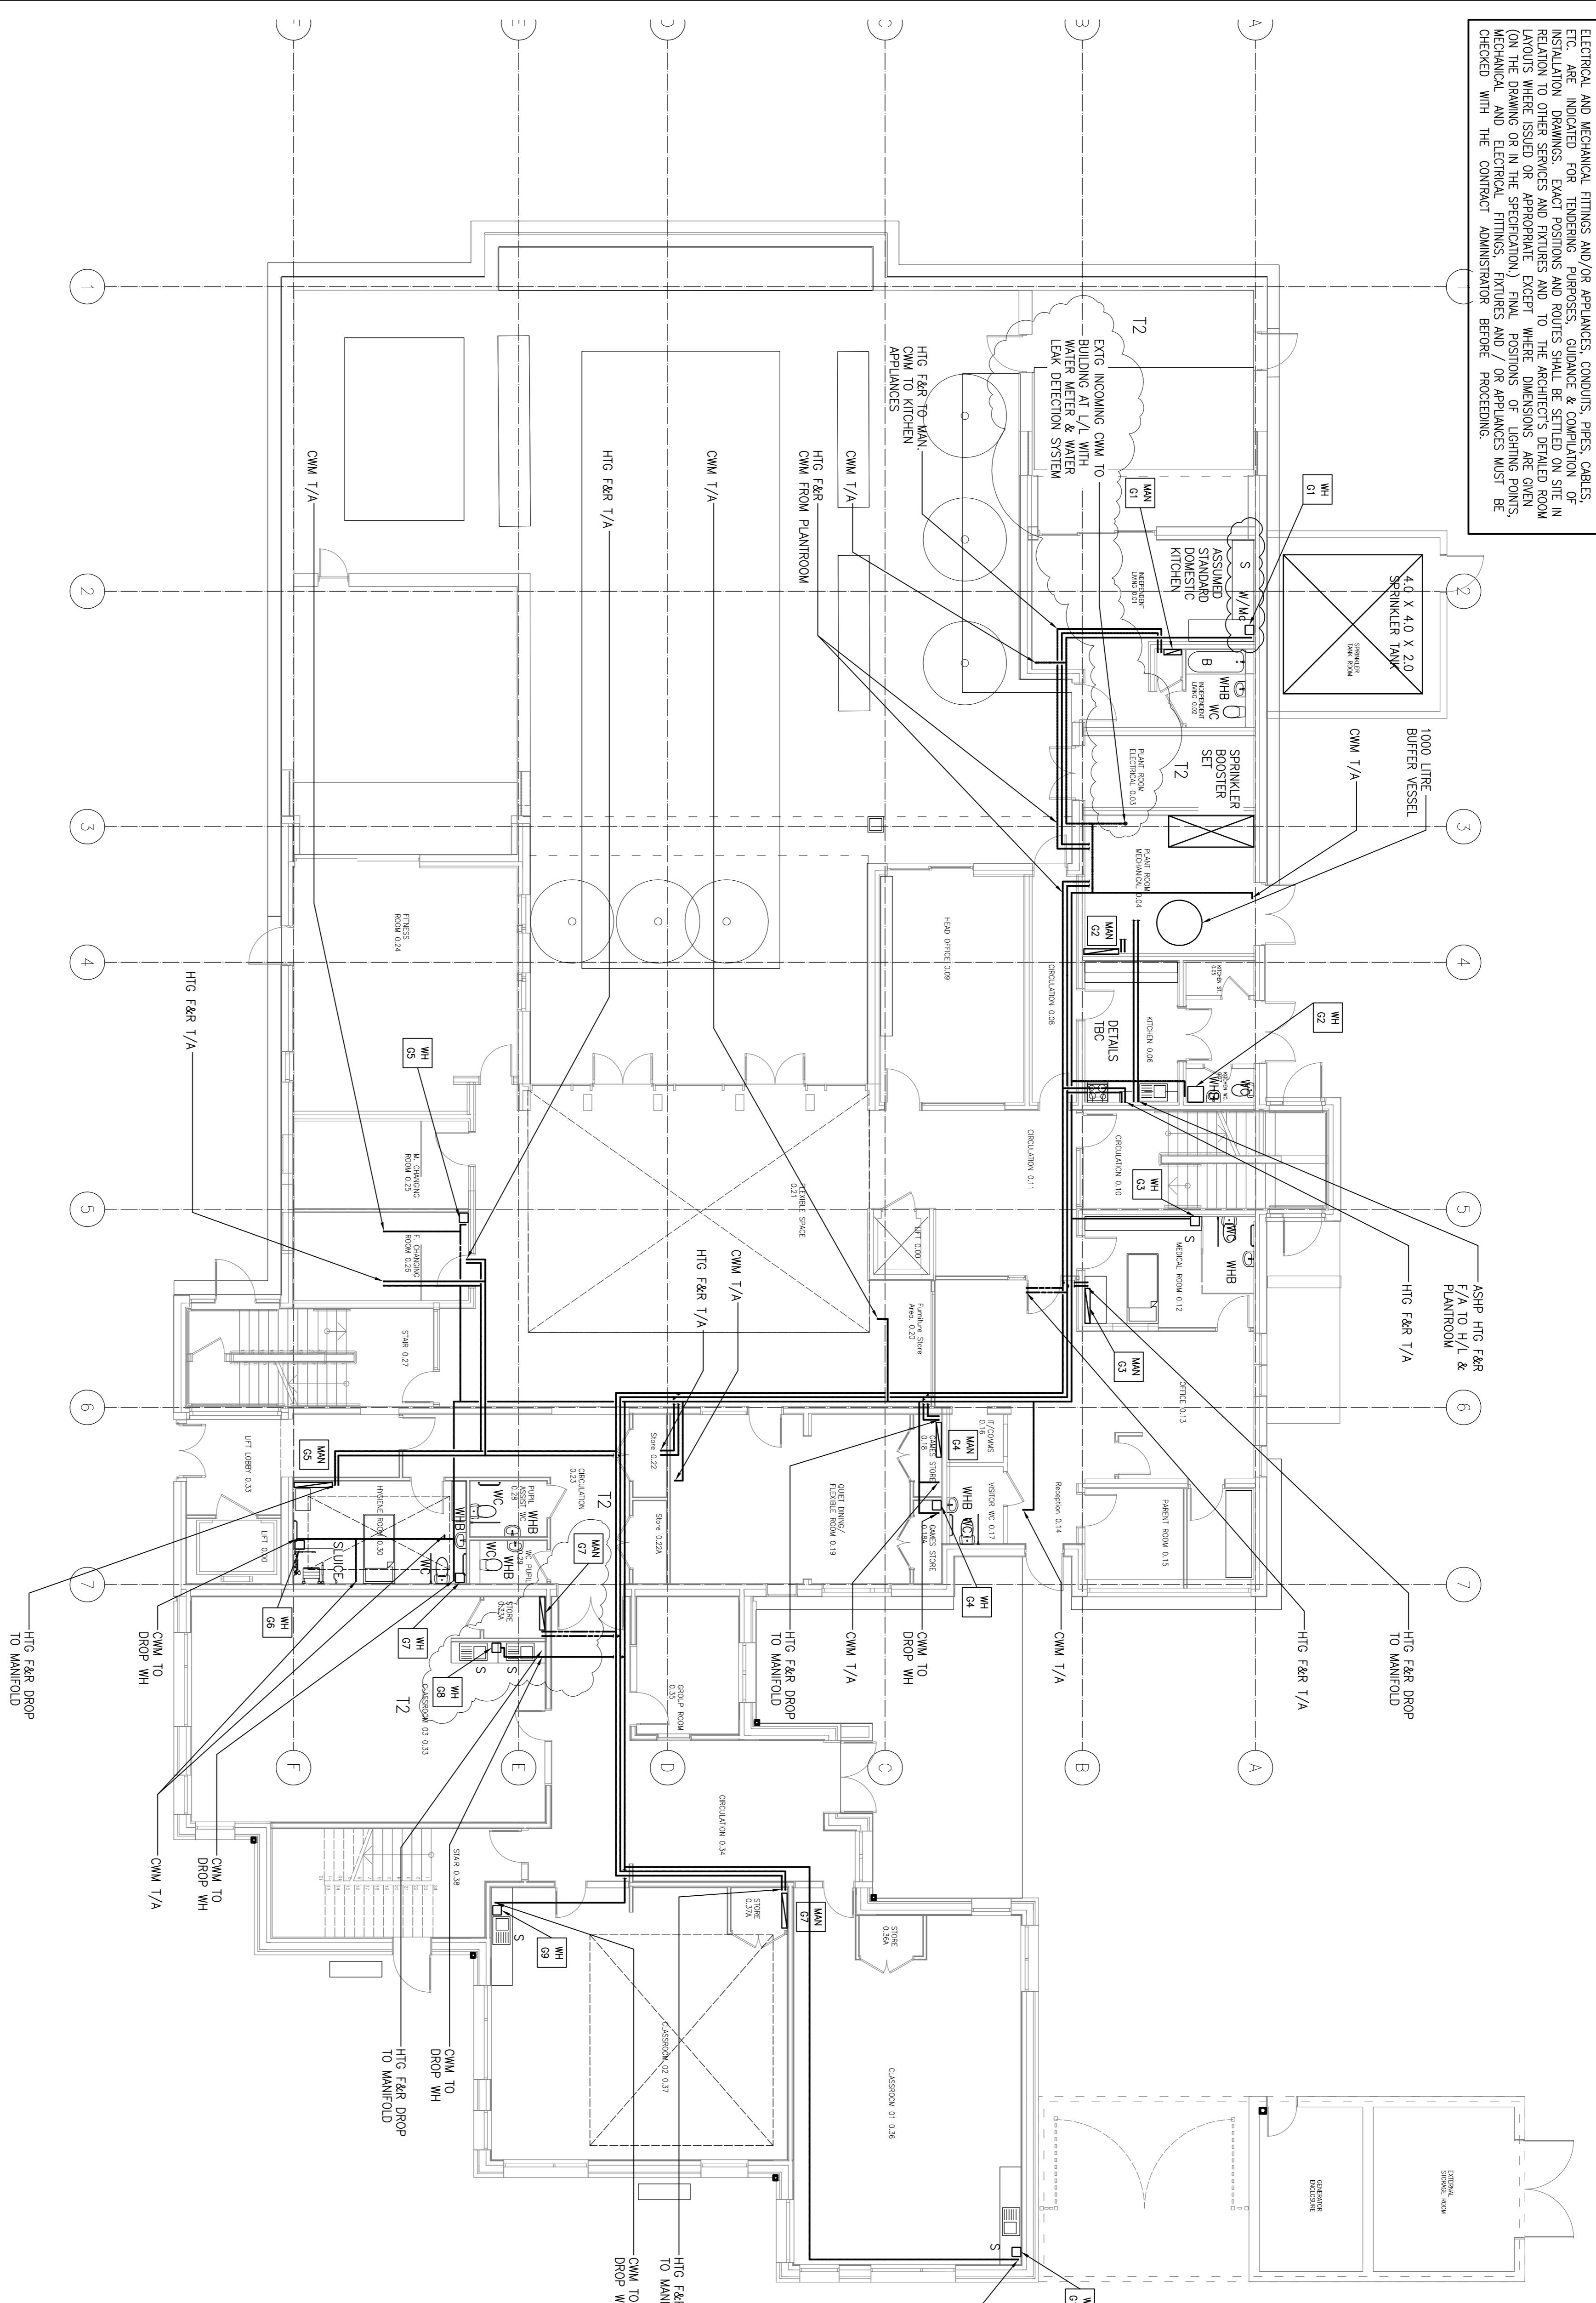

NOTES  
 1. FOR MECHANICAL LEGEND SEE DRG. NO. 21/168-M01  
 2. THIS DRAWING IS TO BE READ IN CONJUNCTION WITH SERVICES SPECIFICATION  
 3. THIS DRAWING IS TO BE READ IN CONJUNCTION WITH ALL RELEVANT ARCHITECTURAL, STRUCTURAL & OTHER SERVICES DRAWINGS  
 4. THIS DRAWING SHALL NOT BE SCALED. ALL DIMENSIONS TO BE VERIFIED ON SITE.  
 5. THE CONTRACTOR SHALL LAUDE WITH ARCHITECT OF EXACT LOCATION AND SIZE OF ACCESS PANELS.

**Edward Pearce**  
CONSULTING ENGINEERS

Edward Pearce LLP  
Old School House  
35 Evelyn Road  
Surbiton, Surrey KT6 6AF

Project Title  
MHS HARFIELD  
NORTHWOOD WAY  
HARFIELD UB9 6ET

Drawn by  
LONDON BOROUGH OF  
HILLINGDON

Proposed  
PROPOSED OUTLINE PIPEWORK  
SERVICES LAYOUT  
GROUND FLOOR

Scale 1:100 @ A1 Drawing Status  
Drawing No. 21/168-M15 Revision T2