



**40 WISE LANE  
MILL HILL  
LONDON  
NW7 2RE  
MOB:  
07946 872537  
[www.homesdesignltd.com](http://www.homesdesignltd.com)**

title	PROPOSED LOWER GROUND FLOOR AND GROUND FLOOR PL		
project	102 Green Lane Northwood Middlesex HA6 1A		
drawing no	ABC503/5000	rev A	
drawn by	R. L	contract no.	ABC503
scale	1:100 @ A3	date	02/2025

ANS

J

S


B

h: ● HEAT DETECTORS TO ALL KITCHEN AREAS & CONNECTED TO SMOKE DETECTORS CIRCUIT


SMOKE DETECTOR SYSTEM CONNECTED TO INDEPENDENT CIRCUIT

● BRITISH STANDARDS. SMOKE DETECTORS AT ALL FLOORS TO BE POSITIONED CENTRAL TO THE HALLWAYS ABOVE THE LANDINGS

● MECHANICAL EXTRACT FANS. KITCHEN WITH (30L/s) & BATH AREAS TO BE 15L/s EXTRACT FAN FITTED TO LIGHT SWITCH WHICH IS 15MINUTES OVER RUN IN ACCORDANCE TO APPROVED DOC-F

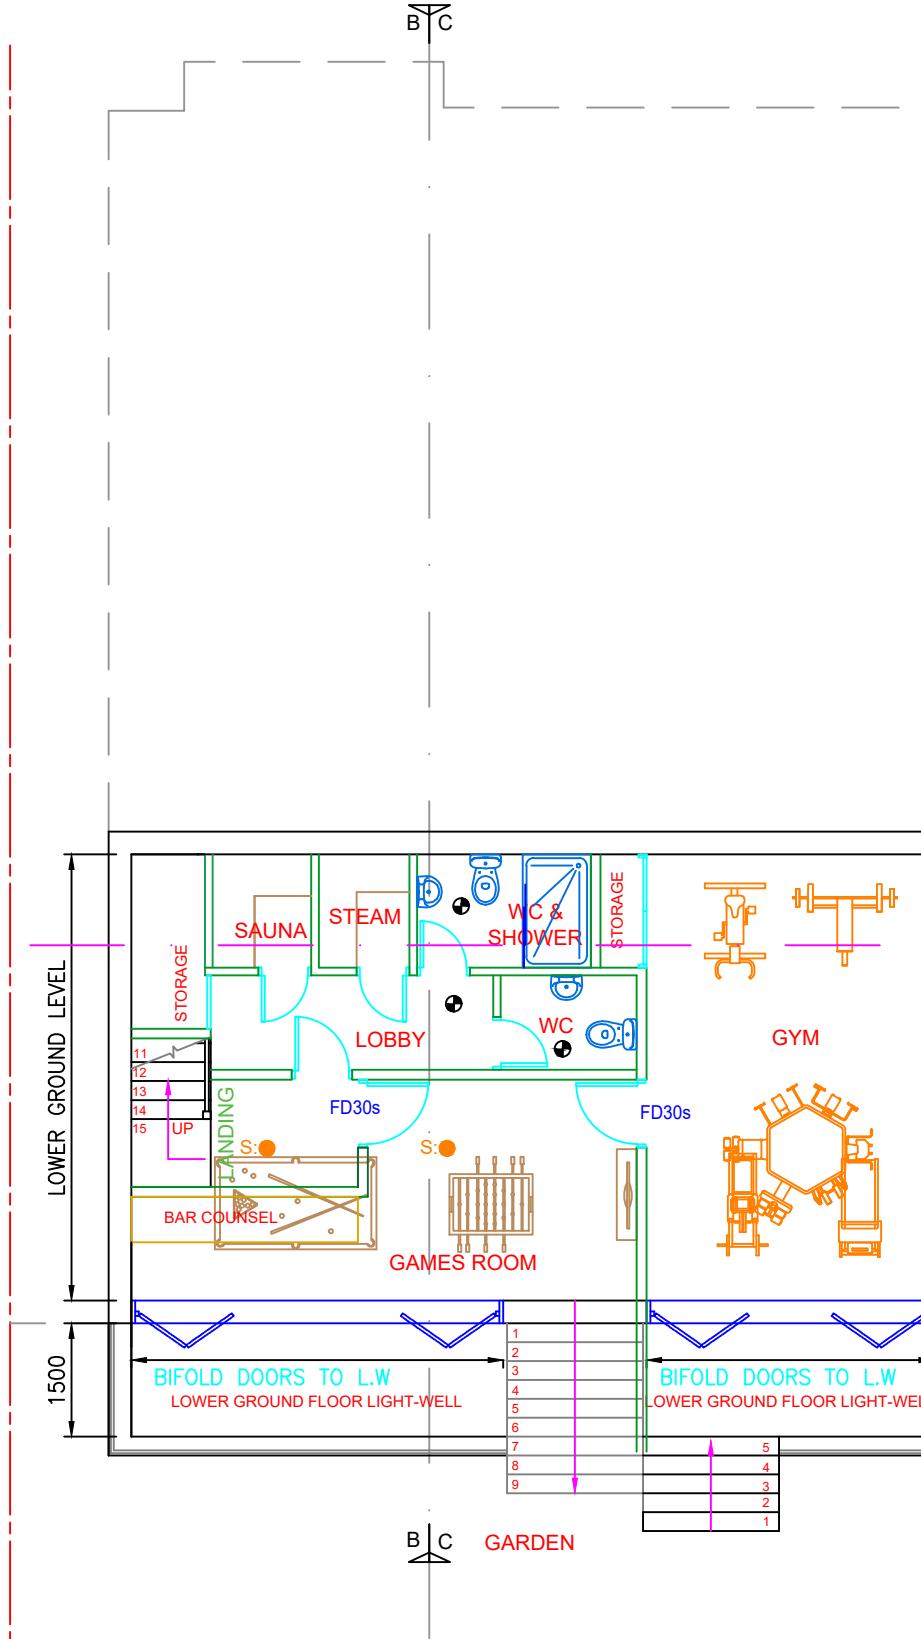

## PROPOSED LOWER GROUND FLOOR PLAN

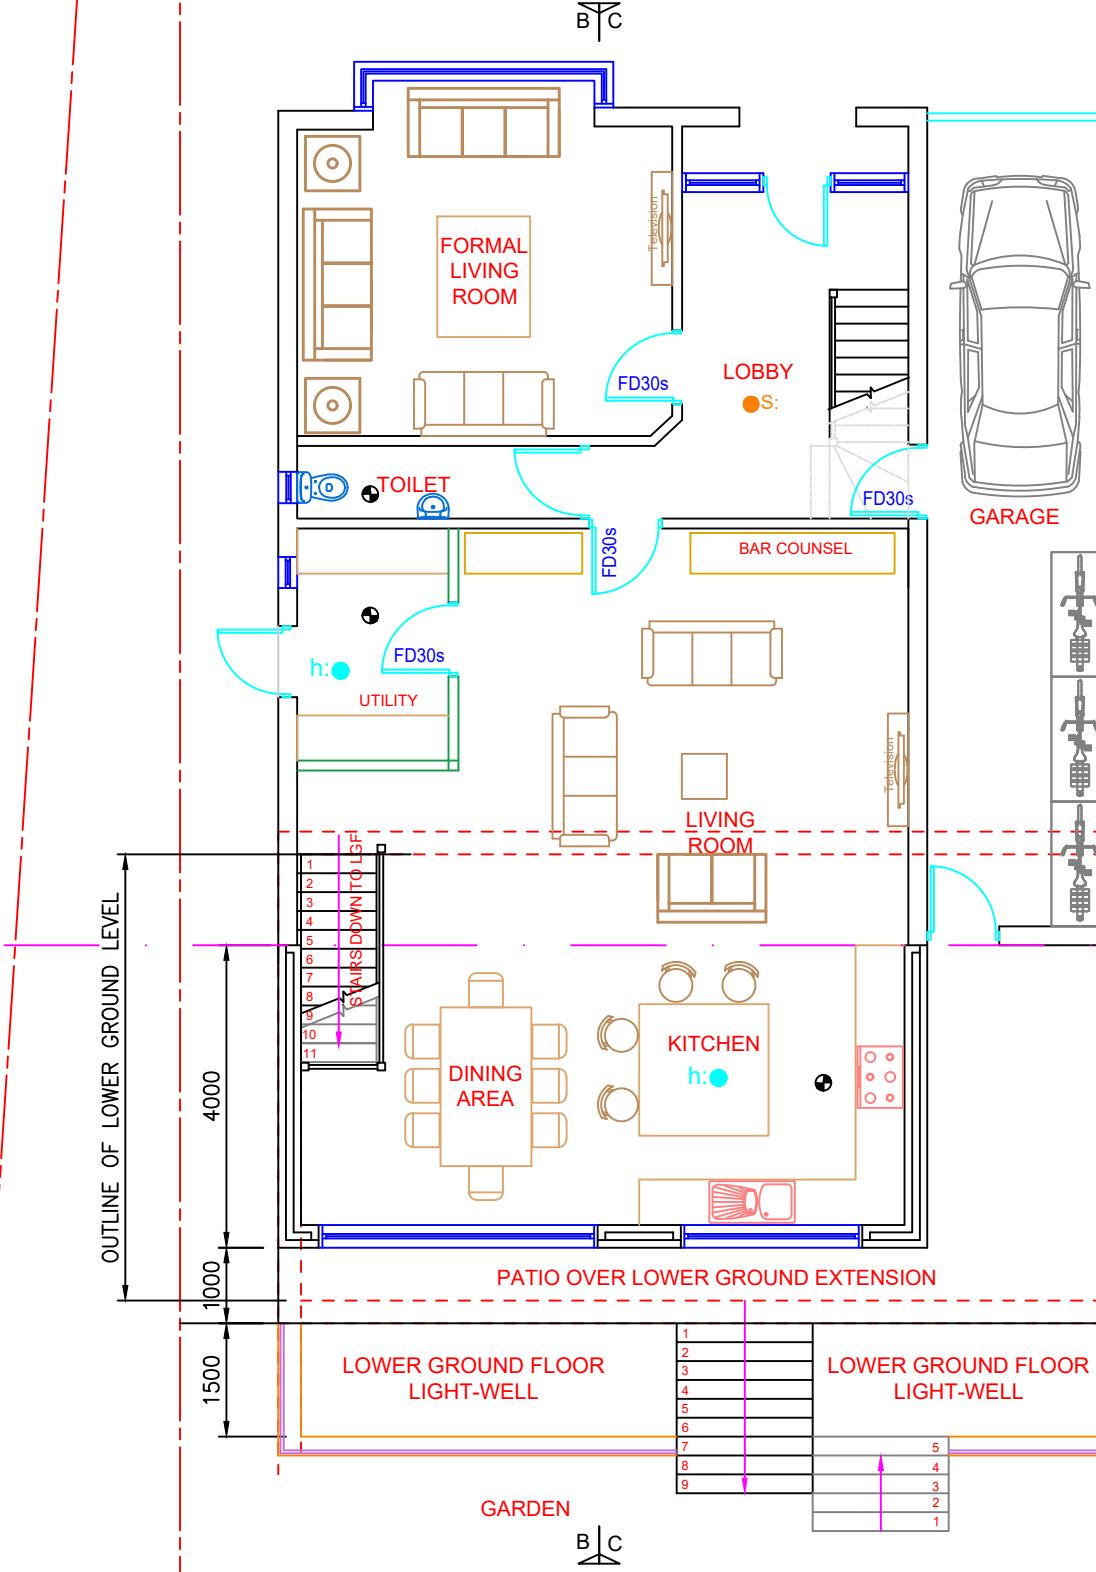

## PROPOSED GROUND FLOOR PLAN

## OUTLINE OF ORIGINAL REAR ELEVATION OF DWELLING

## SCALE