


NOTES

- This drawing are for Planning & Building Control purpose only
- Verify all dimensions & setting out point on site, IF IN DOUBT-ASK
- Engineer must be notified if there are any discrepancies and or before altering any structure details
- Roof tiles to match existing.
- This drawings are to be read in conjunction with specification and relevant drawings.
-  Smoke Detector
-  Heat Detector
- Smoke and heat detectors to be main operated with battery back up. Supply to be independent circuit from consumer unit.
- All detectors to be inter connected so that activation of any detector will send signal to all the detectors in the system to initiate fire alarm sounder in all the units
-  Indicates Wall Type
- Intermittent extract ventilation
- KITCHEN: Mechanical extract ventilation capable of extracting at rate not less than 60 lit/sec, or, 30 lit/sec if incorporated within a cooker hood. Extractor may be operated intermittently e.g. during cooking.
- BATHROOM: Mechanical extract ventilation capable of extracting at a rate not less than 15 lit/sec which may be operated intermittently.
- SANITARY ACCOMMODATION: Mechanical extract ventilation, capable of at least 6 lit/sec which may be operated intermittently with 15 minutes overrun.
- UTILITY ROOM: Mechanical extract ventilation, capable of at least 30 lit/sec which may be operated intermittently with 15 minutes overrun.

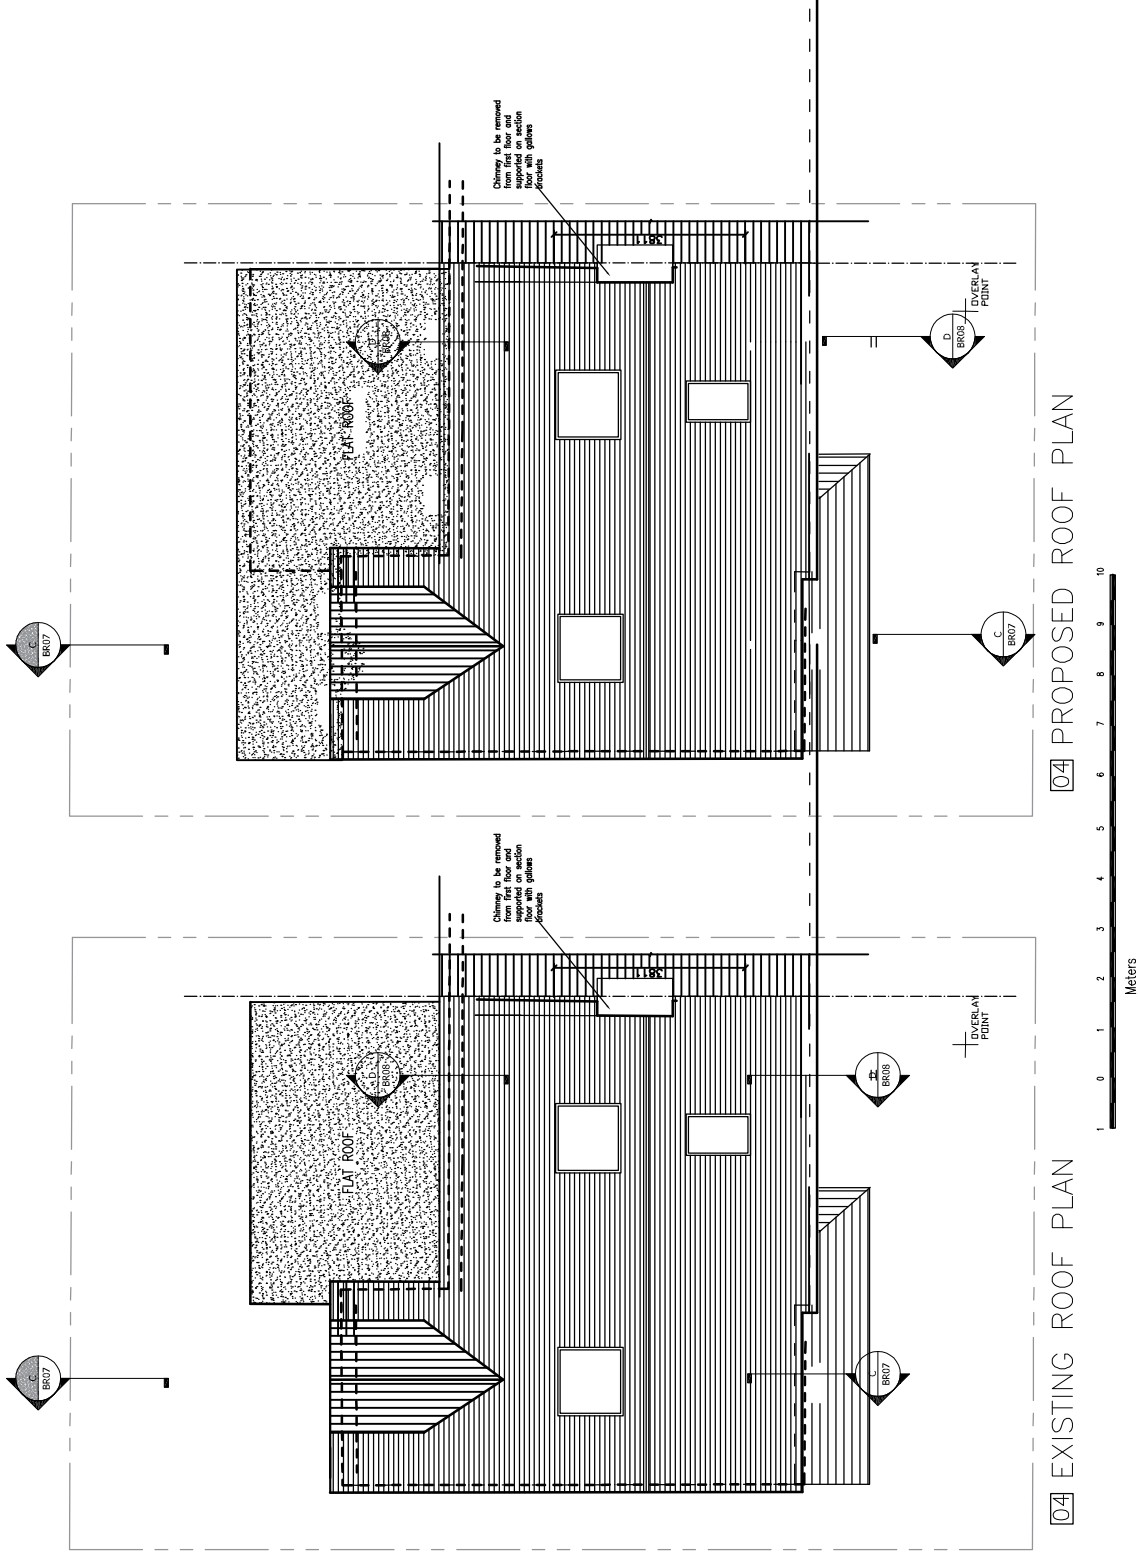

 **Lotus Consultants Limited**
Design, Construction, Management

Address: 37 Woodfield Rise, Bushey, Hertfordshire, WD23 2QR
e: enquiries@lotusll.co.uk web: www.lotusll.co.uk
t: 01772 244 4100 f: 0208 560 2143
© Copyright Lotus Consultants Ltd

No.	Description	Date
-	-	-
-	-	-
-	-	-
-	-	-
-	-	-

Client name
Kishan & Amisha Thakkar

Project address
**234 Northwood Road
Harefield
UB9 8PT**

Project description
PROPOSED GROUND FLOOR EXTENSIONS

Sheet name
Roof plan

Project number
2106

Date:
Oct 2021

Drawn:
KF

Checked:

Project stage
PLANNING

Drawing No.
NR-RE 06- Roof Plan

Scale:
1:100 @ A3

Rev. -