



LOCATION PLAN

SCALE 1=1250

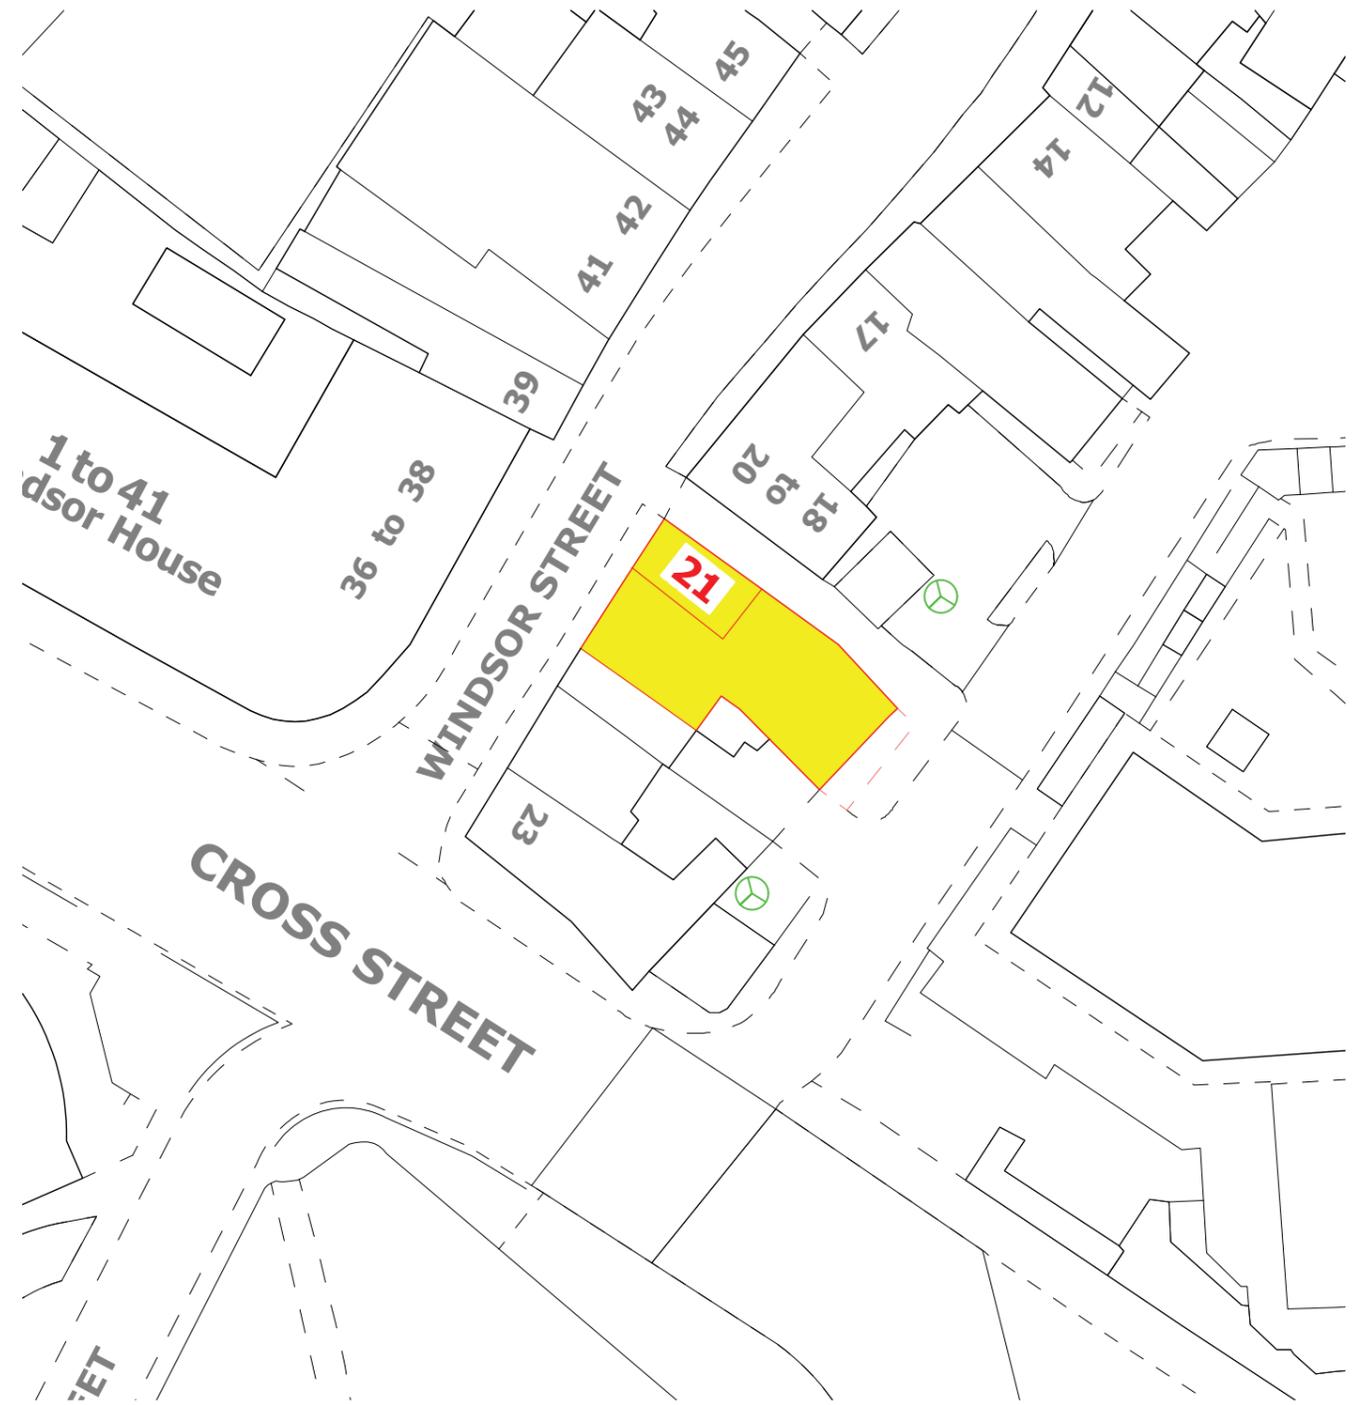

BLOCK PLAN

 SCALE 1=500



GENERAL NOTES

REVISION A : Updated Plans and extraction layout.
 REVISION B :

PROJECT NAME:
 CHUTNEI CHARM UK LTD

DRAWING TITLE:
 LOCATION_AND_BLOCK_PLAN



DRAWN BY: RF
 CHECKED BY: AI
 APPROVED BY: RIZQ
 DATE: 03/02/2026

CLIENT NAME & ADDRESS
 INDIKA SPICE LTD.
 21 WINDSOR STREET,
 UXBRIDGE, UB8 1AB

COMPANY
 RIZQ
 ARCHITECTURE AND CONSTRUCTIONS LTD.
 THE VAULT BUSINESS CENTRE
 117-123 HIGH STREET, DIGBETH
 BIRMINGHAM B12 0JU

CONTACT NO: +44744818321 /+447459760929
 E - MAIL : rizqarchitects@gmail.com

SCALE: 1: 500, 1250	PROJECT NO: -	SHEET SIZE: A3
DRAWING NO: 001	SHEET NO:	
REVISION: A		
UNIT: mm		

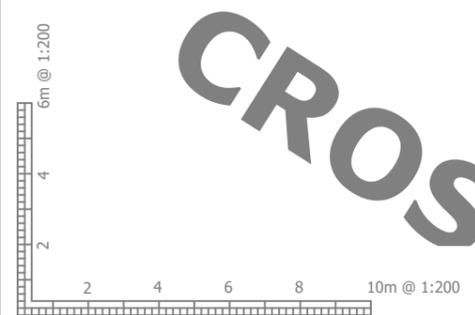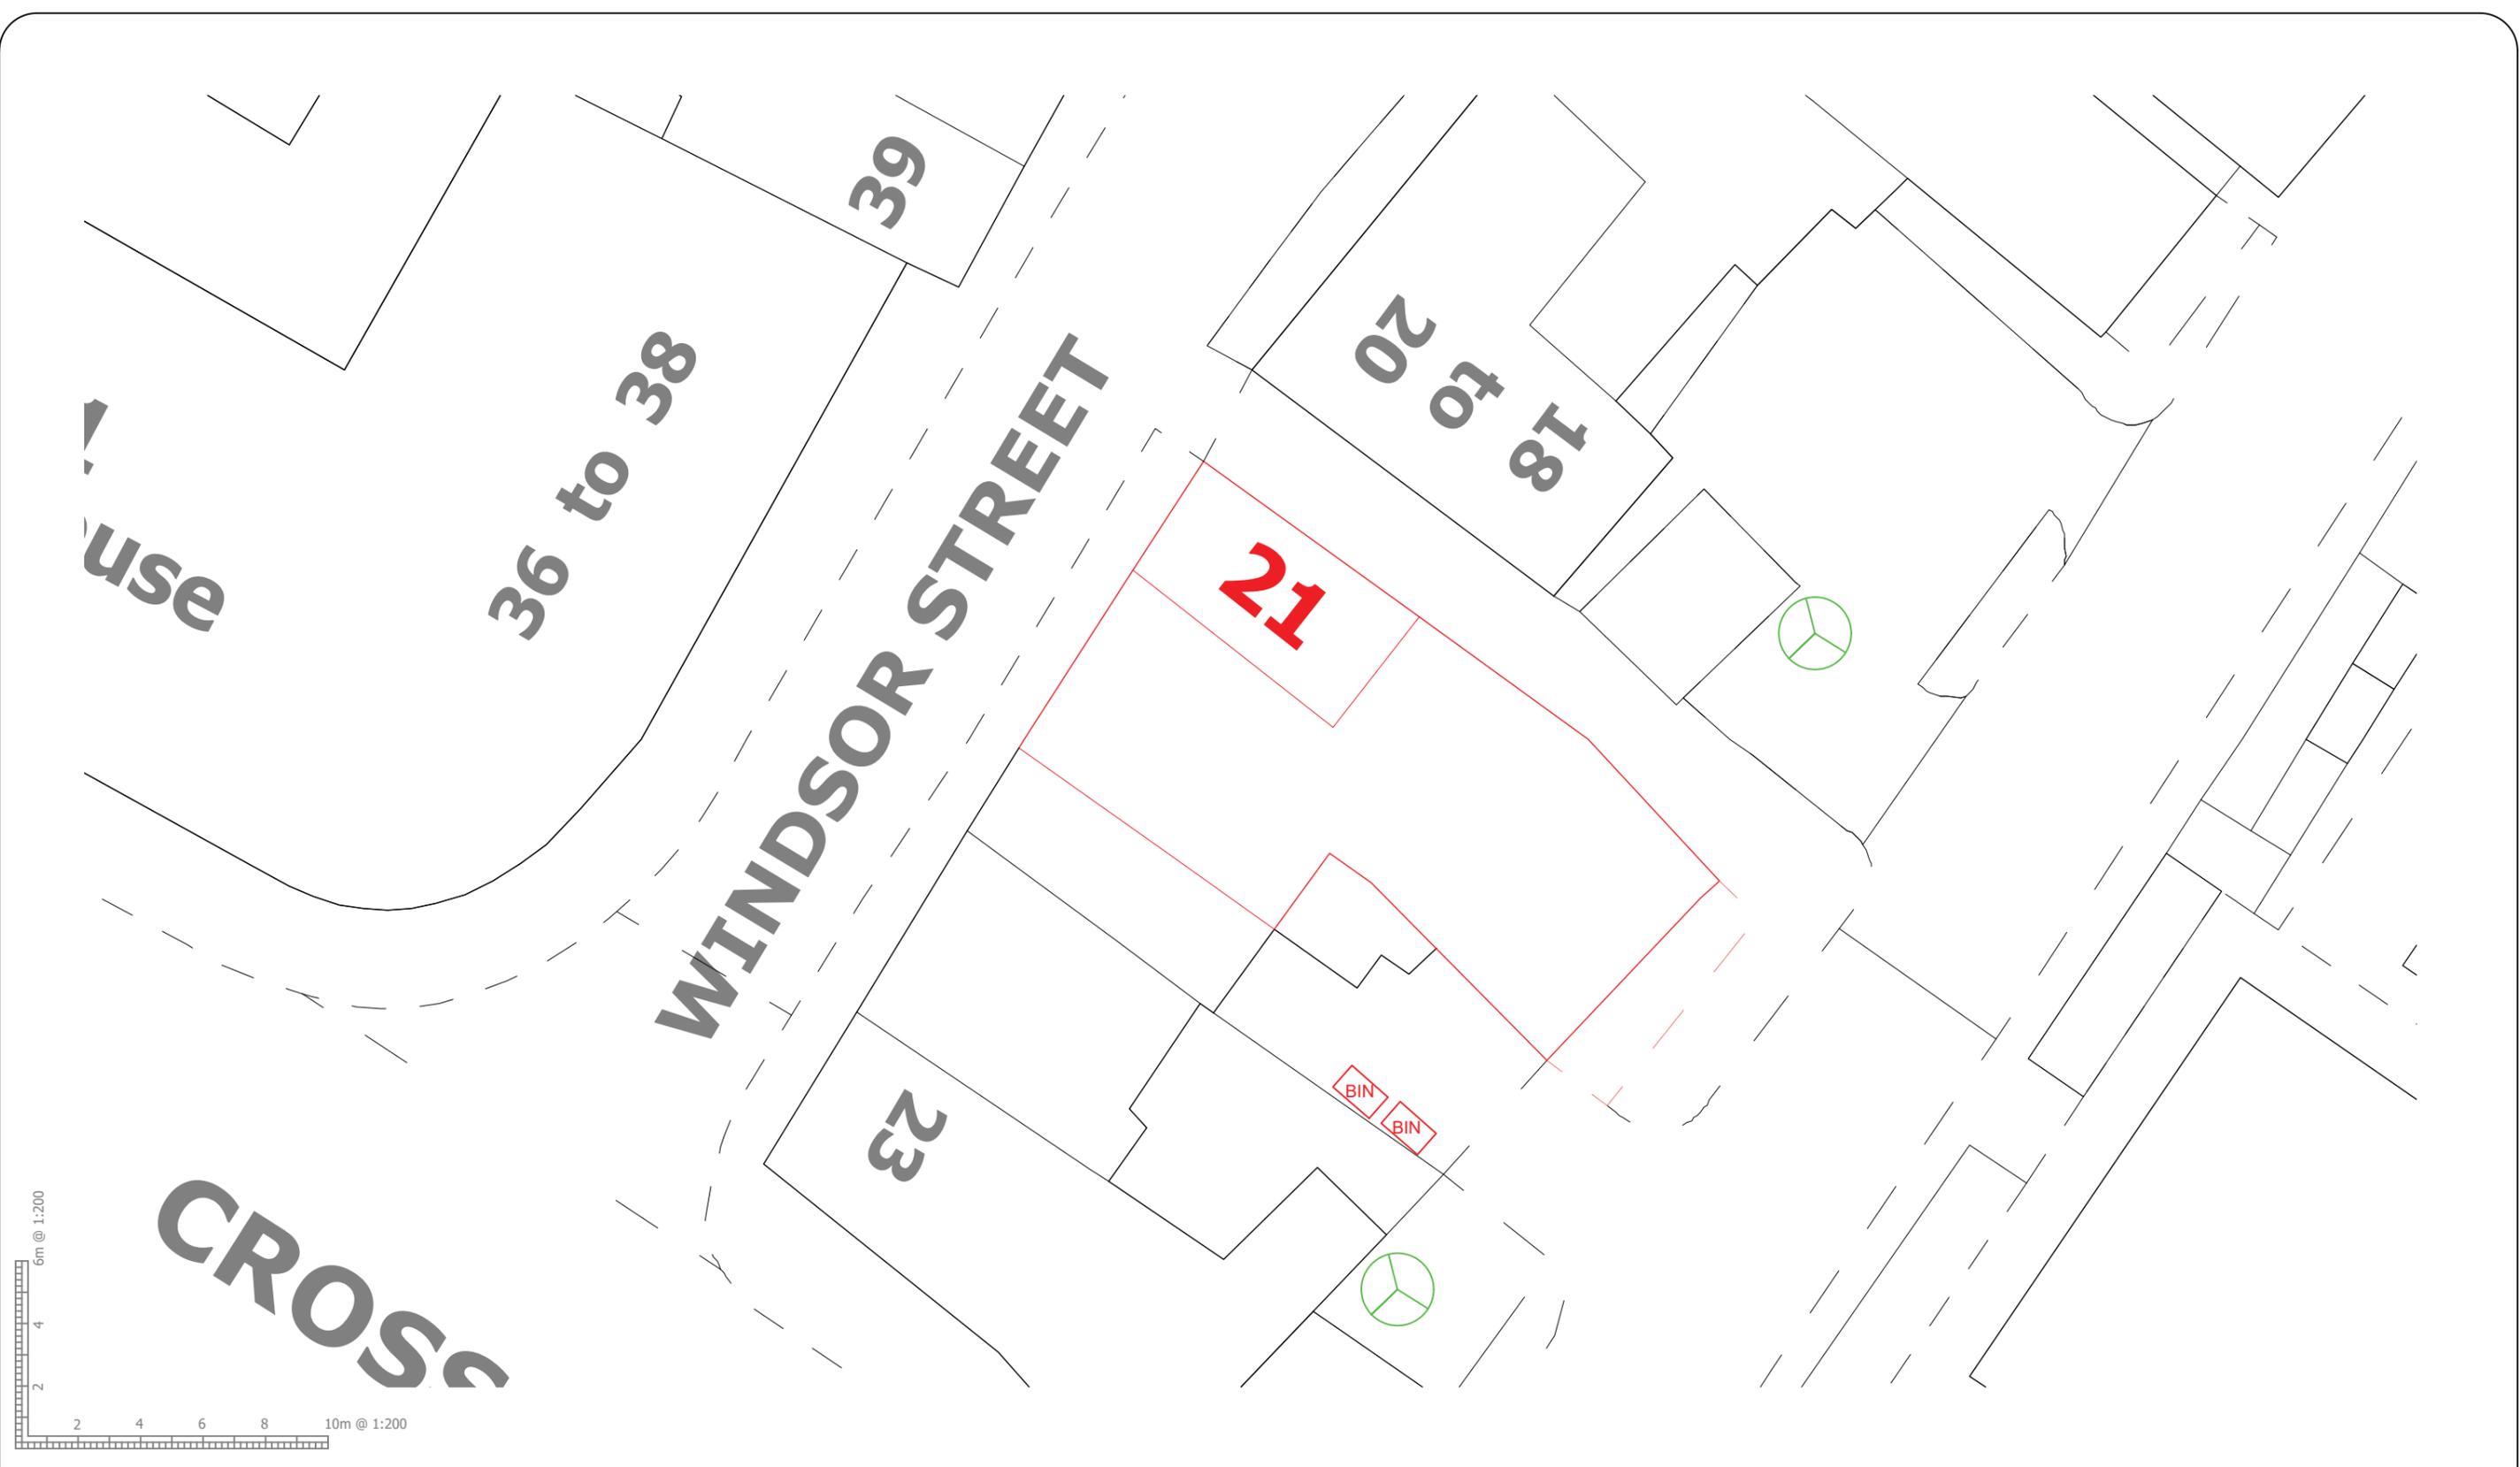

GENERAL NOTES

REVISION A : Updated Plans and extraction layout.
 REVISION B :

PROJECT NAME:
 CHUTNEI CHARM UK LTD

DRAWING TITLE:
 SITE_PLAN

DRAWN BY: RF
CHECKED BY: AI
APPROVED BY: RIZQ
DATE: 03/02/2026

CLIENT NAME & ADDRESS
 INDIKA SPICE LTD.
 21 WINDSOR STREET ,
 UXBRIDGE, UB8 1AB

COMPANY
 RIZQ
 ARCHITECTURE AND CONSTRUCTIONS LTD.
 THE VAULT BUSINESS CENTRE
 117-123 HIGH STREET, DIGBETH
 BIRMINGHAM B12 0JU
 CONTACT NO: +44744818321 /+447459760929
 E - MAIL : rizqarchitects@gmail.com

SCALE: 1:200	PROJECT NO: -	SHEET SIZE: A3
DRAWING NO: 002	SHEET NO:	
REVISION: A		
UNIT: mm		



GENERAL NOTES

REVISION A : Updated Plans and extraction layout.
 REVISION B :

PROJECT NAME:
 CHUTNEI CHARM UK LTD

DRAWING TITLE:
 EXISTING_GROUND_FLOOR_PLAN

DRAWN BY:
 RF

CHECKED BY:
 AI

APPROVED BY:
 RIZQ

DATE:
 03/02/2026

CLIENT NAME & ADDRESS
 INDIKA SPICE LTD.
 21 WINDSOR STREET ,
 UXBRIDGE, UB8 1AB

COMPANY
 RIZQ
 ARCHITECTURE AND CONSTRUCTIONS LTD.
 THE VAULT BUSINESS CENTRE
 117-123 HIGH STREET, DIGBETH
 BIRMINGHAM B12 0JU

CONTACT NO: +44744818321 /+447459760929
 E - MAIL : rizqarchitects@gmail.com

SCALE:
 1:100


DRAWING NO:
 003

REVISION:
 A



UNIT:
 mm

PROJECT NO:
 -

SHEET NO:

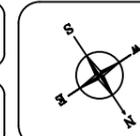

SHEET SIZE:
 A3

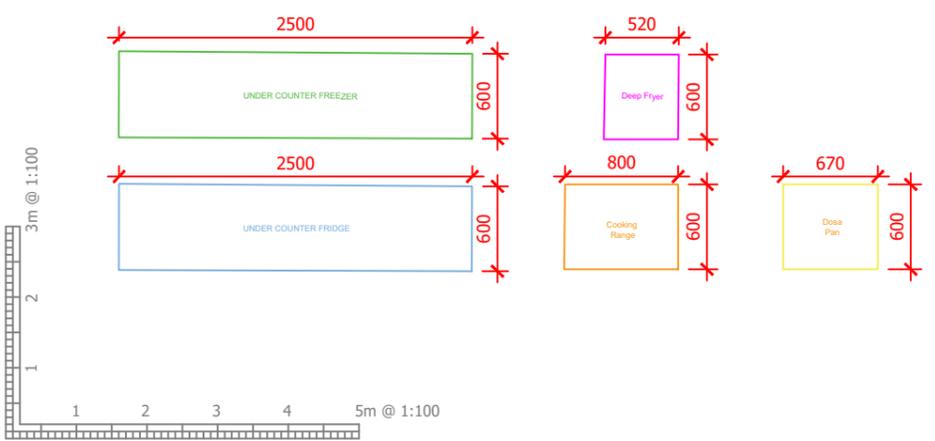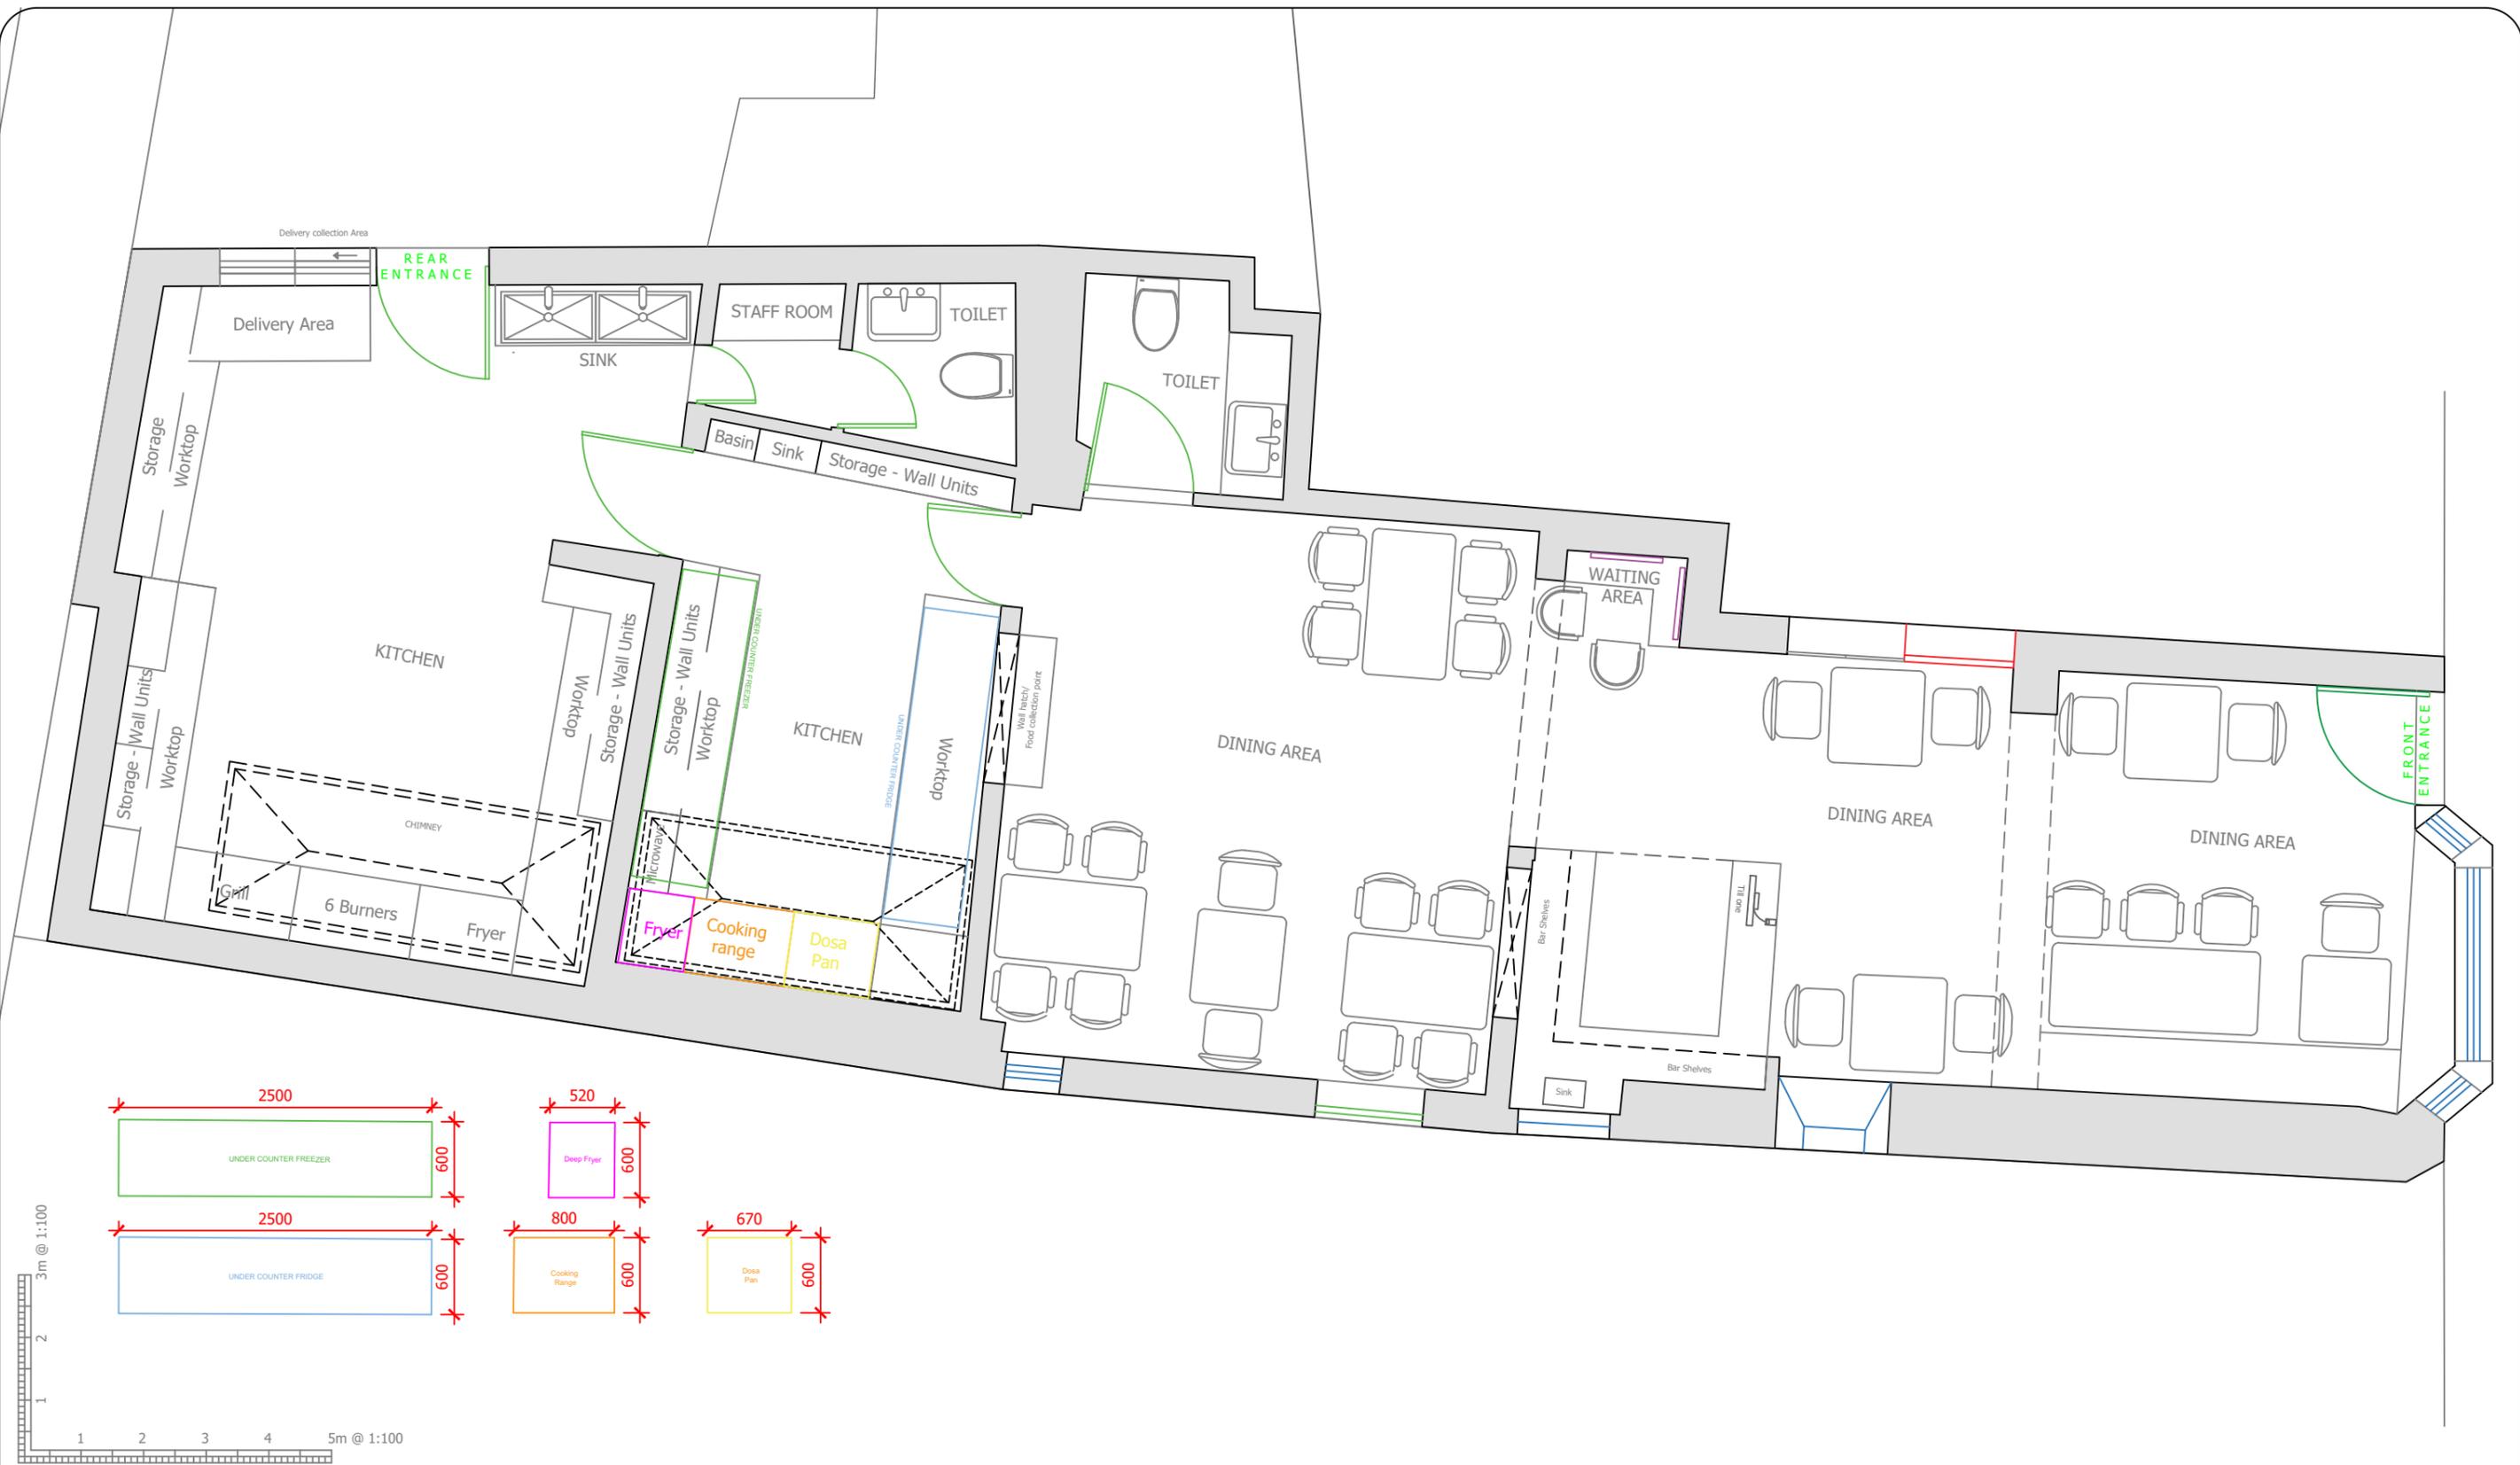

GENERAL NOTES

REVISION A : Updated Plans and extraction layout.
 REVISION B :

PROJECT NAME:
 CHUTNEI CHARM UK LTD


DRAWING TITLE:
 PROPOSED_GROUND_FLOOR_PLAN

DRAWN BY: RF
CHECKED BY: AI
APPROVED BY: RIZQ
DATE: 03/02/2026

CLIENT NAME & ADDRESS
 INDIKA SPICE LTD.
 21 WINDSOR STREET ,
 UXBRIDGE, UB8 1AB

COMPANY
 RIZQ
 ARCHITECTURE AND CONSTRUCTIONS LTD.
 THE VAULT BUSINESS CENTRE
 117-123 HIGH STREET, DIGBETH
 BIRMINGHAM B12 0JU
 CONTACT NO: +44744818321 /+447459760929
 E - MAIL : rizqarchitects@gmail.com

SCALE: 1:100	PROJECT NO: -	SHEET SIZE: A3
DRAWING NO: 004	SHEET NO:	
REVISION: A		
UNIT: mm		

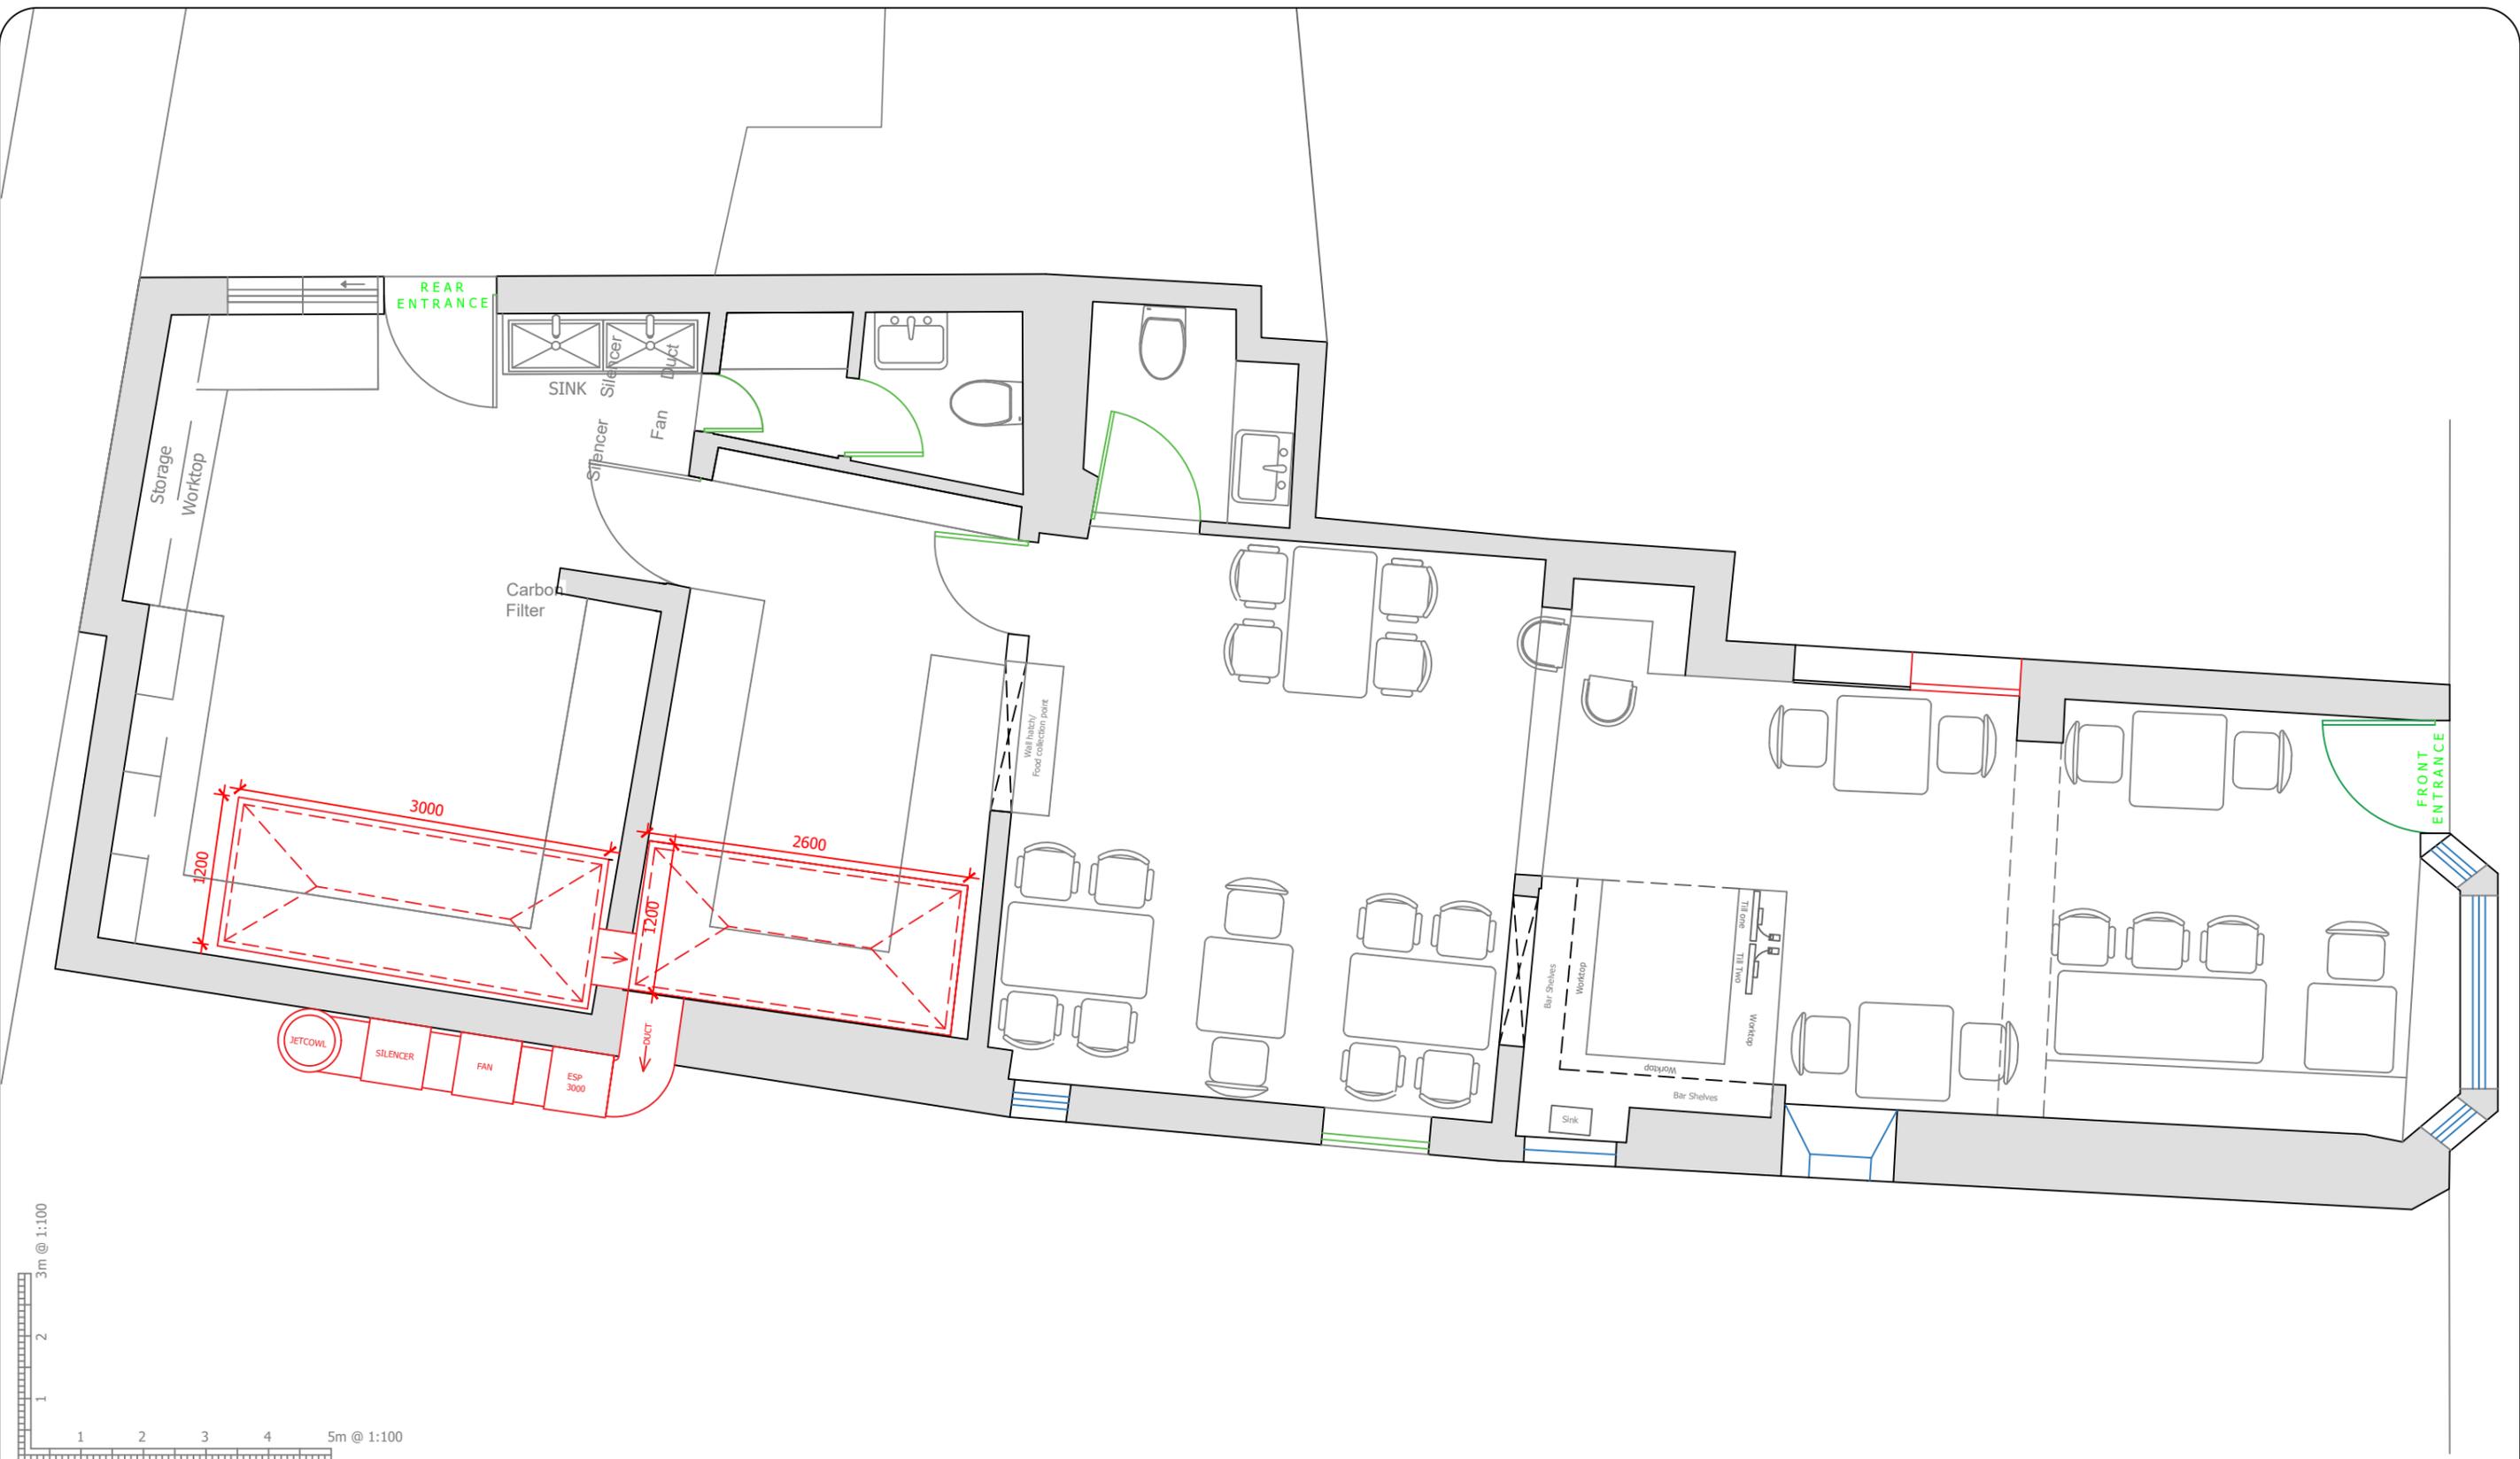

GENERAL NOTES

REVISION A : Updated Plans and extraction layout.
 REVISION B :

PROJECT NAME:
 CHUTNEI CHARM UK LTD

DRAWING TITLE:
 HVAC_EXTRACTION_PLAN

DRAWN BY:
 RF

CHECKED BY:
 AI

APPROVED BY:
 RIZQ

DATE:
 03/02/2026

CLIENT NAME & ADDRESS
 INDIKA SPICE LTD.
 21 WINDSOR STREET ,
 UXBRIDGE, UB8 1AB

COMPANY
 RIZQ
 ARCHITECTURE AND CONSTRUCTIONS LTD.
 THE VAULT BUSINESS CENTRE
 117-123 HIGH STREET, DIGBETH
 BIRMINGHAM B12 0JU

CONTACT NO: +44744818321 /+447459760929
 E - MAIL : rizqarchitects@gmail.com

SCALE:
 1:100

DRAWING NO:
 005

REVISION:
 A

UNIT:
 mm

PROJECT NO:
 -

SHEET NO:

SHEET SIZE:
 A3





GENERAL NOTES

REVISION A : Updated Plans and extraction layout.
 REVISION B :

PROJECT NAME:
 CHUTNEI CHARM UK LTD

DRAWING TITLE:
 PROPOSED_GROUND_FLOOR_WITH_DIMESIONS

DRAWN BY:
 RF

CHECKED BY:
 AI

APPROVED BY:
 RIZQ

DATE:
 03/02/2026

CLIENT NAME & ADDRESS
 INDIKA SPICE LTD.
 21 WINDSOR STREET ,
 UXBRIDGE, UB8 1AB

COMPANY
 RIZQ
 ARCHITECTURE AND CONSTRUCTIONS LTD.
 THE VAULT BUSINESS CENTRE
 117-123 HIGH STREET, DIGBETH
 BIRMINGHAM B12 0JU

CONTACT NO: +44744818321 /+447459760929
 E - MAIL : rizqarchitects@gmail.com

SCALE:
 1:100

PROJECT NO:
 -


SHEET SIZE:
 A3

DRAWING NO:
 005

SHEET NO:

REVISION:
 A

UNIT:
 mm

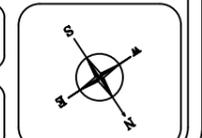

NFPA FIRE ALARM SYMBOLS	
(S)	SMOKE DETECTOR PHOTOELECTRIC PRODUCT OF COMBUSTION DETECTOR
FD 30	30 MINUTE FIRE RESISTANT DOOR
	FIRE BELL
	MANUAL CALL POINT (BREAK GLASS UNIT)
	FIRE EXTINGUISHER
	FIRE ALARM CONTROL PANEL FACP
	EMERGENCY LIGHT EM



GENERAL NOTES

REVISION A : Updated Plans and extraction layout.
 REVISION B :

PROJECT NAME:
CHUTNEI CHARM UK LTD

DRAWING TITLE:
FIRE_DRAWING_1

DRAWN BY: RF
CHECKED BY: AI
APPROVED BY: RIZQ
DATE: 03/02/2026

CLIENT NAME & ADDRESS
 INDIKA SPICE LTD.
 21 WINDSOR STREET,
 UXBRIDGE, UB8 1AB

COMPANY
 RIZQ
 ARCHITECTURE AND CONSTRUCTIONS LTD.
 THE VAULT BUSINESS CENTRE
 117-123 HIGH STREET, DIGBETH
 BIRMINGHAM B12 0JU
 CONTACT NO: +44744818321 /+447459760929
 E - MAIL : rizqarchitects@gmail.com

SCALE: 1:100
DRAWING NO: 007
REVISION: A
UNIT: mm

PROJECT NO: -
SHEET NO:
SHEET SIZE: A3

NFPA FIRE ALARM SYMBOLS	
	SMOKE DETECTOR PHOTOELECTRIC PRODUCT OF COMBUSTION DETECTOR
FD 30	30 MINUTE FIRE RESISTANT DOOR
	FIRE BELL
	MANUAL CALL POINT (BREAK GLASS UNIT)
	FIRE EXTINGUISHER
	FIRE ALARM CONTROL PANEL
	EMERGENCY LIGHT



GENERAL NOTES

REVISION A : Updated Plans and extraction layout.
 REVISION B :

PROJECT NAME:
CHUTNEI CHARM UK LTD

DRAWING TITLE:
FIRE_DRAWING_FIRE_ESCAPE_ROUTE

DRAWN BY: RF
CHECKED BY: AI
APPROVED BY: RIZQ
DATE: 03/02/2026


CLIENT NAME & ADDRESS
 INDIKA SPICE LTD.
 21 WINDSOR STREET,
 UXBRIDGE, UB8 1AB

COMPANY
 RIZQ
 ARCHITECTURE AND CONSTRUCTIONS LTD.
 THE VAULT BUSINESS CENTRE
 117-123 HIGH STREET, DIGBETH
 BIRMINGHAM B12 0JU
 CONTACT NO: +44744818321 /+447459760929
 E - MAIL : rizqarchitects@gmail.com

SCALE: 1:100
DRAWING NO: 008
REVISION: A
UNIT: mm


PROJECT NO: -
SHEET NO:
SHEET SIZE: A3



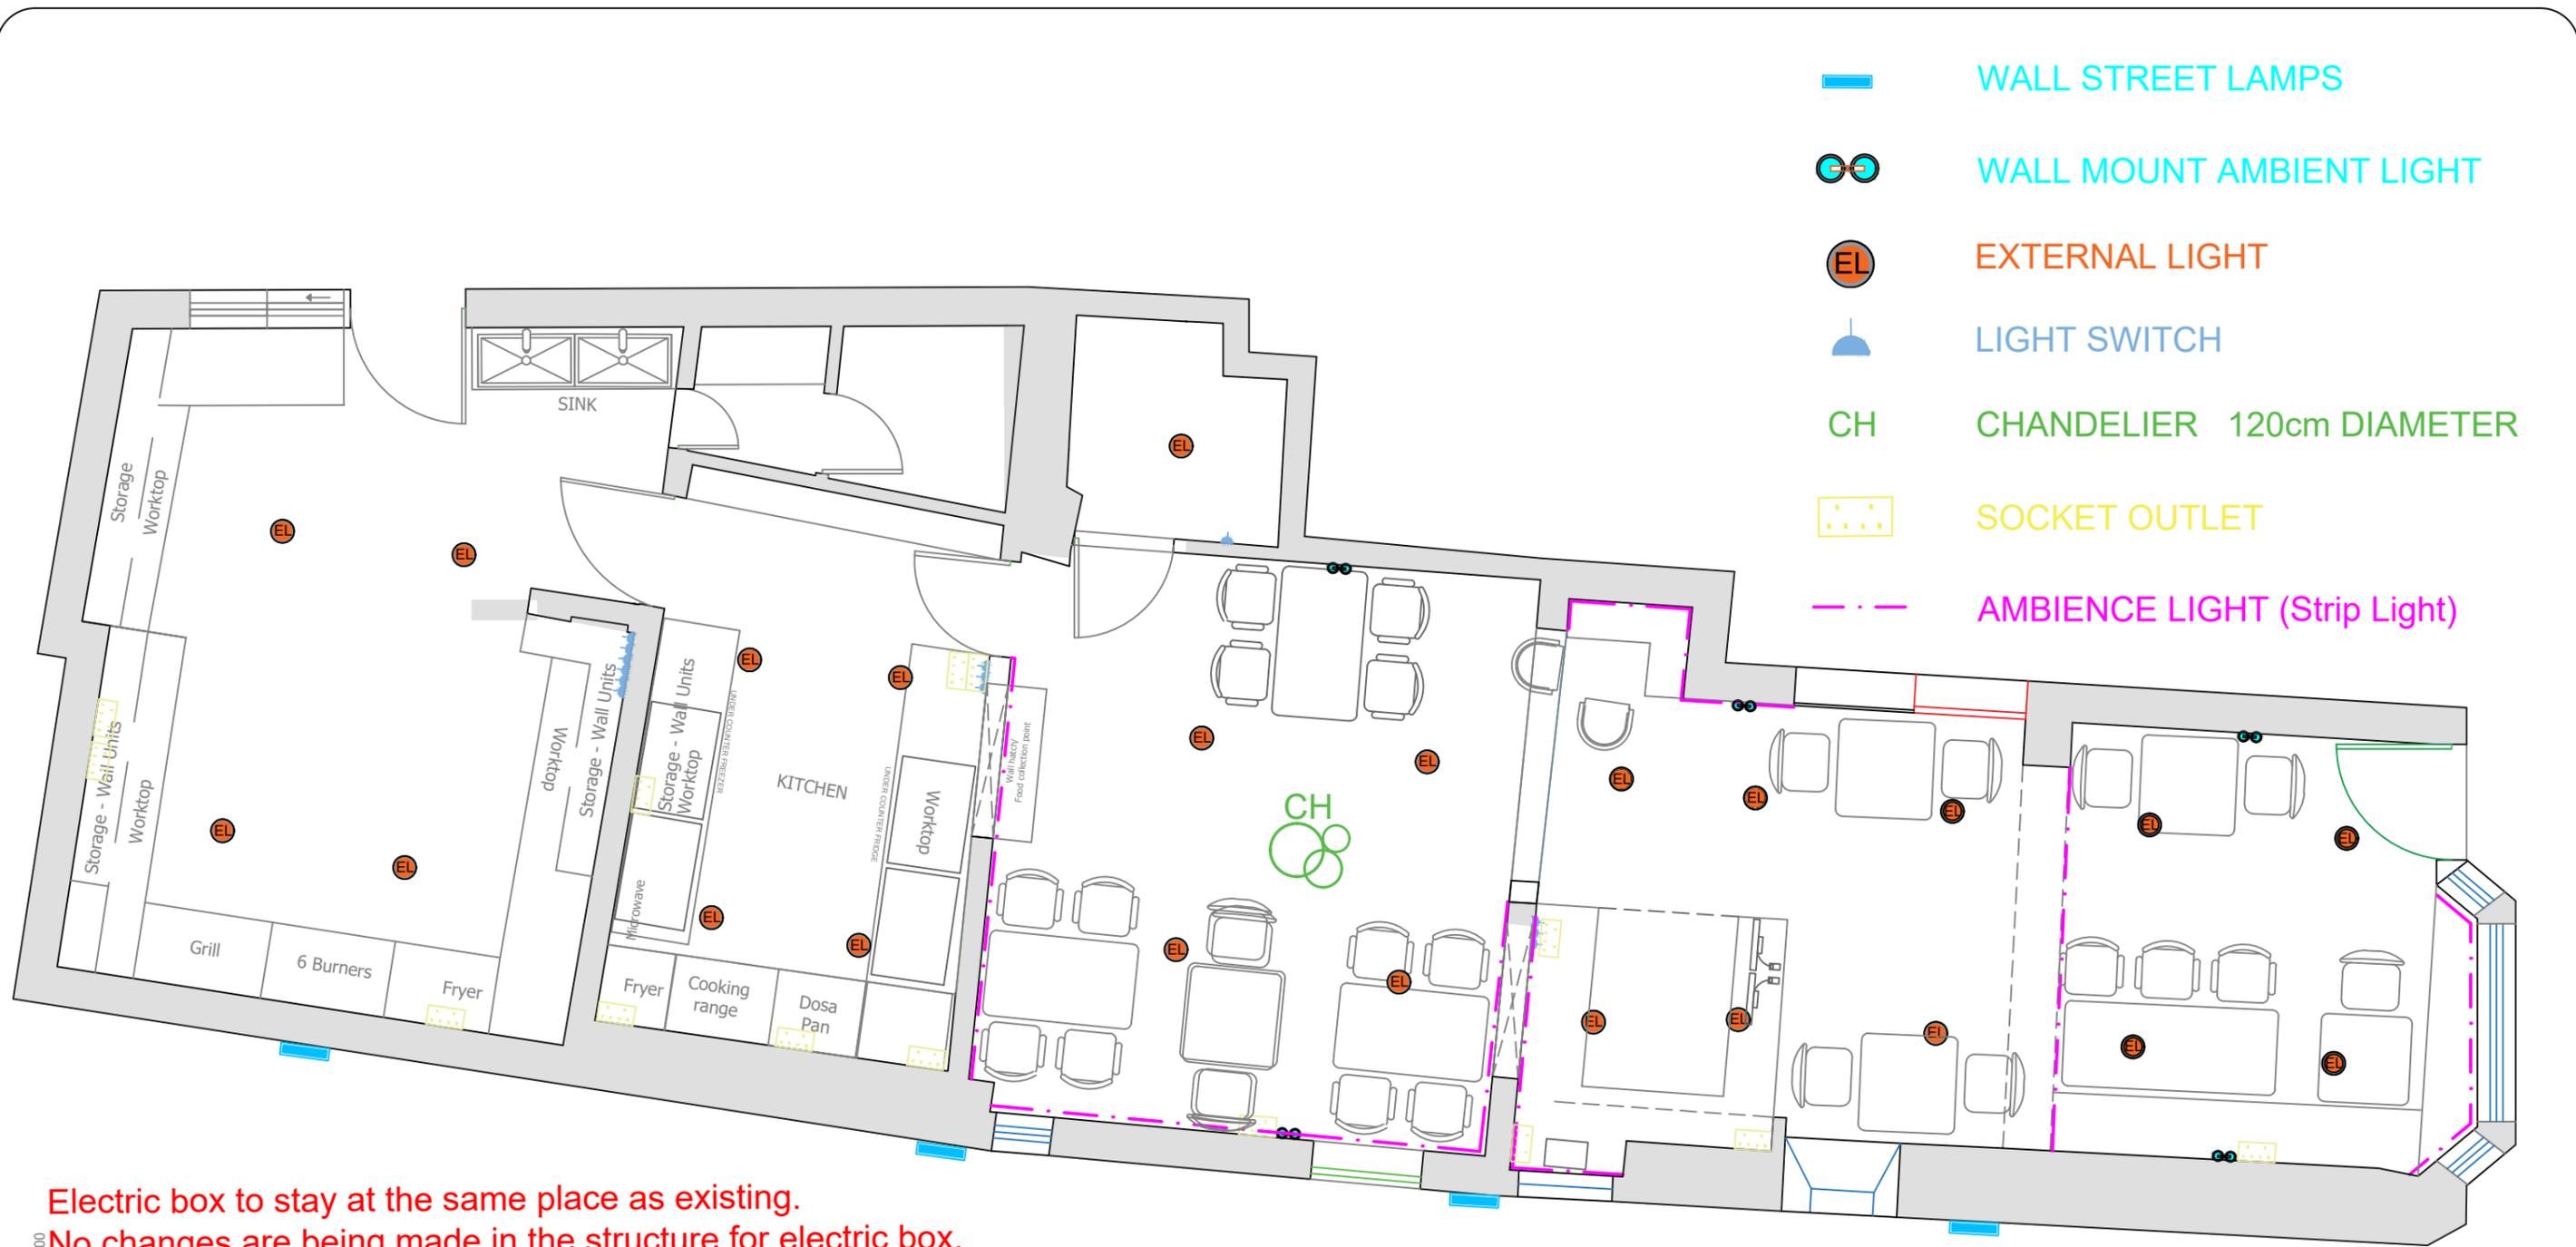

Electric box to stay at the same place as existing.
 No changes are being made in the structure for electric box.

This is just an architectural plan for electrical layout design. All electric loads and assessments to be confirmed by electrician.
 Types of outlet and outlet capacity and loads to be confirmed and decided by the electrician.

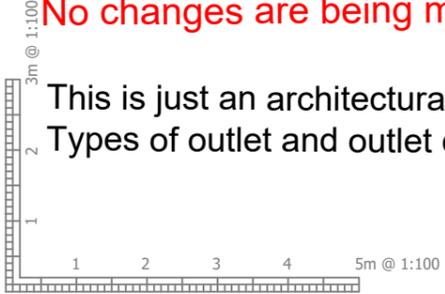


GENERAL NOTES REVISION A : Updated Plans and extraction layout. REVISION B :	PROJECT NAME: CHUTNEI CHARM UK LTD		CLIENT NAME & ADDRESS INDIKA SPICE LTD. 21 WINDSOR STREET , UXBRIDGE, UB8 1AB		COMPANY RIZQ ARCHITECTURE AND CONSTRUCTIONS LTD. THE VAULT BUSINESS CENTRE 117-123 HIGH STREET, DIGBETH BIRMINGHAM B12 0JU		SCALE: 1:100	PROJECT NO: -	SHEET SIZE: A3	
	DRAWING TITLE: ELECTRICAL LAYOUT						DRAWING NO: 009	SHEET NO:		
	DRAWN BY: RF	CHECKED BY: AI	APPROVED BY: RIZQ	DATE: 03/02/2026			REVISION: A			
							UNIT: mm			

1.5 Ton of Split AC unit with Dimensions no more than 95cm.
The Ac will circulate warm and cold air.

All the pipe work to be hidden under the ceiling and the duct dimension to be confirmed by the AC company.

Duct/outlet pipe to be connected to the existing outlet system.

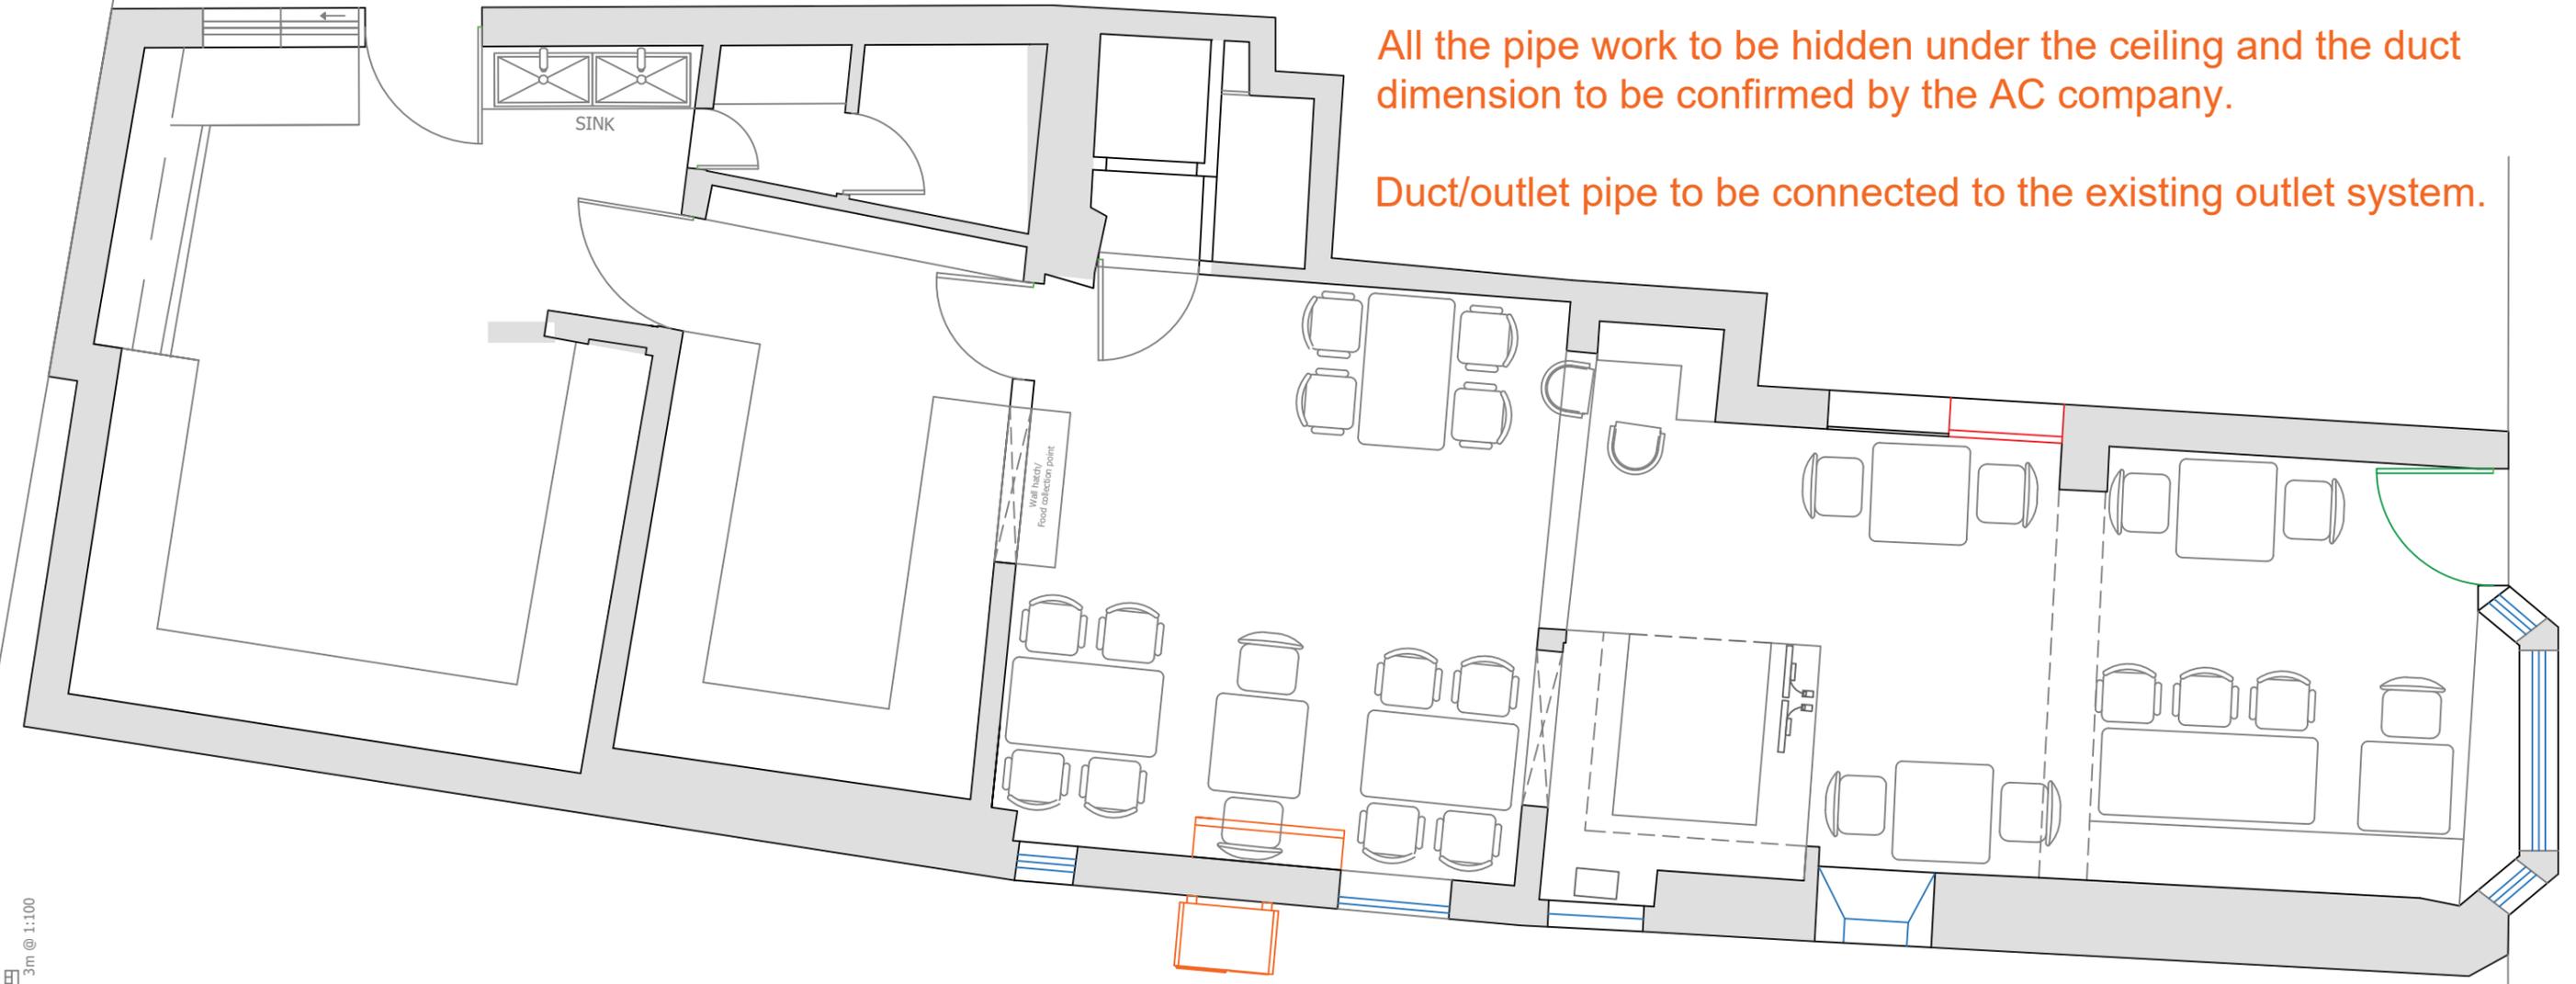

1.5 TON SPLIT AC UNIT

GENERAL NOTES

REVISION A : Updated plans and condition layout.
REVISION B :

PROJECT NAME:
CHUTNEI CHARM UK LTD

DRAWING TITLE:
HVAC - AIR_CONDITIONING

DRAWN BY:
RF

CHECKED BY:
AI

APPROVED BY:
RIZQ

DATE:
03/02/2026

CLIENT NAME & ADDRESS
INDIKA SPICE LTD.
21 WINDSOR STREET ,
UXBRIDGE, UB8 1AB

COMPANY
RIZQ
ARCHITECTURE AND CONSTRUCTIONS LTD.
THE VAULT BUSINESS CENTRE
117-123 HIGH STREET, DIGBETH
BIRMINGHAM B12 0JU

CONTACT NO: +44744818321 /+447459760929
E - MAIL : rizqarchitects@gmail.com

SCALE:
1:100

DRAWING NO:
010

REVISION:
A


UNIT:
mm

PROJECT NO:
-

SHEET NO:

SHEET SIZE:
A3



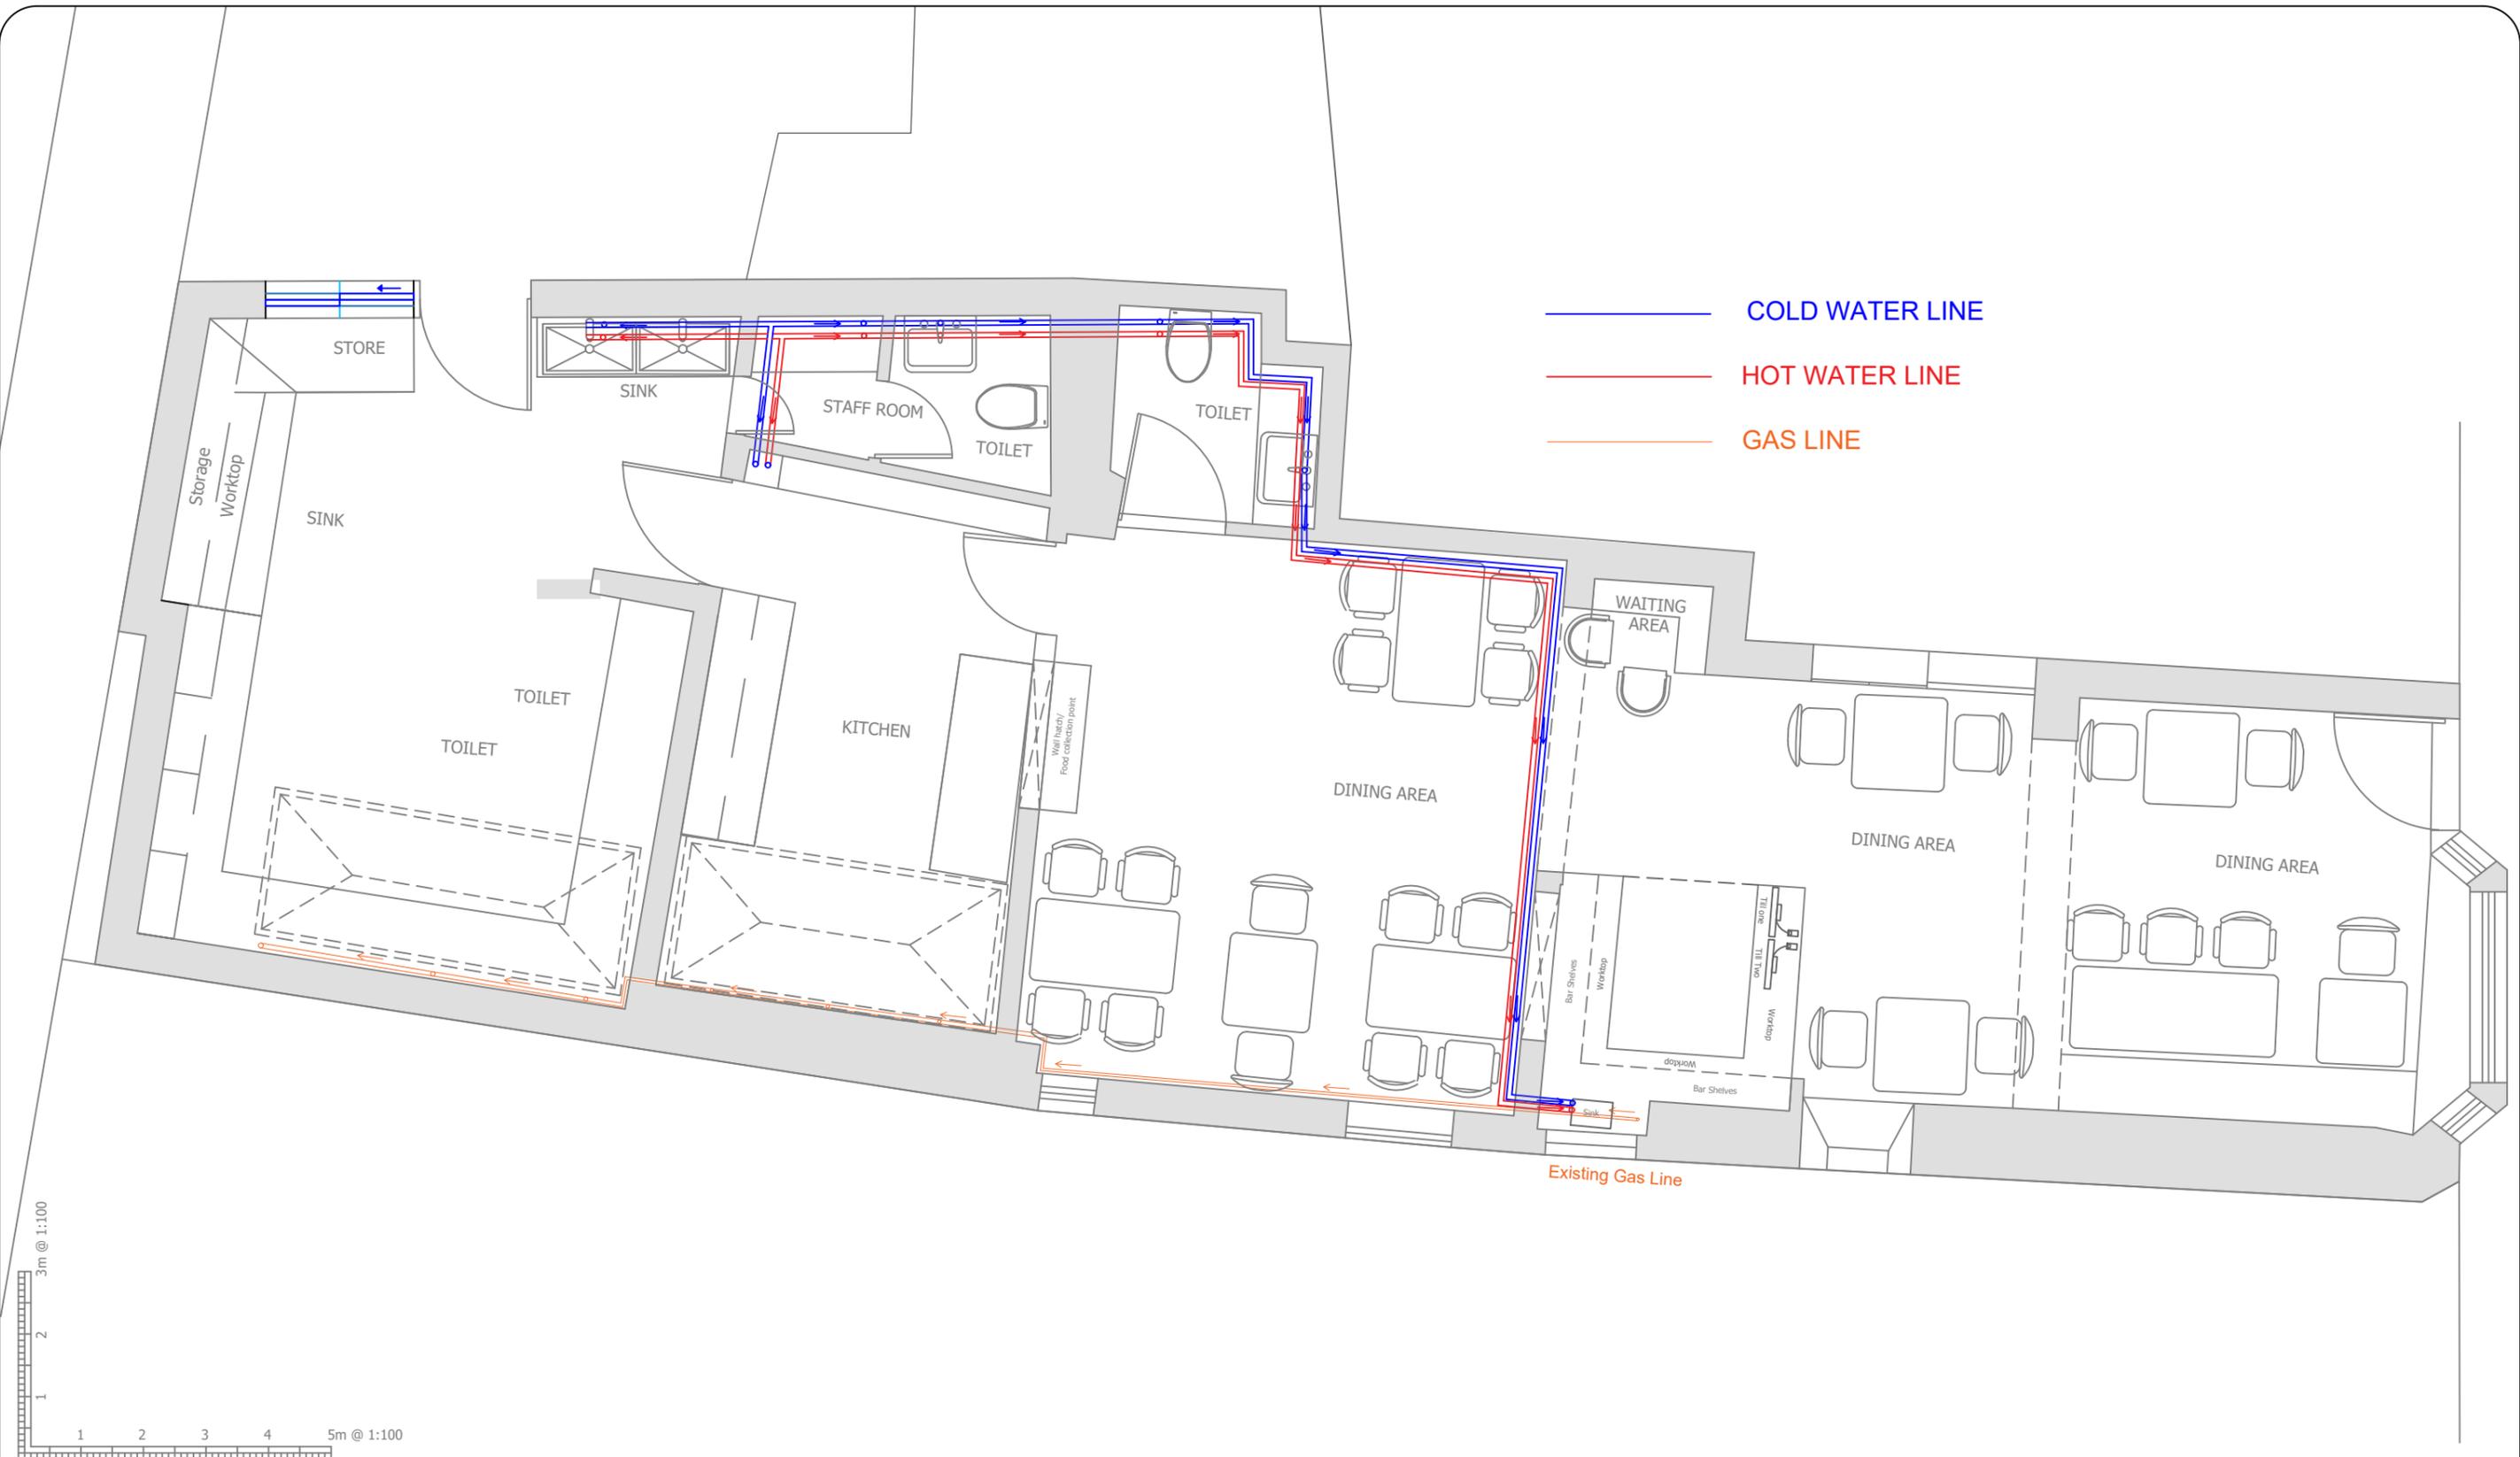

GENERAL NOTES

REVISION A : Updated Plans and extraction layout.
 REVISION B :

PROJECT NAME:
 CHUTNEI CHARM UK LTD

DRAWING TITLE:
 WATER INLET HOT AND COLD & GAS INLET

DRAWN BY:
 RF

CHECKED BY:
 AI

APPROVED BY:
 RIZQ

DATE:
 03/02/2026

CLIENT NAME & ADDRESS
 INDIKA SPICE LTD.
 21 WINDSOR STREET ,
 UXBRIDGE, UB8 1AB

COMPANY
 RIZQ
 ARCHITECTURE AND CONSTRUCTIONS LTD.
 THE VAULT BUSINESS CENTRE
 117-123 HIGH STREET, DIGBETH
 BIRMINGHAM B12 0JU

CONTACT NO: +44744818321 /+447459760929
 E - MAIL : rizqarchitects@gmail.com

SCALE:
 1:100

DRAWING NO:
 011

REVISION:
 A

UNIT:
 mm

PROJECT NO:
 -

SHEET NO:
 -

SHEET SIZE:
 A3






EXISTING FRONT ELEVATION




EXISTING SIDE ELEVATION

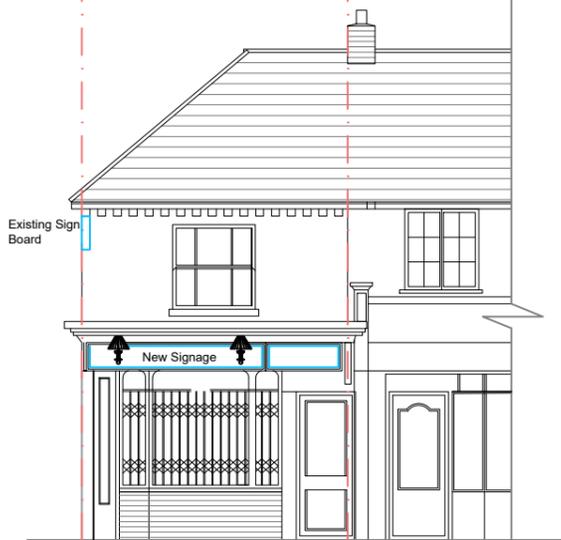

PROPOSED FRONT ELEVATION



PROPOSED SIDE ELEVATION

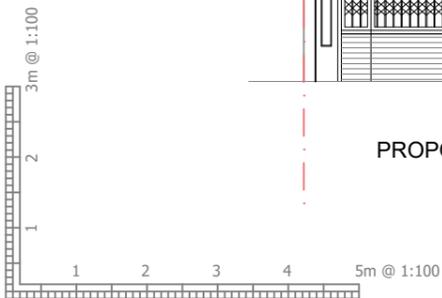

GENERAL NOTES

REVISION A : Updated Plans and extraction layout.
REVISION B :

PROJECT NAME:
CHUTNEI CHARM UK LTD

DRAWING TITLE:
ELEVATIONS

DRAWN BY:
RF

CHECKED BY:
AI

APPROVED BY:
RIZQ

DATE:
03/02/2026

CLIENT NAME & ADDRESS
INDIKA SPICE LTD.
21 WINDSOR STREET ,
UXBRIDGE, UB8 1AB

COMPANY
RIZQ
ARCHITECTURE AND CONSTRUCTIONS LTD.
THE VAULT BUSINESS CENTRE
117-123 HIGH STREET, DIGBETH
BIRMINGHAM B12 0JU

CONTACT NO: +44744818321 /+447459760929
E - MAIL : rizqarchitects@gmail.com

SCALE:
1:100

DRAWING NO:
012

REVISION:
A

UNIT:
mm

PROJECT NO:
-

SHEET NO:

SHEET SIZE:
A3





EXISTING REAR ELEVATION



EXISTING SIDE ELEVATION



PROPOSED REAR ELEVATION



PROPOSED SIDE ELEVATION

GENERAL NOTES

REVISION A : Updated Plans and extraction layout.
 REVISION B :

PROJECT NAME:
 CHUTNEI CHARM UK LTD

DRAWING TITLE:
 ELEVATIONS_2

DRAWN BY:
 RF

CHECKED BY:
 AI

APPROVED BY:
 RIZQ

DATE:
 03/02/2026

CLIENT NAME & ADDRESS
 INDIKA SPICE LTD.
 21 WINDSOR STREET ,
 UXBRIDGE, UB8 1AB

COMPANY
 RIZQ
 ARCHITECTURE AND CONSTRUCTIONS LTD.
 THE VAULT BUSINESS CENTRE
 117-123 HIGH STREET, DIGBETH
 BIRMINGHAM B12 0JU

CONTACT NO: +44744818321 /+447459760929
 E - MAIL : rizqarchitects@gmail.com

SCALE:
 1:100


DRAWING NO:
 013


REVISION:
 A

UNIT:
 mm


PROJECT NO:
 - SHEET SIZE:
 A3

SHEET NO:

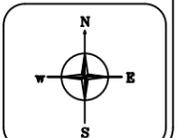


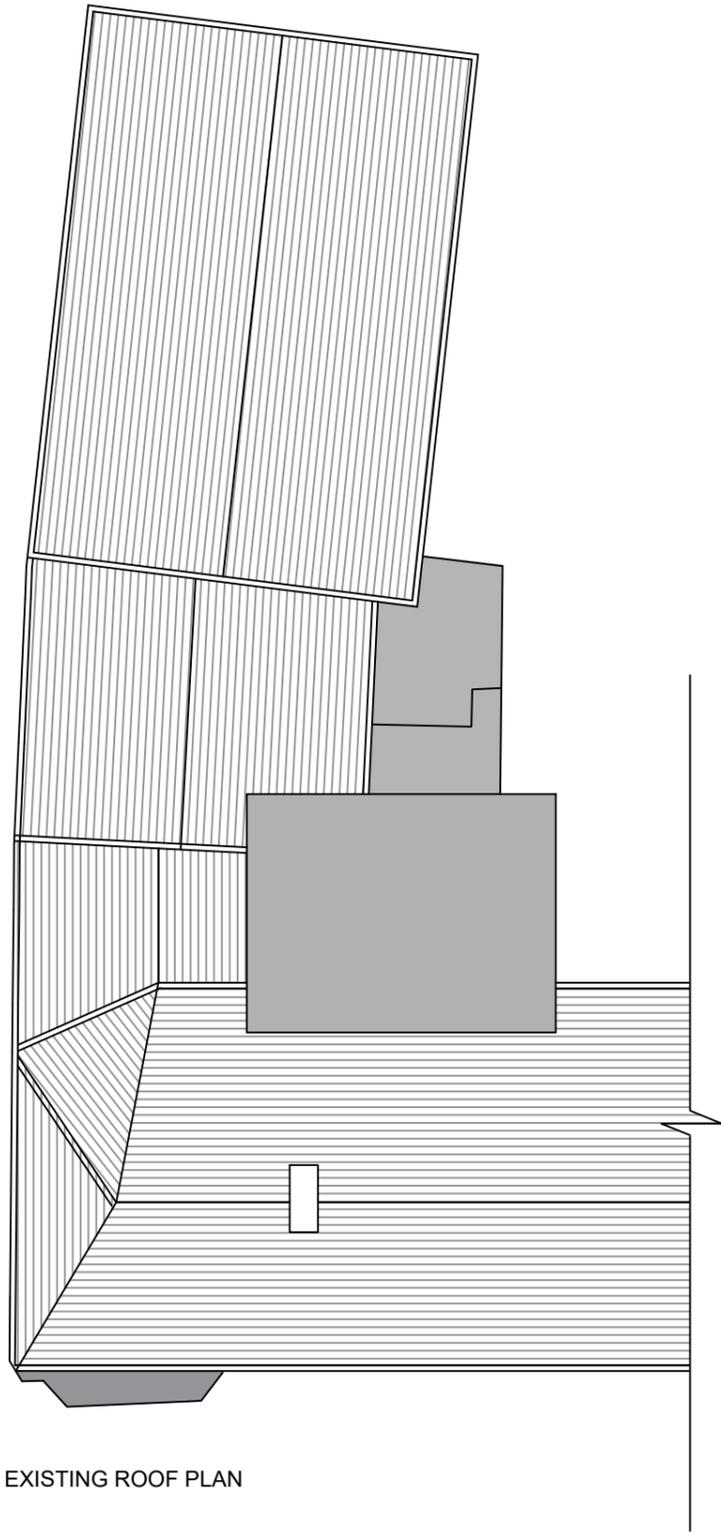

EXISTING ROOF PLAN

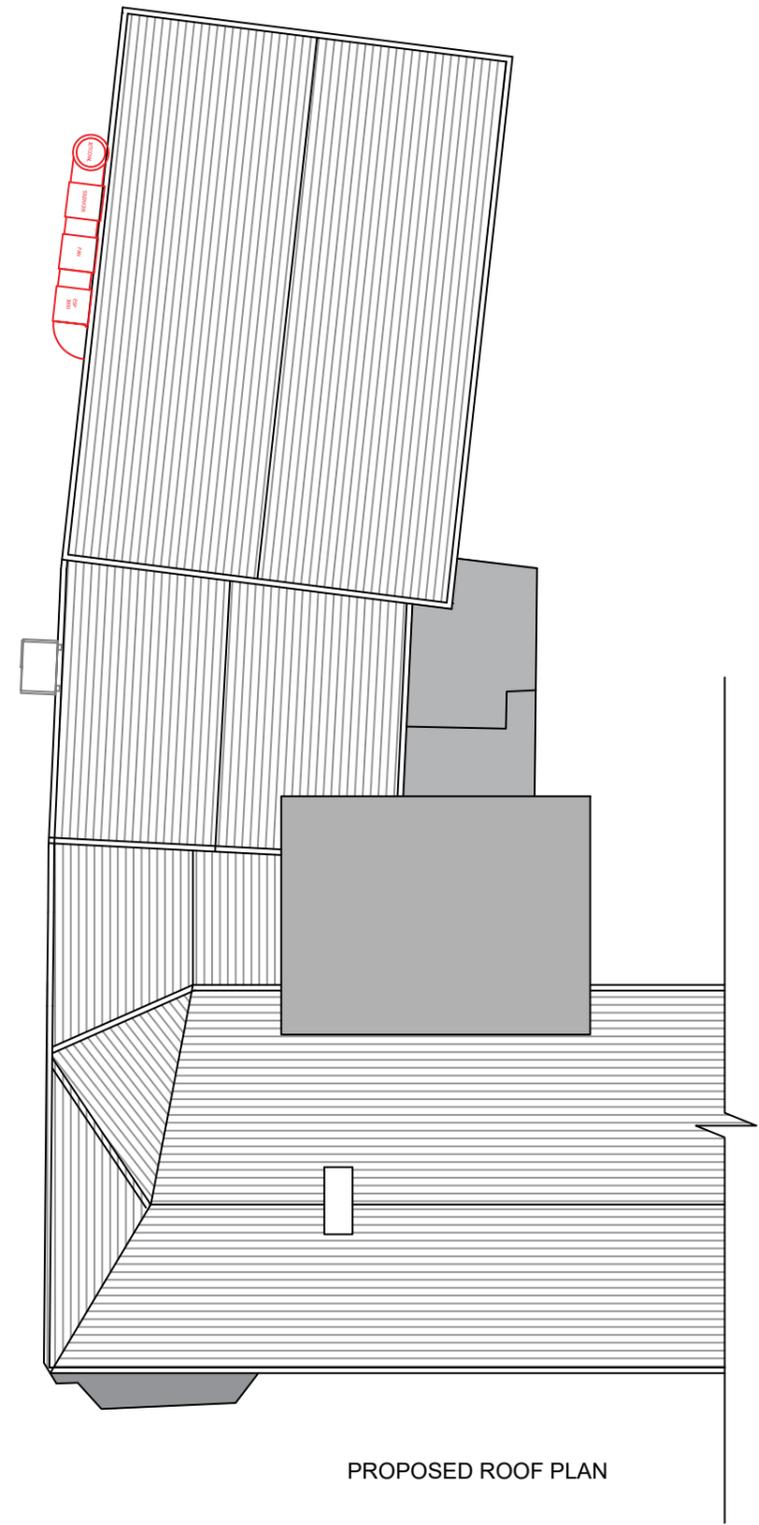

PROPOSED ROOF PLAN

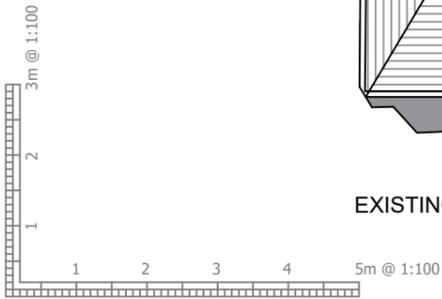

GENERAL NOTES

REVISION A : Updated Positioning
 REVISION B :

PROJECT NAME:
 CHUTNEI CHARM UK LTD

DRAWING TITLE:
 ROOF_PLAN

DRAWN BY: RF
 CHECKED BY: AI
 APPROVED BY: RIZQ
 DATE: 03/02/2026

CLIENT NAME & ADDRESS
 INDIKA SPICE LTD.
 21 WINDSOR STREET ,
 UXBRIDGE, UB8 1AB

COMPANY
 RIZQ
 ARCHITECTURE AND CONSTRUCTIONS LTD.
 THE VAULT BUSINESS CENTRE
 117-123 HIGH STREET, DIGBETH
 BIRMINGHAM B12 0JU
 CONTACT NO: +44744818321 /+447459760929
 E - MAIL : rizqarchitects@gmail.com

SCALE: 1:100	PROJECT NO: -	SHEET SIZE: A3
DRAWING NO: 014	SHEET NO:	
REVISION: A		
UNIT: mm		