


#### HARD LANDSCAPING

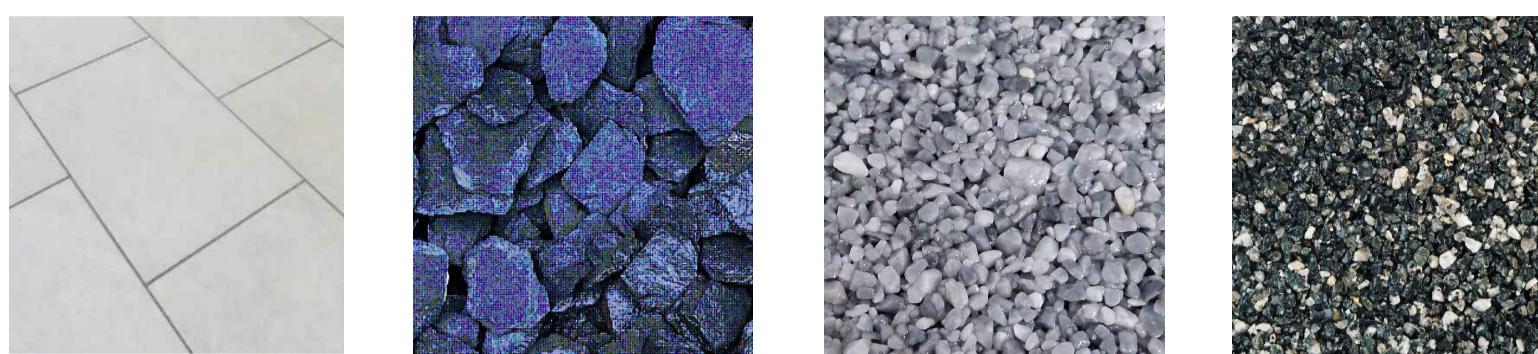

LIGHT GREY PAVING    BLUE SLATE CHIPPINGS    PAVING - LIGHT GREY COLOUR    DRIVEWAY - SLATE GREY COLOUR



OVERLAP WOOD FENCE PANELS

#### SOFT LANDSCAPING



PHOTINIA HEDGE    LAVENDER    ESPALIER FRUIT TREE    ESPALIER FRUIT TREE    WISTERIA



PERIWINKLE GROUND COVER    LAVENDER    MAPLE TREE    SILVER BRICH

#### MAINTENANCE


MAINTENANCE TO COMPLY WITH BS 395 AND BS 4428.

DURING THE FIRST FIVE YEARS KEEP PLANTING WEEDED AND WATERED UNTIL WELL ESTABLISHED ANY SHRUB WHICH DIES OR IS REMOVED IS TO BE REPLACED IN NEXT PLANTING SEASON. SOIL AROUND PLANTS TO BE FIRMED AND MULCH MADE GOOD AFTER HIGH WINDS & FROSTS AND GIVEN ANNUAL FEEDING OF A GOOD FERTILIZER.

PRUNING TO BE CARRIED OUT BY QUALIFIED PERSONS. PHOTINIA HEDGE TO BE CUT WHEN REACHING 2 METRE HEIGHT AND MAINTAINED THEREAFTER. QUALIFIED LANDSCAPE CONTRACTOR TO CARRY OUT THE PLANTING SCHEME AND UNDERTAKE TO ARRANGE A CONTRACT TO CARRY OUT MAINTENANCE WORKS TO THE APPROVED SCHEME.



#### LIGHTING

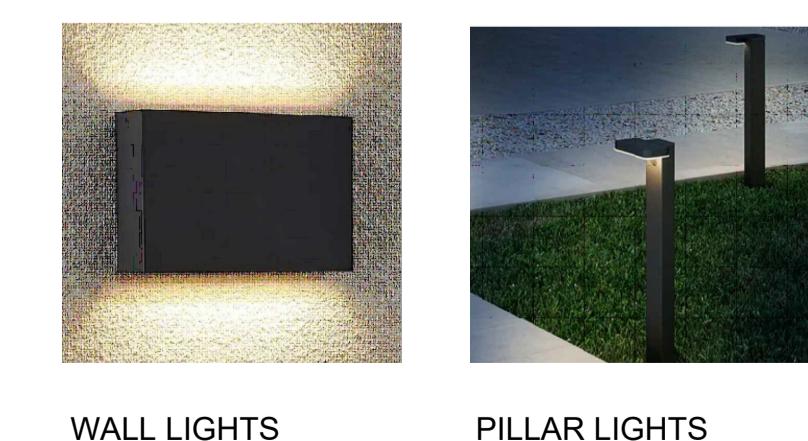

WALL LIGHTS    PILLAR LIGHTS

GENERAL AMENDMENTS    MAY '25 DATE    A REV.  
COPYRIGHT RESERVED  
ALL SCALED DIMENSIONS MUST BE VERIFIED ON SITE

JOB  
5A HARROW VIEW  
UXBRIDGE  
UB10 0QG  
CLIENT

DRAWING  
LANDSCAPE PLAN  
LIGHTING PLAN

DALE VENN ARCHITECTS  
Architects, Planners & Surveyors  
HIGH HOUSE, HARLINGTON ROAD,  
HILLINGDON, MIDDLESEX    01895-237345

SCALE 1:200 @A1	DRAWING No.	REV.
DATE JAN'25		
DRAWN LK		
CHECKED DV		

5092-27 A