



Notes
 ALL MEASUREMENTS, DIMENSIONS SHOULD BE VERIFIED ON SITE
 AND IN ACCORDANCE TO EXISTING SITE CONDITIONS.
 DRAWINGS ARE THE PROPERTY OF THE DRAWING OWNER.
 DRAWING TO BE PREPARED BY SPECIALIST AND SUBMITTED
 FOR LANDSCAPE ARCHITECTS APPROVAL.

ALL PAVING MATERIAL FOR EVA OR VEHICLE AREAS
 USE 60mm THK.

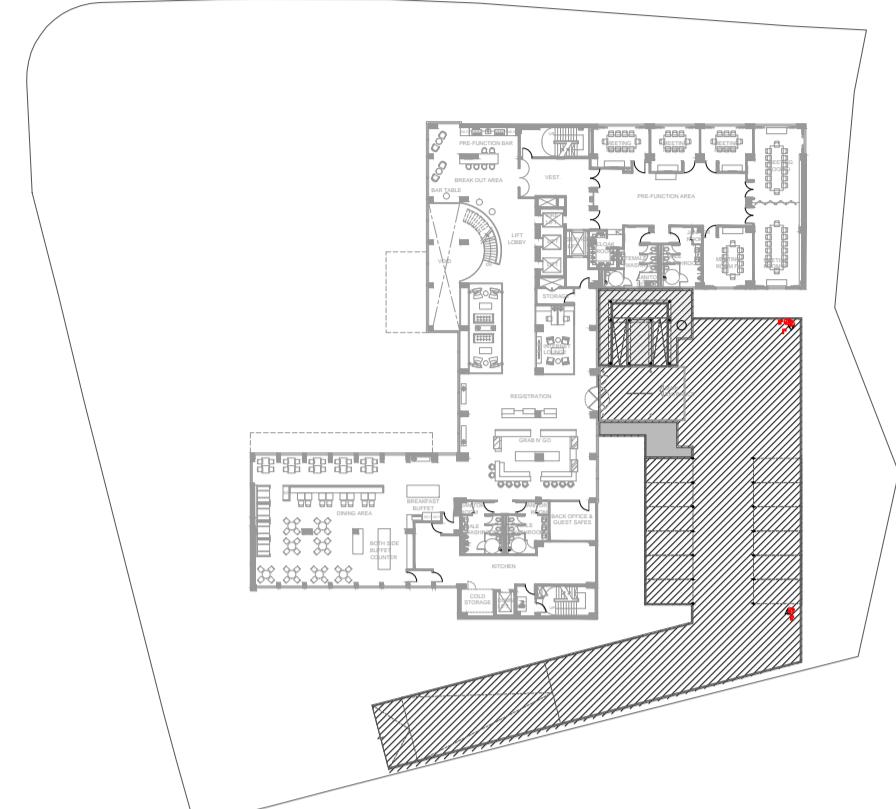

B KEY PLAN
SCALE 1:750

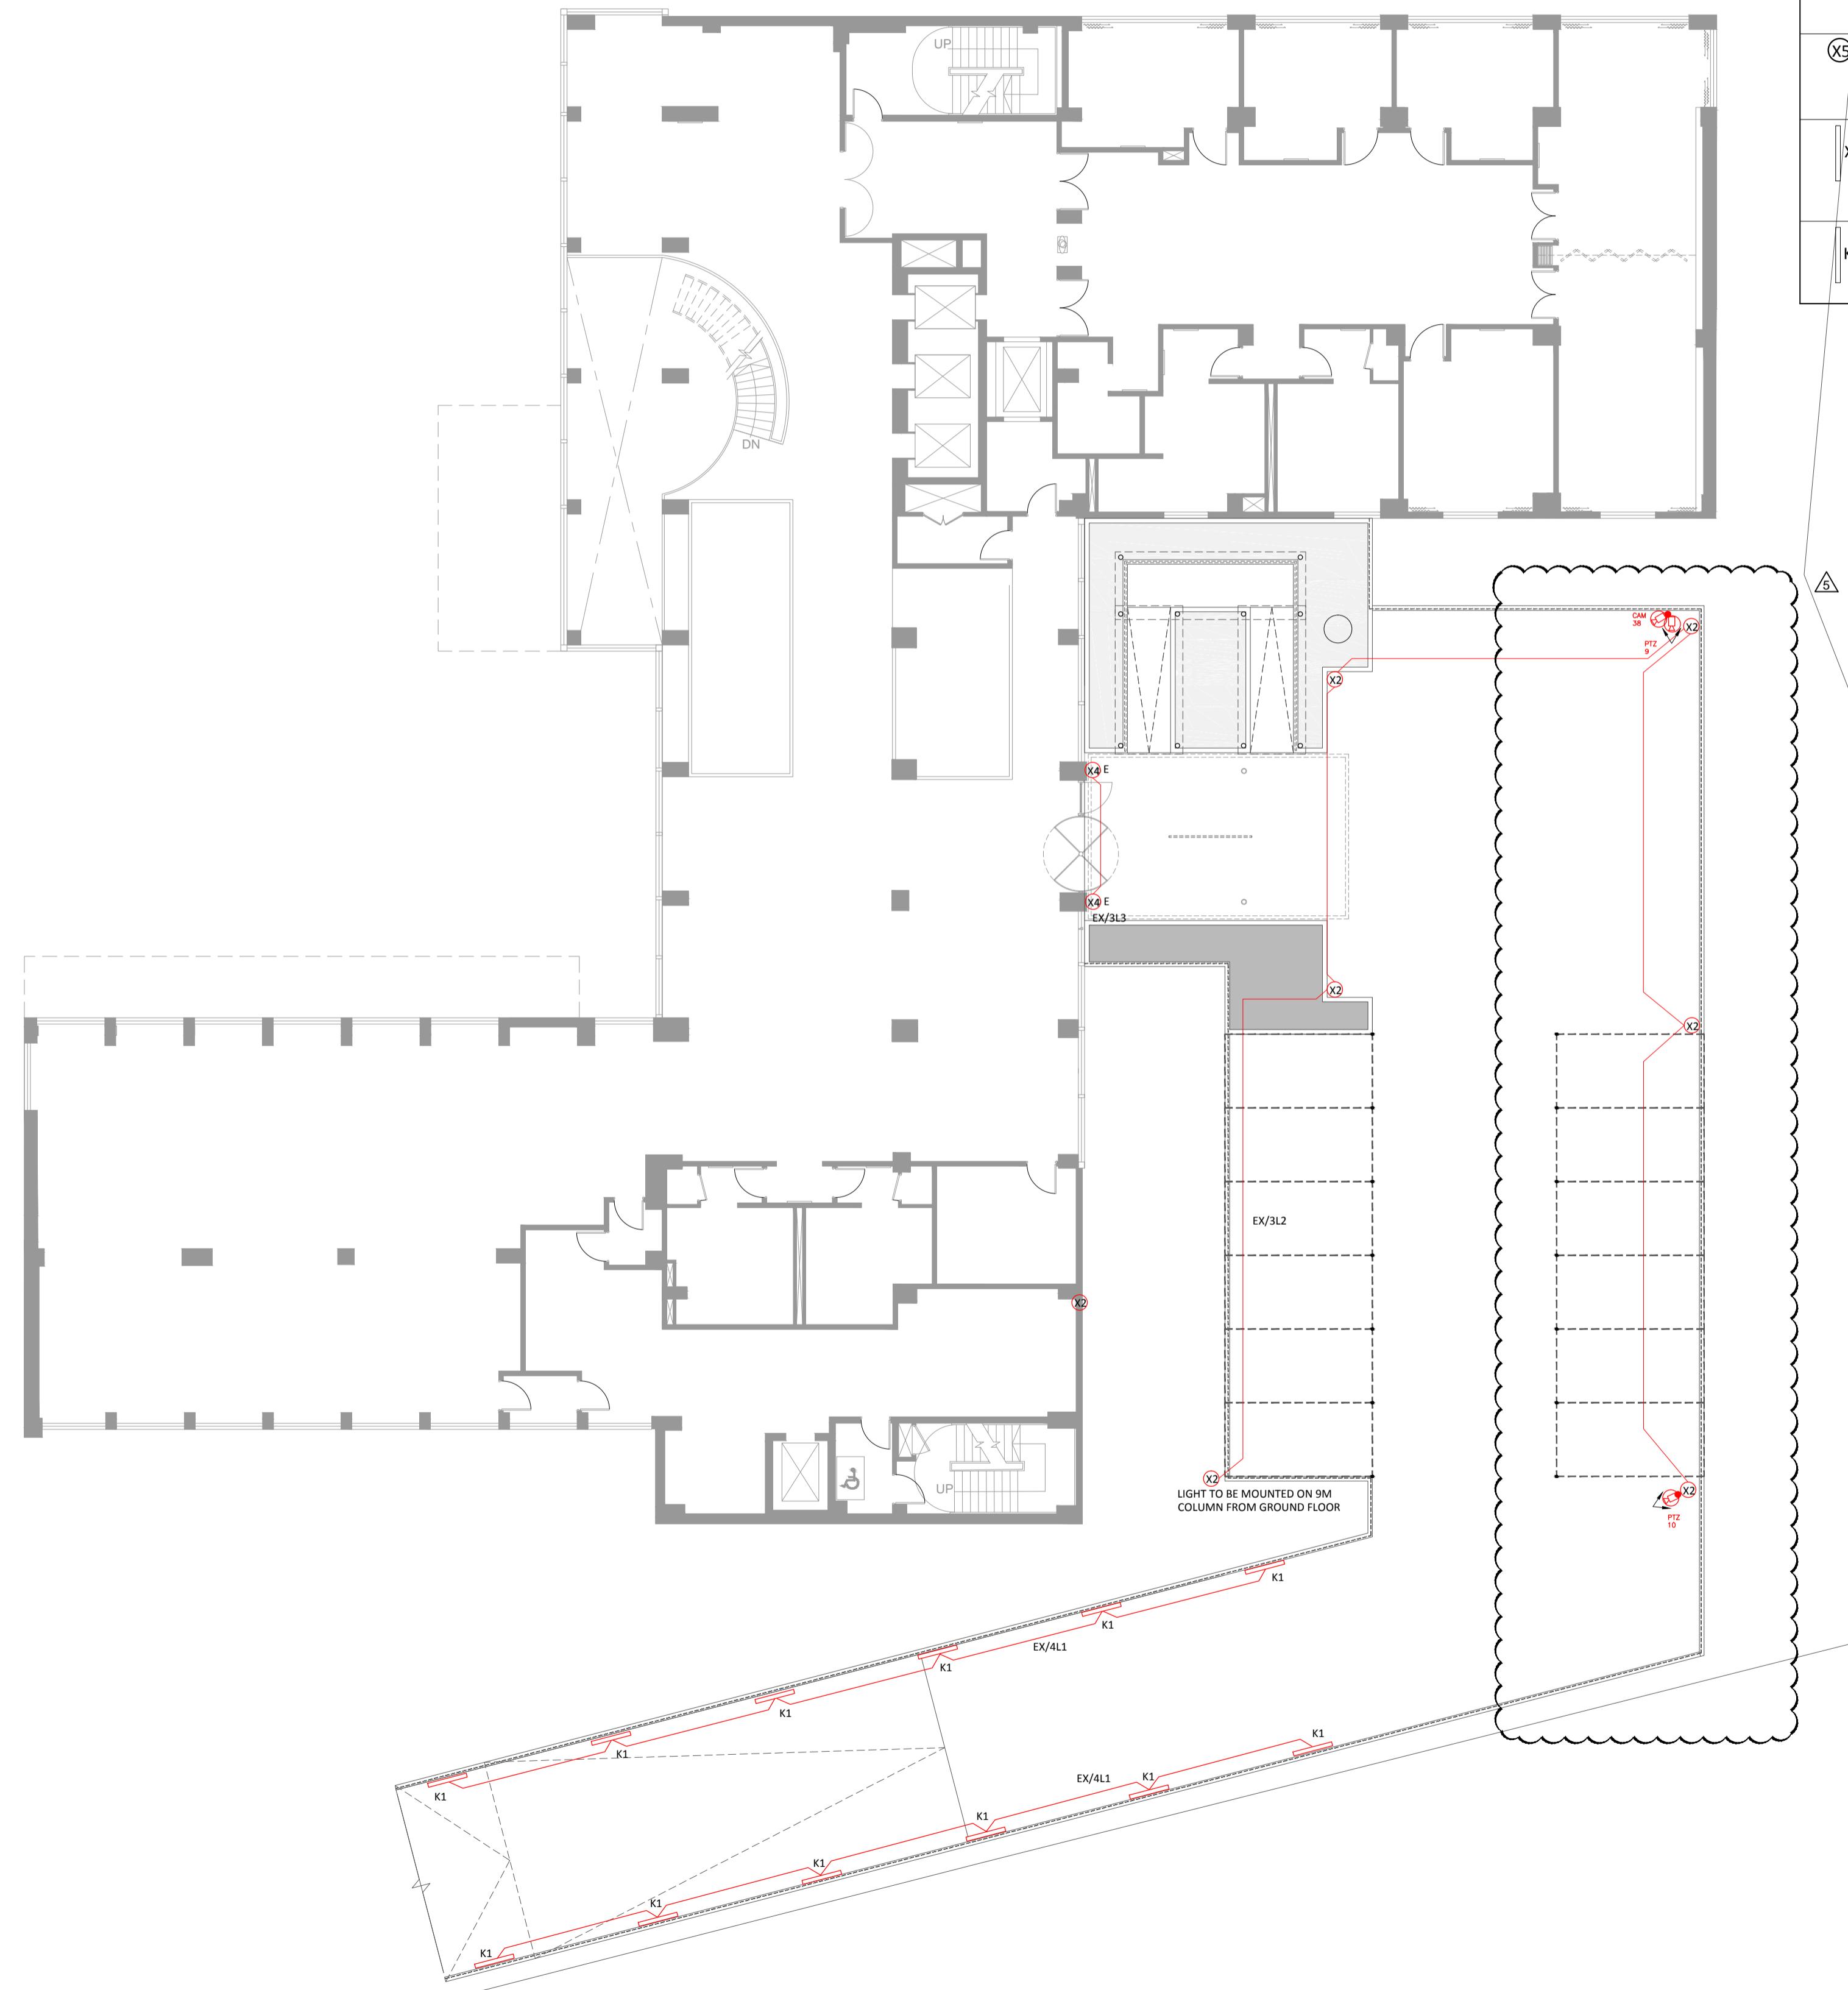

A LIGHTING PLAN
SCALE 1:200

LIGHTING SCHEDULE		
REFERENCE	DESCRIPTION	PICTURE
X1	ARCHITECTURAL POLE MOUNT FITTING WITH ZERO UPWARD LIGHT. 70W CDM. 4000K. SILVER. IP65. AS CONCORD SKYLINE WITH ACCESSORY ON 6M COLUMN.	
X2	POLE MOUNT STREET LIGHT WITH ASYMMETRIC DISTRIBUTION. IP67. ZERO UPWARD LIGHT. 70W CDM. 4000K. ON 6M COLUMN. AS CONCORD MERCURY	
X3	ARCHITECTURAL SLIMLINE LED FLOODLIGHT. SILVER. 25W. 4500K. IP65. IK08. AS SYLVANIA FLOODED.	
X4	ARCHITECTURAL SURFACE MOUNTED LED UP/DOWNLIGHT. SILVER. 26W. 4000K. IP65. E = 3HR EMERGENCY. MOUNTED AT 3m AFFL TO CENTRE AS LUMINANCE INVERTO.	
X5	ARCHITECTURAL SURFACE MOUNTED LED DOWNLIGHT. SILVER. 26W. 4000K. IP65. E = 3HR EMERGENCY. AS LUMINANCE INVERTO.	
X6	LED CORROSION PROOF FITTING WITH STAINLESS STEEL. VR TOGGLES. 48W. 4000K. IP65. IK07. E = 3HR EMERGENCY. AS SYLVANIA SYLPROOF LED.	
K1	LED CORROSION PROOF FITTING WITH STAINLESS STEEL CIRCULAR TUBULAR. VR TOGGLES. 28W. 4000K. IP65. MOUNTED 1m AFFL. AS SYLVANIA SYLPROOF TUBULAR	

CCTV SYMBOL SCHEDULE		
REFERENCE	DESCRIPTION	
	SURFACE MOUNTED. ANALOGUE DAY & NIGHT COLOUR HIGH DEFINITION DOME CCTV CAMERA. CAMERA COMES WITH 1/3" SENSOR AND 2.8mm LENS. CAMERA COMES WITH IP66 RATING	
PTZ	SURFACE MOUNTED. PAN, TILT AND ZOOM ANALOGUE DAY & NIGHT COLOUR HIGH DEFINITION DOME CCTV CAMERA. CAMERA COMES WITH 1/3" SENSOR, 2.8mm LENS, 16x DIGITAL ZOOM. CAMERA COMES WITH IP66 RATING	
	CCTV CAMERA MOUNTED ON 4.5M FIXED COLUMN. AS ACC1 FIXED BASE	
	2x6 CCTV CAMERA MOUNTED ON TWIN BRACKET ON 4.5M FIXED COLUMN. AS ACC1 EMBEDDED BASE FOR GROUND FLOOR AREAS AND FIXED BASE ON FIRST FLOOR CAR PARK	

Rev.	Description	Date
05	GENERAL REVISION	23/10/2015
04	LIGHTING REVISION	02/07/2015
03	CONSTRUCTION DOCUMENTS	21/11/2014
02	VE SUBMISSION	29/05/2014
01	TENDER SUBMISSION	10/12/2013
00	1ST SUBMISSION	28/11/2013



Client

MAGILL INVESTMENTS LIMITED

Project

HEATHROW GATE HOTEL
27 UXBRIDGE ROAD
HAYES, MIDDLESEX
UB4 0JN



St. Legere Design International Ltd.
7/F, Pacific Plaza,
410 Des Voeux Road West,
Shek Tong Tsui, HK

Project Phase

CONSTRUCTION DOCUMENTS

Drawing Title

LIGHTING PLAN
1/F

Designed by: VV BW TY |
 Drawn by: BW TY |
 Checked by: VV DS |
 Project no. Scale
 1305 1:200 (A1)
 DWG no. Rev.
 LP-5.02 5