


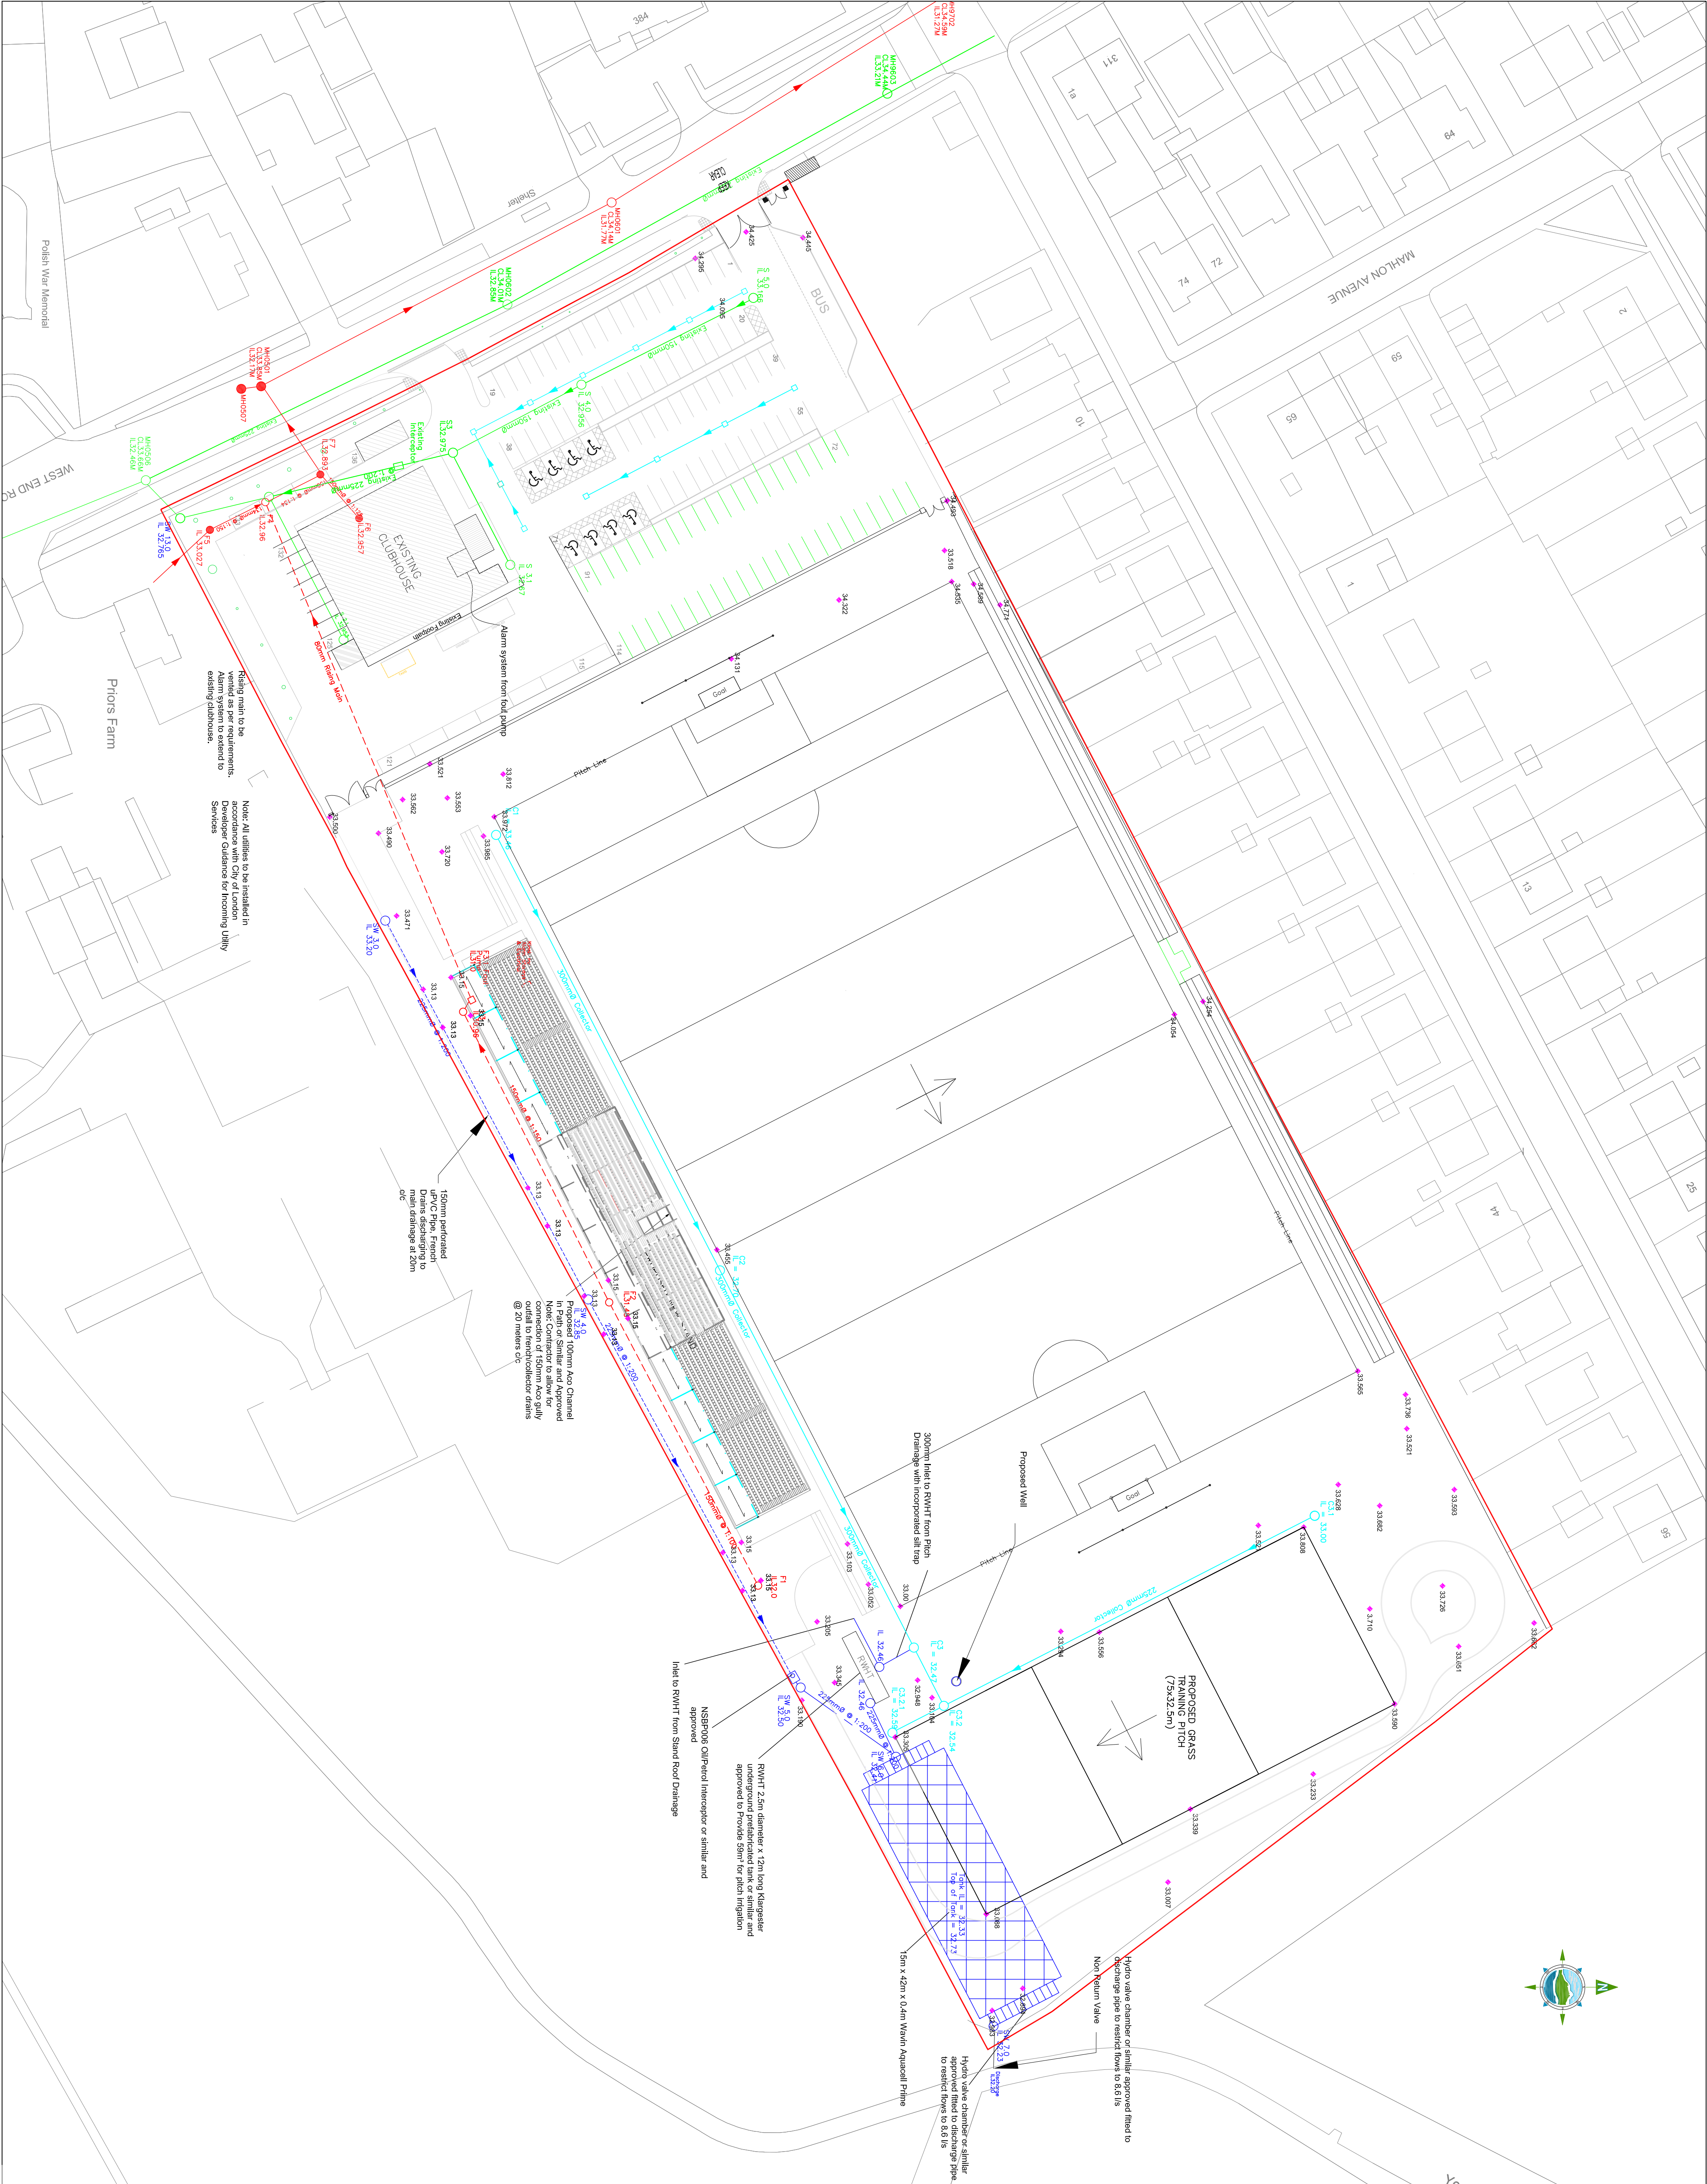

WHERE COVER TO THE PIPE WORK UNDER A PATH OR ROAD OR SERVICE ROAD IS LESS THAN 150mm, PIPES SHOULD BE BEDDED AND SURROUNDED IN CONCRETE, 150mm THICK, CLASS E IN ACCORDANCE WITH CLAUSE 1502 OF THE SPECIFICATION FOR ROADWORKS

ALL MANHOLES AND PIPELINES TO BE CONSTRUCTED IN ACCORDANCE WITH THE SPECIFICATION AND ALL RELEVANT GUIDELINES. PIPES FROM GULLIES TO BE 150MM Ø uPVC LAID TO 1/150 FALLS

LEGEND

- SITE BOUNDARY
- MAIN CONTRACT
- SITE BOUNDARY
- PITCH CONTRACT
- EXISTING CD CHANNEL
- EXISTING STORM SEWER
- PROPOSED FOUL SEWER
- EXISTING FOUL SEWER
- PROPOSED 150mm Ø MANHOLES
- EXISTING MANHOLES
- COLLECTOR DRAIN
- SILT DRAINS
- GRAVEL MOLE DRAINS
- FRENCH DRAINS
- PROPOSED ROAD GULLY

NOTES:

- FIGURED DIMENSIONS ONLY TO BE TAKEN FROM THIS DRAWING.
- ALL DRAWINGS TO BE CHECKED BY THE CONTRACTOR ON SITE REPRESENTATIVE AS APPROPRIATE TO BE INFORMED BY THE CONTRACTOR OF ANY DISCREPANCIES BEFORE ANY WORK COMMENCES.
- THE CONTRACTOR SHALL UNDERTAKE A THOROUGH CHECK FOR THE ACTUAL LOCATION OF ALL SERVICES/UTILITIES ABOVE AND BELOW GROUND, BEFORE ANY WORK COMMENCES.
- ALL LEVELS SHOWN RELATE TO ORDNANCE DATUM NEWLYN (ODN)

Rev	Date	Description	By	Chkd.
A	16/02/2016	Issued for Planning Review	KL	AD
B	03/06/2014	Issued for Planning Purpose	NOG	AD

Client: **Coiste Chontae Londain**
(London GAA County Board)

Project: **Redevelopment of Emerald GAA Grounds at West End Road, Ruaislip**

Title: **Proposed Storm & Foul Drainage Layout**

Scale @ A1:500	A3: 1:1000
Prepared by: NOG	Checked: AD
Date: 03/06/2014	
Project Director: C. McGovern	
Drawing Status: Planning	



TOBIN Consulting Engineers (UK) Ltd.
Floor 4, Ergon House,
25-27, Westmoreland Street,
SW1P 2AL, London
tel: +0044 203 713 4371
e-mail: info@tobin-uk.com
www.tobin.ie

Drawing No: **7321-2001** Revision: **B**