


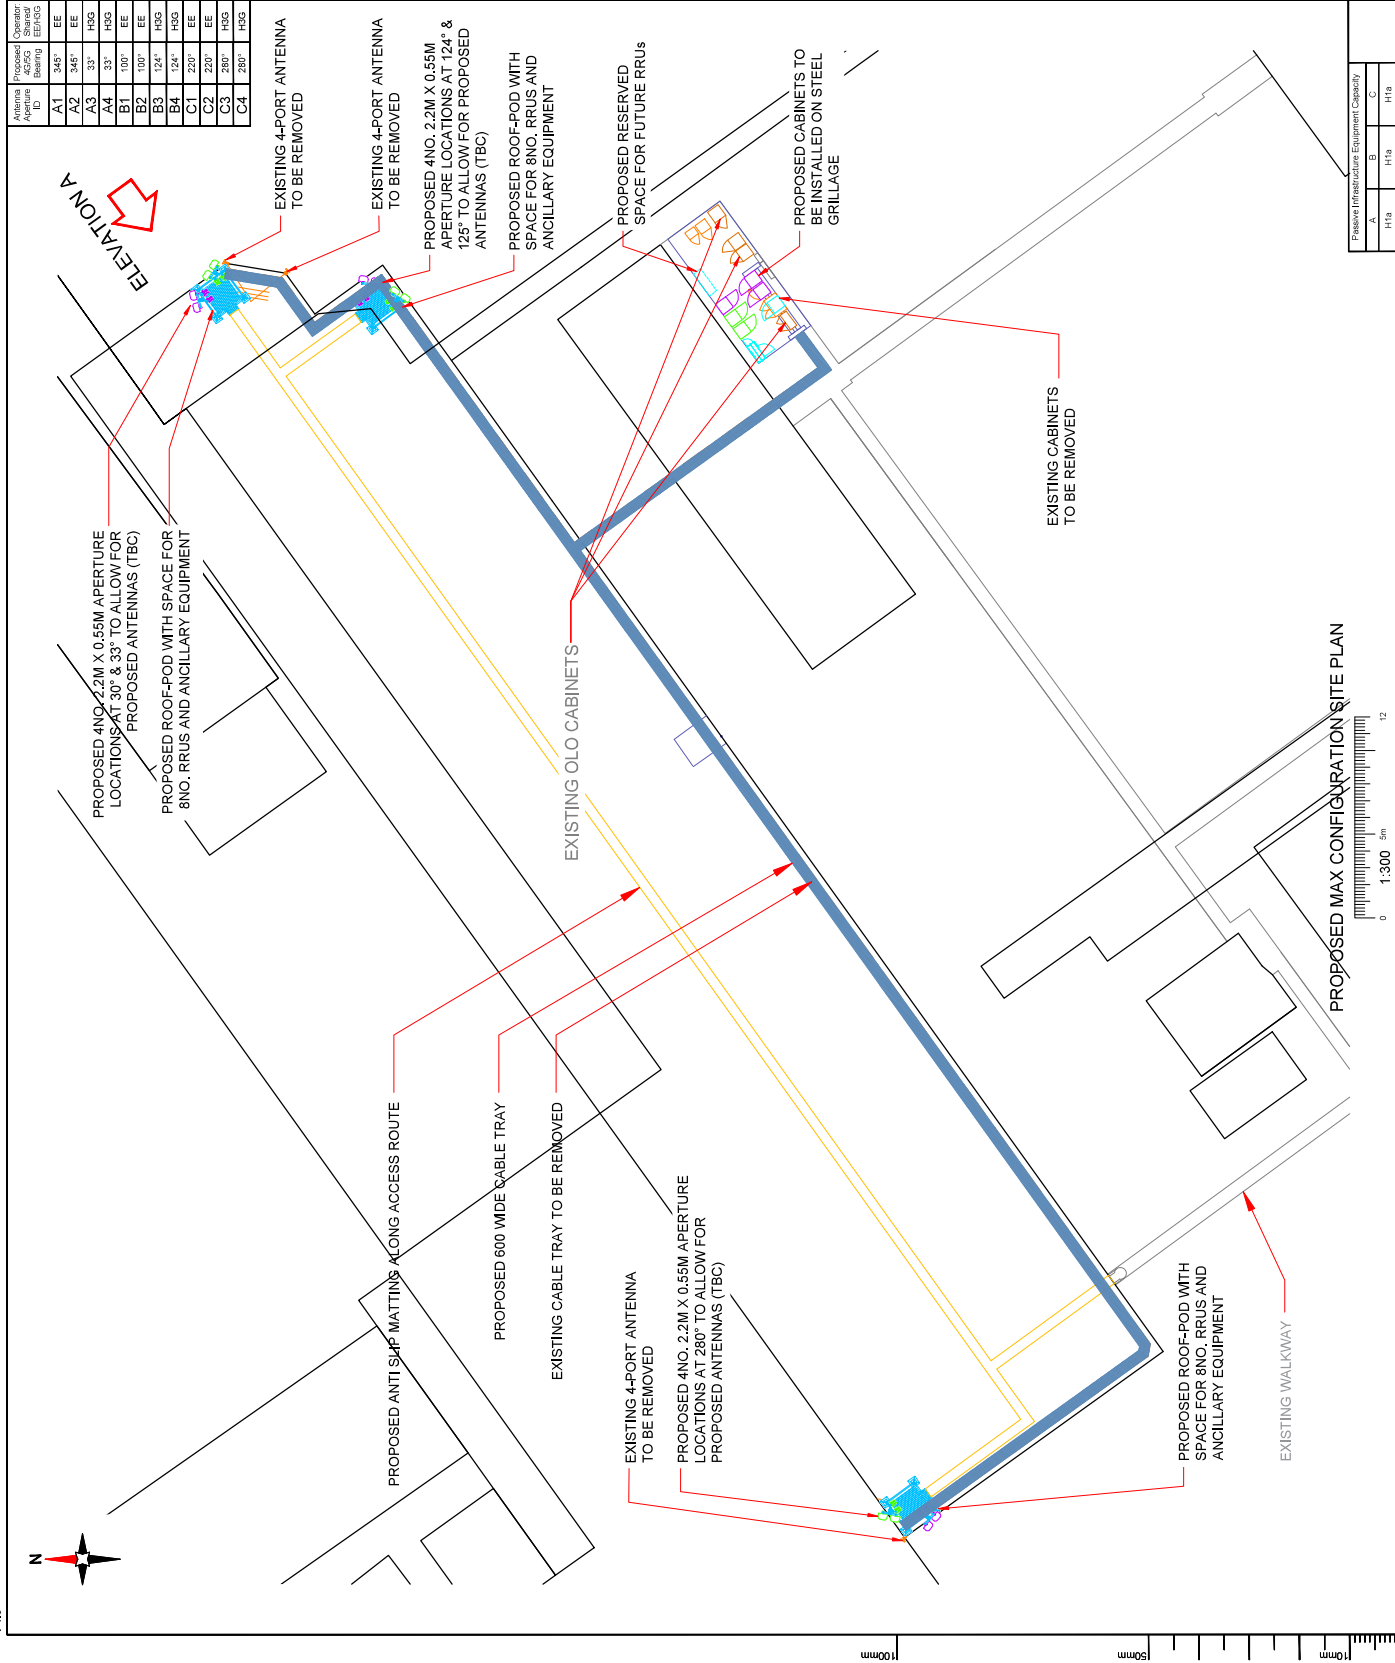

Antenna Aperture ID	Proposed AG/SG Bearing	Operator Shared/EE/AGG
A1	345°	EE
A2	345°	EE
A3	33°	HSG
A4	33°	HSG
B1	100°	EE
B2	100°	EE
B3	124°	HSG
B4	124°	HSG
C1	220°	EE
C2	220°	EE
C3	280°	HSG
C4	280°	HSG

NOTES:

1. ALL DIMENSIONS IN MM UNLESS OTHERWISE NOTED.

Master:	MBNL / EE / H03	Project:	T & A	Purpose of Issue:	Planning	Issue:	B
M002	MBNL						
Date:	31/03/2020	Revision / Upgrade Description:					
Drawn:	L. McMoran	Minor amendments					

Master:	MBNL	Project:	T&A	Purpose of Issue:	Planning	Issue:	A
Date:	17/03/2020	Revision / Upgrade Description: First Issue					
Drawn:	L. McMoran						
Drawn by:	T. Curran						

[illegible]

MBNL
Mobile Broadband Network Limited
Sixth Floor, Thames Tower, Station Road, Reading, RG1 1LX



Site Name: TW0070 TERM 3 HEATHROW
208245

Site ID: 1109174

Address: TERMINAL 3 HEATHROW
CANBERRA ROAD HEATHROW
AIRPORT HOUNSLOW LONDON;
HILLINGDON

TW6 1QG

215 MAX CONFIGURATION SITE PLAN

Project: T&A

Purpose of Issue:	GENERAL ARRANGEMENT
-------------------	---------------------

EE Cell ID:	27254	MBNL Cell ID:	HGN081	3UK Cell ID:	TW0070
-------------	-------	---------------	--------	--------------	--------

Master Drawing No:	1109174_HGN081_27254_TW0070_M002	Issue:	B
--------------------	----------------------------------	--------	---

Passive Infrastructure Equipment Capacity		
A	B	C
H1a	H1a	H1a