


Proposed Car Parking and Electrical Charging Points

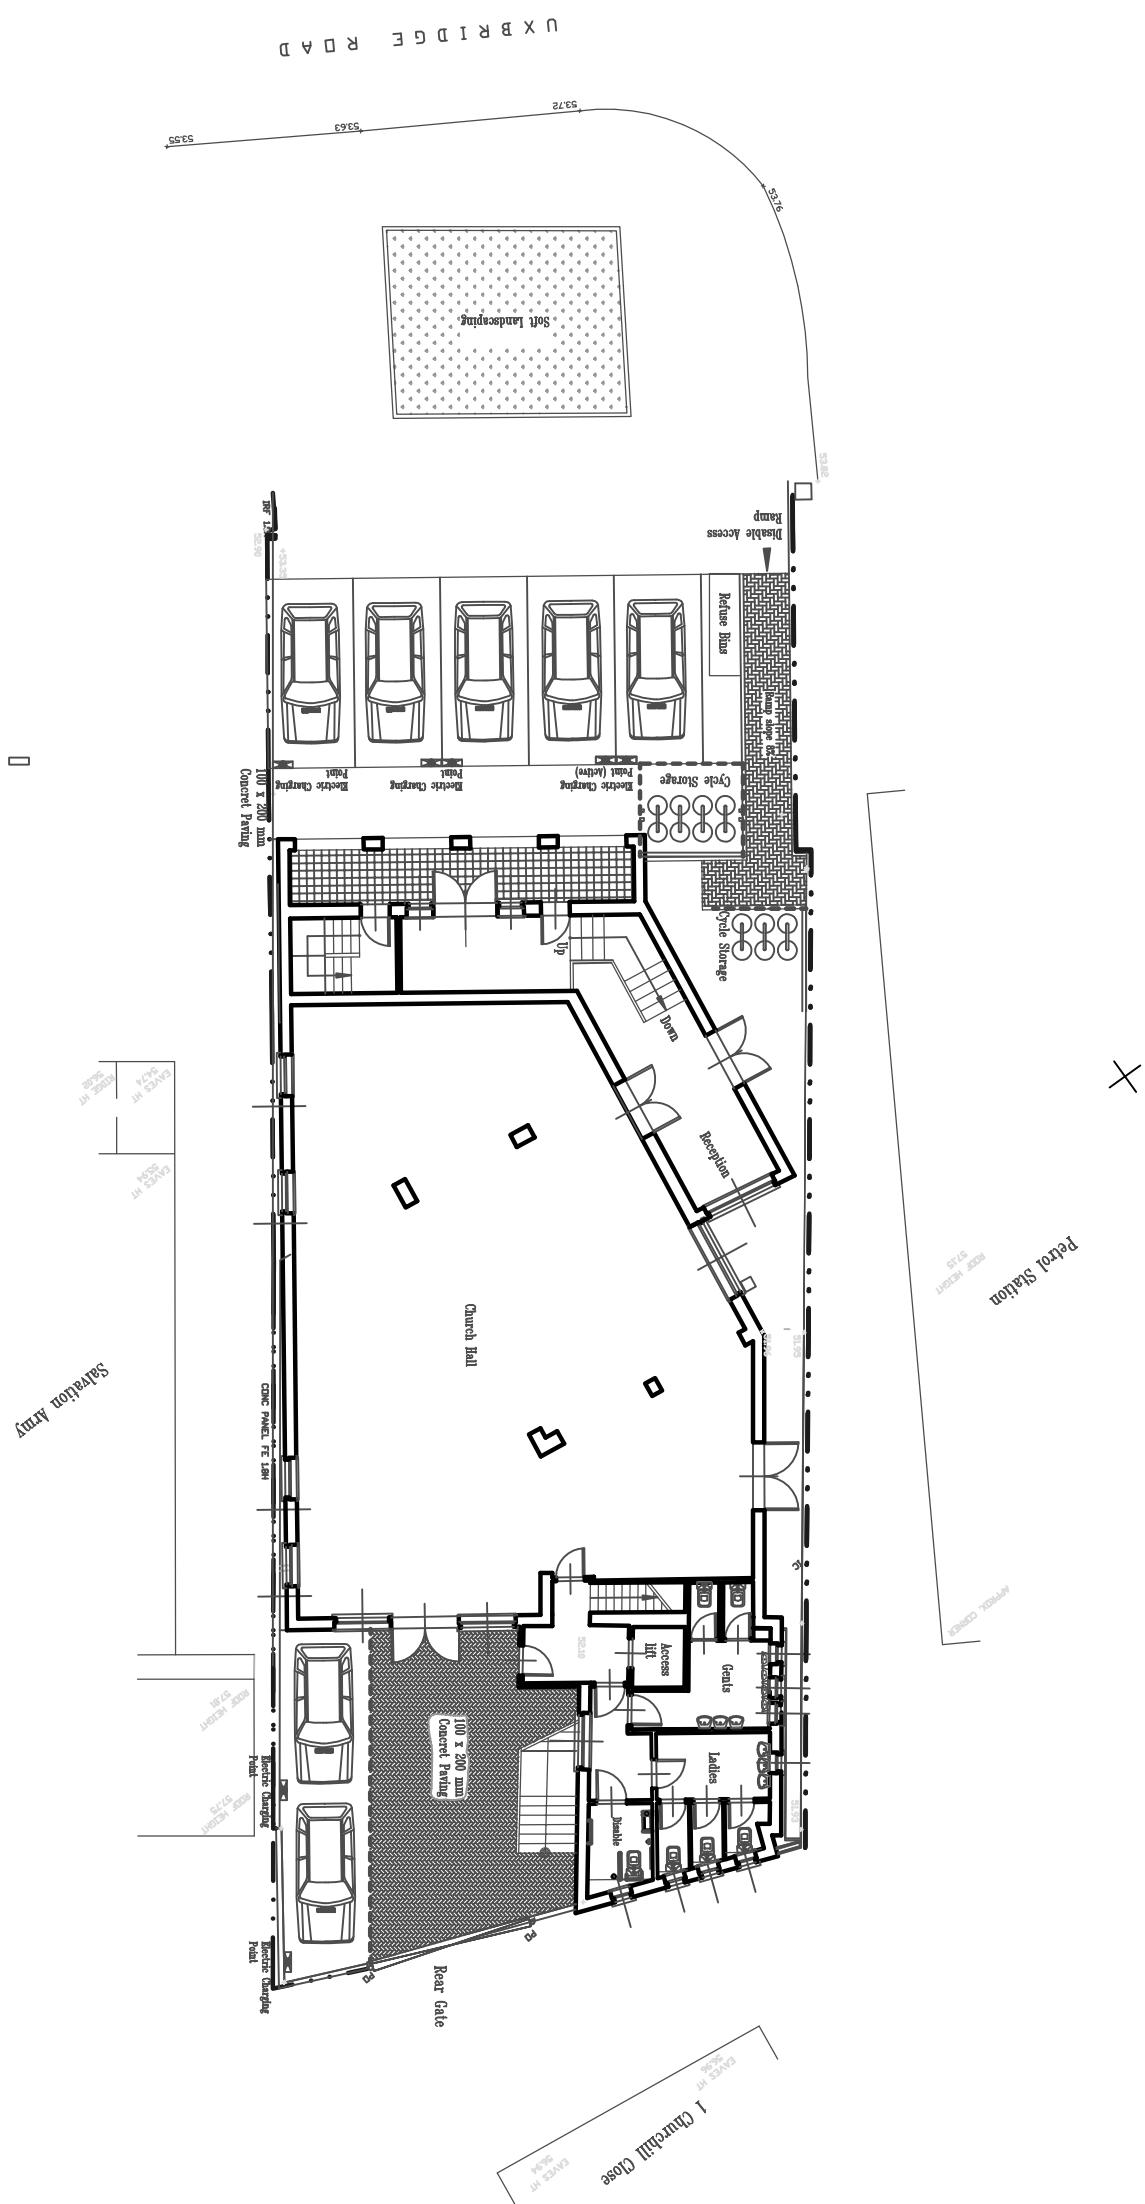

Leads Design Partnership
 Chartered Architects, Engineers and Surveyors
 Planning Supervisors and Construction Project Managers
 86 Chestnut Road Enfield EN3 6SY Tel: 01992 787 937

Client:
 Focus International Christian
 Centre
Site:
 123 Uxbridge Road,
 Hillingdon UB10 0LQ
Drawing:
 Proposed Site Plan

Date	Pr./Drawing Number	Scale
May 2022	LDP/PC/250/P/03/A	1:200 @ A3

The copyright of this drawing is vested in the architect and
 must not be copied or reproduced without his written consent.
 Figures, dimensions only are to be taken from this drawing. All
 Contractors must visit the site and be responsible for taking and
 checking all dimensions relative to this work. Do not scale off
 this drawing. IF IN DOUBT ASK.