
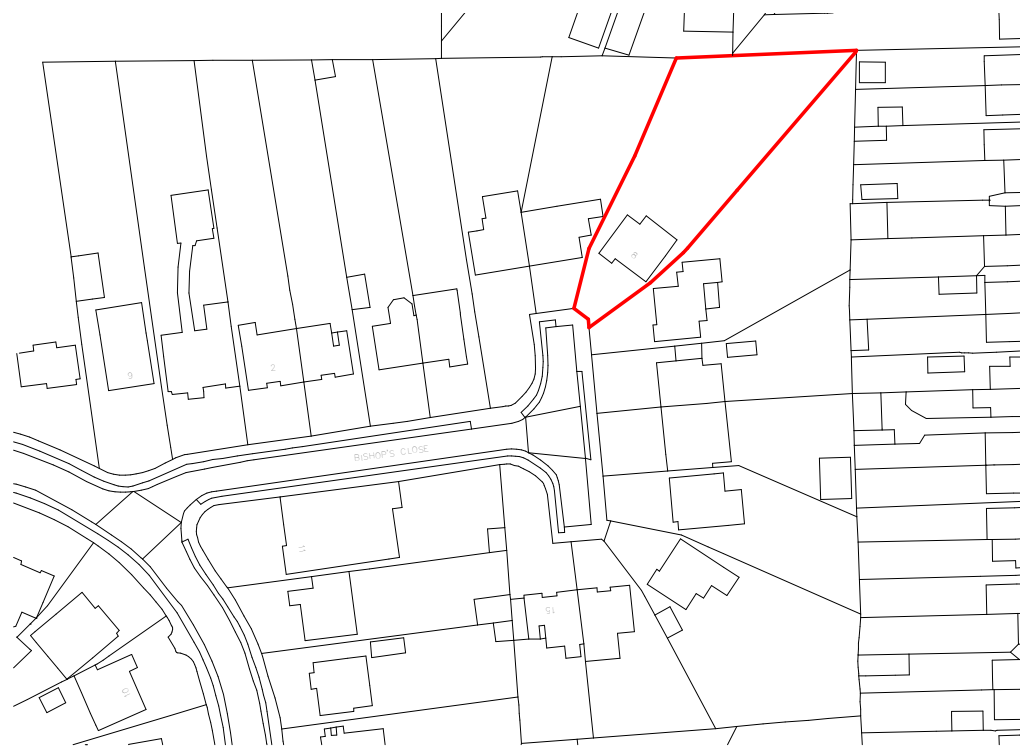


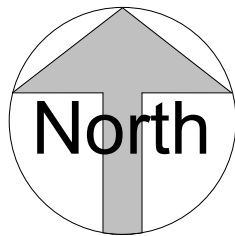


Location Plan

1 : 1250

Site Plan

1 : 200

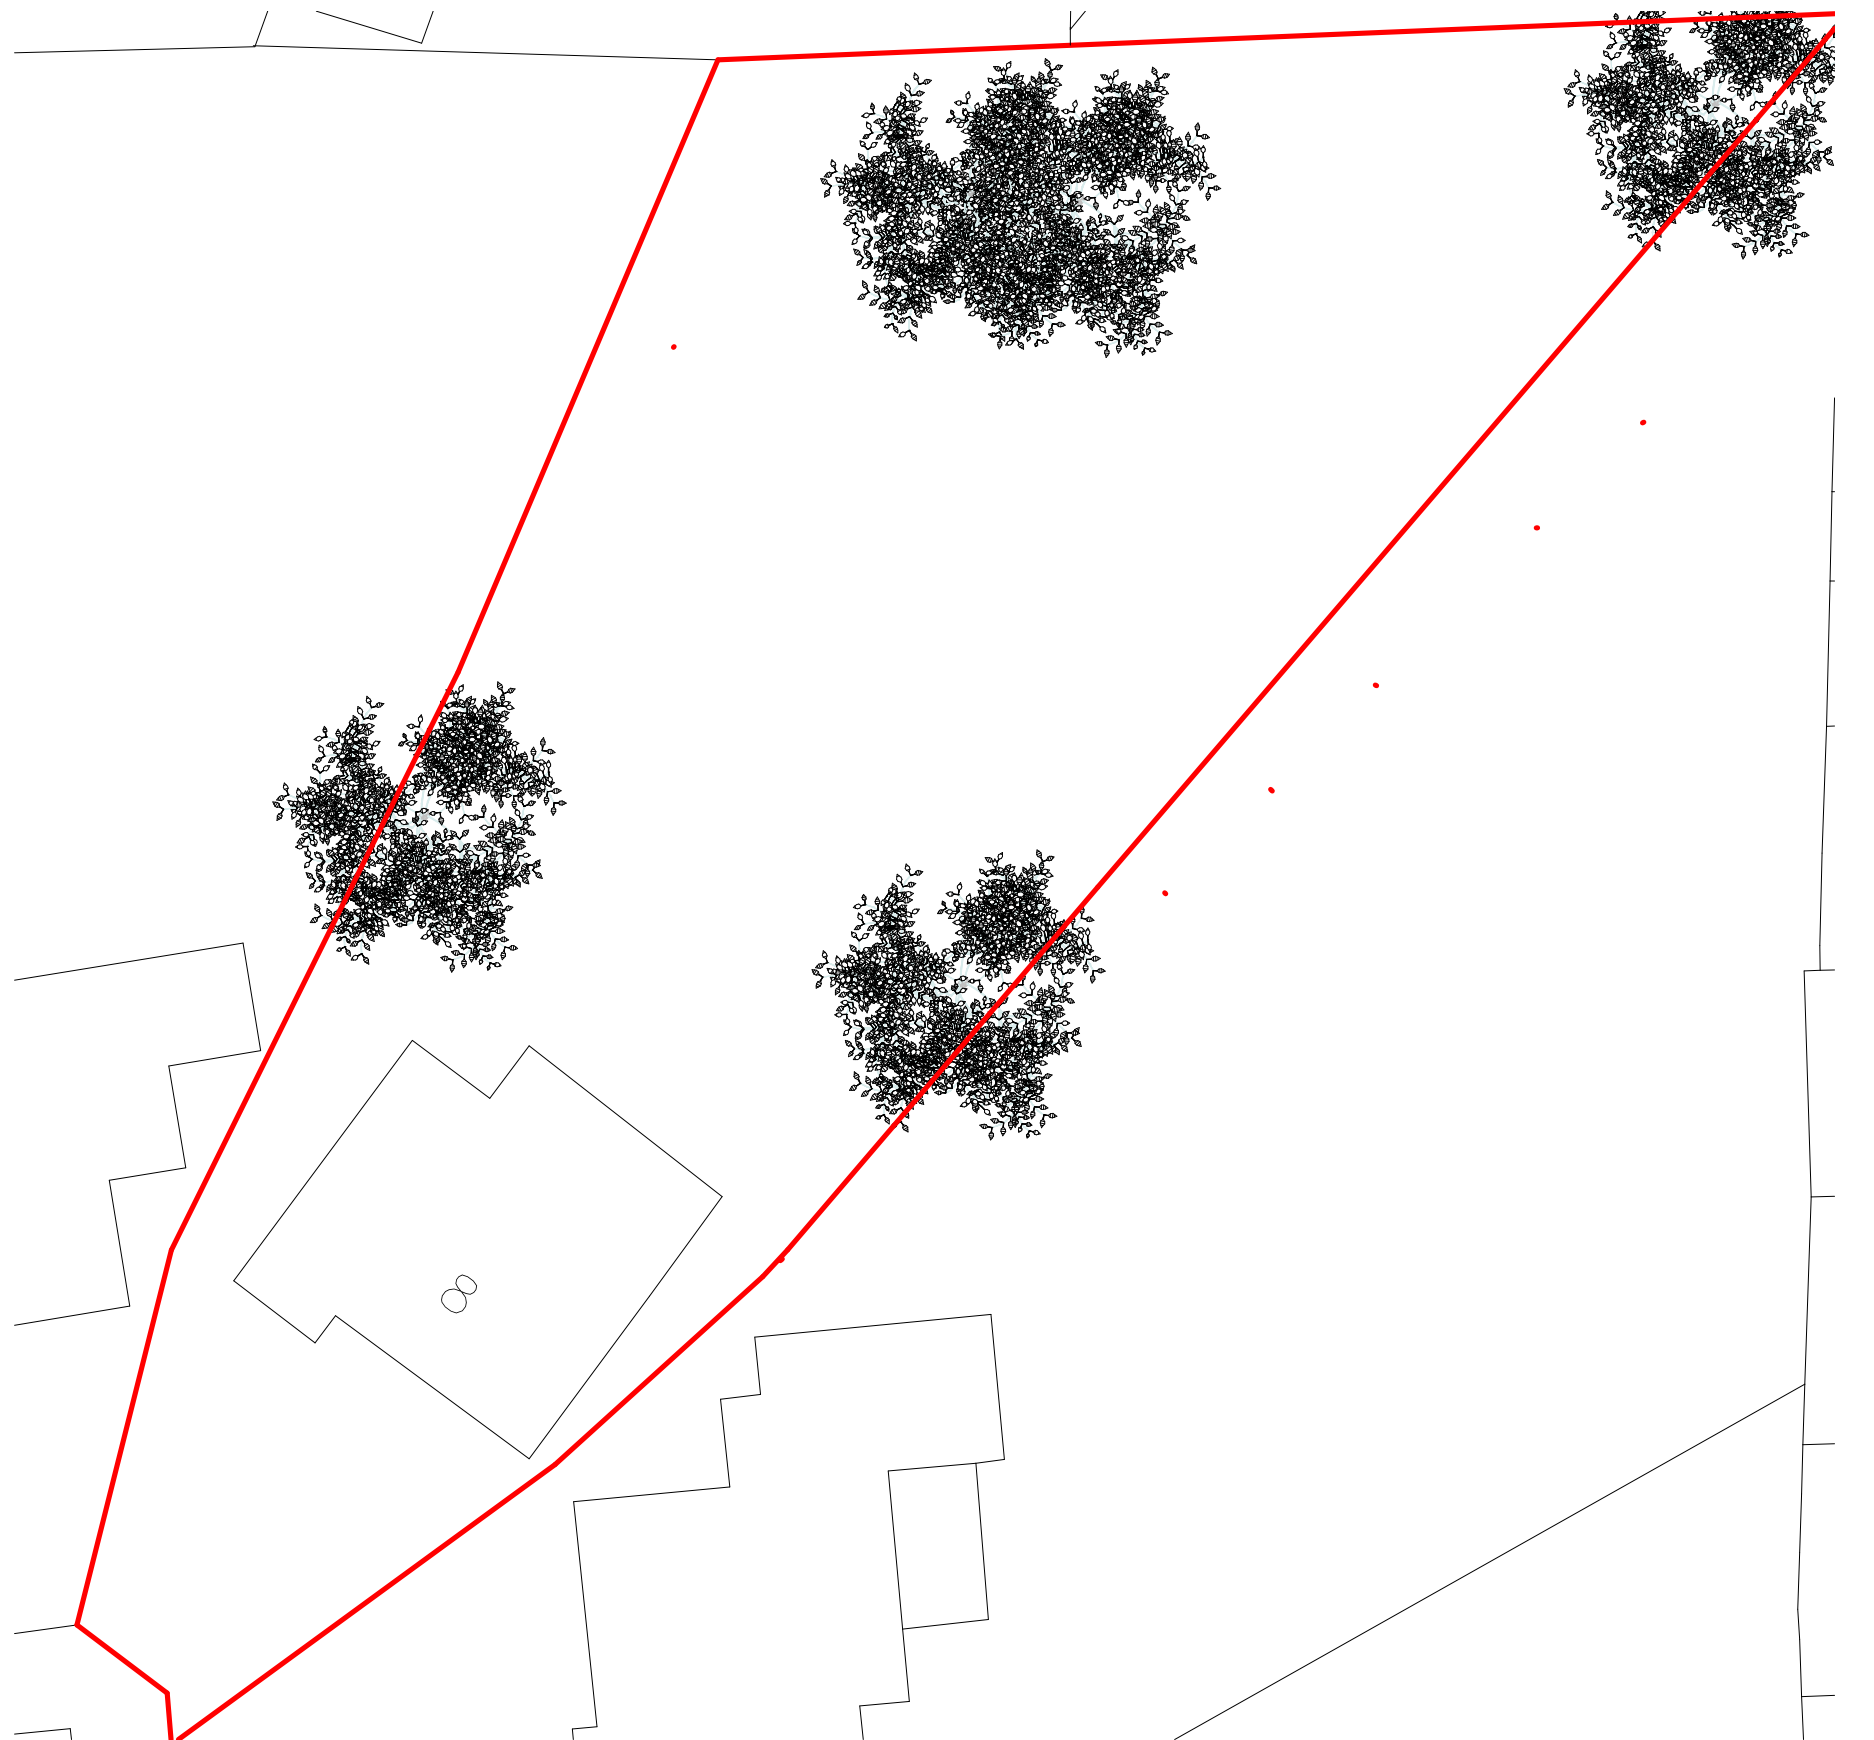

FLUENT
ARCHITECTURAL DESIGN SERVICES
Tel: 0800 043 8838
E-MAIL: INFO@FLUENT-ADS.CO.UK
WEB: FLUENT-ADS.CO.UK

8 Bishops Close, Uxbridge

Existing Site Plan and Location

Scale @ A3

As indicated

Date

18.03.2019

Drawn by

D. Owolana

Drawing number

FLU.1161.01

Rev

2

No.	Description	Date