




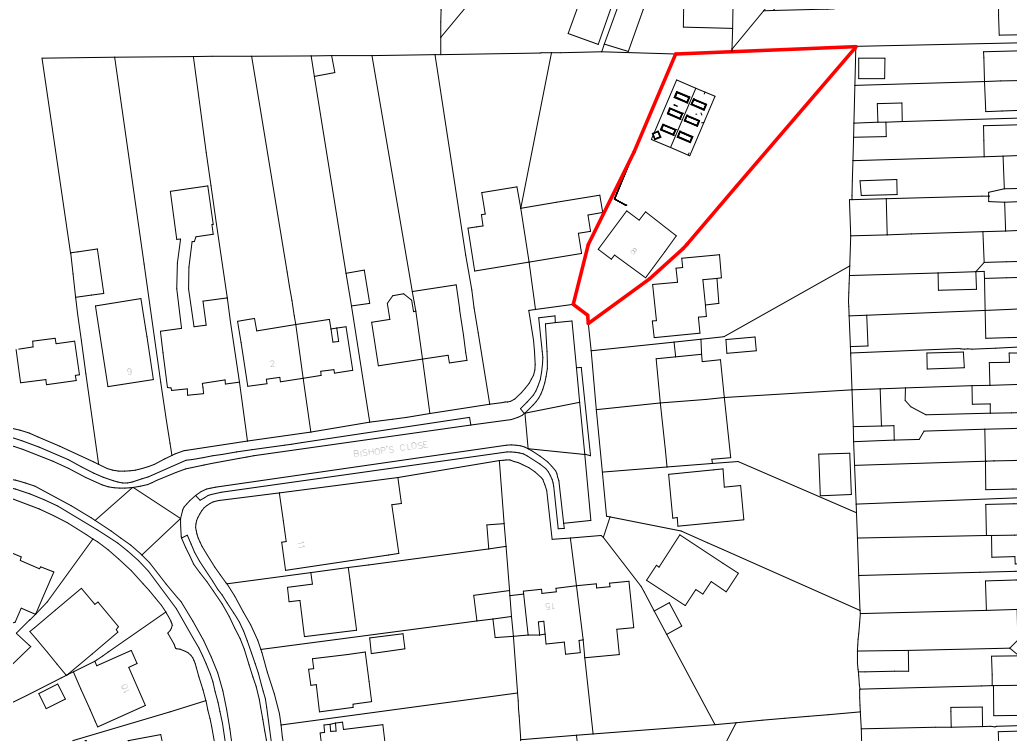

Proposed Location Plan
1 : 1250

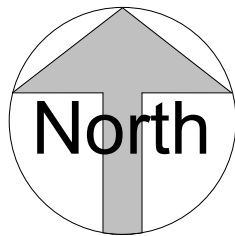

Proposed Site Plan
1 : 200

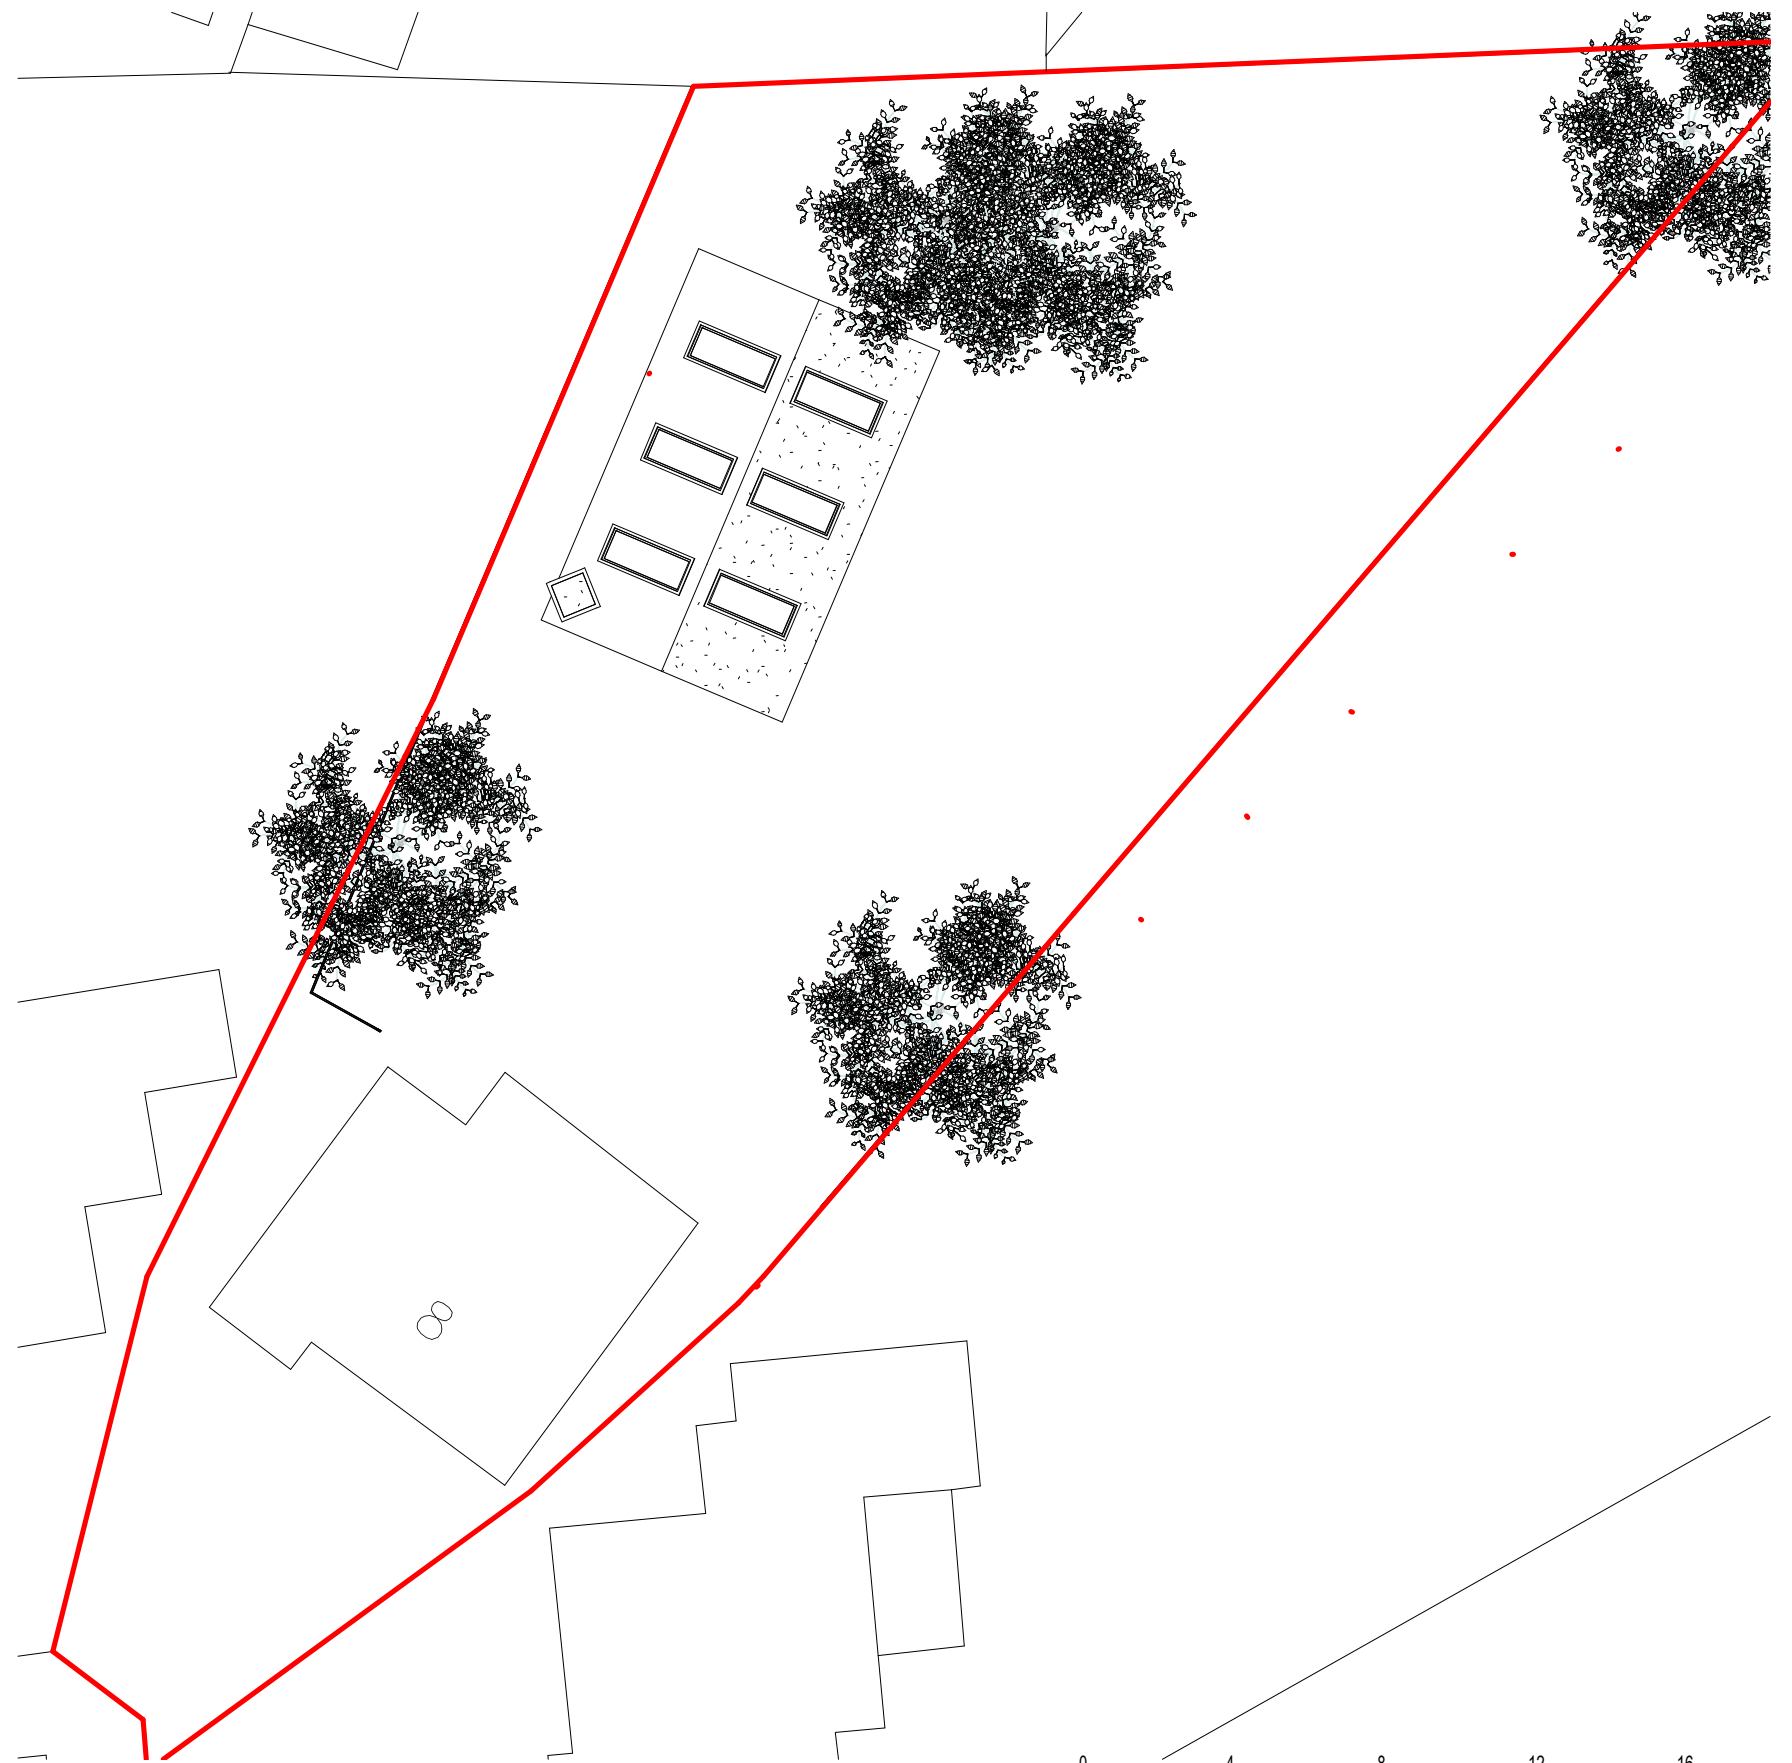

FLUENT
ARCHITECTURAL DESIGN SERVICES
TEL: 0800 043 8838
E-MAIL: INFO@FLUENT-ADS.CO.UK
WEB: FLUENT-ADS.CO.UK

8 Bishops Close, Uxbridge

Proposed Site Plan and Location

Scale @ A3

As indicated

Date

18.03.2019

Drawn by

D.OWOLANA

Drawing number

FLU.1161.02

Rev

2

No.	Description	Date
1	Adding mezzanine floor and window for shower room. Reducing front window size.	20/04/2020
2	Chimney added and alterations to the roof	29/04/2020