


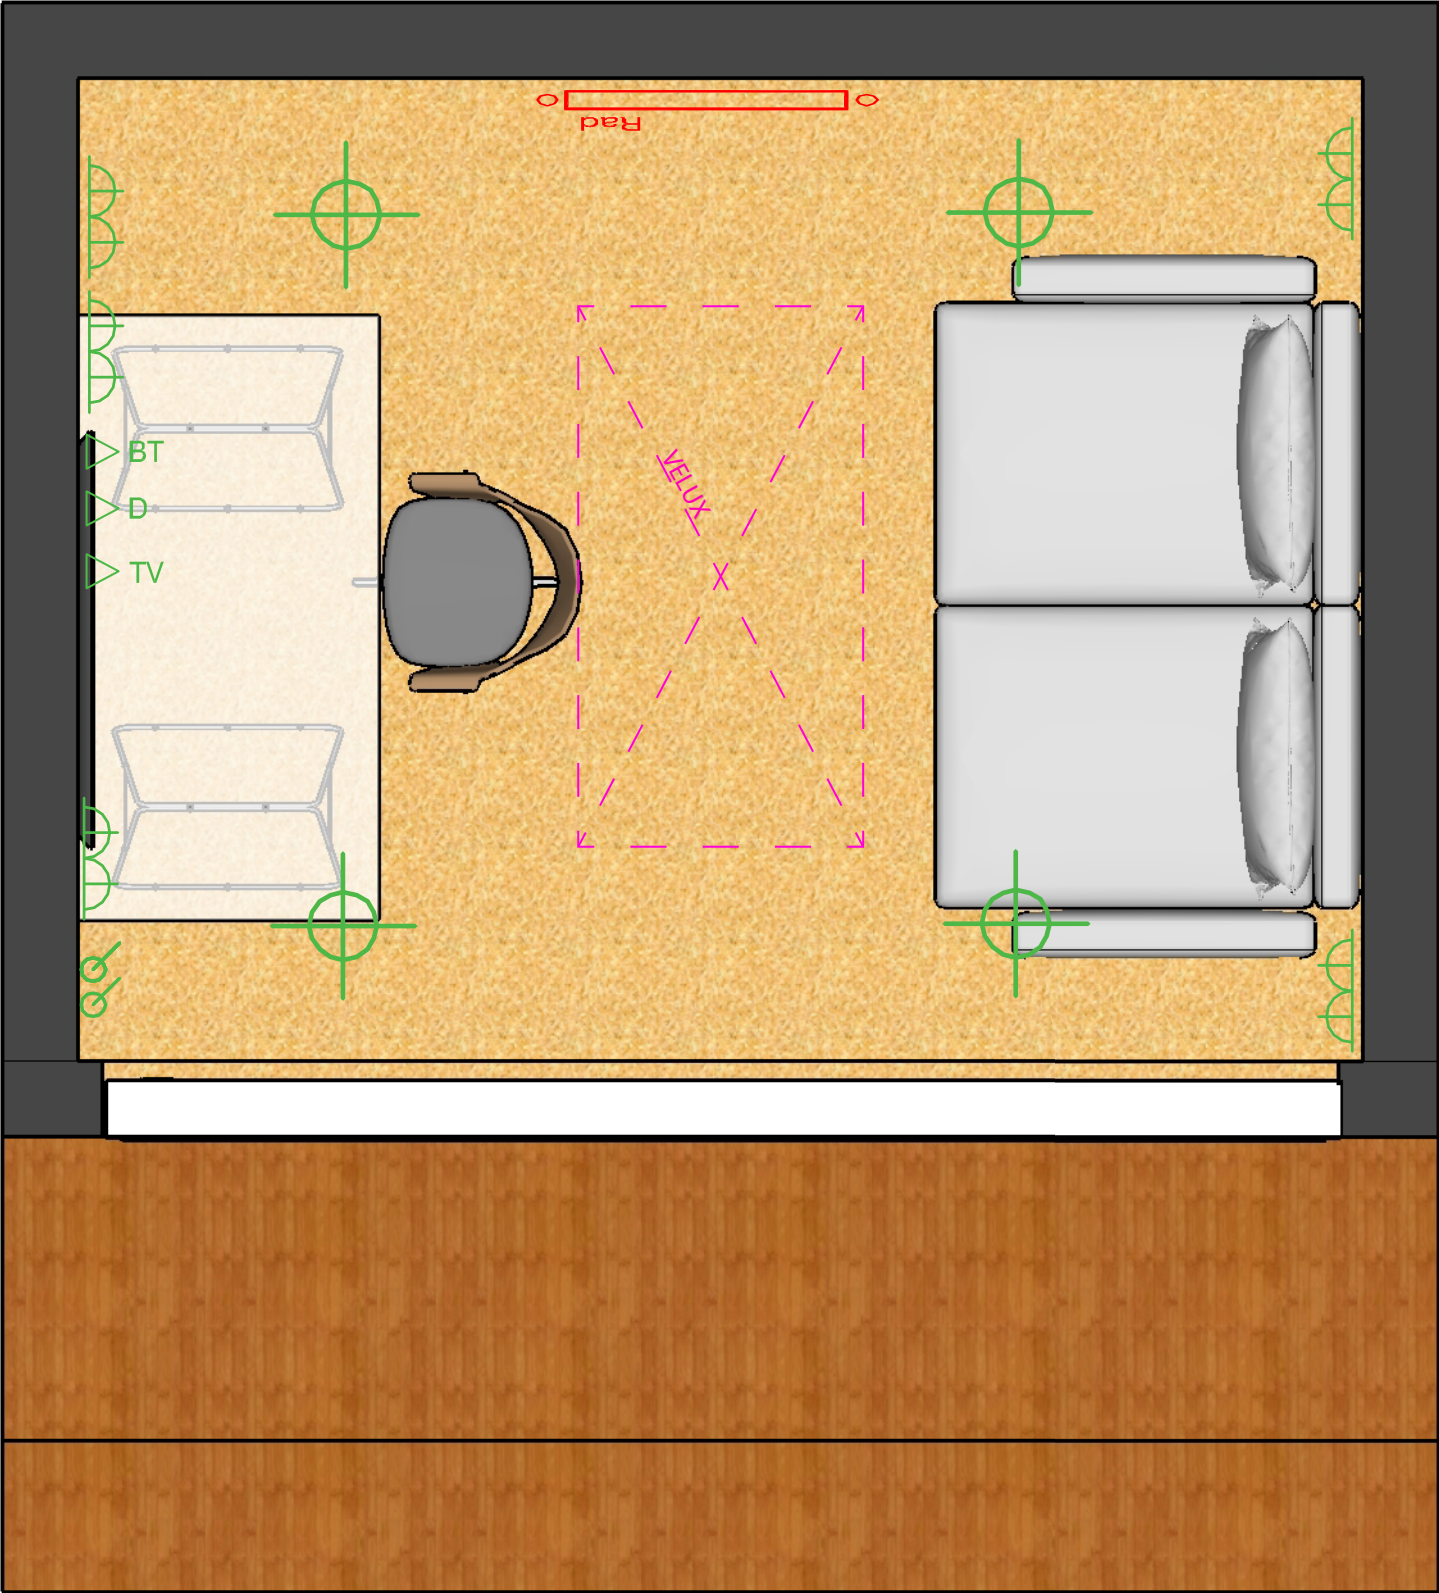

electrical key

- recessed downlighter
- pendant light
- wall-light
- Dimmable light switch
- BT jackpoint
- Data point
- TV outlet @ HL (13amp @ HL)
- shaver socket
- Thermostat
- smoke detector
- carbon monoxide detector
- heat detector
- twin extract fans
- double switched 13Amp socket
- switched spur with indicator
- entryphone handset
- radiator

GARDEN STUDIO FLOOR PLAN

CLIENT
Sylvester O'Shea
135a Charville Lane
Hayes
UB4 8PD

ISSUE
FEB 2020

DRAWN BY
SS