
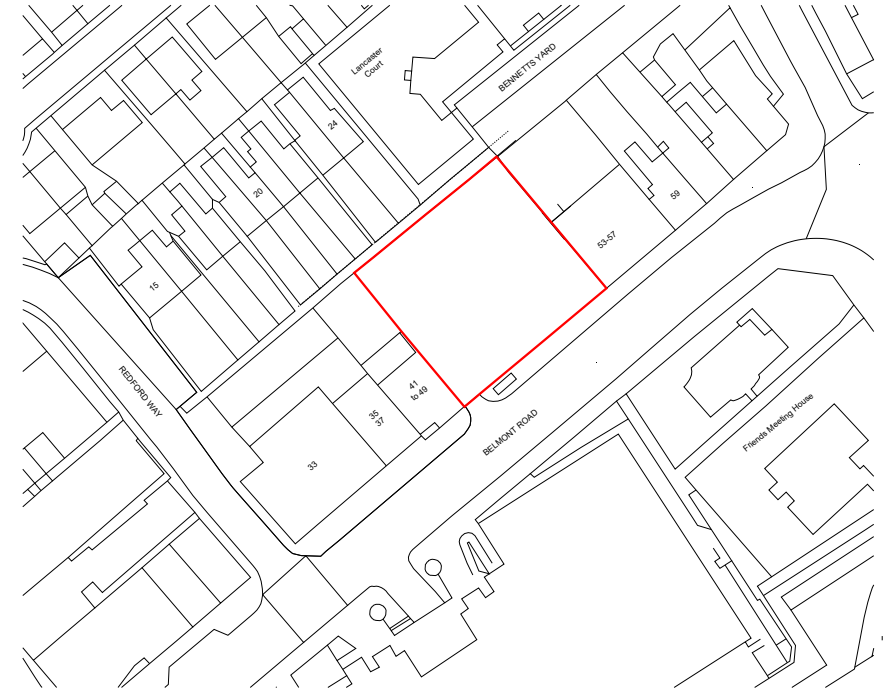


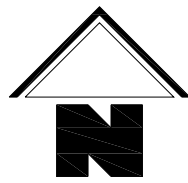


Rev	Date	Description

**Fluent**[®]
ARCHITECTURAL DESIGN SERVICES

FLUENT
ARCHITECTURAL DESIGN SERVICES
69-71 WINDMILL ROAD, SUNBURY,
MIDDLESEX, TW15 7DT
TEL: 0800 0438888
E-MAIL: INFO@FLUENT-ADS.CO.UK
WEB: FLUENT-ADS.CO.UK

51 Belmont Road, Uxbridge

 Existing Site Plan



Scale 1:500 @ A3	Dwg No. FLU.838.3.08
Date 22.11.18	Rev B
Drawn N.Millin	