


COPYRIGHT CONTRACTOR MUST CONFIRM SITE DIMENSIONS BEFORE COMMENCEMENT OF WORK. THIS DRAWING OR DESIGN IS THE COPYRIGHT AND MAY NOT BE REPRODUCED WITHOUT WRITTEN CONSENT OF THE DESIGNER. CONTRACTOR RESPONSIBLE FOR CORRECT SETTING OUT ON SITE. ANY DISCREPANCIES TO BE NOTED TO THE DESIGNER IMMEDIATELY.		
MARKED	REVISION	DATE
A		


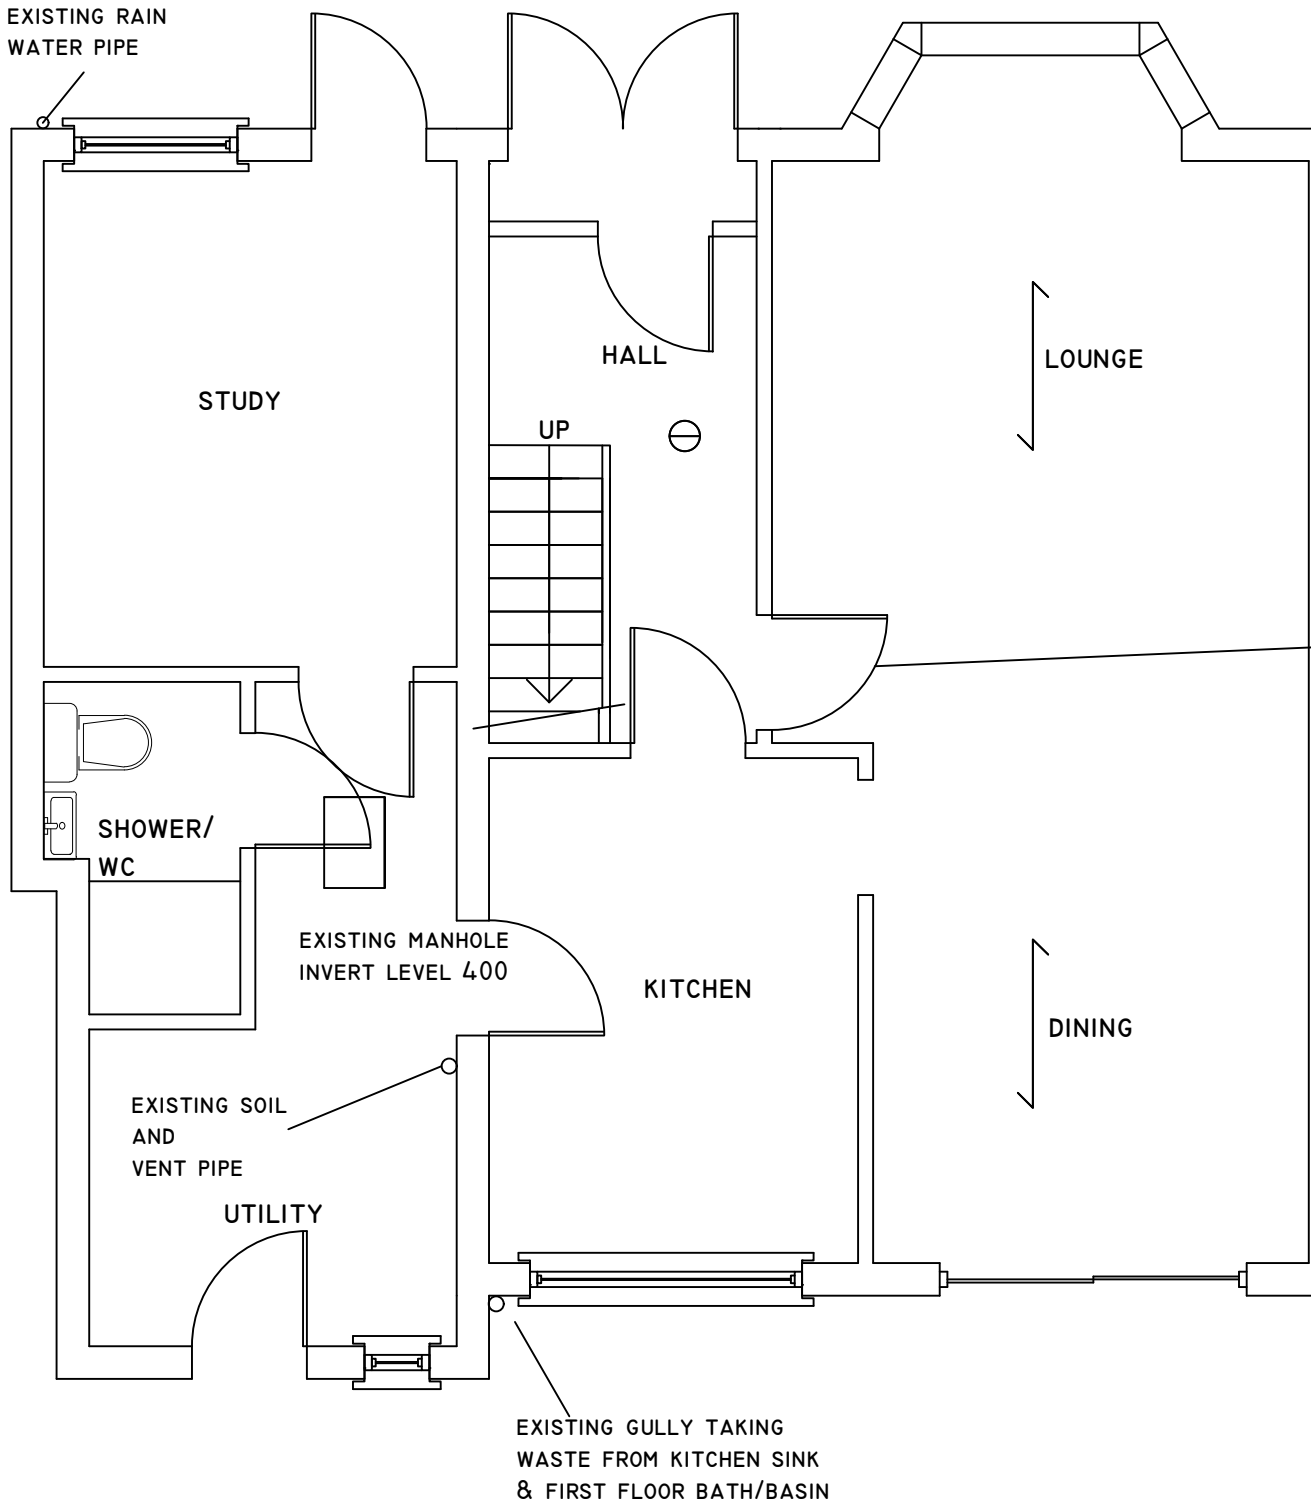


PROVIDE AT EACH LANDING SELF CONTAINED SMOKE DETECTORS PERMANENTLY WIRED TO A SEPARATELY FUSED CIRCUIT AT THE DISTRIBUTION BOARD WITH BATTERY BACK UP, SMOKE ALARMS TO BE LINKED AND DENOTED THUS:- Ø SMOKE ALARMS TO COMPLY WITH BS 5446;PART I

EXISTING DOORS CHANGED TO HALF HOUR FIRE DOORS FD30 -AT FIRST AND GROUND FLOOR LEVEL THAT OPEN ONTO STAIRS INCLUDING BATH AND W.C.

PROPOSED GROUND FLOOR PLAN

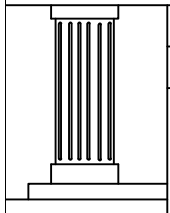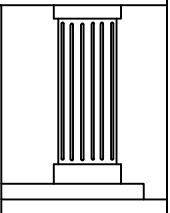

	CHECKED:	DATE: SEPT 2020	DRAWING TITLE: PROPOSED GROUND FLOOR PLAN	PROJECT: I PERRY CLOSE UXBRIDGE UB8 3HR	
	DRAWN:	SCALE: 1:50			
	DRAWING NUMBER: LI				