


NORTH

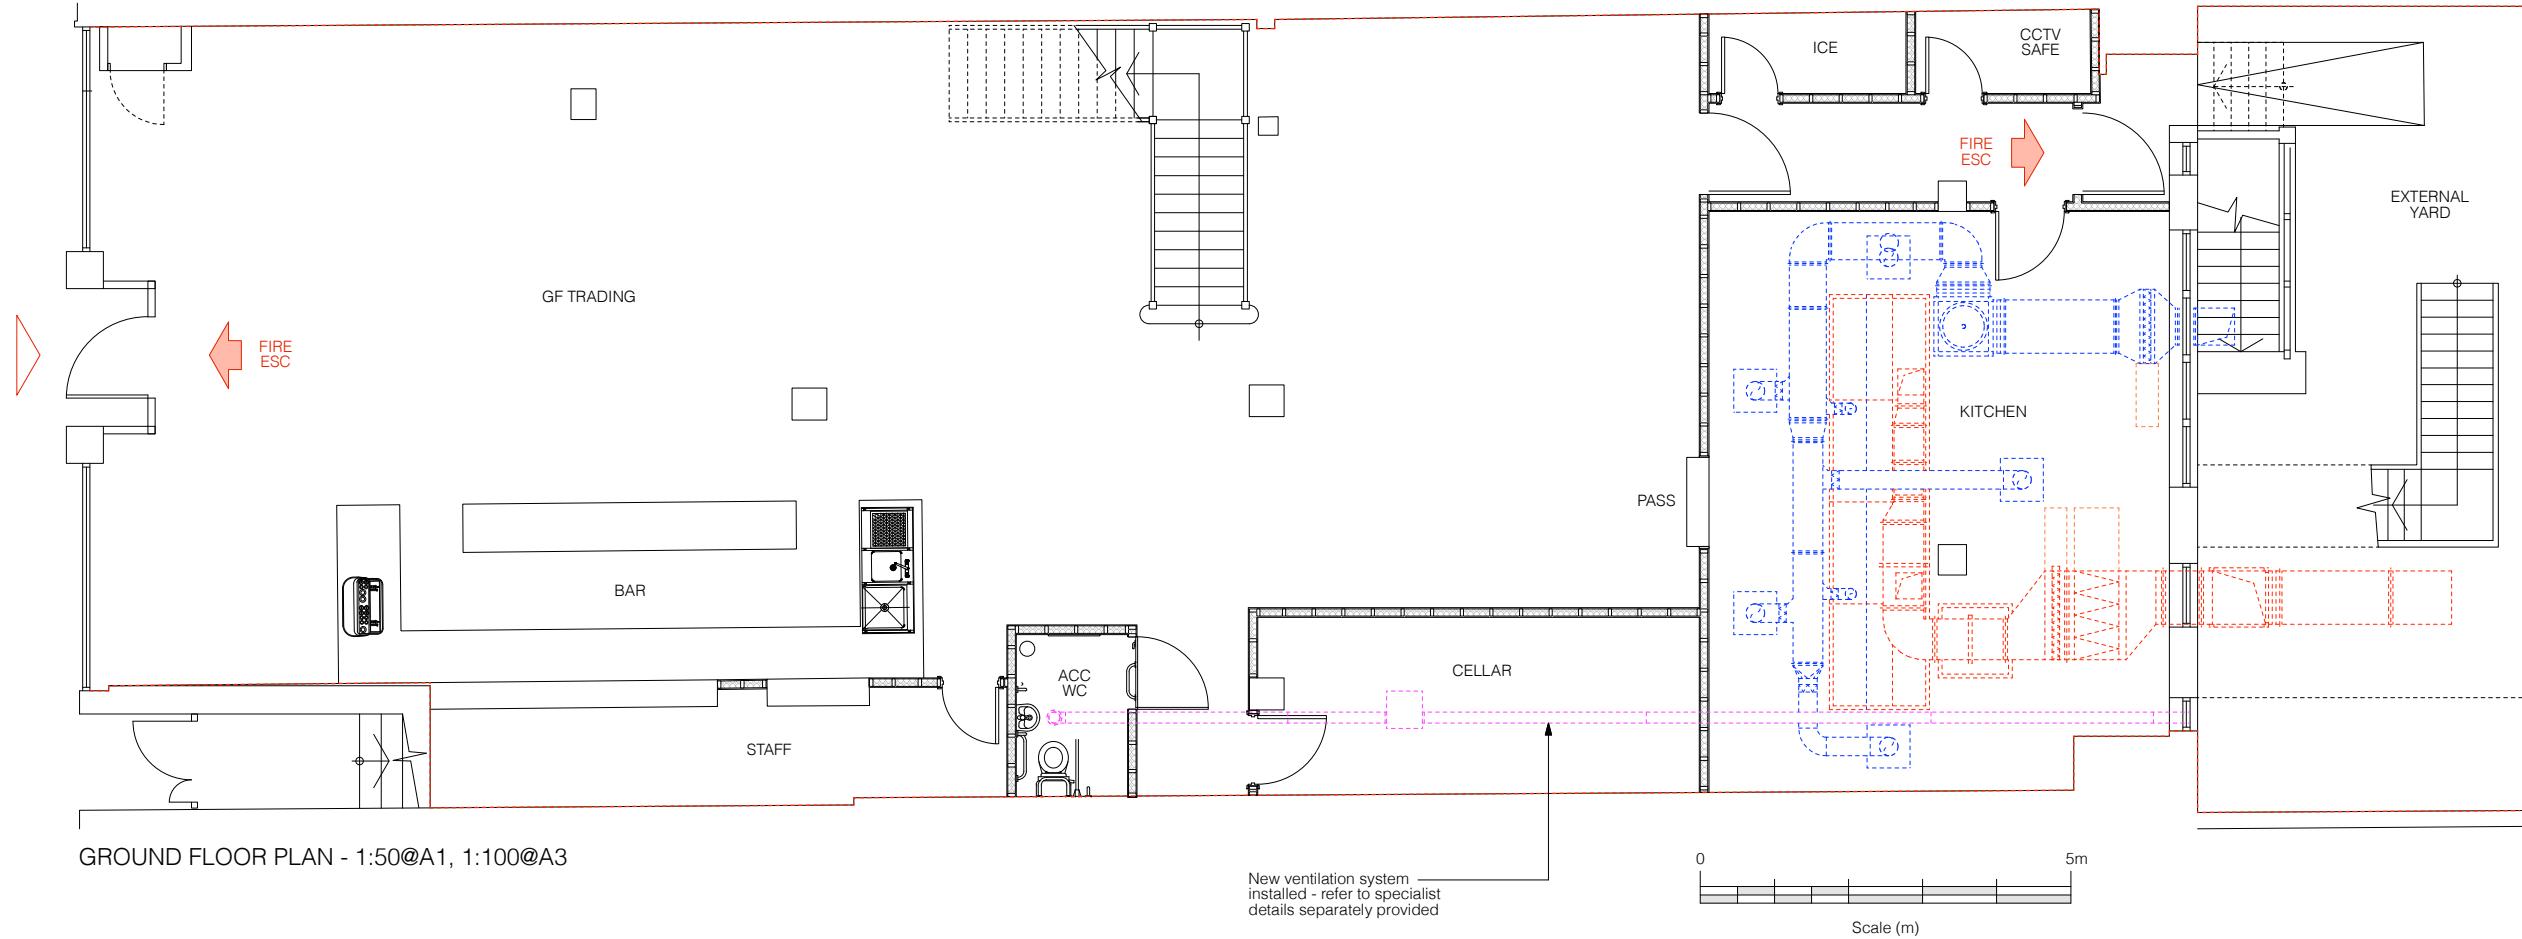

B 05.01.22 DR Labelling corrected
A 05.01.22 DR Ventilation layout added
Rev Date Initials Details

Purpose of Issue
SCHEME DESIGN

RICHARD PEDLAR ARCHITECTS
ARCHITECTURE • CONSERVATION • URBAN DESIGN

RPCA 4 Grove Road Redland
Bristol BS6 6UJ • 0117 974 2612
www.rpc.co.uk • info@rpc.co.uk

Project LOUNGE at 81-83 High Street
Ruislip

Client Loungers UK Limited

Title Proposed Plans

Drawing No. LNG4538.03B

Scale 1:50@A1 1:100@A3 Date DEC 2021

Responsibility is not accepted for errors made by others in scaling from this drawing. All construction information to be taken from figured dimensions only.