


NORTH

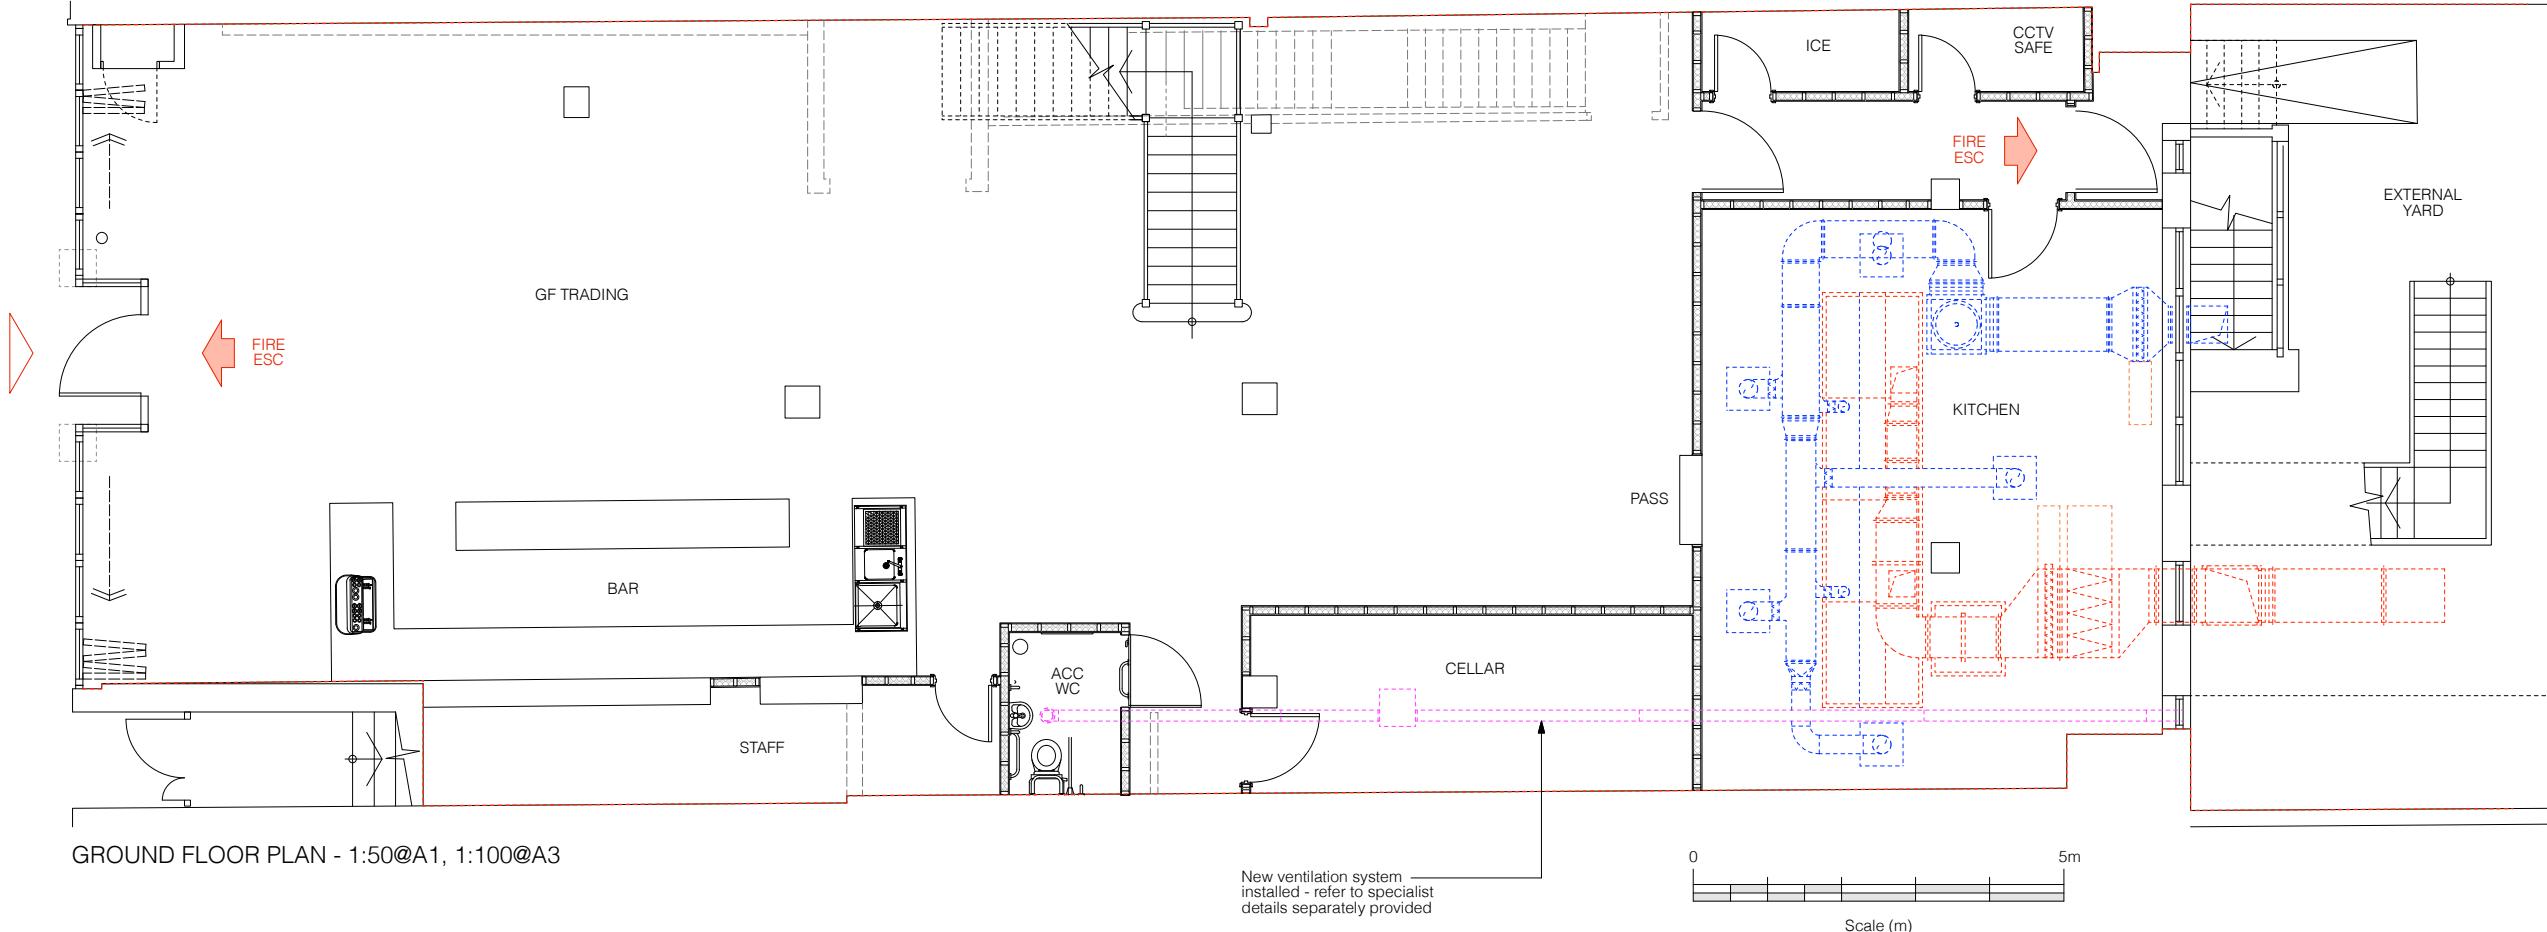

C 18.02.22 FW Shopfront updated
 B 05.01.22 DR Labelling corrected
 A 05.01.22 DR Ventilation layout added
 Rev Date Initials Details

Purpose of Issue
SCHEME DESIGN

RICHARD PEDLAR ARCHITECTS
 ARCHITECTURE • CONSERVATION • URBAN DESIGN

RPCA 4, Grove Road, Redland, Bristol BS6 6UJ • 0117 974 2612
 www.rpca.co.uk • info@rpca.co.uk

Project LOUNGE at 81-83 High Street, Ruislip
 Client Loungers UK Limited

Title Proposed Plans

Drawing No. LNG4535.03C

Scale 1:50@A1 1:100@A3 Date DEC 2021

Responsibility is not accepted for errors made by others in scaling from this drawing. All construction information to be taken from figured dimensions only.