
 


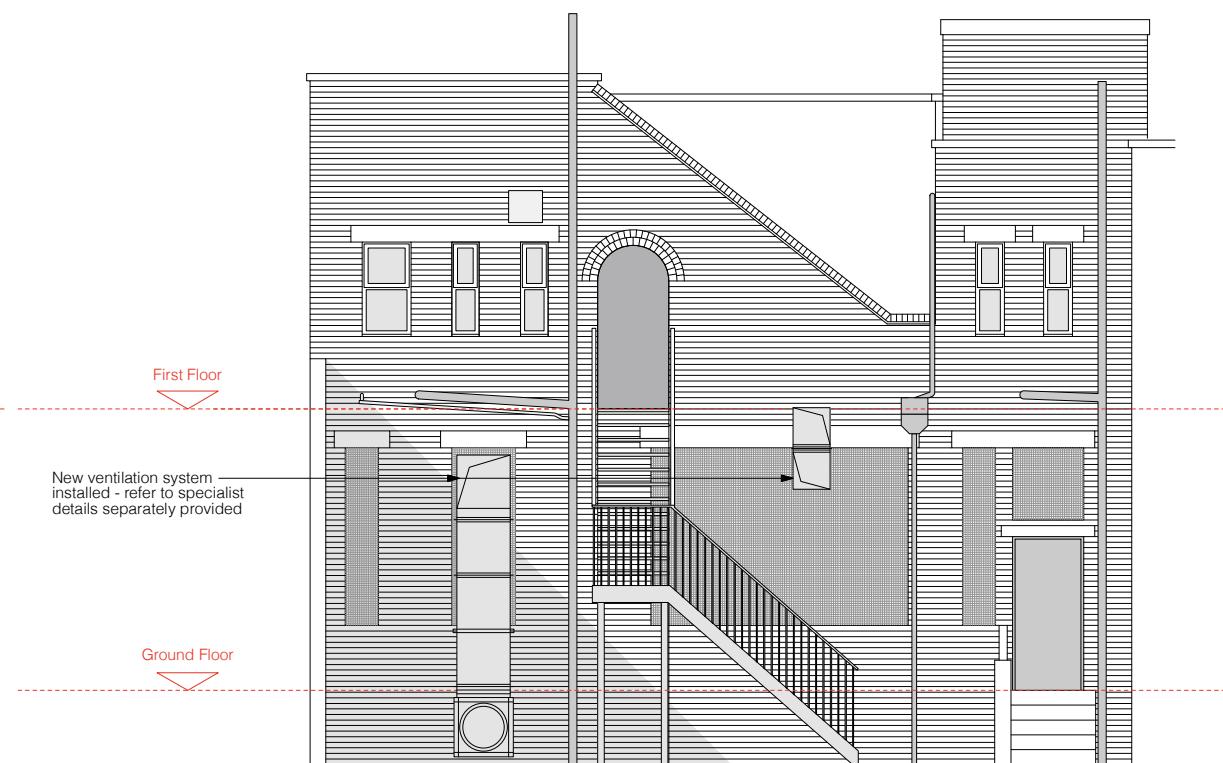

HIGH STREET - SOUTHWEST ELEVATION - 1:50@A1, 1:100@A3



REAR - NORTHEAST ELEVATION - 1:50@A1, 1:100@A3

C 01.04.22 DR Shopfront fenestration amended
B 18.02.22 DR Ventilation Details added
A 05.01.22 DR Ventilation Details added
Rev Date Initials Details

Purpose of Issue
SCHEME DESIGN

RICHARD PEDLAR ARCHITECTS
ARCHITECTURE • CONSERVATION • URBAN DESIGN

RPCA 4, Grove Road, Redland,
Bristol BS6 6UJ • 0117 974 2612
www.rpcaco.uk • info@rpcaco.uk



Project **GRANERO LOUNGE** at 81-83 High Street, Ruislip

Client Loungers UK Limited

Title Proposed Elevations

Drawing No. **LNG4535.04C**

Scale 1:50@A1 Date DEC 2021
1:100@A3

Responsibility is not accepted for errors made by others in scaling from this drawing. All construction information to be taken from figured dimensions only.