
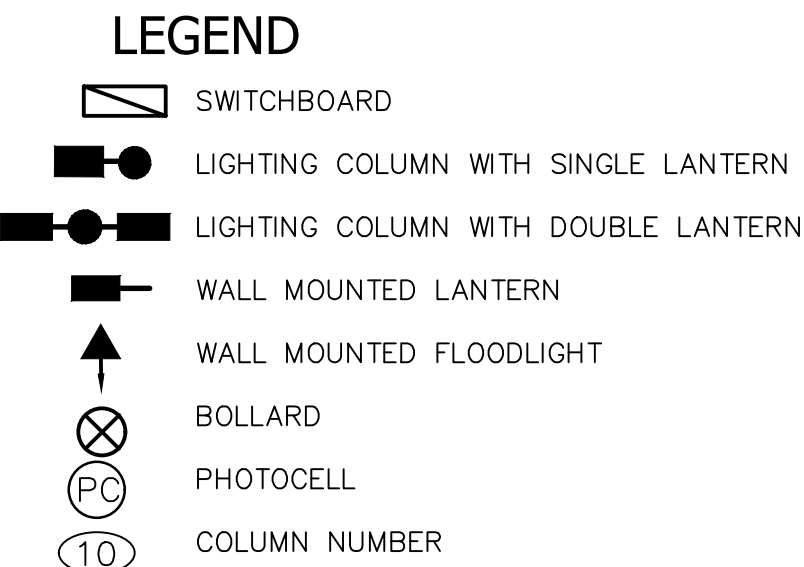



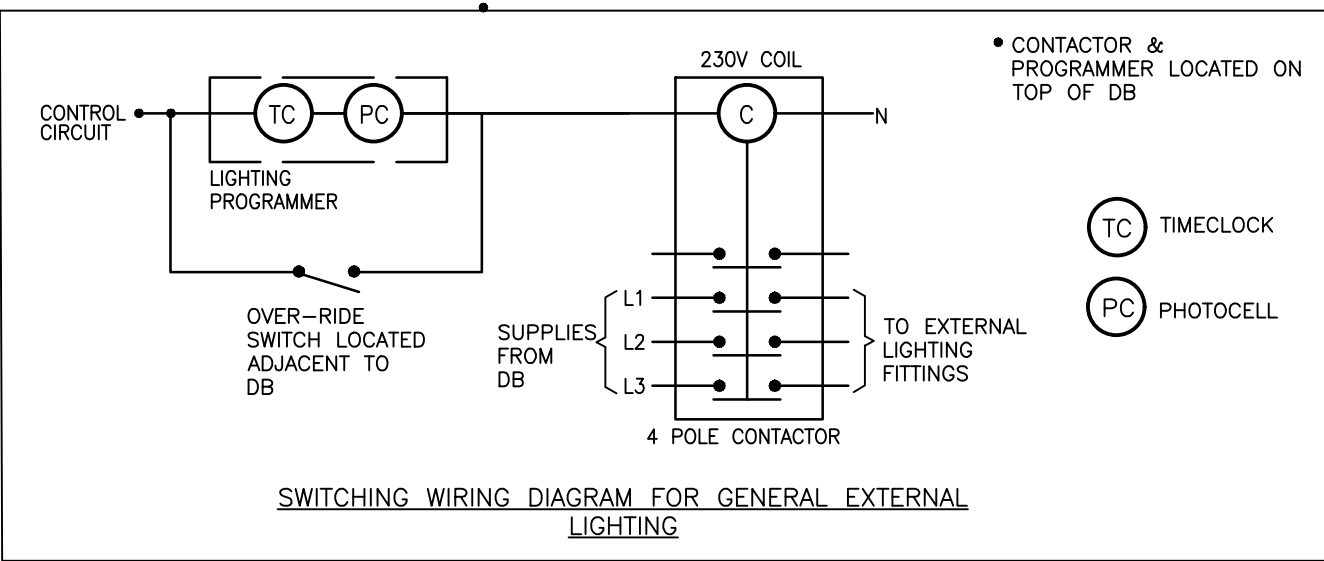


LOCATIONS OF COLUMNS ARE INDICATIVE ONLY. THE MAIN CONTRACTOR & ARCHITECT SHALL BE RESPONSIBLE FOR CO-ORDINATING THE FINAL LOCATIONS WITH KERB DETAILS ETC

LUMINAIRE SCHEDULE

- A KINGFISHER - ITALO 1 -LED LANTERN WITH S05 OPTIC, COLUMN MOUNTED AT 6M
IT1-S05-A.5-4MIF
- B KINGFISHER -ITALO 1 -LED LANTERN WITH S05 OPTIC, BUILDING MOUNTED AT 6M
IT1-S05-A.5-4MIF
RLWB05076
- C KINGFISHER - DECO 20W LED 1000MM FLANGE MOUNTED BOLLARD
BDE1020LEDKFG
- D KINGFISHER - ITALO 3 -5 LED MODULE FLOODLIGHTS WITH 450-7W ASYMMETRICAL COMFORT WIDE OPTIC, WALL MOUNTED AT 10M
IT3-ASC7W4.7-SMF
RLWB05076
- F KINGFISHER - ITALO 3 LED S05 OPTIC-15 LED MODULE FLOODLIGHT COLUMN MOUNTED AT 10M
IT3-S05-A.7-15MIF
- G KINGFISHER -QUARTO VANDEL RESISTANT WALLPACK WITH CYCLE PATH OPTIC BUILDING MOUNTED AT 3M
AQ1018-00KG

PROPOSED LUMINAIRE HEIGHTS WHERE SPECIFIED ARE HEIGHTS ABOVE GROUND FINISHED FLOOR LEVEL

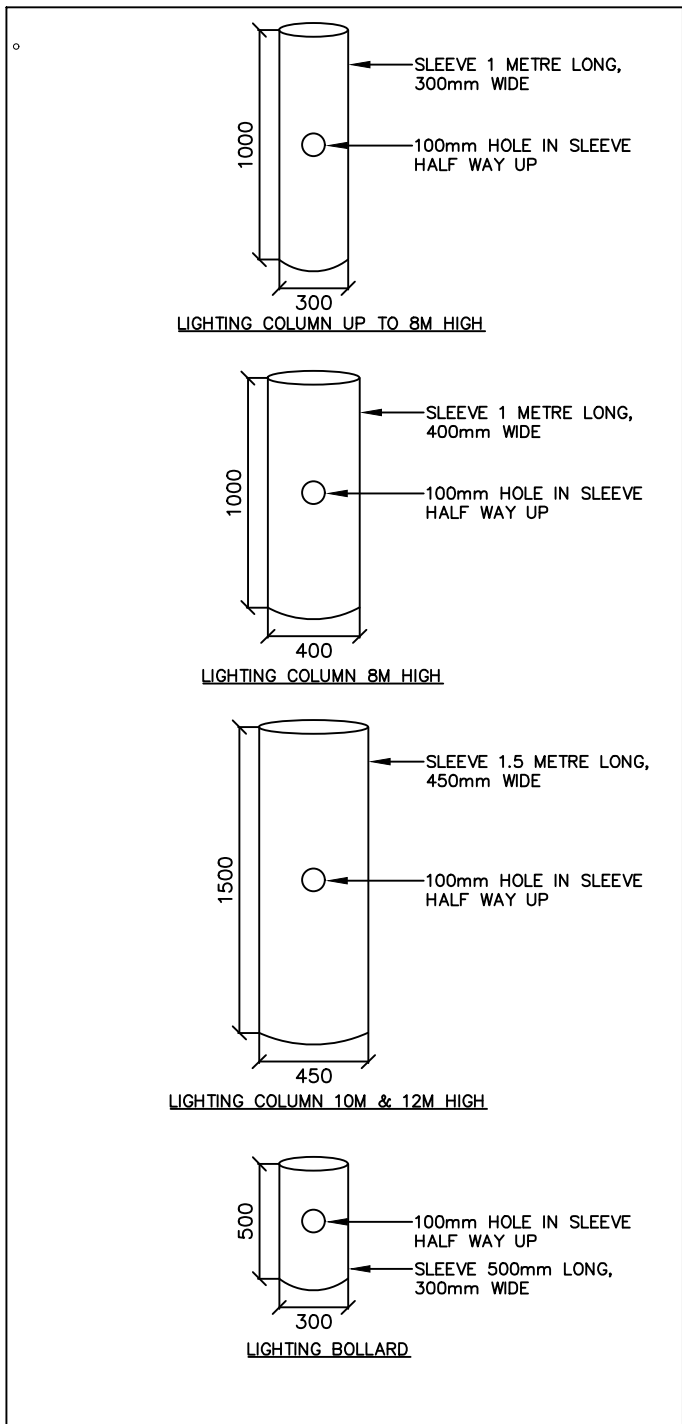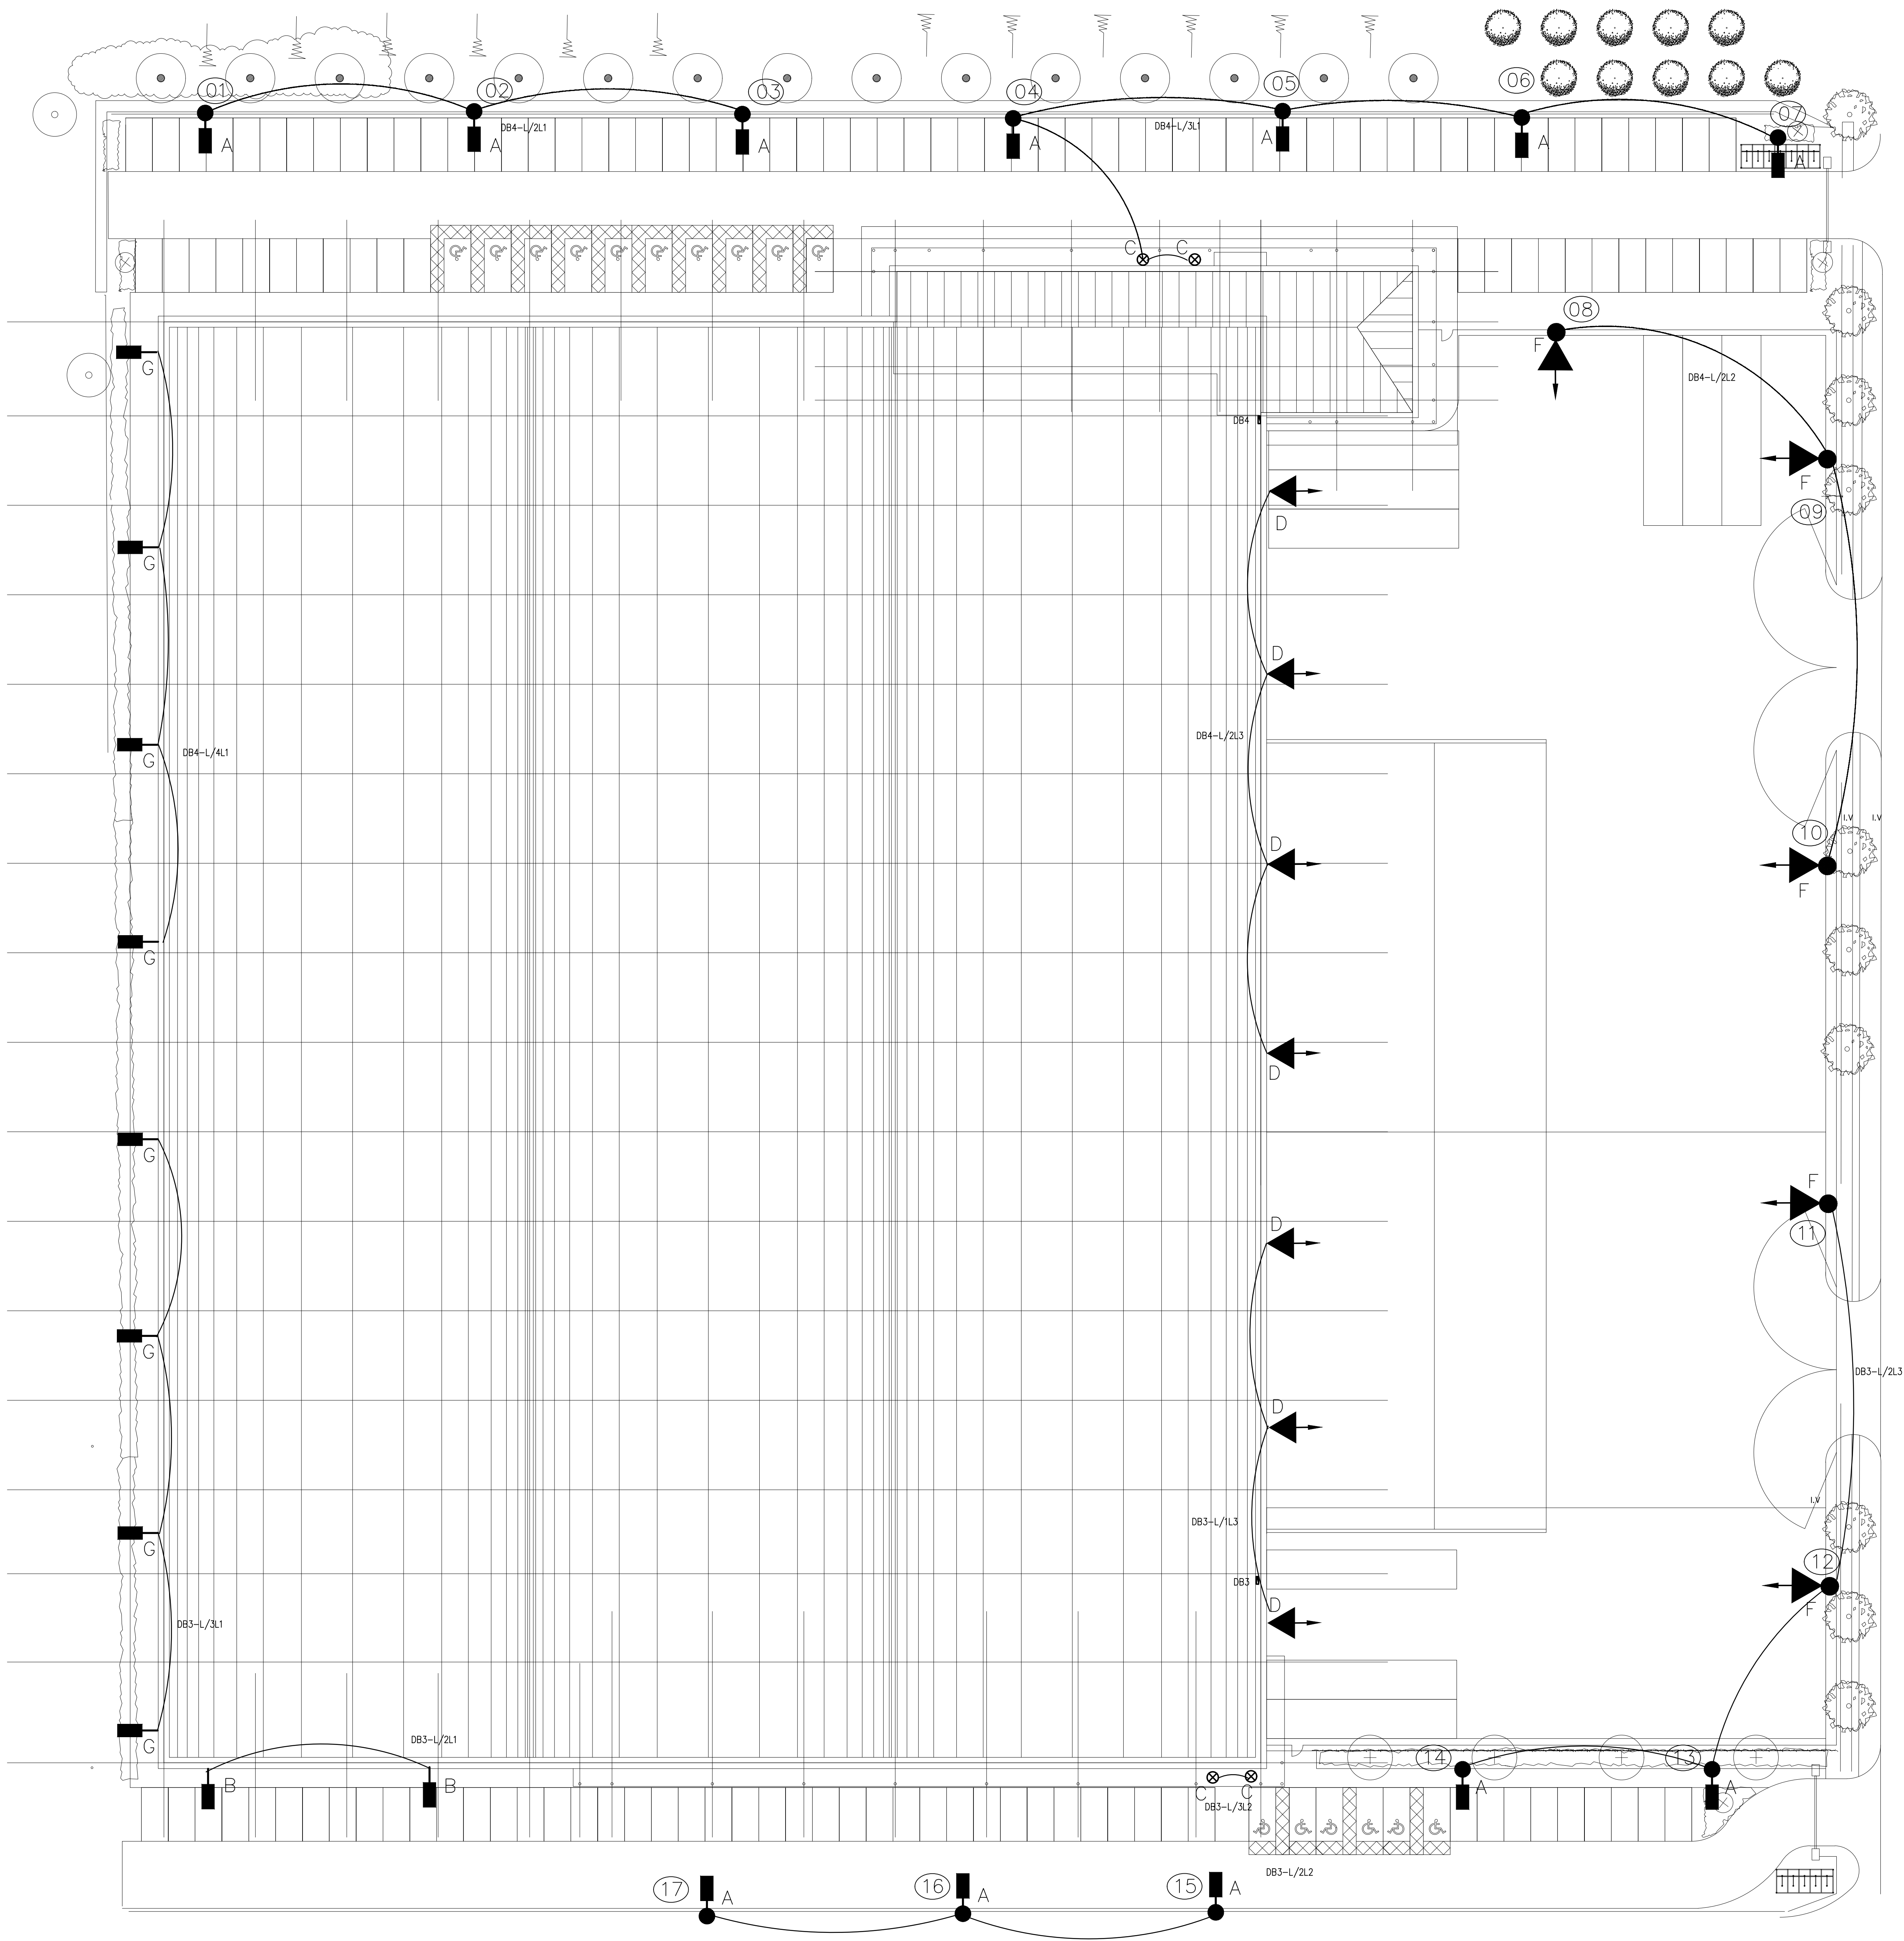

AF	12.11.18	AS FITTED	HVS
REV	DATE	DESCRIPTION	BY

WM BUILDING SERVICES
557 Mutton Road
Thurston
London
Tel: (0116) 311 2477
Fax: (0116) 260 9537
Email: office@wmbuildingservices.com
Web: www.wmbuildingservices.com

BES **ISO 9001** **ISO 14001** **ISO 45001** **REAL**

Project:
Prologis Park
West London
Units 3a & 3b

Client:
readie

Title:
External Lighting Layout

Scale at A0	Date:	Designed:	Drawn:	Design Check:
1:250	03/18	HVS	HVS	RWF
Drawing No:	2088-E-500		Rev:	AF

AS FITTED