




1 Smoking Shelter - Ground Floor Plan
1 : 50

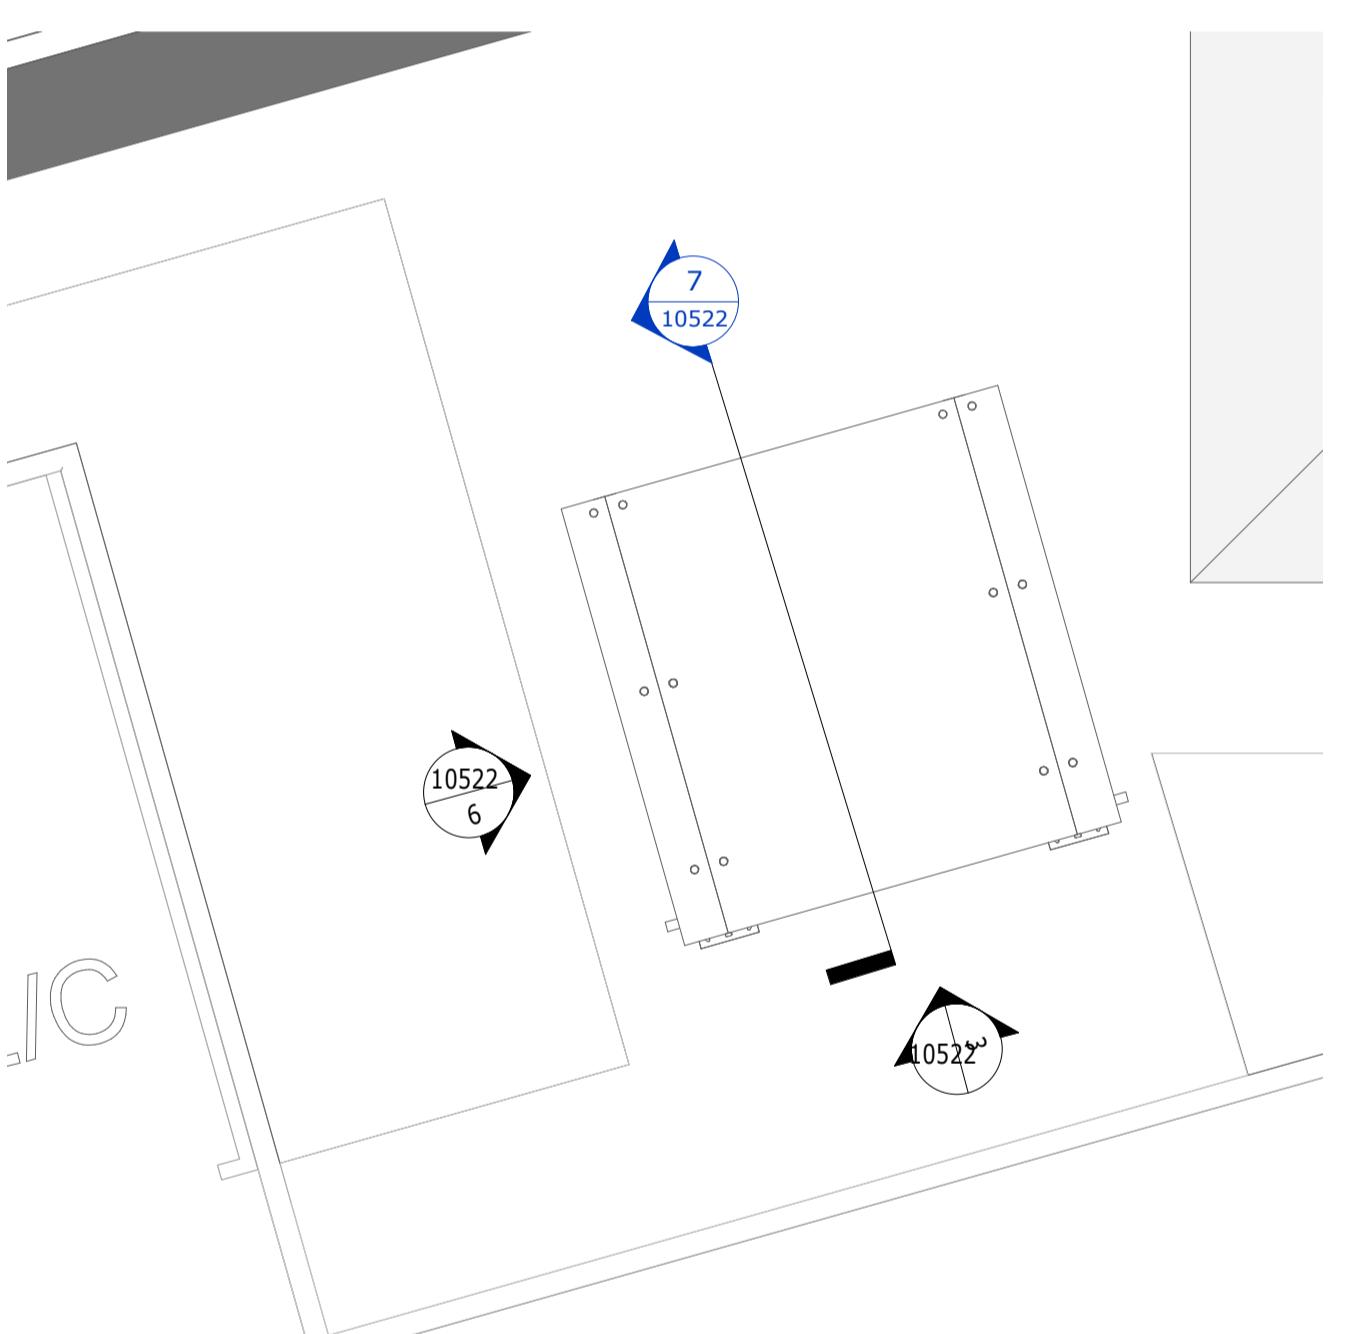


2 Smoking Shelter - Roof Plan
1 : 50

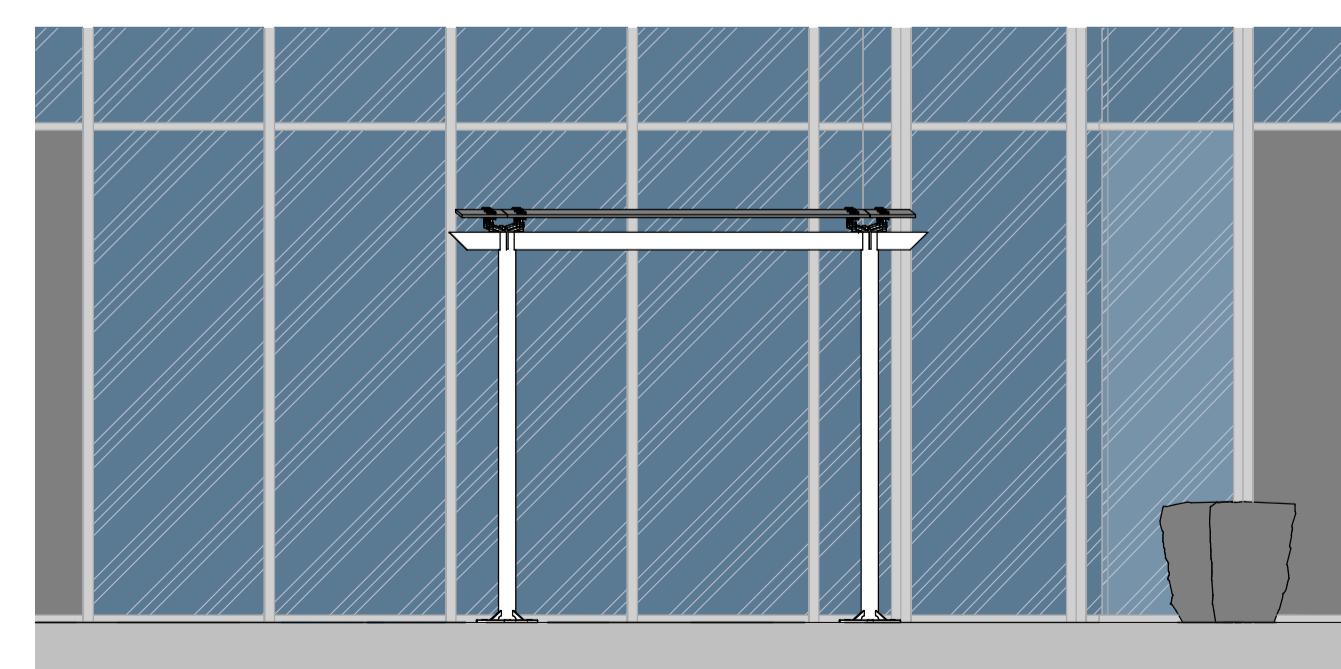


3 Smoking Shelter - South Elevation
1 : 50

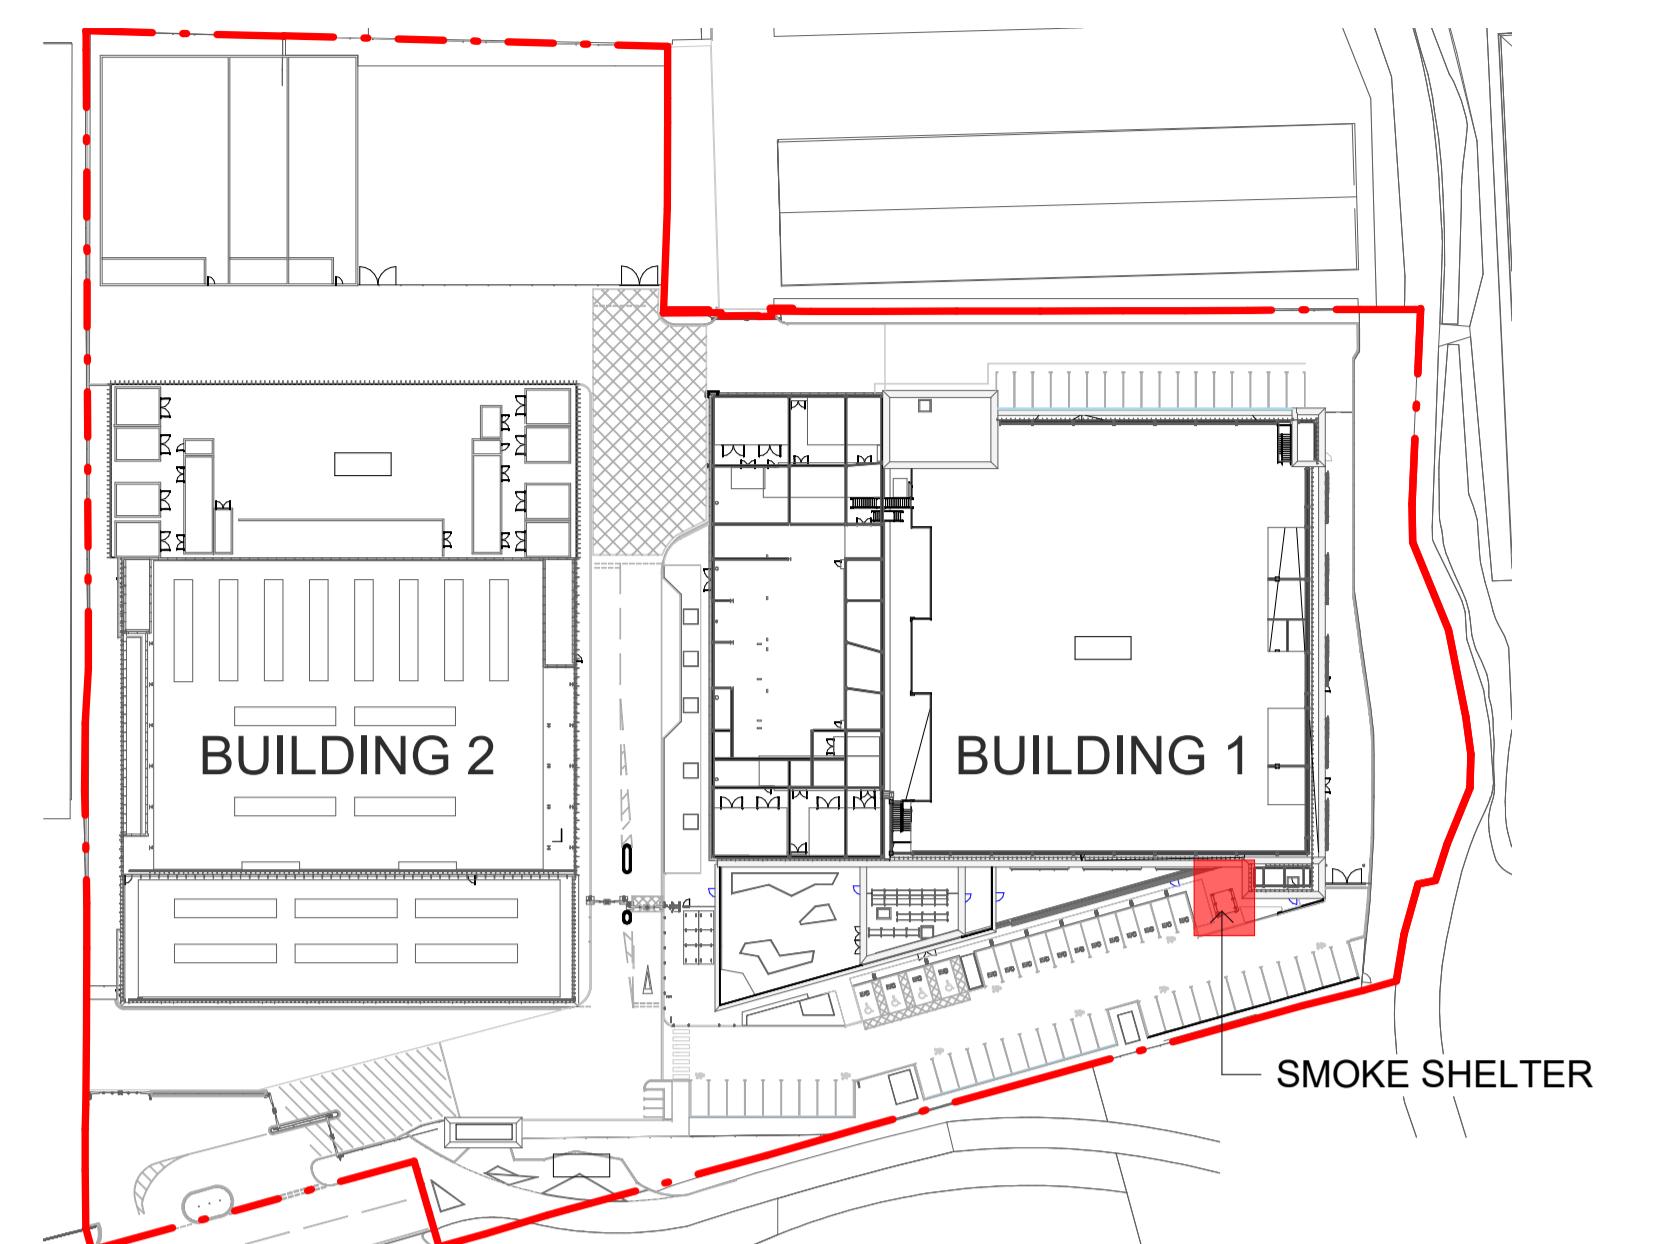


4 Smoking Shelter Site Location
1 : 1000

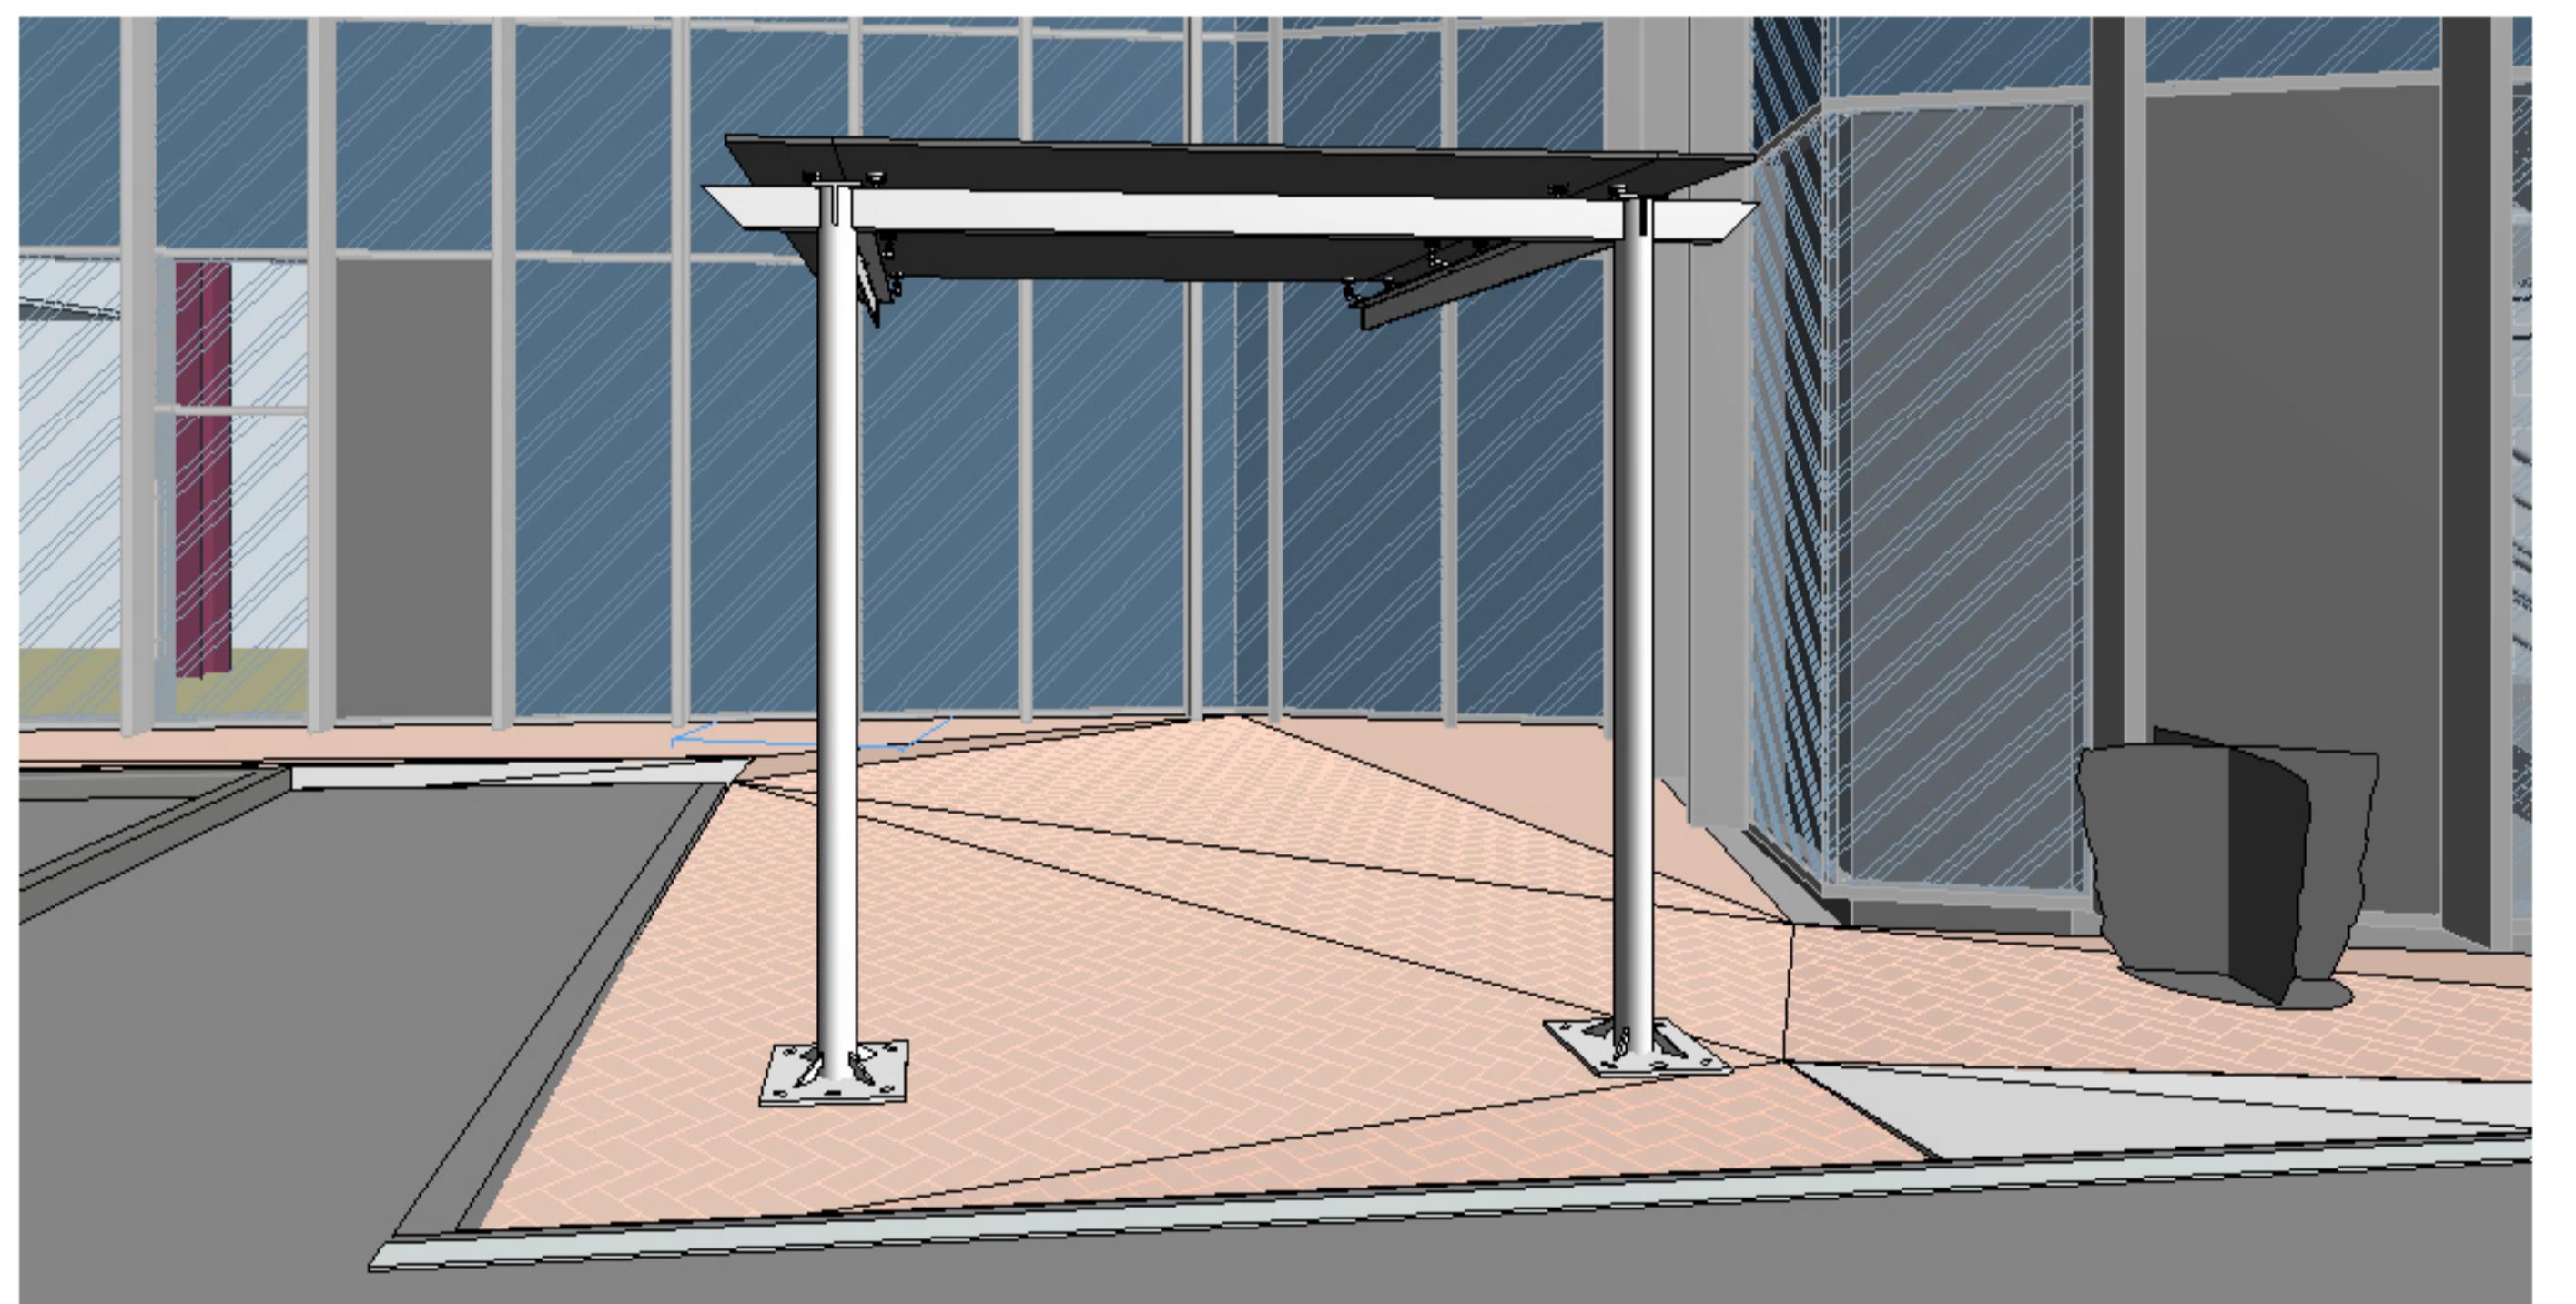

5 Smoking Shelter - 3D

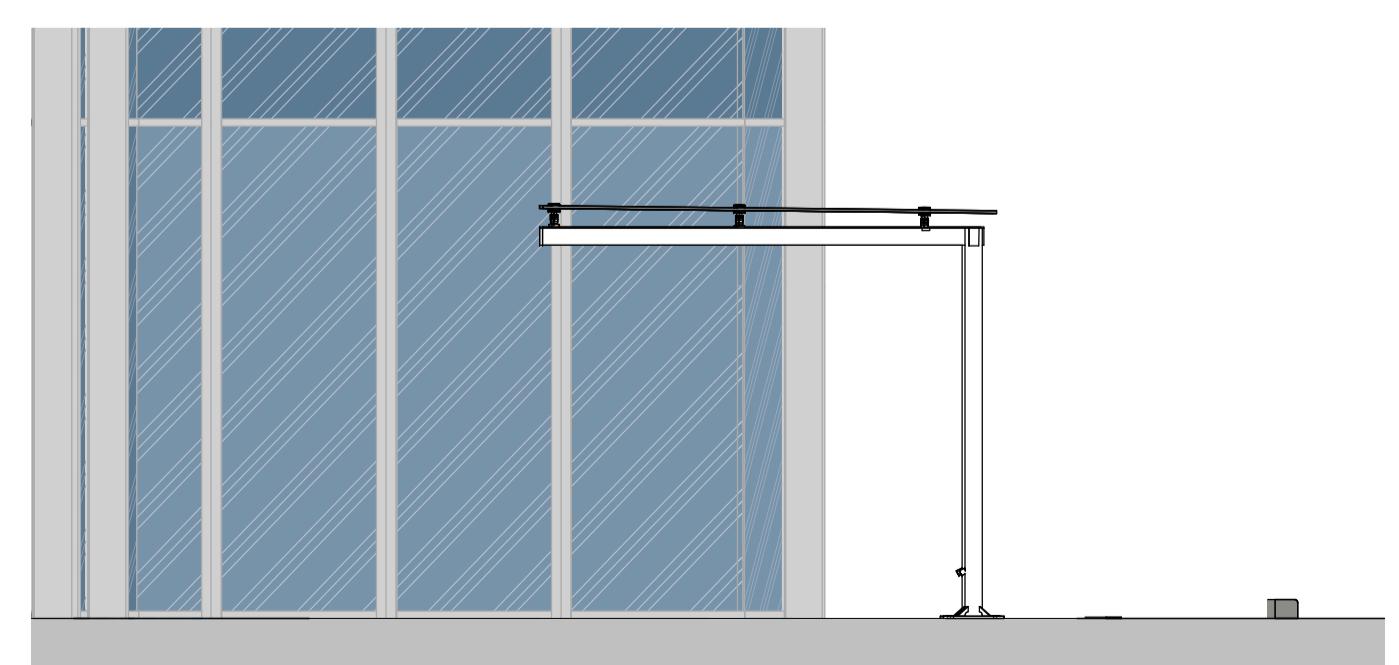

6 Smoking Shelter - West Elevation
1 : 50

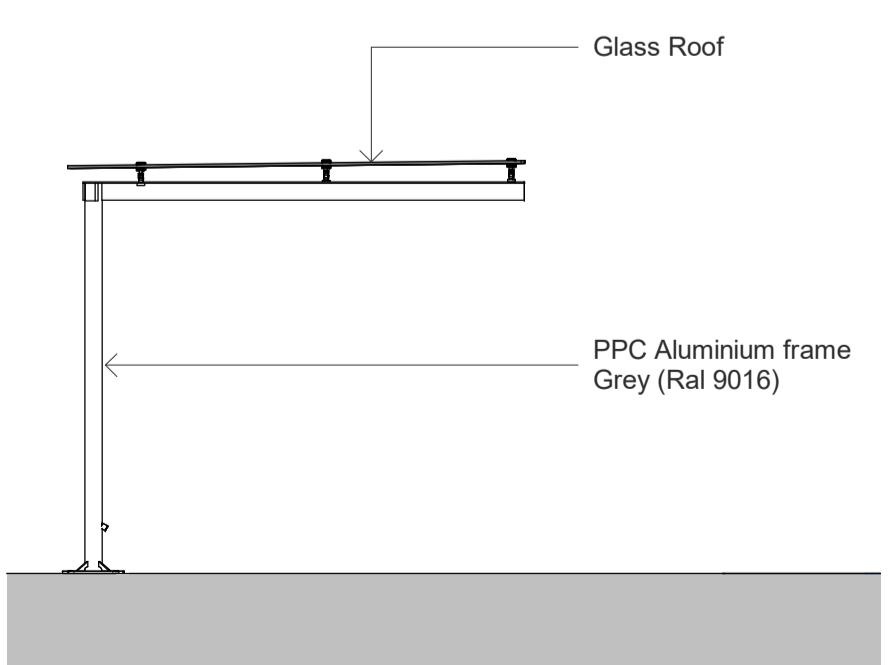


7 1055 - Smoking Shelter - Section
1 : 50

General Notes

- Do not scale from this drawing. All dimensions indicated are in millimetres unless otherwise stated. Validate all measurements on site.
- Any discrepancies between the drawings and other documents shall be brought to the attention of the contractor.
- This drawing is not an installation drawing. It is the contractor's responsibility to make final coordinated installation shop drawings.
- The contents of this drawing shall be read in conjunction with the current revisions of Architecture, Civil, Structural, Mechanical, Electrical, Telecoms drawings and all relevant sections of the specifications.

2000 0 2000 4000 6000 8000
SCALE: 1:200

Key Plan

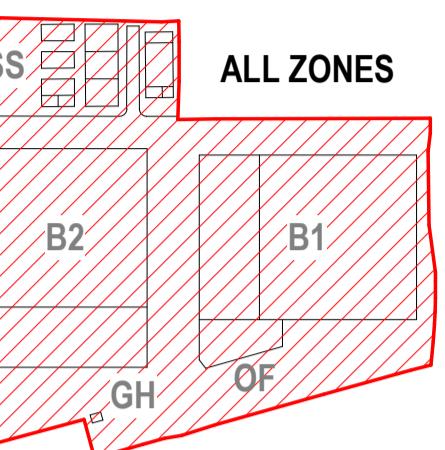

P01 PLANNING ISSUE PD 23/06/2023
Rev Details By Chkd / App Date

Client
colt
Data Centre Services
Lead Consultant / MEP Designer
28-30 Worship Street
London, EC2A 2AH
United Kingdom
www.coltdatcentres.net

28-30 Worship Street
London, EC2A 2AH
United Kingdom
www.coltdatcentres.net

Architect
NWA
NWA Architects
The Old Dairy
Harpenderbury Farm
Redbourn, Hertfordshire
AL3 7QA, United Kingdom
www.nwarchitects.co.uk

The Old Dairy
Harpenderbury Farm
Redbourn, Hertfordshire
AL3 7QA, United Kingdom
www.nwarchitects.co.uk

Structural / Civil Engineer
ARUP
Central Square, Firth Street
Newcastle Upon Tyne
NE1 3PL, United Kingdom
www.arup.com

Central Square, Firth Street
Newcastle Upon Tyne
NE1 3PL, United Kingdom
www.arup.com

Fire Consultant
salus
Building Compliance without Complexity
Security Designer

Building Compliance without Complexity
Security Designer

Project Title
London 4
Drawing Title
**Buildings 1
Smoking Shelter**
Project Status
PLANNING
Discipline
ARCHITECTURE Status Code
S4
Project Number Scale @ A1 Revision
0493 VARIES P01
Drawing Number
DCS20109-NWA-DC-B1-LP-DR-A-10522
Project — Originator — Functional — Spatial — Level — Form — Discipline — Number
Breakdown — Breakdown