


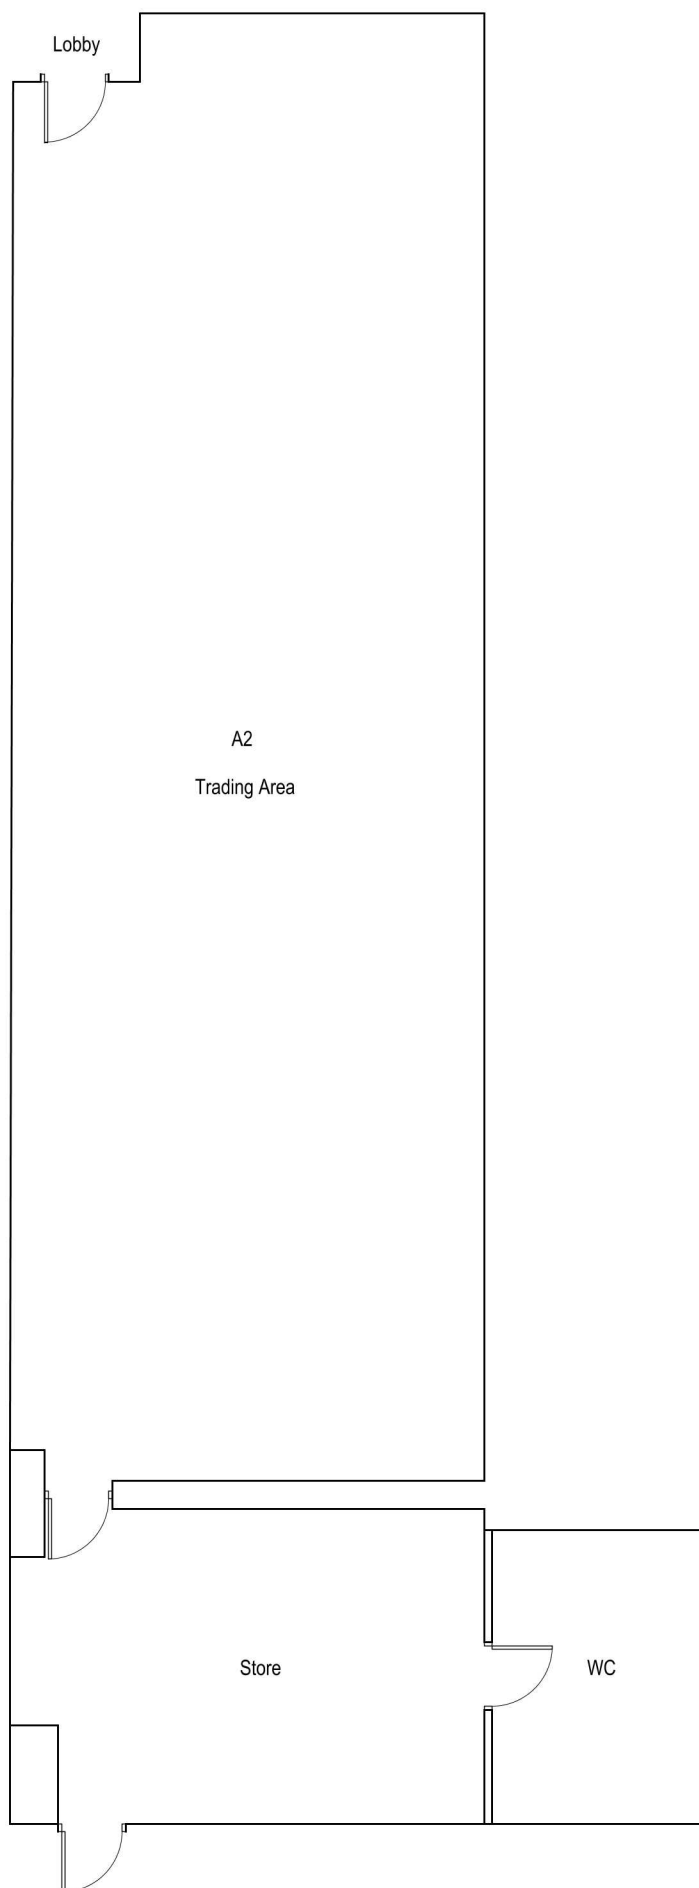

01 EXISTING AND PROPOSED PLAN
Scale 1:100

0m

10m

Revision Table:			
Rev. No.	Date	By	Description of revision
-	-	-	-

Drawing Notes:

-



fluid.
Architectural
Design Consultants

www.fluiddesignassociates.com
Studio. 01904 310 257
E-mail. info@fluid.uk.com
SUITE S1 . THE CATALYST . BAIRD LANE . YORK . YO10 5GA

Client:
Terry O'Sullivan

Project:
173 Field End Road, Eastcote, HA5 1QR

Drawing Title: Existing Floor Plan	Drawing Status: PLANNING
---------------------------------------	-----------------------------

Job No: SUL055	Rev No: -	Drawing Number DE(0)001
-------------------	--------------	----------------------------

Date: MAR 20	Scale: 1:100 @ A4	Drawn By: AG	Checked By: AWJ
-----------------	----------------------	-----------------	--------------------

THIS DRAWING & ALL INFORMATION CONTAINED WITHIN IS THE COPYRIGHT OWNERSHIP OF FLUID ASSOCIATES LLP AND CANNOT BE USED BY ANY OTHER PARTY WITHOUT PRIOR PERMISSION IN WRITING FROM FLUID ASSOCIATES LLP. ALL DIMENSIONS ARE SUBJECT TO A SITE SURVEY - DO NOT SCALE FROM THIS DRAWING - FLUID ASSOCIATES LLP CAN NOT GUARANTEE THE SCALE OF ANY DRAWINGS WHICH ARE CONVERTED TO PDF - ALL DIMENSIONS ARE IN MILLIMETERS UNLESS STATED OTHERWISE. THIS DRAWING SHOULD BE READ IN CONJUNCTION WITH ALL OTHER RELEVANT DRAWINGS AND SPECIFICATIONS - NO PART OF THIS DRAWING IS TO BE REPRODUCED, STORED IN A RETRIEVAL SYSTEM OR TRANSMITTED IN ANY FORM OR BY ANY MEANS WITHOUT PRIOR PERMISSION IN WRITING. COMPANY NUMBER: 06437794. VAT REGISTRATION NUMBER 880 2554 23. FLUID DESIGN IS A TRADING NAME OF FLUID ASSOCIATES LLP