

SECURITY & ACCESS CONTROL LEGEND

- ACCESS CONTROL PANEL
- CARD/FOB ACCESS READER
- CARD/FOB ACCESS READER COMPLETE WITH VIDEO INTERCOM
- REQUEST TO EXIT SENSOR - NON TOUCH
- GREEN BREAK GLASS UNIT
- ACCESS CONTROL MAGNETIC LOCK
- MAGNETIC DOOR CONTACT
- PIR MOTION DETECTOR
- VIDEO INTERCOM ACCESS CONTROL UNIT
- VIDEO INTERCOM ACCESS CONTROL PANEL
- INTRUDER ALARM KEYPAD
- IP65 WALL MOUNTED CCTV DOME CAMERA
- INTRUDER ALARM PANEL

GENERAL NOTES

- THIS DRAWING IS NOT AN INSTALLATION DRAWING.
- SCALED DIMENSIONS SHALL NOT BE TAKEN FROM THIS DRAWING.
- THIS DRAWING SHALL BE READ IN CONJUNCTION WITH ALL RELEVANT REPORTS, SPECIFICATIONS, ARCHITECTURAL AND ENGINEERING DRAWINGS.
- THIS DRAWING SHALL BE PRINTED AND READ IN COLOUR ONLY.

ELECTRICAL NOTES

- THE CONTRACTOR SHALL BE DEEMED TO HAVE INCLUDED FOR ALL ITEMS OF EQUIPMENT INCLUDING MANUFACTURER AND TYPE AS DETAILED ON THIS DRAWING AND WITHIN THE SPECIFICATION.
- THE CONTRACTOR SHALL BE RESPONSIBLE FOR THE CORRECT AND FINAL POSITIONING OF ALL OUTLETS TO MEET THE END-USERS REQUIREMENTS THIS SHALL BE CARRIED OUT IN CONJUNCTION WITH THE PROJECT ARCHITECT. FINAL SETTING OUT EQUIPMENT SHALL BE TO THE ARCHITECTS ROOM LAYOUT AND REFLECTED CEILING PLANS.
- THE CONTRACTOR SHALL CO-ORDINATE ALL ELECTRICAL SERVICES WITH MECHANICAL SERVICES AND STRUCTURE.
- THE CONTRACTOR SHALL EMPLOY A REPRESENTATIVE OF THE SYSTEM MANUFACTURER TO TEST AND COMMISSION EACH SYSTEM UPON COMPLETION OF EACH PHASE OF WORKS.

P09	APR 24	FINAL STAGE 4 ISSUE	AT	RML
P08	MAR 24	PRELIMINARY TENDER ISSUE	LD	DR
P07	JAN 24	UPDATED TO INCORPORATE ARCHITECT COMMENTS	LD	RML
P06	DEC 23	UPDATED FOR LAYOUT CHANGE	LD	RML
P05	MARCH 23	REVISED	JS	NR
P03	APR 22	FOR PLANNING AMENDMENTS	JS	NR
P02	DEC 21	SUITABLE FOR STAGE APPROVAL	BP	JP
P01	SEP 21	CHANGES TO TITLE BLOCK REVISIONS	ZD	DR
T02	SEP 21	TENDER ISSUE	JS	NR
T01	SEP 21	TENDER ISSUE	JS	NR
REV	DATE	DESCRIPTION	BY	VE



STAGE 4

SUITABLE FOR STAGE APPROVAL

CLIENT: THE HILLINGDON HOSPITALS NHS - FOUNDATION TRUST

PROJECT: HILLINGDON HOSPITAL - THE FURZE

DRAWING TITLE

ELECTRICAL SERVICES
GROUND FLOOR - CLINICAL ADMIN
SECURITY, ACCESS & CCTV LAYOUT



SCALE (A): 1:50 DATE: SEP 21 BY: JG VE: NR

Proj ID: THHFP1 CPW: ZZ Volume: 00 Level: DR Role: E S1001 Number: Subdiv: Revision: P09

THHFP1-CPW-ZZ-00-DR-E-51001_S4_P09
CPW Project No: 240299

LINKED FILES: HTF-LDW-XX-ZZ-M3-A-0001

THHFP1-CRH-ZZ-M3-S-0001

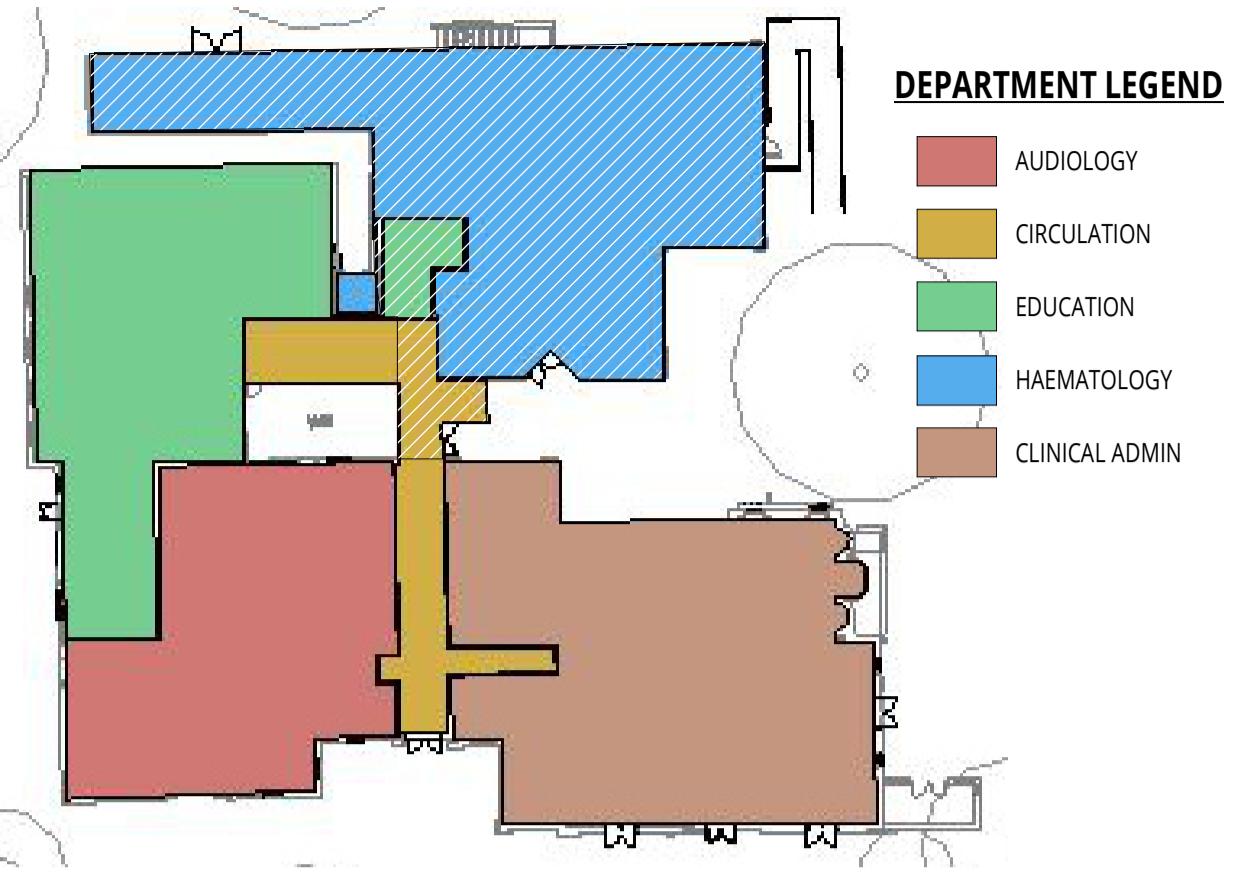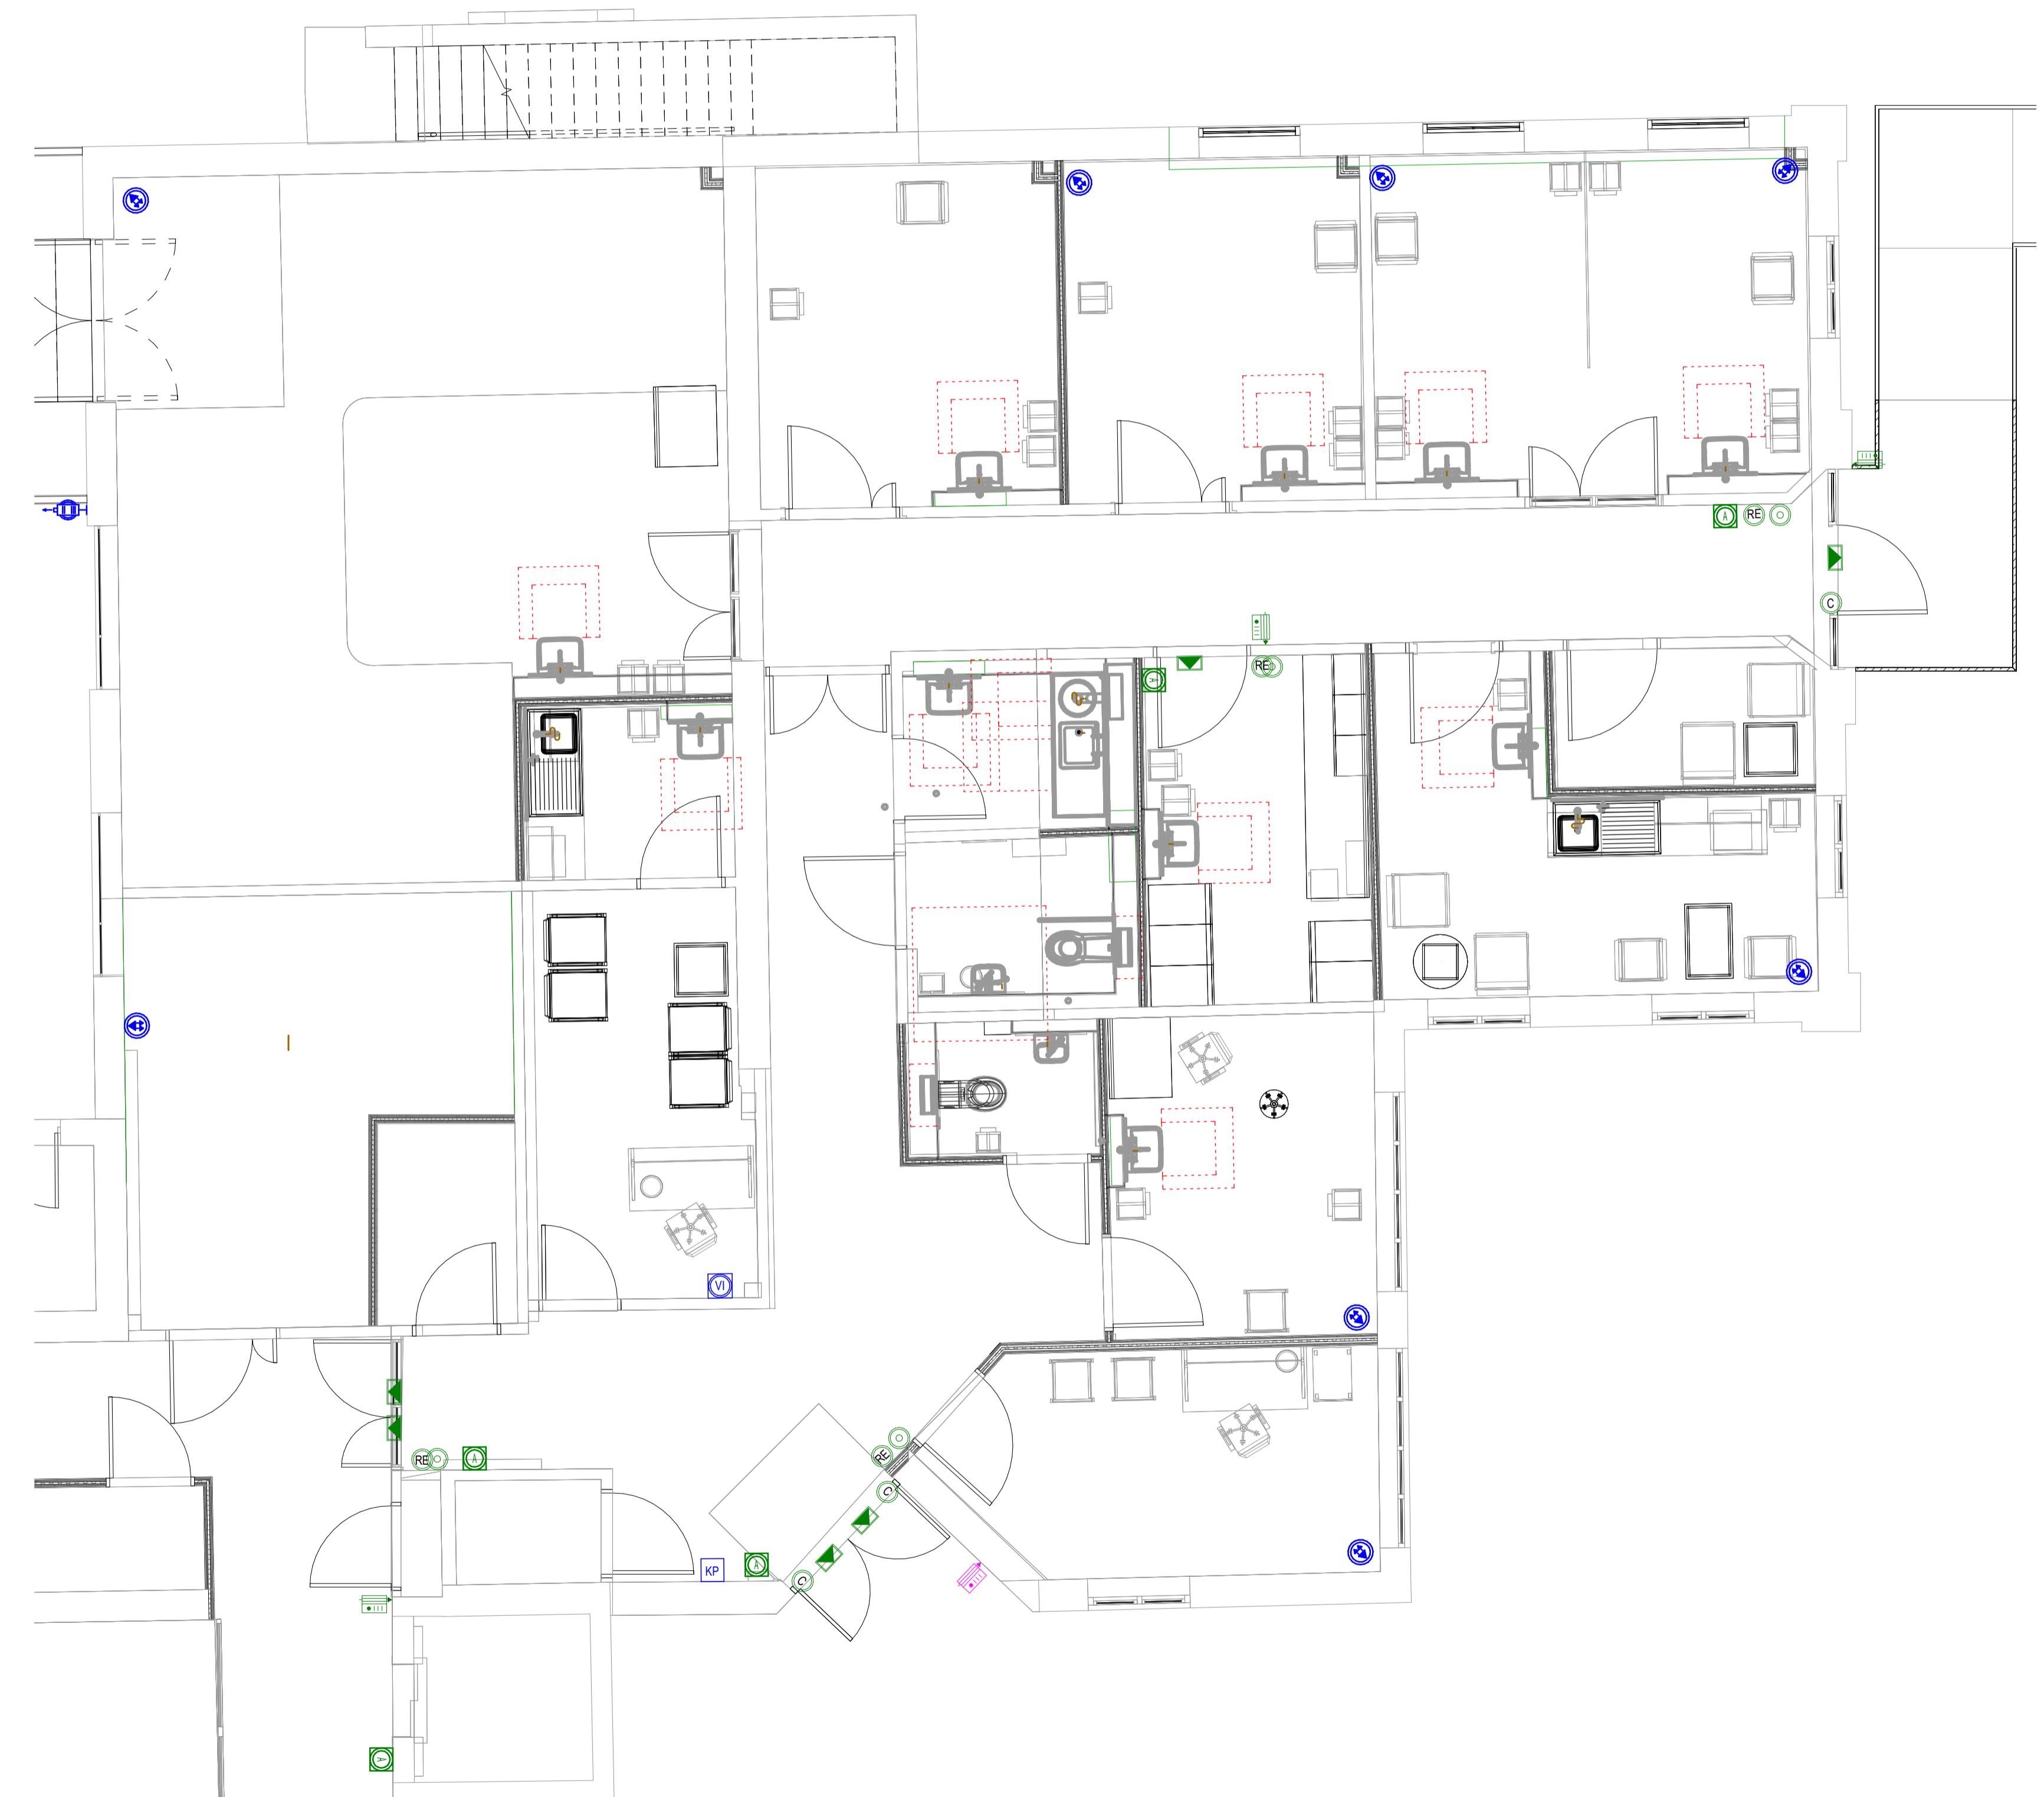

SECURITY & ACCESS CONTROL LEGEND

- ACCESS CONTROL PANEL
- CARD/FOB ACCESS READER
- CARD/FOB ACCESS READER COMPLETE WITH VIDEO INTERCOM
- REQUEST TO EXIT SENSOR - NON TOUCH
- GREEN BREAK GLASS UNIT
- ACCESS CONTROL MAGNETIC LOCK
- MAGNETIC DOOR CONTACT
- PIR MOTION DETECTOR
- VIDEO INTERCOM ACCESS CONTROL UNIT
- VIDEO INTERCOM ACCESS CONTROL PANEL
- INTRUDER ALARM KEYPAD
- IP65 WALL MOUNTED CCTV DOME CAMERA
- INTRUDER ALARM PANEL

GENERAL NOTES

- THIS DRAWING IS NOT AN INSTALLATION DRAWING.
- SCALED DIMENSIONS SHALL NOT BE TAKEN FROM THIS DRAWING.
- THIS DRAWING SHALL BE READ IN CONJUNCTION WITH ALL RELEVANT REPORTS, SPECIFICATIONS, ARCHITECTURAL AND ENGINEERING DRAWINGS.
- THIS DRAWING SHALL BE PRINTED AND READ IN COLOUR ONLY.

ELECTRICAL NOTES

- THE CONTRACTOR SHALL BE DEEMED TO HAVE INCLUDED FOR ALL ITEMS OF EQUIPMENT INCLUDING MANUFACTURER AND TYPE AS DETAILED ON THIS DRAWING AND WITHIN THE SPECIFICATION.
- THE CONTRACTOR SHALL BE RESPONSIBLE FOR THE CORRECT AND FINAL POSITIONING OF ALL OUTLETS TO MEET THE END-USERS REQUIREMENTS THIS SHALL BE CARRIED OUT IN CONJUNCTION WITH THE PROJECT ARCHITECT. FINAL SETTING OUT EQUIPMENT SHALL BE TO THE ARCHITECTS ROOM LAYOUT AND REFLECTED CEILING PLANS.
- THE CONTRACTOR SHALL CO-ORDINATE ALL ELECTRICAL SERVICES WITH MECHANICAL SERVICES AND STRUCTURE.
- THE CONTRACTOR SHALL EMPLOY A REPRESENTATIVE OF THE SYSTEM MANUFACTURER TO TEST AND COMMISSION EACH SYSTEM UPON COMPLETION OF EACH PHASE OF WORKS.

P09	APR 24	FINAL STAGE 4 ISSUE	AT	RM
P08	MAR 24	PRELIMINARY TENDER ISSUE	LD	DR
P07	JAN 24	UPATED TO INCORPORATE ARCHITECT COMMENTS	LD	RM
P06	DEC 23	UPATED FOR LAYOUT CHANGE	LD	RM
P05	MAY 23	FOR PLANNING AMENDMENTS	JS	DR
P03	APR 22	SUITABLE FOR STAGE APPROVAL	JS	NR
P02	DEC 21	SUITABLE FOR STAGE APPROVAL	BP	JP
T02	SEP 21	CHANGES TO TITLE BLOCK REVISIONS	ZD	DR
T01	SEP 21	TENDER ISSUE	JS	DR
REV	DATE	DESCRIPTION	BY	VE



STAGE 4

STATUS

SUITABLE FOR STAGE APPROVAL

CLIENT

THE HILLINGDON HOSPITALS NHS - FOUNDATION TRUST

PROJECT

HILLINGDON HOSPITAL - THE FURZE

DRAWING TITLE

EELECTRICAL SERVICES
GROUND FLOOR - HAEMATOLOGY
SECURITY, ACCESS & CCTV LAYOUT

SCALE (A) DATE BY VE
1:50 SEP 21 JG NR



Proj ID Originator Volume Level Type Ref. Number Sub Ref. Revision
THHFP1 CPW ZZ 00 DR E S1003 P09

THHFP1-CPW-ZZ-00-DR-E-51003_S4_P09
CPW Project No. 240299

LINKED FILES

HTF-LDW-XX-ZZ-M3-A-0001

THHFP1-CRH-ZZ-M3-S-0001

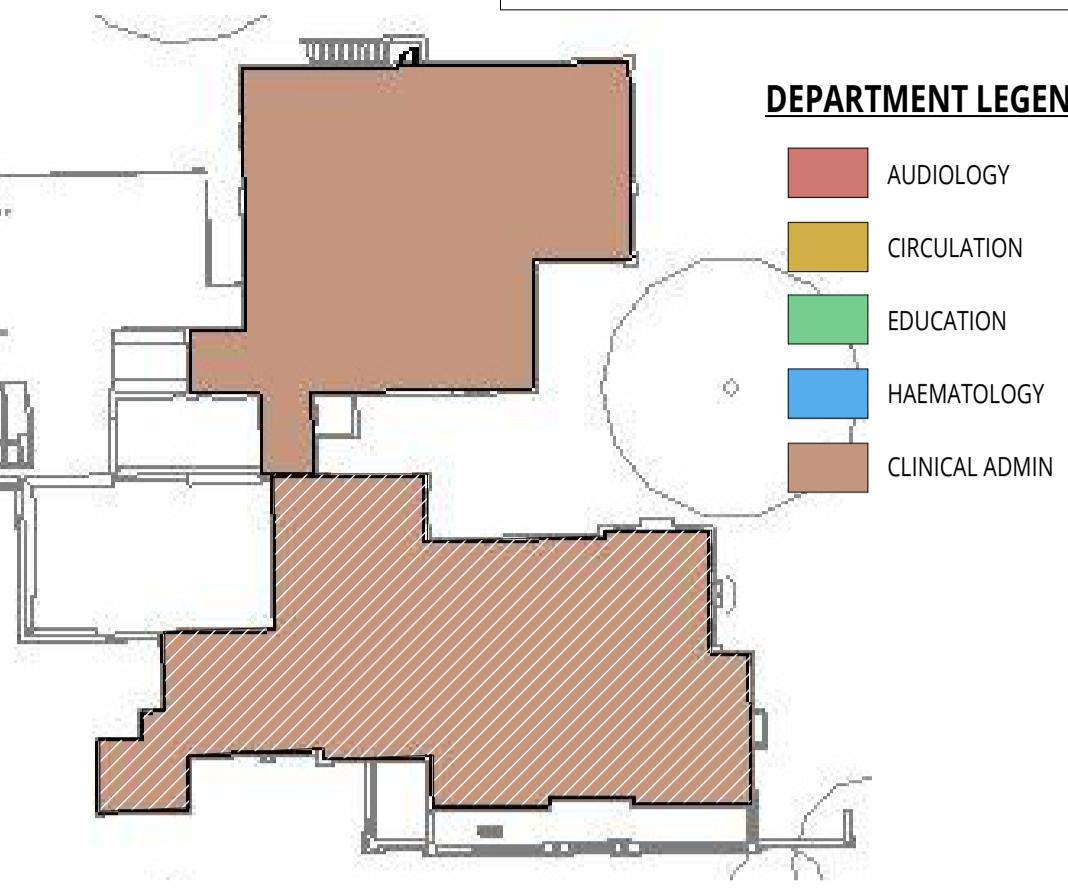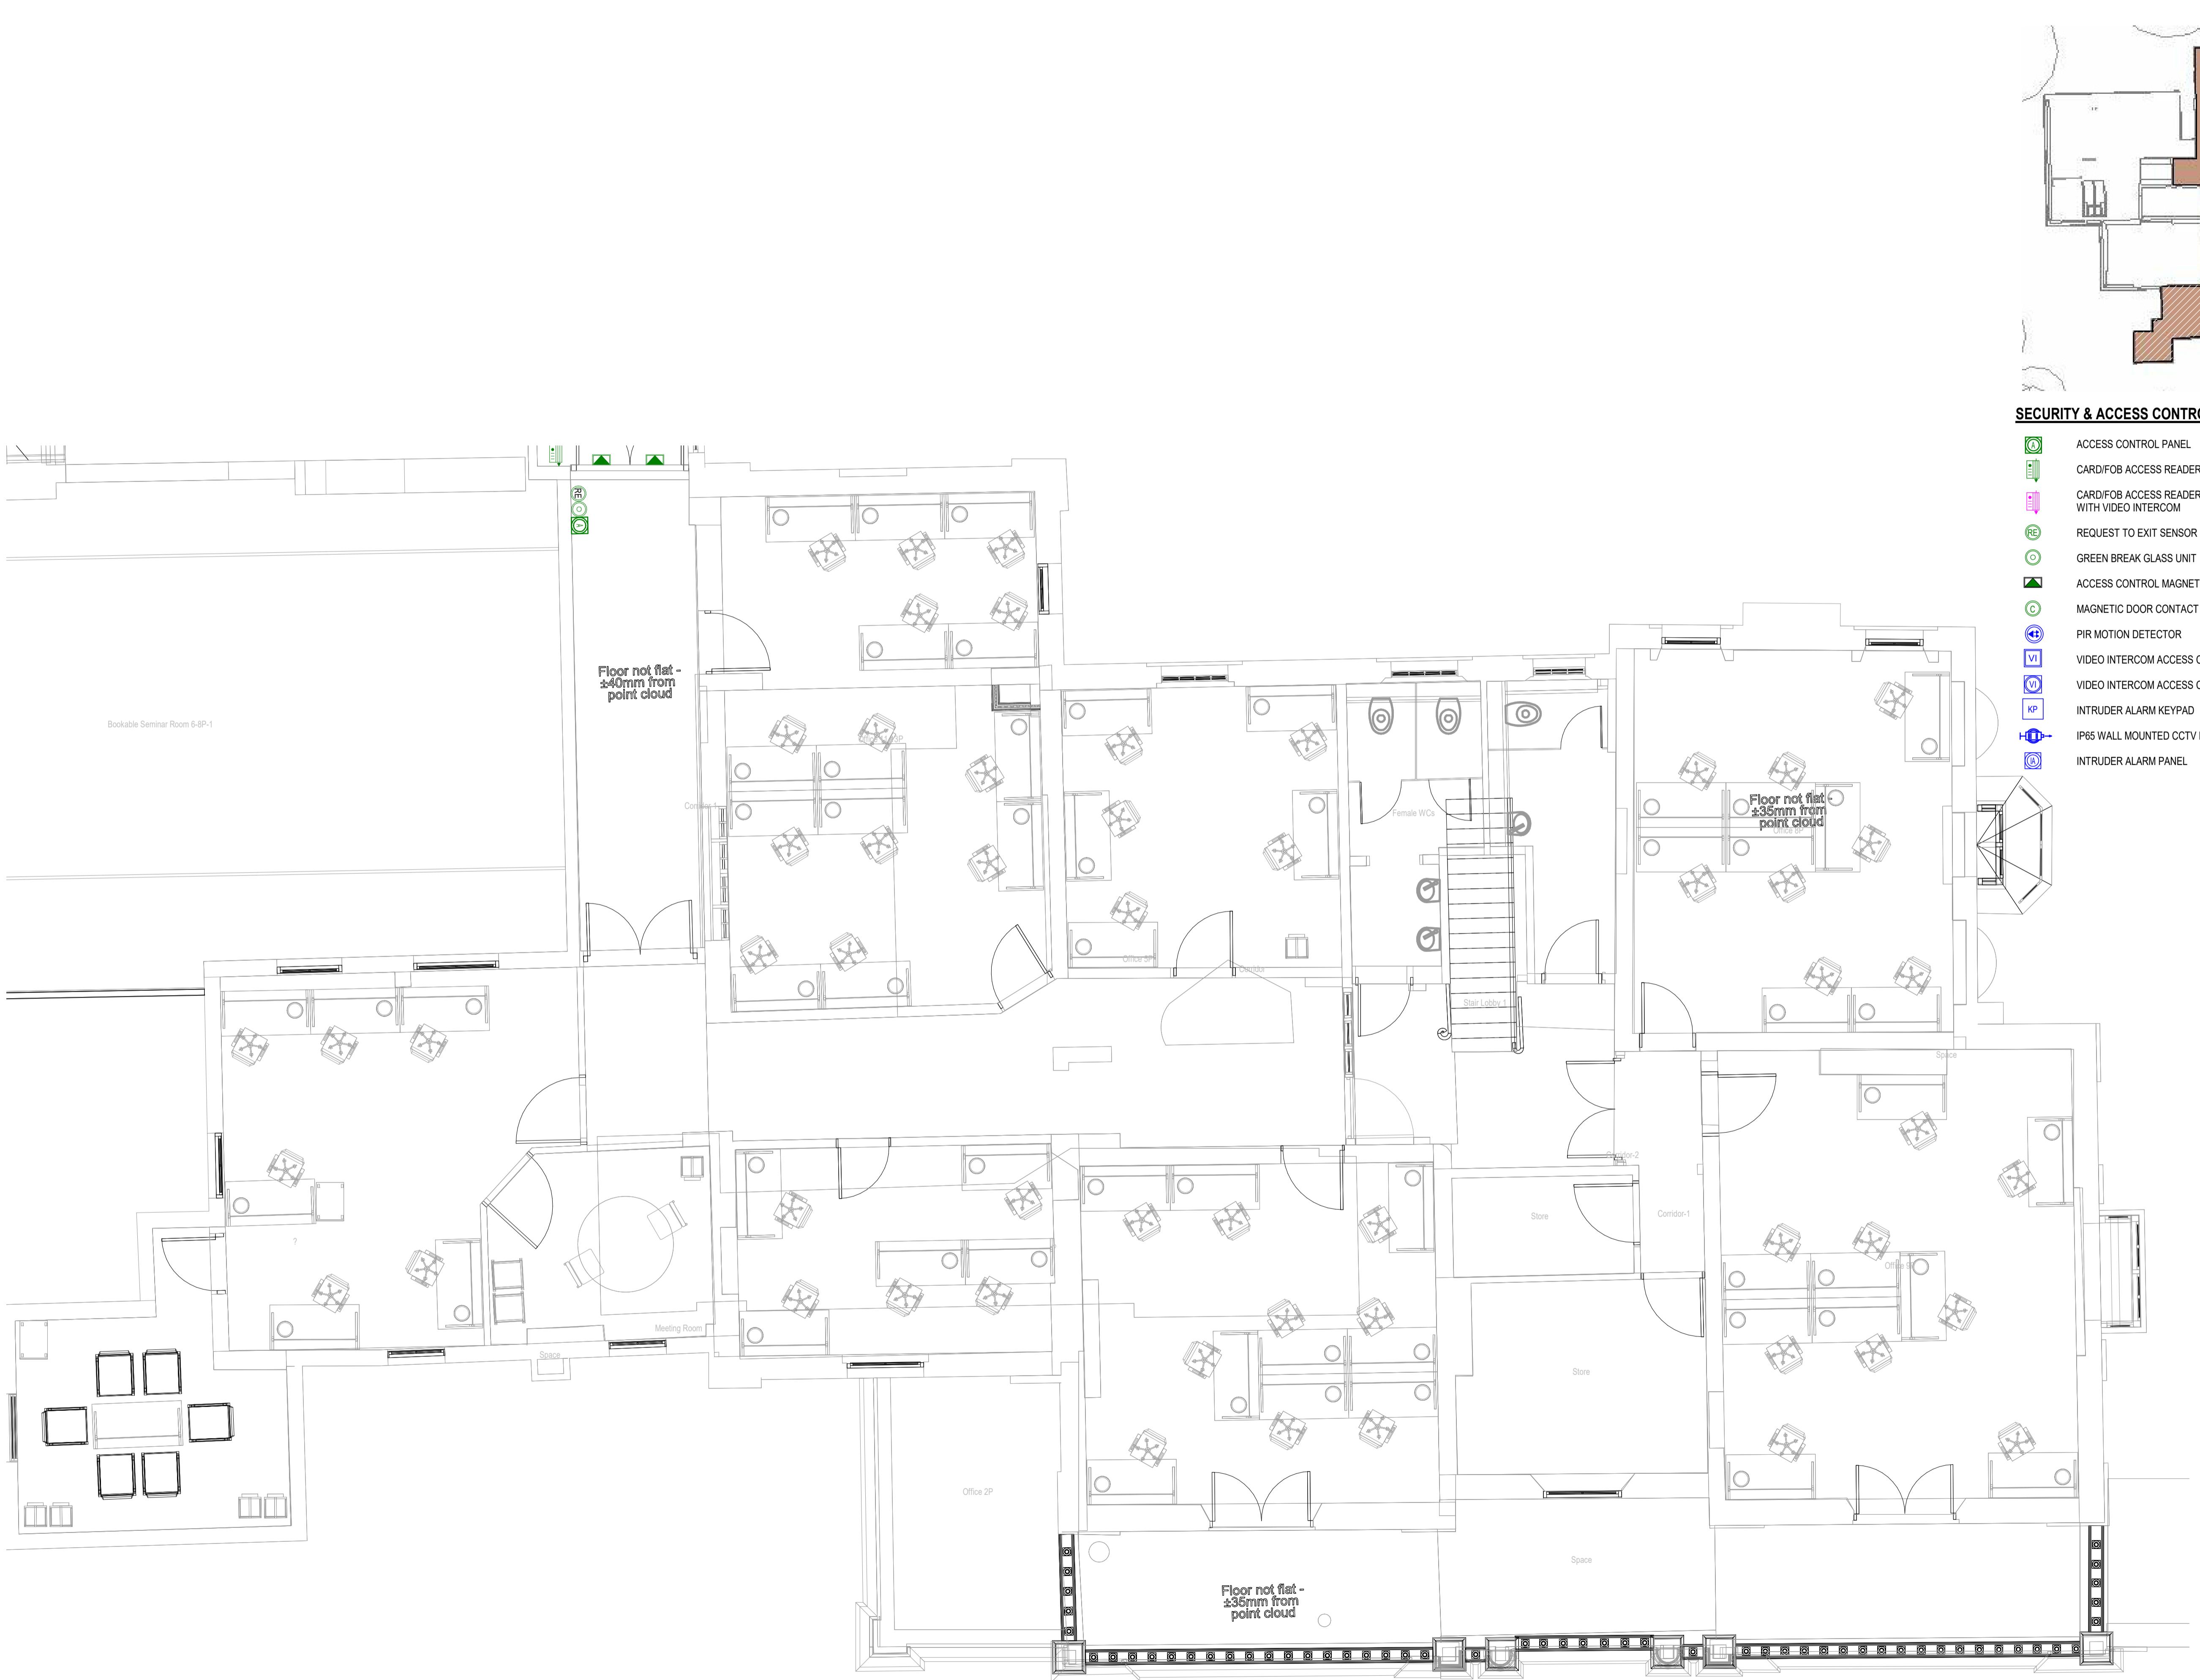

SECURITY & ACCESS CONTROL LEGEND

- ACCESS CONTROL PANEL
- CARD/FOB ACCESS READER
- CARD/FOB ACCESS READER COMPLETE WITH VIDEO INTERCOM
- REQUEST TO EXIT SENSOR - NON TOUCH
- GREEN BREAK GLASS UNIT
- ACCESS CONTROL MAGNETIC LOCK
- MAGNETIC DOOR CONTACT
- PIR MOTION DETECTOR
- VIDEO INTERCOM ACCESS CONTROL UNIT
- VIDEO INTERCOM ACCESS CONTROL PANEL
- INTRUDER ALARM KEYPAD
- IP65 WALL MOUNTED CCTV DOME CAMERA
- INTRUDER ALARM PANEL

GENERAL NOTES

1. THIS DRAWING IS NOT AN INSTALLATION DRAWING.
2. SCALED DIMENSIONS SHALL NOT BE TAKEN FROM THIS DRAWING.
3. THIS DRAWING SHALL BE READ IN CONJUNCTION WITH ALL RELEVANT REPORTS, SPECIFICATIONS, ARCHITECTURAL AND ENGINEERING DRAWINGS.
4. THIS DRAWING SHALL BE PRINTED AND READ IN COLOUR ONLY.

ELECTRICAL NOTES

1. THE CONTRACTOR SHALL BE DEEMED TO HAVE INCLUDED FOR ALL ITEMS OF EQUIPMENT INCLUDING MANUFACTURER AND TYPE AS DETAILED ON THIS DRAWING AND WITHIN THE SPECIFICATION.
2. THE CONTRACTOR SHALL BE RESPONSIBLE FOR THE CORRECT AND FINAL POSITIONING OF ALL OUTLETS TO MEET THE END USERS REQUIREMENTS THIS SHALL BE CARRIED OUT IN CONJUNCTION WITH THE PROJECT ARCHITECT. FINAL SETTING OUT EQUIPMENT SHALL BE THE ARCHITECTS ROOM LAYOUT AND REFLECTED CEILING PLANS.
3. THE CONTRACTOR SHALL CO-ORDINATE ALL ELECTRICAL SERVICES WITH MECHANICAL SERVICES AND STRUCTURE.
4. THE CONTRACTOR SHALL EMPLOY A REPRESENTATIVE OF THE SYSTEM MANUFACTURER TO TEST AND COMMISSION EACH SYSTEM UPON COMPLETION OF EACH PHASE OF WORKS.

P09	APR 24	FINAL STAGE 4 ISSUE	AT	RML
P08	MAR 24	PRELIMINARY TENDER ISSUE	LD	DR
P07	JAN 24	UPATED TO INCORPORATE ARCHITECT COMMENTS	LD	RML
P06	DEC 23	UPATED FOR LAYOUT CHANGE	LD	RML
P05	MAR 23	REVISED LAYOUT	JS	NR
P03	APR 22	FOR PLANNING AMENDMENTS	JS	NR
P02	DEC 21	SUITABLE FOR STAGE APPROVAL	BP	JP
P01	SEP 21	CHANGED TITLE BLOCK REVISIONS	ZD	NR
T02	SEP 21	TENDER ISSUE	JS	NR
T01	SEP 21	TENDER ISSUE	JS	NR
REV	DATE	DESCRIPTION	BY	VE



STAGE 4

SUITABLE FOR STAGE APPROVAL

CLIENT: THE HILLINGDON HOSPITALS NHS - FOUNDATION TRUST

PROJECT: HILLINGDON HOSPITAL - THE FURZE

DRAWING TITLE:
ELECTRICAL SERVICES
FIRST FLOOR - CLINICAL ADMIN
SECURITY, ACCESS & CCTV LAYOUT


SCALE (A): 1:50 DATE: SEP 21 BY: JG VE: NR

Proj ID: THHFP1 CPW: ZZ-01 DR: E S1001: P09

240299

LINKED FILES: THF-LDW-XX-ZZ-M3-A-0001

THHFP1-CRH-ZZ-M3-S-0001

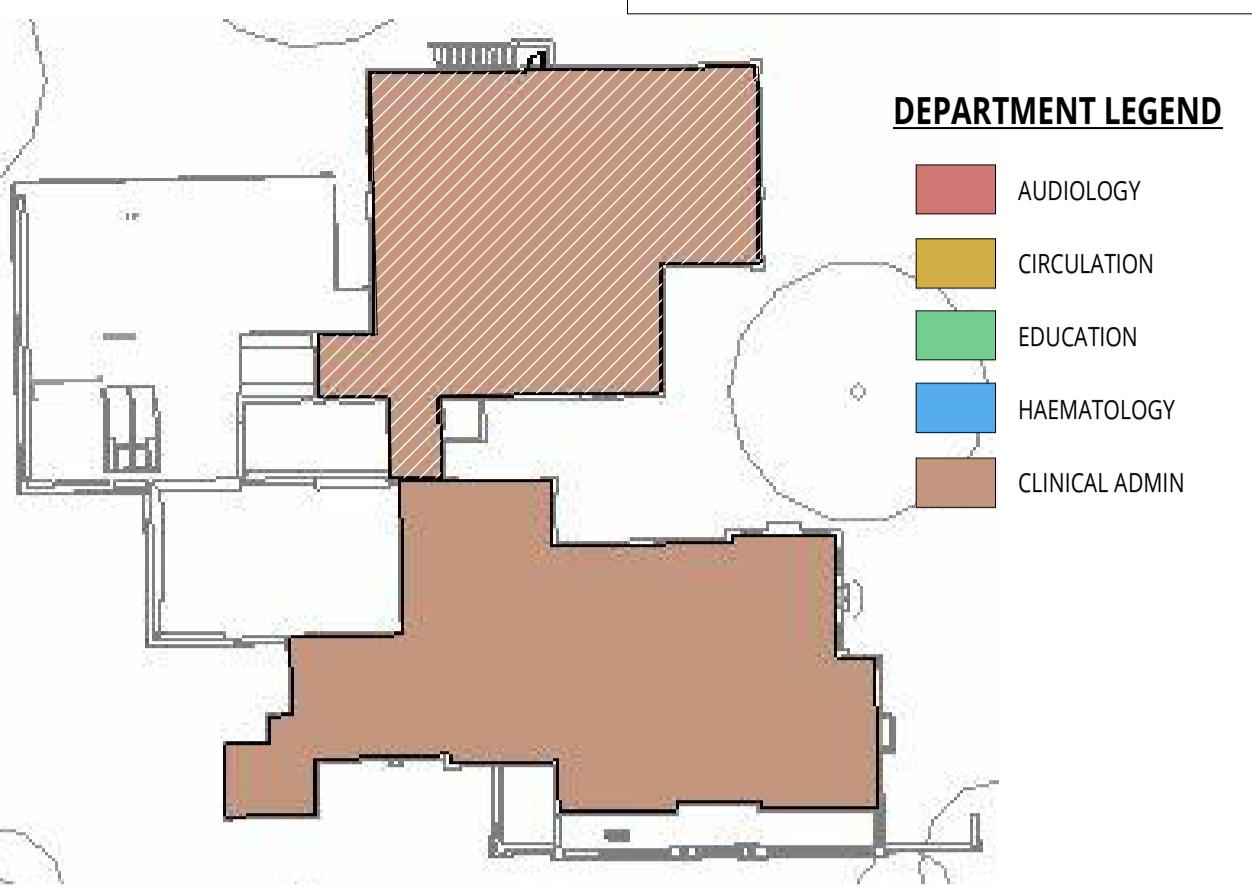

SECURITY & ACCESS CONTROL LEGEND

- ACCESS CONTROL PANEL
- CARD/FOB ACCESS READER
- CARD/FOB ACCESS READER COMPLETE WITH VIDEO INTERCOM
- REQUEST TO EXIT SENSOR - NON TOUCH
- GREEN BREAK GLASS UNIT
- ACCESS CONTROL MAGNETIC LOCK
- MAGNETIC DOOR CONTACT
- PIR MOTION DETECTOR
- VIDEO INTERCOM ACCESS CONTROL UNIT
- VIDEO INTERCOM ACCESS CONTROL PANEL
- INTRUDER ALARM KEYPAD
- IP65 WALL MOUNTED CCTV DOME CAMERA
- INTRUDER ALARM PANEL

GENERAL NOTES

- THIS DRAWING IS NOT AN INSTALLATION DRAWING.
- SCALED DIMENSIONS SHALL NOT BE TAKEN FROM THIS DRAWING.
- THIS DRAWING SHALL BE READ IN CONJUNCTION WITH ALL RELEVANT REPORTS, SPECIFICATIONS, ARCHITECTURAL AND ENGINEERING DRAWINGS.
- THIS DRAWING SHALL BE PRINTED AND READ IN COLOUR ONLY.

ELECTRICAL NOTES

- THE CONTRACTOR SHALL BE DEEMED TO HAVE INCLUDED FOR ALL ITEMS OF EQUIPMENT INCLUDING MANUFACTURER AND TYPE AS DETAILED ON THIS DRAWING AND WITHIN THE SPECIFICATION.
- THE CONTRACTOR SHALL BE RESPONSIBLE FOR THE CORRECT AND FINAL POSITIONING OF ALL OUTLETS TO MEET THE END-USERS REQUIREMENTS THIS SHALL BE CARRIED OUT IN CONJUNCTION WITH THE PROJECT ARCHITECT. FINAL SETTING OUT EQUIPMENT SHALL BE TO THE ARCHITECTS ROOM LAYOUT AND REFLECTED CEILING PLANS.
- THE CONTRACTOR SHALL CO-ORDINATE ALL ELECTRICAL SERVICES WITH MECHANICAL SERVICES AND STRUCTURE.
- THE CONTRACTOR SHALL EMPLOY A REPRESENTATIVE OF THE SYSTEM MANUFACTURER TO TEST AND COMMISSION EACH SYSTEM UPON COMPLETION OF EACH PHASE OF WORKS.

P09	APR 24	FINAL STAGE 4 ISSUE	AT	RMAL
P08	MAR 24	PRELIMINARY TENDER ISSUE	LD	RD
P08	JAN 24	UPDATED TO INCORPORATE ARCHITECT COMMENTS	RS	RMAL
P08	DEC 23	UPDATED FOR LAYOUT CHANGE	LD	RMAL
P08	MAR 23	CHANGED	ZZ	NR
P03	APR 22	FOR PLANNING AMENDMENTS	JG	NR
P02	DEC 21	SUITABLE FOR STAGE APPROVAL	BP	JP
T02	SEP 21	CHANGED TITLE BLOCK REVISIONS	ZD	NR
T01	SEP 21	TENDER ISSUE	JG	NR
REV	DATE	DESCRIPTION	BY	VE



STAGE 4

STATUS

SUITABLE FOR STAGE APPROVAL

CLIENT THE HILLINGDON HOSPITALS NHS - FOUNDATION TRUST

PROJECT HILLINGDON HOSPITAL - THE FURZE

DRAWING TITLE
ELECTRICAL SERVICES
FIRST FLOOR - CLINICAL ADMIN
SECURITY, ACCESS & CCTV LAYOUT

SCALE (A) DATE BY VE NR
1:50 SEP 21 JG NR

Proj ID Originator Volume Level Type Role Number Subtype Revision
THHFP1 CPW ZZ 01 DR E S1002 P09



CPW Project No. 240299

LINKED FILES

THHFP1-CPW-ZZ-01-DR-E-51002_S4_P09

THHFP1-CPW-ZZ-01-DR-E-51002_S4_P09

THHFP1-CPW-ZZ-01-DR-E-51002_S4_P09

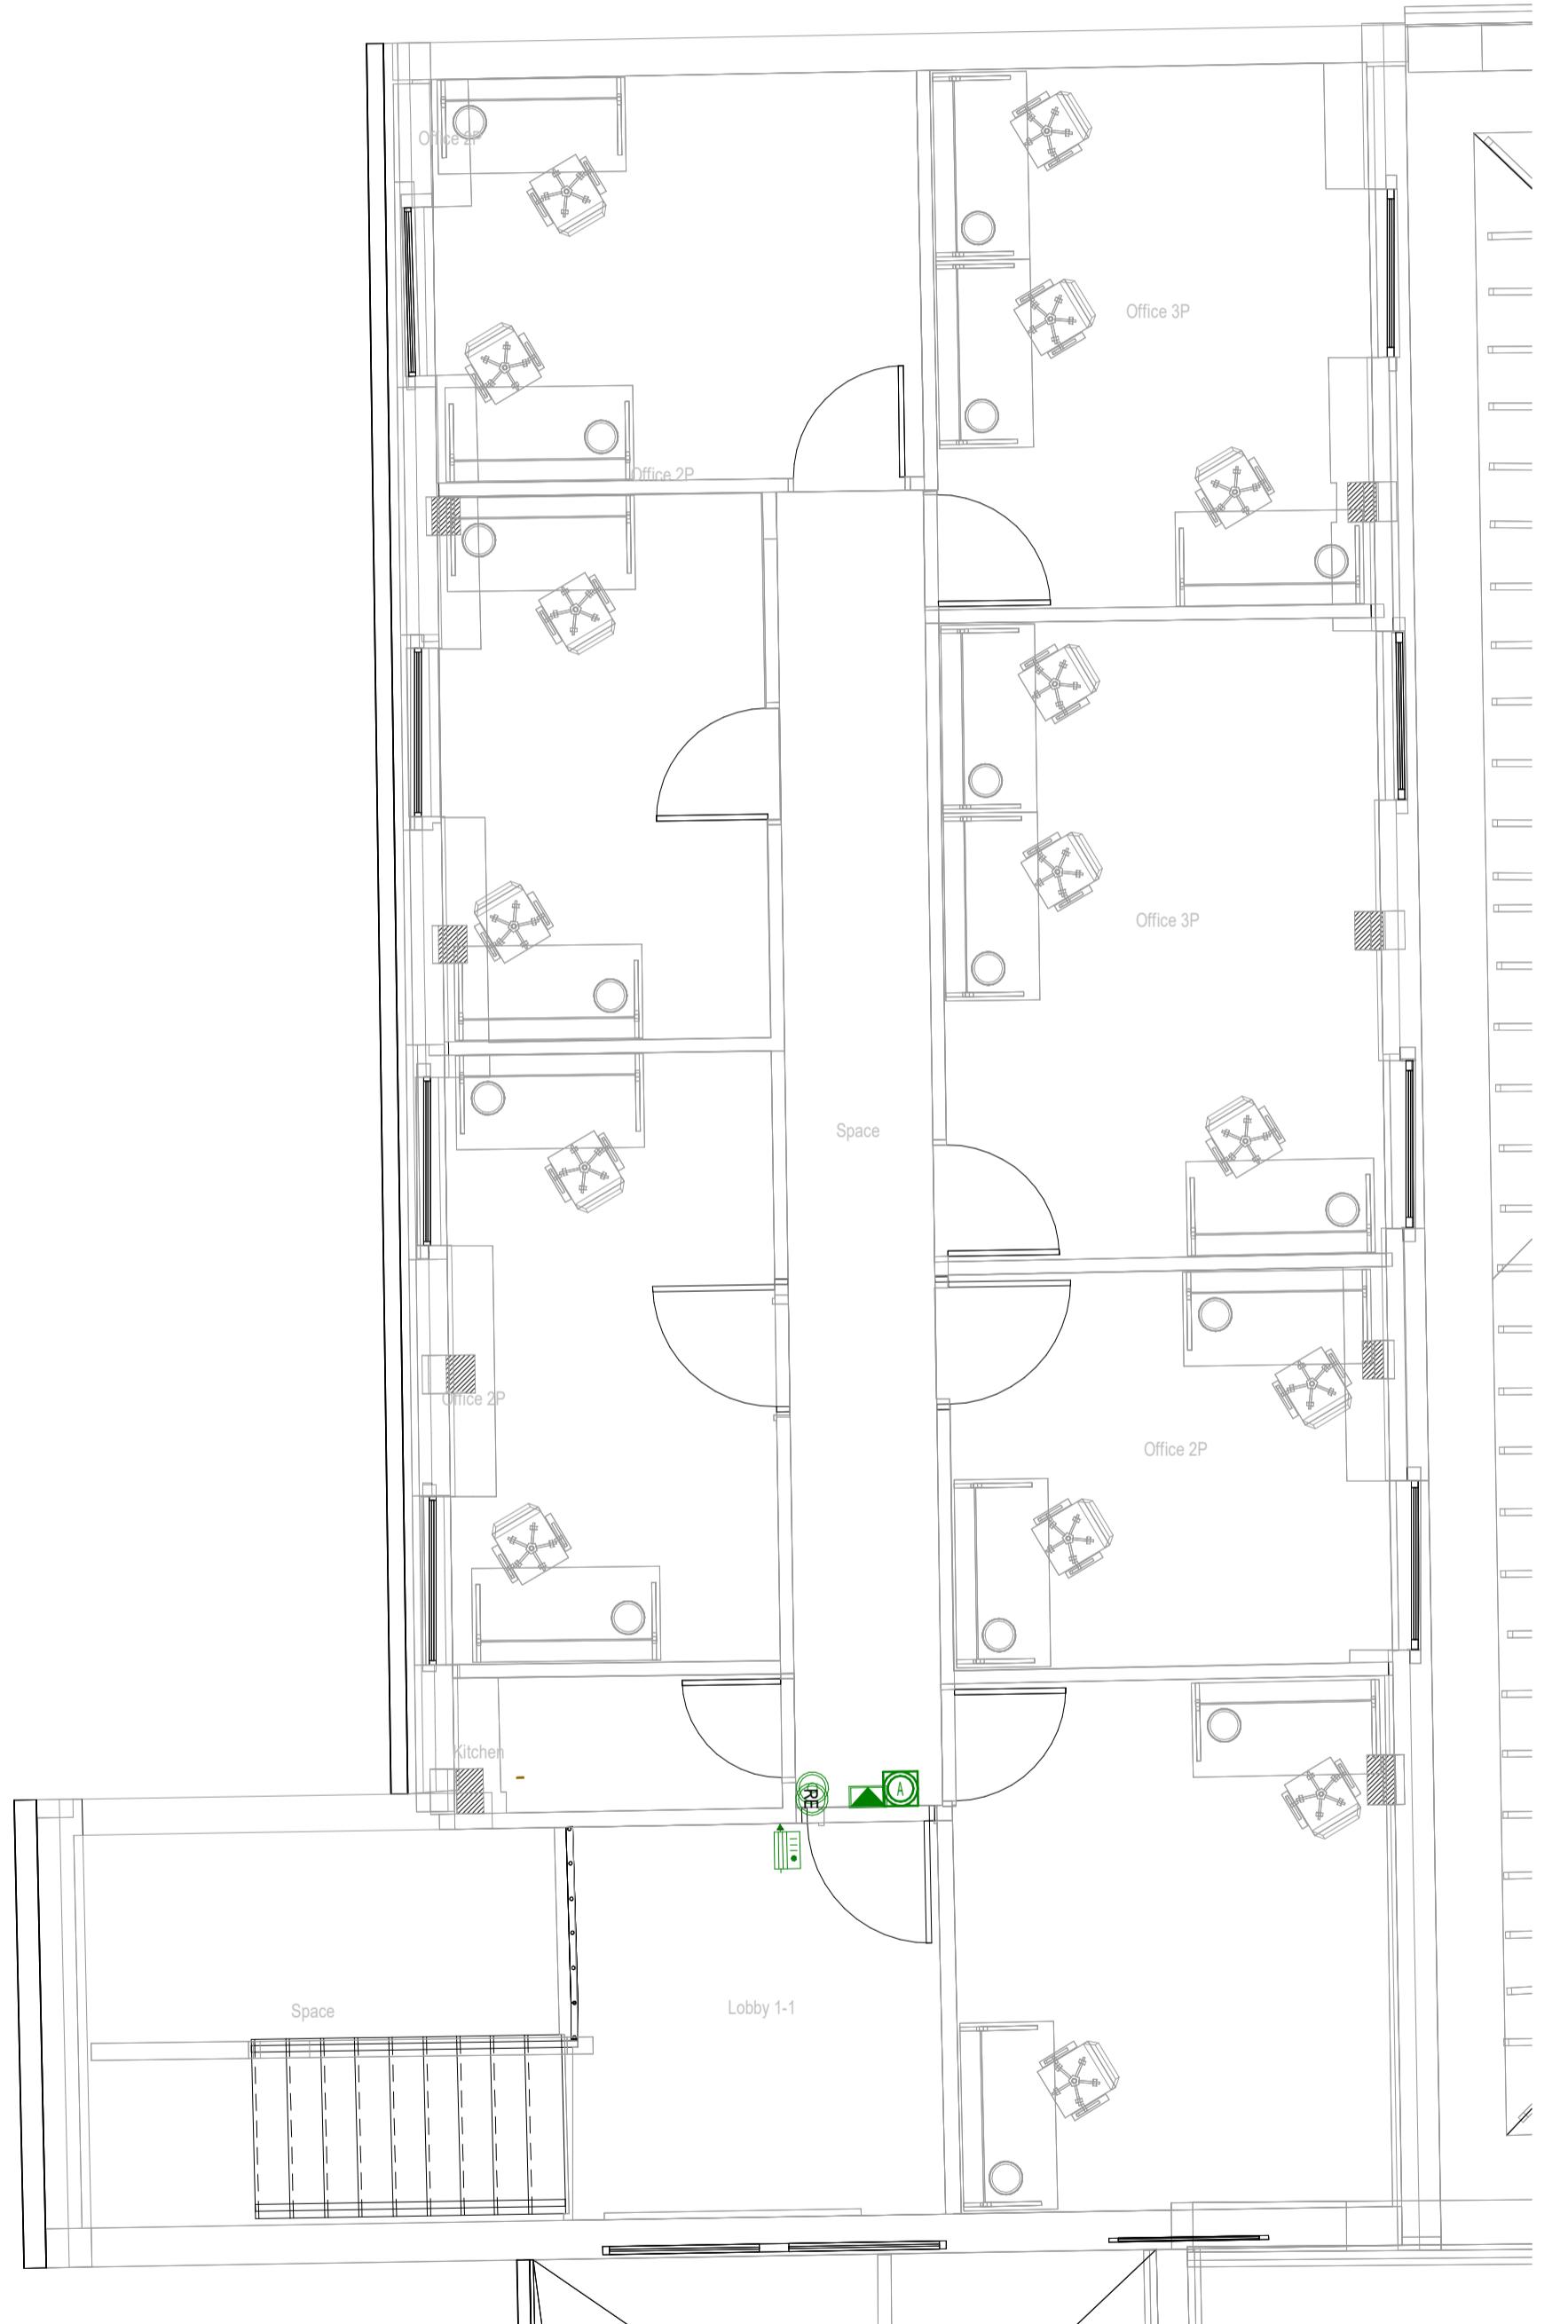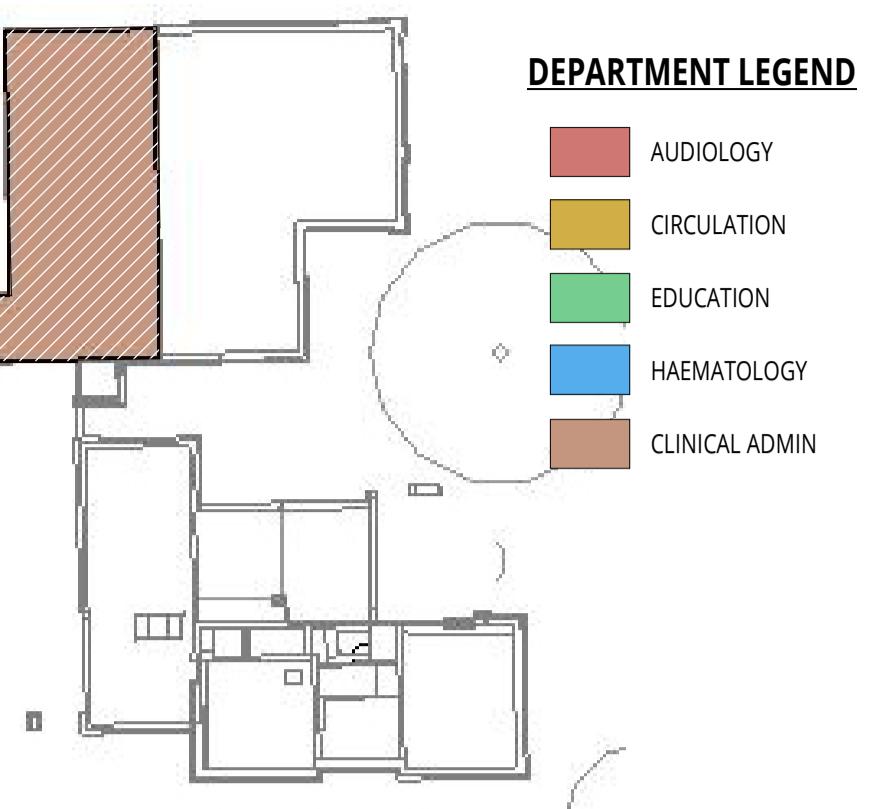

SECURITY & ACCESS CONTROL LEGEND

- ACCESS CONTROL PANEL
- CARD/FOB ACCESS READER
- CARD/FOB ACCESS READER COMPLETE WITH VIDEO INTERCOM
- REQUEST TO EXIT SENSOR - NON TOUCH
- GREEN BREAK GLASS UNIT
- ACCESS CONTROL MAGNETIC LOCK
- MAGNETIC DOOR CONTACT
- PIR MOTION DETECTOR
- VIDEO INTERCOM ACCESS CONTROL UNIT
- VIDEO INTERCOM ACCESS CONTROL PANEL
- INTRUDER ALARM KEYPAD
- IP65 WALL MOUNTED CCTV DOME CAMERA
- INTRUDER ALARM PANEL

GENERAL NOTES

- THIS DRAWING IS NOT AN INSTALLATION DRAWING.
- SCALED DIMENSIONS SHALL NOT BE TAKEN FROM THIS DRAWING.
- THIS DRAWING SHALL BE READ IN CONJUNCTION WITH ALL RELEVANT REPORTS, SPECIFICATIONS, ARCHITECTURAL AND ENGINEERING DRAWINGS.
- THIS DRAWING SHALL BE PRINTED AND READ IN COLOUR ONLY.

ELECTRICAL NOTES

- THE CONTRACTOR SHALL BE DEEMED TO HAVE INCLUDED FOR ALL ITEMS OF EQUIPMENT INCLUDING MANUFACTURER AND TYPE AS DETAILED ON THIS DRAWING AND WITHIN THE SPECIFICATION.
- THE CONTRACTOR SHALL BE RESPONSIBLE FOR THE CORRECT AND FINAL POSITIONING OF ALL OUTLETS TO MEET THE END-USERS REQUIREMENTS THIS SHALL BE CARRIED OUT IN CONJUNCTION WITH THE PROJECT ARCHITECT. FINAL SETTING OUT EQUIPMENT SHALL BE TO THE ARCHITECTS ROOM LAYOUT AND REFLECTED CEILING PLANS.
- THE CONTRACTOR SHALL CO-ORDINATE ALL ELECTRICAL SERVICES WITH MECHANICAL SERVICES AND STRUCTURE.
- THE CONTRACTOR SHALL EMPLOY A REPRESENTATIVE OF THE SYSTEM MANUFACTURER TO TEST AND COMMISSION EACH SYSTEM UPON COMPLETION OF EACH PHASE OF WORKS.

P09	APR 24	FINAL STAGE 4 ISSUE	AT	RM
P08	MAR 24	PRELIMINARY TENDER ISSUE	LD	DR
P07	JAN 24	UPATED TO INCORPORATE ARCHITECT COMMENTS	RS	RM
P06	DEC 23	UPATED FOR LAYOUT CHANGE	LD	RM
P05	MAY 23	RS	DR	NR
P03	APR 22	FOR PLANNING AMENDMENTS	JS	NR
P02	DEC 21	SUITABLE FOR STAGE APPROVAL	BP	JP
P01	SEP 21	CHANGED TITLE BLOCK REVISIONS	ZD	NR
T02	SEP 21	TENDER ISSUE	JS	NR
T01	SEP 21	TENDER ISSUE	JS	NR
REV	DATE	DESCRIPTION	BY	VE



STAGE 4

SUITABLE FOR STAGE APPROVAL

CLIENT: THE HILLINGDON HOSPITALS NHS - FOUNDATION TRUST

PROJECT: HILLINGDON HOSPITAL - THE FURZE

DRAWING TITLE: ELECTRICAL SERVICES
SECOND FLOOR - CLINICAL ADMIN
SECURITY, ACCESS & CCTV LAYOUT

SCALE (A): 1:50 DATE: SEP 21 BY: JG VE: NR

Prod ID: THHFP1 CPW: ZZ Level: 02 Type: DR Role: E Number: 51001 Subtype: Revision: P09

CPW Project No: 240299

LINKED FILES: THF-LDW-XX-ZZ-M3-A-0001

THHFP1-CRH-ZZ-M3-S-0001