

NOTES:


1. THIS DRAWING SHOWS AN INDICATIVE FIRE ALARM LAYOUT. IT IS THE RESPONSIBILITY OF THE CONTRACTOR TO ENSURE THE FINAL L2 SYSTEM IS FULLY COMPLIANT WITH BS 5839 AND ALL OTHER RELEVANT STANDARDS.
2. VOID PROTECTION AND ASSOCIATED REPEATERS SHALL BE PROVIDED BY THE CONTRACTOR FOR VOIDS GREATER THAN 800mm AND OTHER HIGH RISK AREAS.
3. THE CONTRACTOR IS TO ENSURE ALL GAS SHUT-OFF DEVICES ARE FULLY INTERFACED WITH THE FIRE ALARM SYSTEM.

FIRE ALARM LEGEND

	FIRE ALARM PANEL
	FIRE ALARM INTERFACE UNIT
	HEAT DETECTOR
	HEAT DETECTOR WITH SOUNDER
	SMOKE DETECTOR
	SMOKE DETECTOR WITH SOUNDER
	MANUAL CALL POINT C/W ALARM COVER
	WALL SOUNDER BEACON

ABBREVIATIONS

HD	HAND DRYER
WH	WATER HEATER
F	EXTRACT FAN
CL	CLEANERS SOCKET
HL	HIGH LEVEL
IAP	INTRUDER ALARM PANEL
FAP	FIRE ALARM PANEL
BLR	BOILER
FC	FUME CUPBOARD
DC	DATA CABINET

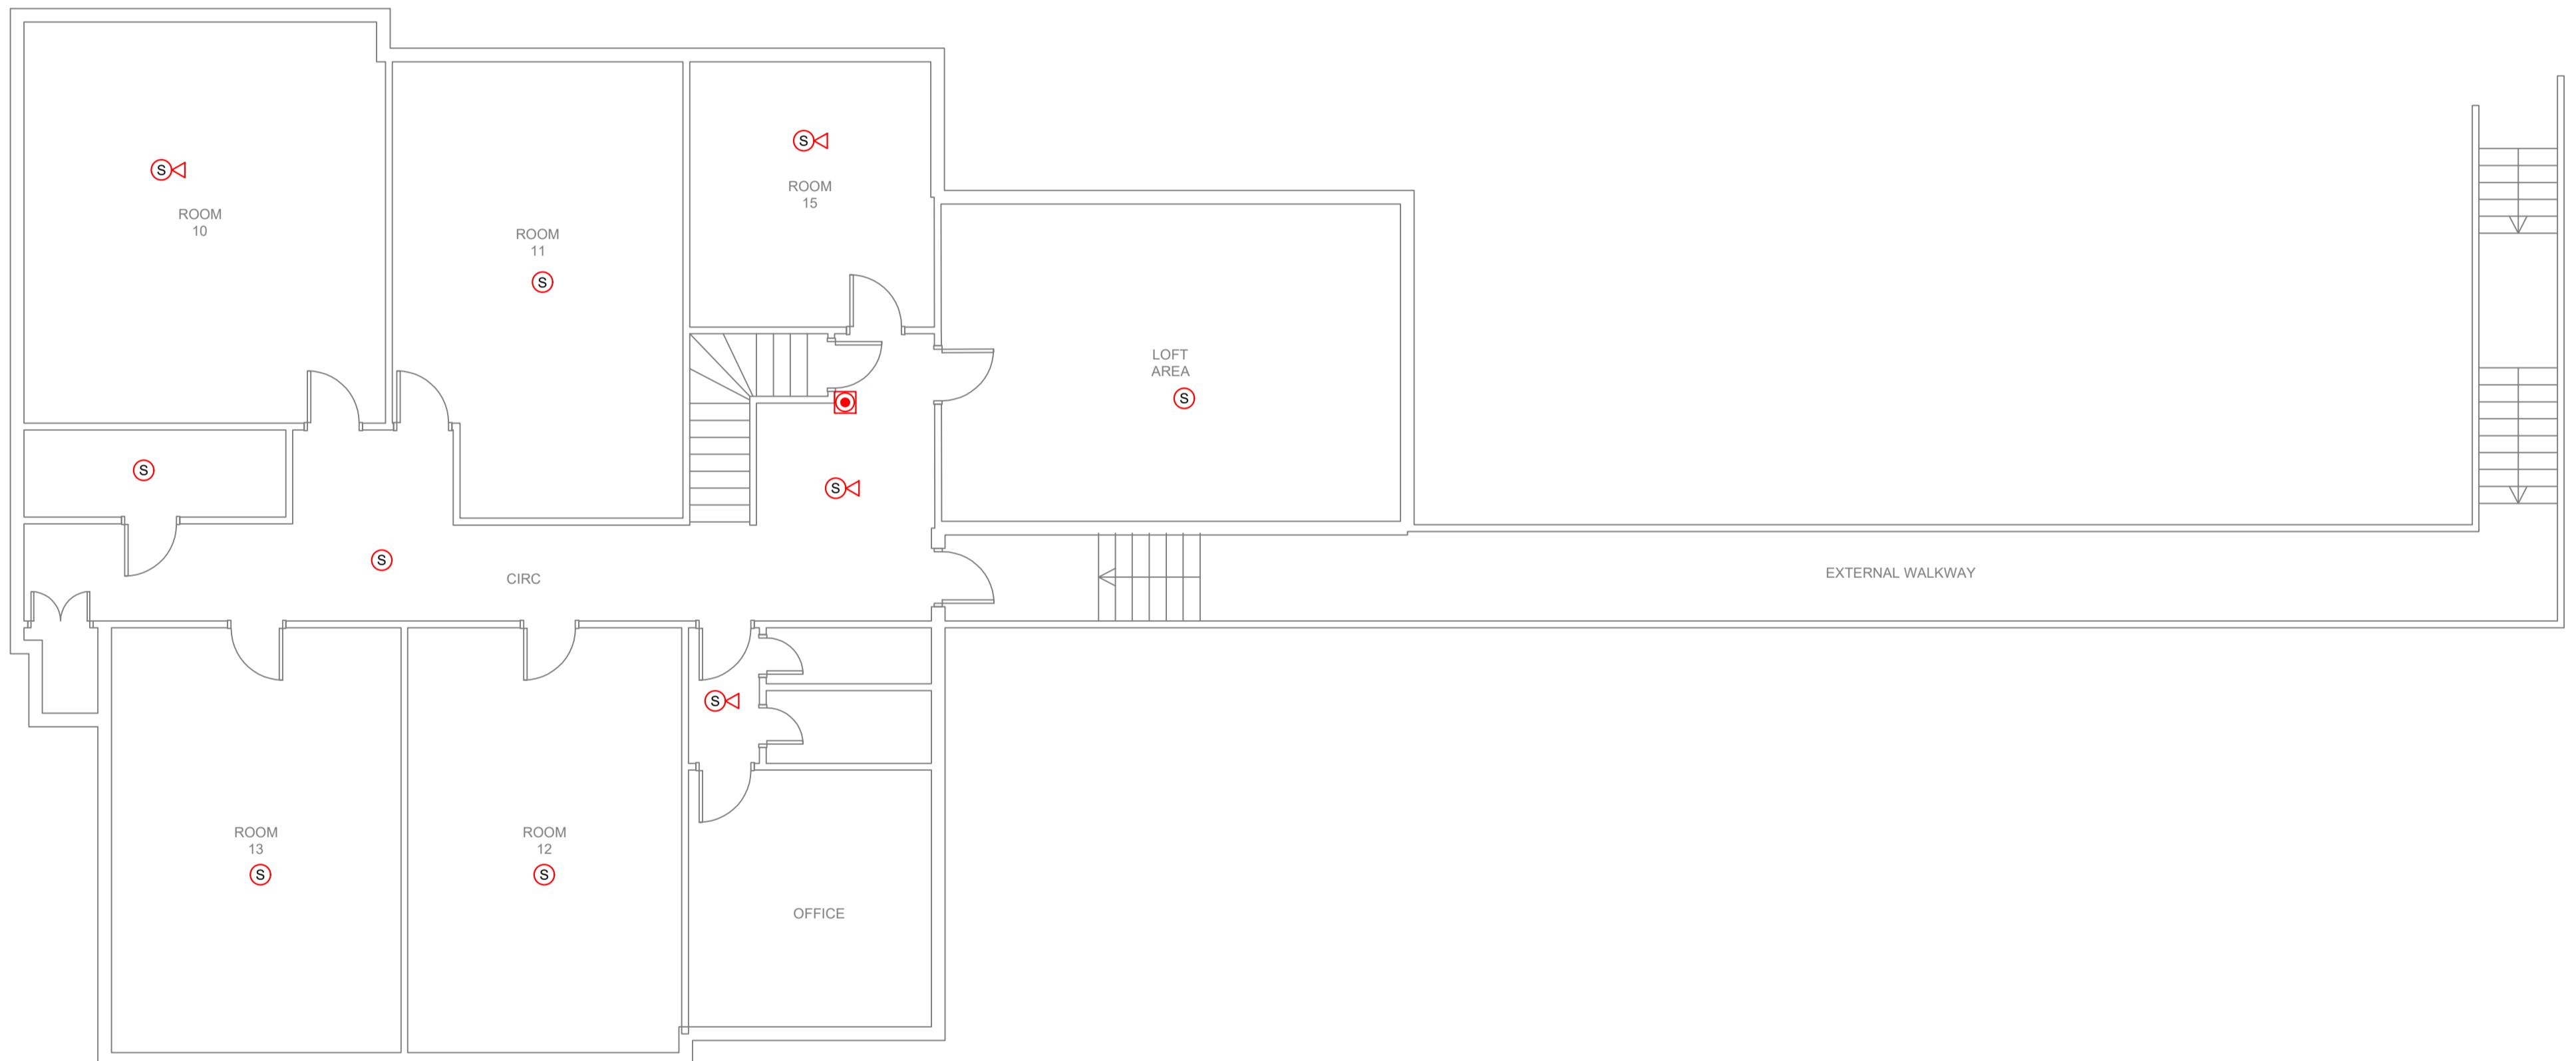

BLOCK A
SECOND FLOOR

P	30.09.22	ISSUED FOR COMMENT
REV	DATE	DESCRIPTION



8 Holgate Court, Western Road,
Romford, Essex, RM1 3JS

Tel: 01708 729070 www.davidmiles.co.uk

project
BISHOPHALT SCHOOL

title
BLOCK A - SECOND FLOOR
PROPOSED FIRE ALARM
LAYOUT

scale 1:100@A1 date SEPT 2020
drawn checked rev
PC JS P

drawing no.
7722-EFA-

PRELIMINARY