



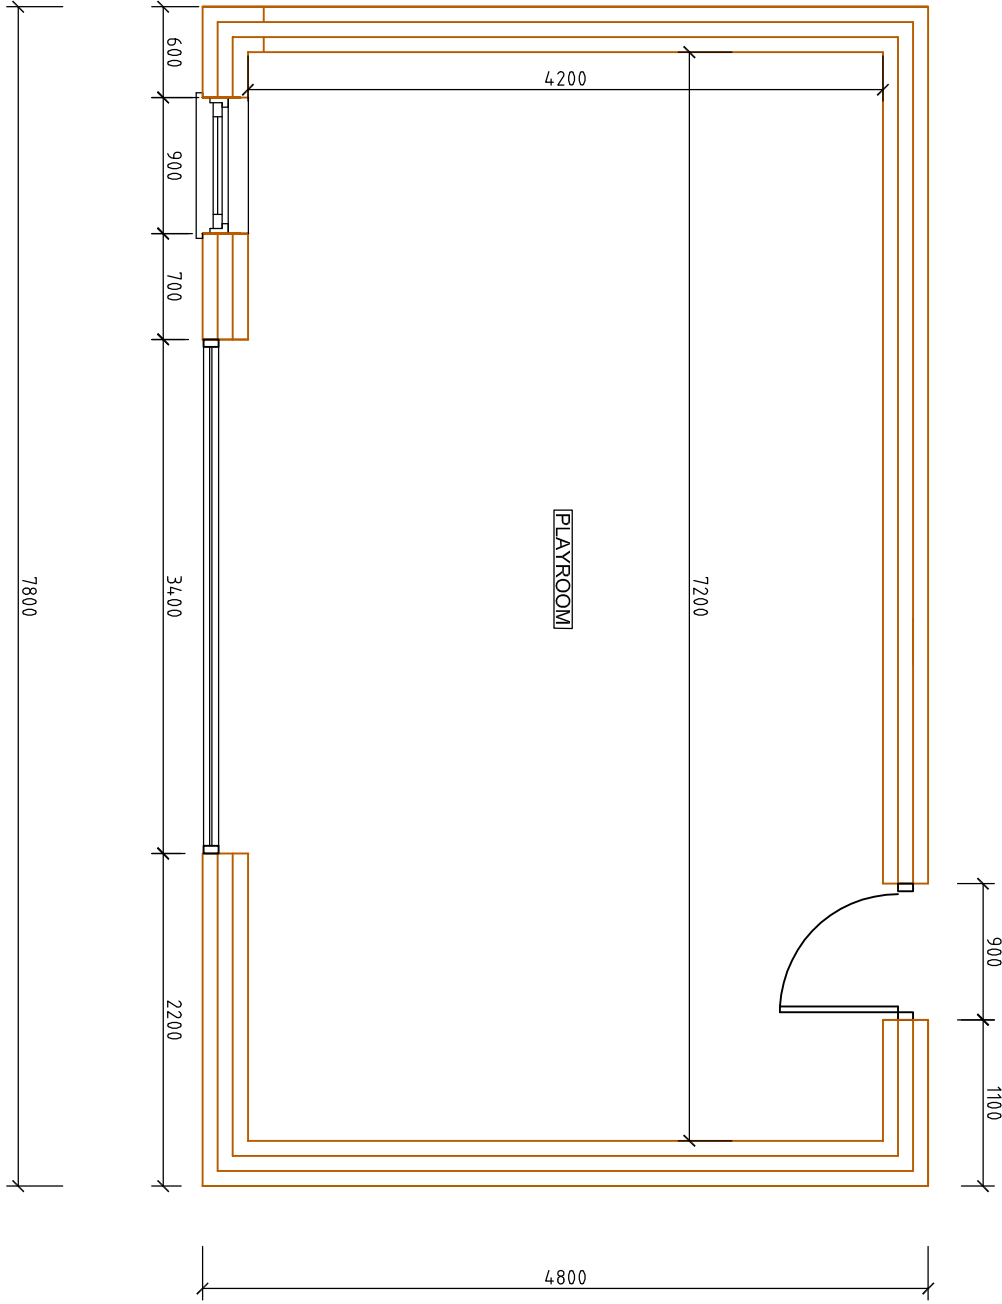

FLOOR PLAN
SCALE BAR 1:50 @ A1

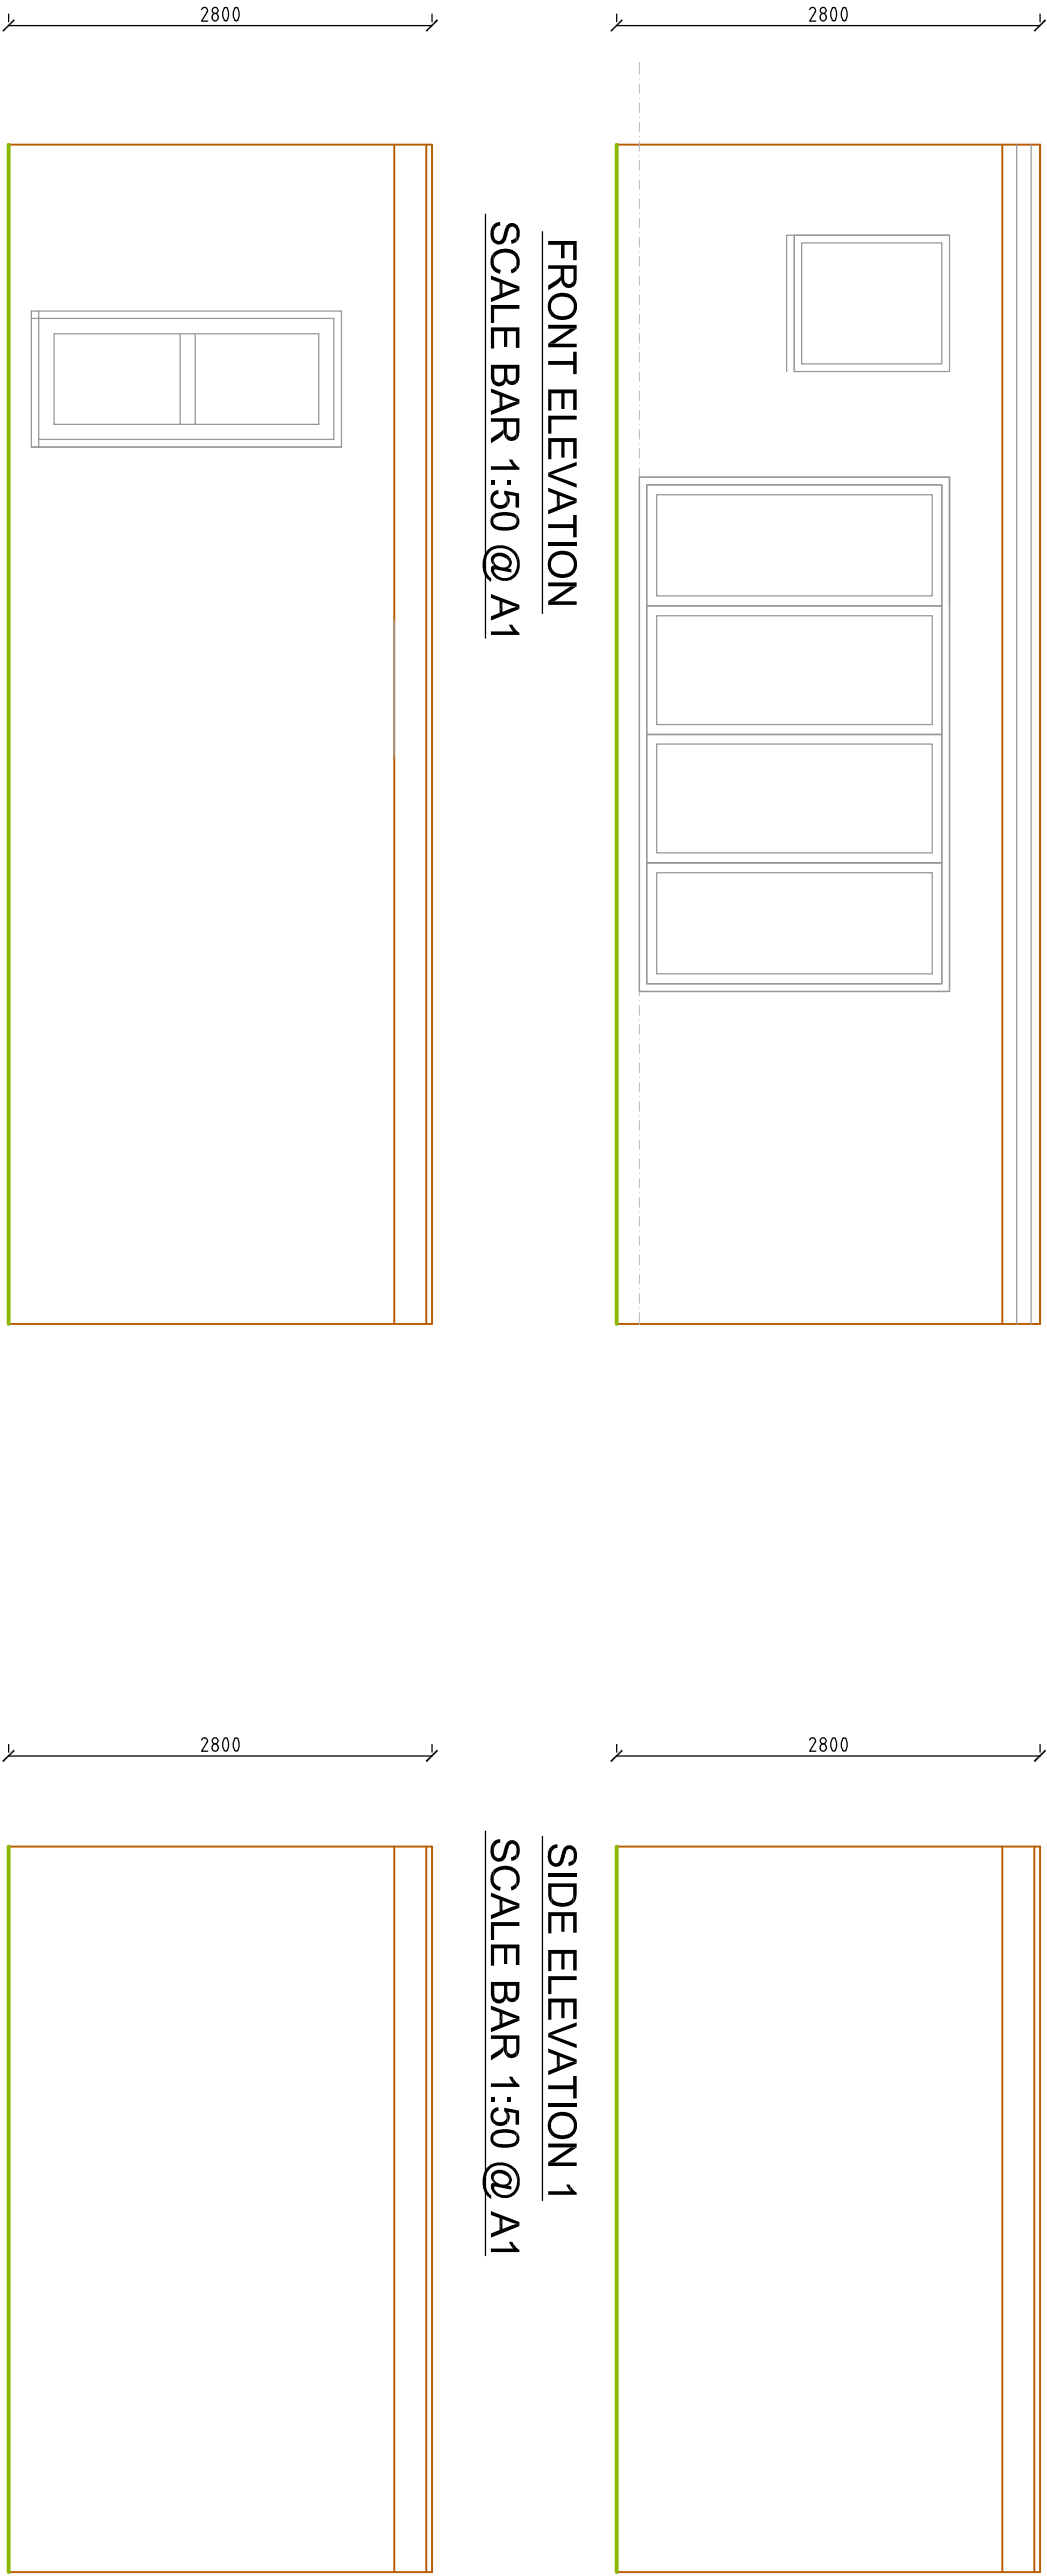

FRONT ELEVATION
SCALE BAR 1:50 @ A1

REAR ELEVATION
SCALE BAR 1:50 @ A1

SIDE ELEVATION 1
SCALE BAR 1:50 @ A1

SIDE ELEVATION 2
SCALE BAR 1:50 @ A1

Electrical Installation.

All the electrical installation is to be in full accordance with BS 7671 and with the latest addition of IEE wiring regulations, part 'P' building regs, and should be carried out in accordance with current installation techniques applicable to the material and equipment being used.

Full completion certificates to be issued by a certified electrical engineer to be provided upon completion of the electrical installation.

Note that all wiring which is covered or surrounded with thermal insulation to be de-rated in accordance with Appendix A of BRE 'Thermal Insulation'; avoiding risks 2002 edition.

All light switches are to be fitted 1200mm from finished floor level and all switched outlets to be fitted 450mm above finished floor levels.



SCALE BAR 1:50 @ A1

Greenfields
Architectural
Services

London Office: 113 Domes Road, Oxford Office: 14 Station Crescent,

Fulham London, Campton, Oxfordshire, OX18 1LE

SW6 7DU Telephone: 0207 262 4439 Telephone: 01893 697 897

Website: www.greenfieldsarchitecturalservices.co.uk

DRAWING TITLE: FLOOR PLANS

AND ELEVATIONS OUTBUILDING

SITE ADDRESS: 19 GRANGE ROAD, HAYES, UB3 2RP

SCALE: 1:50 @ A1 DRAWN BY: BG

DATE: 14.05.2019

DRAWING NO: GRANGE 01