



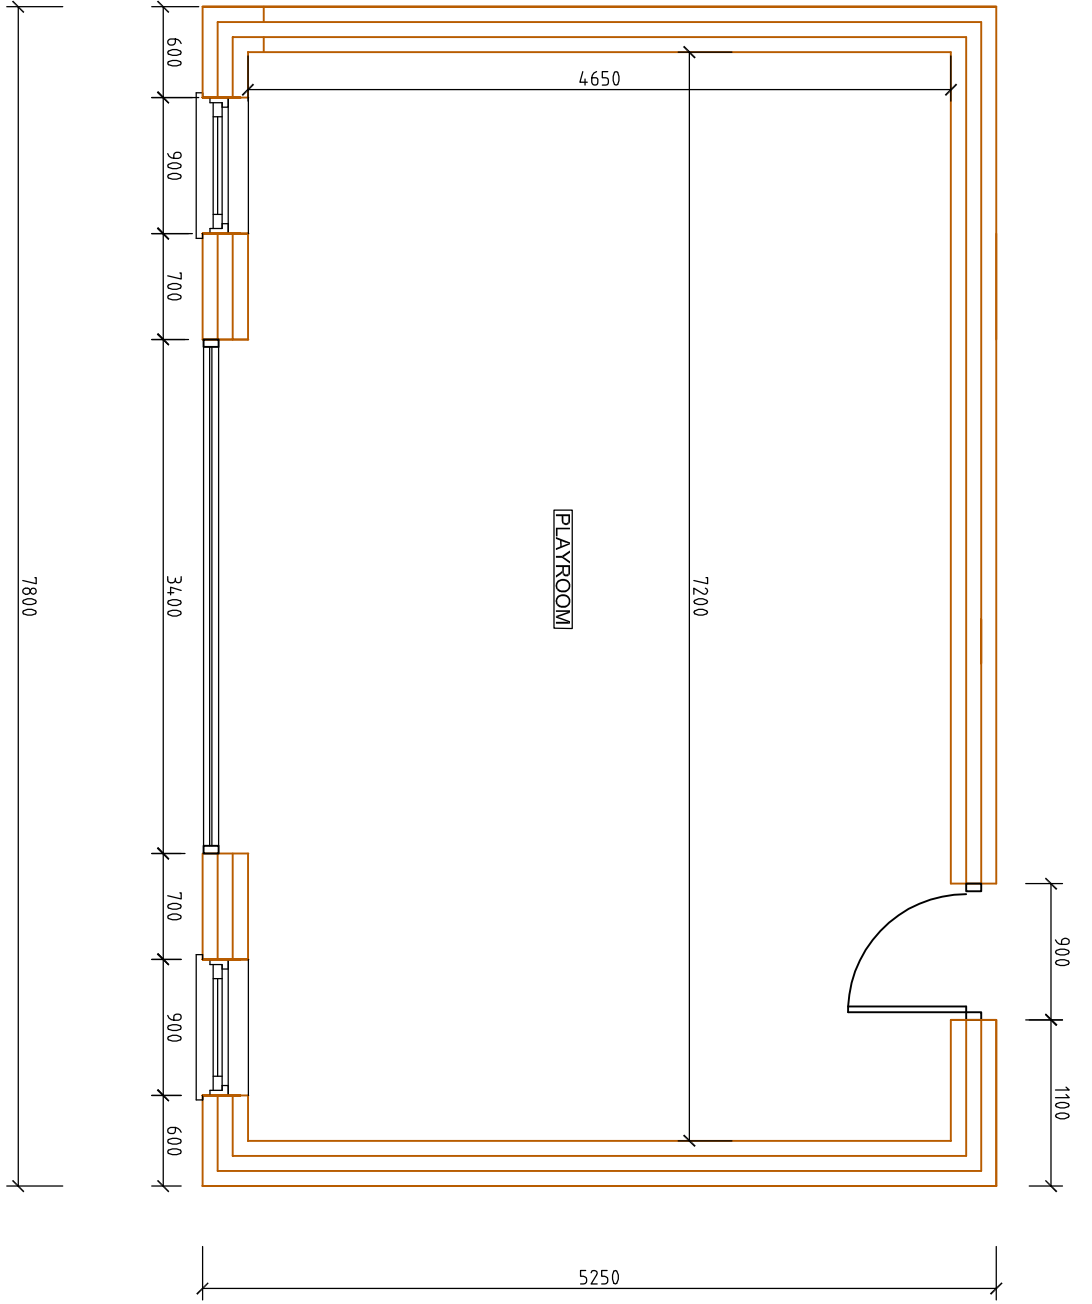

FLOOR PLAN
SCALE BAR 1:50 @ A1

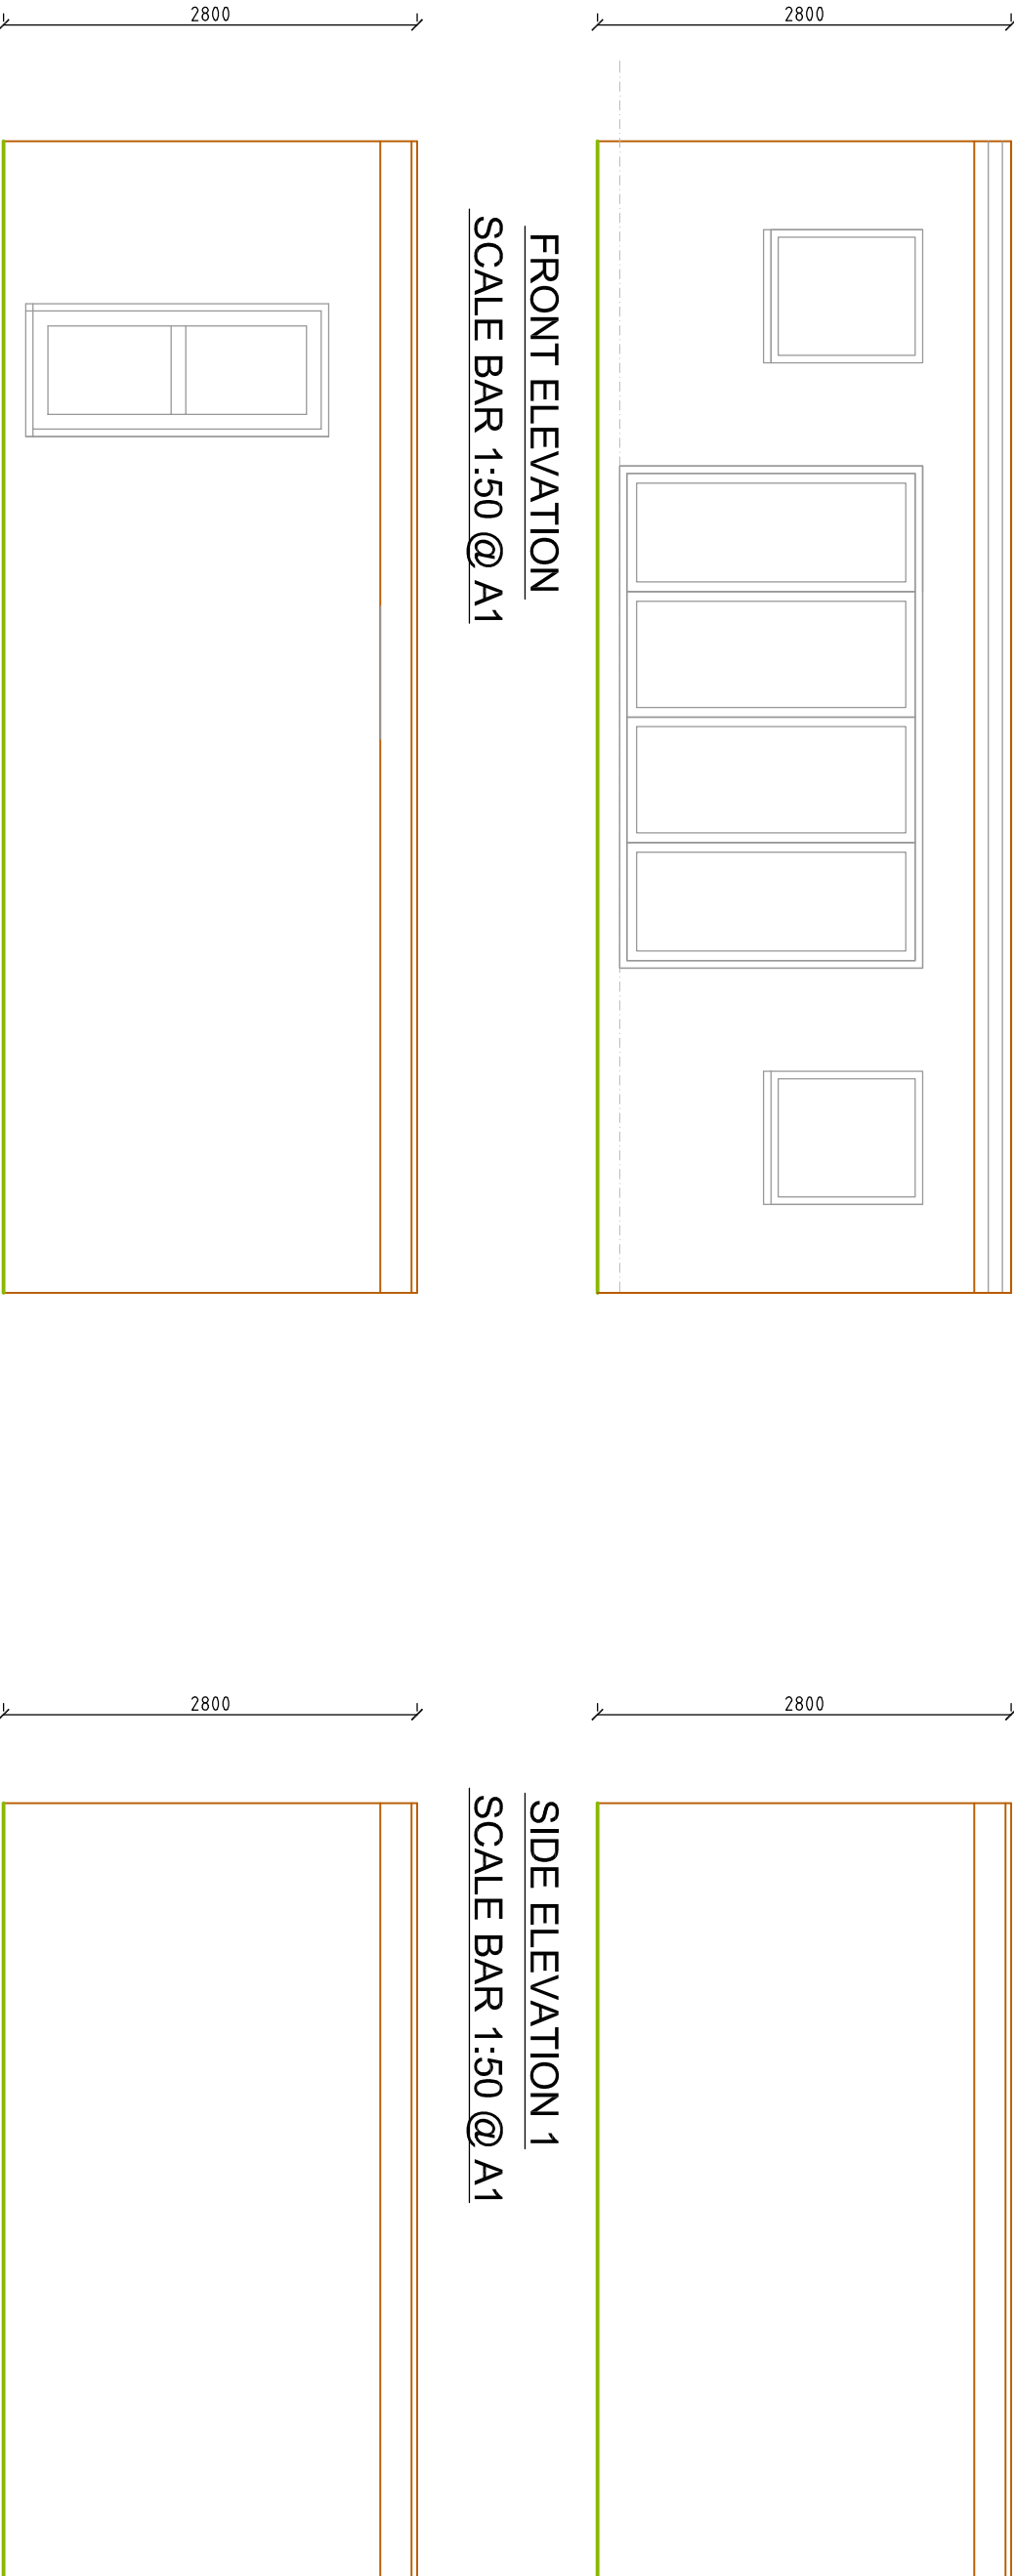

REAR ELEVATION
SCALE BAR 1:50 @ A1

 
SIDE ELEVATION 2
SCALE BAR 1:50 @ A1

Electrical Installation.

All the electrical installation is to be in full accordance with BS 7671 and with the latest addition of IEE wiring regulations, part 'P' building regs, and should be carried out in accordance with current installation techniques applicable to the material and equipment being used.
Full completion certificates to be issued by a certified electrical engineer to be provided upon completion of the electrical installation.

Note that all wiring which is covered or surrounded with thermal insulation to be de-rated in accordance with Appendix A of BRE 'Thermal Insulation'; avoiding risks 2002 edition.

All light switches are to be fitted 1200mm from finished floor level and all switched outlets to be fitted 450mm above finished floor levels.



SCALE BAR 1:50 @ A1

REVISION	DESCRIPTION	DATE	BY
1	PLANS REQUIRED AS PER CLIENT'S REQUIREMENT	14.05.2019	BB

**Greenfields
Architectural
Services**

London Office: 113 Daines Road, Oxford Office: 14 Station Crescent,

Edinam, London, Oxfordshire,

SW6 7DU, OX18 1LE

Telephone: 0207 282 4439 Telephone: 01893 697 897

Email: info@greenfieldsarchitecturalservices.co.uk

Website: www.greenfieldsarchitecturalservices.co.uk

DRAWING TITLE: FLOOR PLANS

AND ELEVATIONS OUTBUILDING

SITE ADDRESS: 19 GRANGE ROAD, HAYES, UB3 2RP

SCALE: 1:50 @ A1 DRAWN BY: BG

DATE: 14.05.2019 DRAWING NO: GRANGE 01 REVISION A