


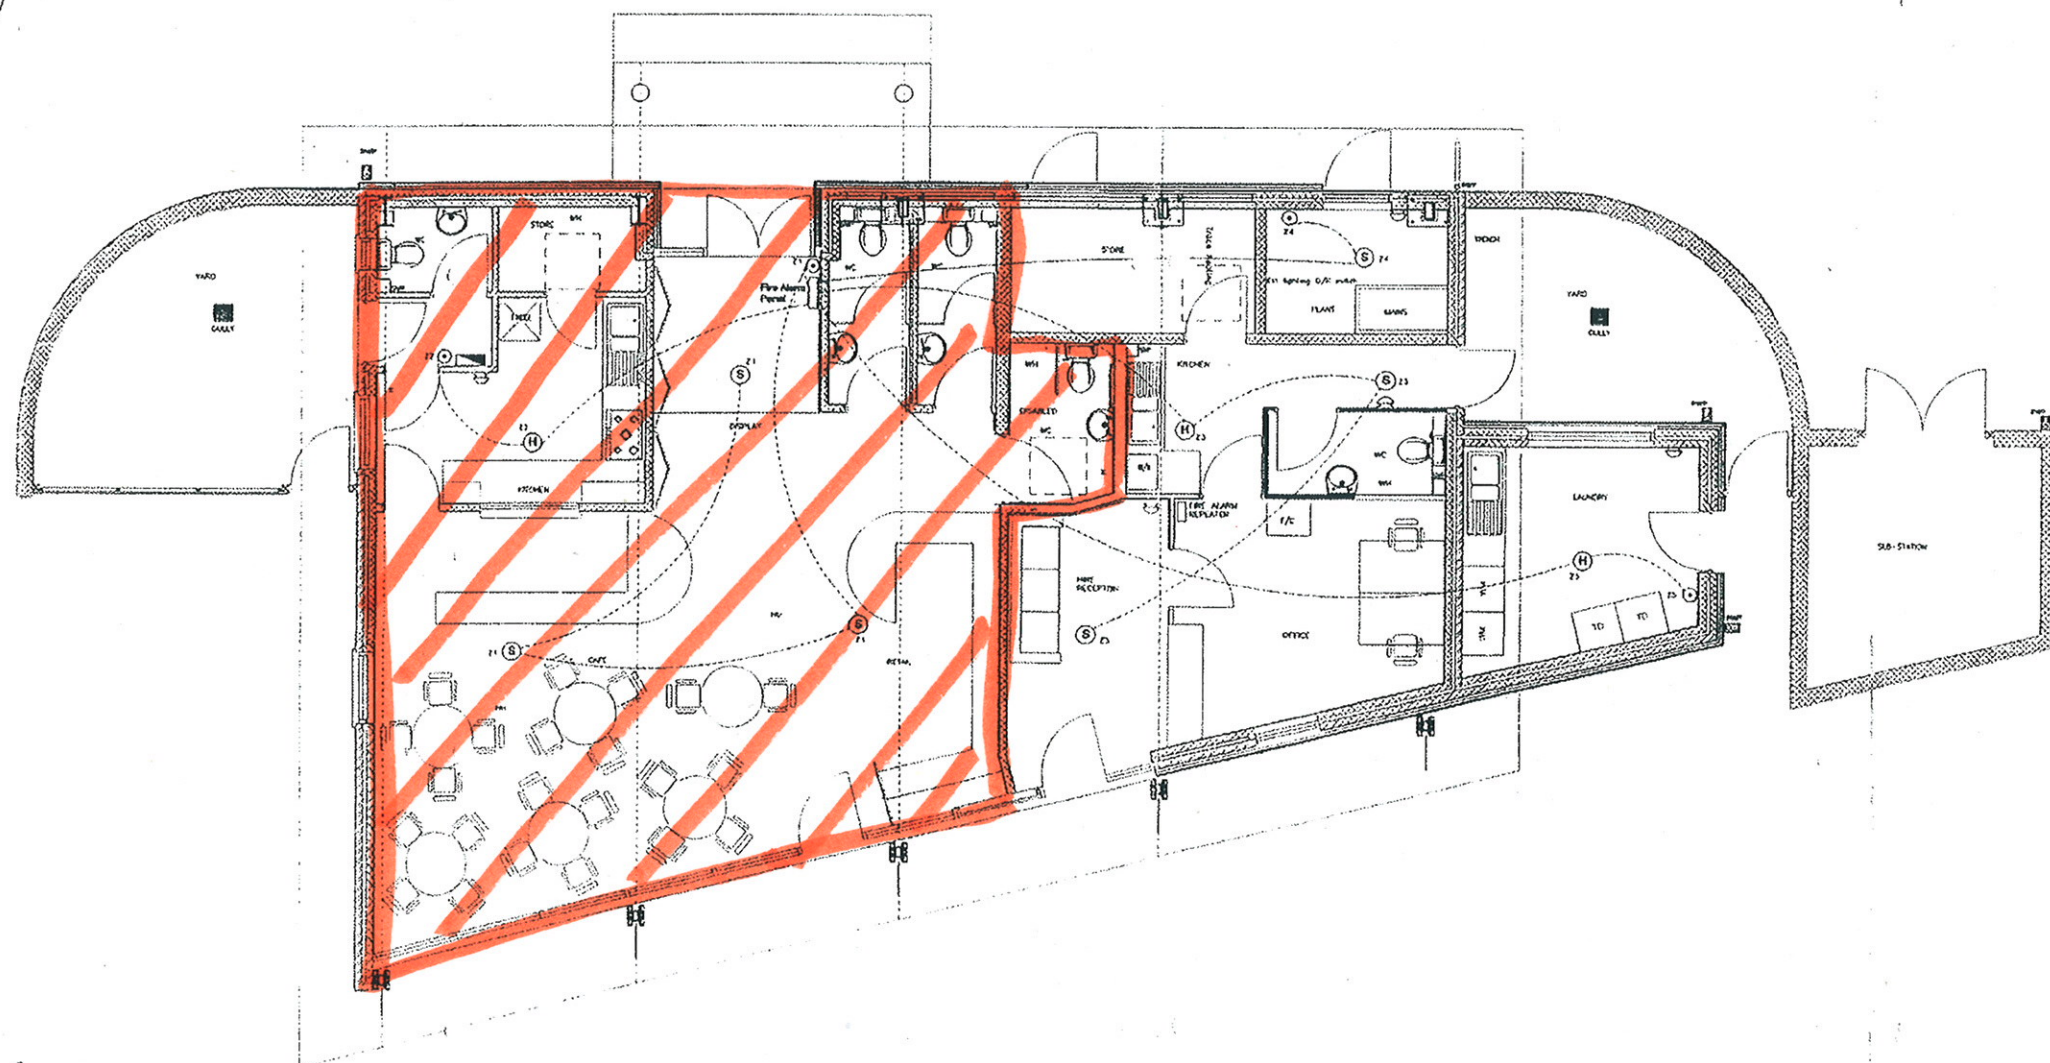

Scale 1:100 0 1m 5m 10m

Existing Class B1

LEGEND

- (S) Smoke detector
- (H) Heat detector
- (G) Fire alarm break glass
- (A) Fire alarm sounder

ZONES

- Z1 VISITOR CENTRE MAIN AREA
- Z2 KITCHEN
- Z3 HIRE CENTRE
- Z4 PLANT ROOM
- Z5 LAUNDRY

ISSUED AS FITTED	JAG	23.01.03
DESCRIPTION	DATE	DATE
AS FITTED		
LORNE STEWART BUILDING SERVICES ENGINEERS Lorne Stewart PLC Lorne Stewart House Springfield Lyons Approach Springfield, Chelmsford Essex CM2 5EY Tel: 01245 459000 Fax: 01245 465568		
PROJECT		
COWLEY PEACHEY MARINA		
CLIENT		
EDMUND NUTTALL LTD		
EXISTING FLOOR PLANS		
SCALE	1:100	
DRAWN BY	JAG	CHECKED BY RGT
DATE	15.01.03	DATE 22.01.03
DRAWING NUMBER	63065-E-007	REVISION
DRAWING SIZE	A1	0
TET: 01245 465568		