


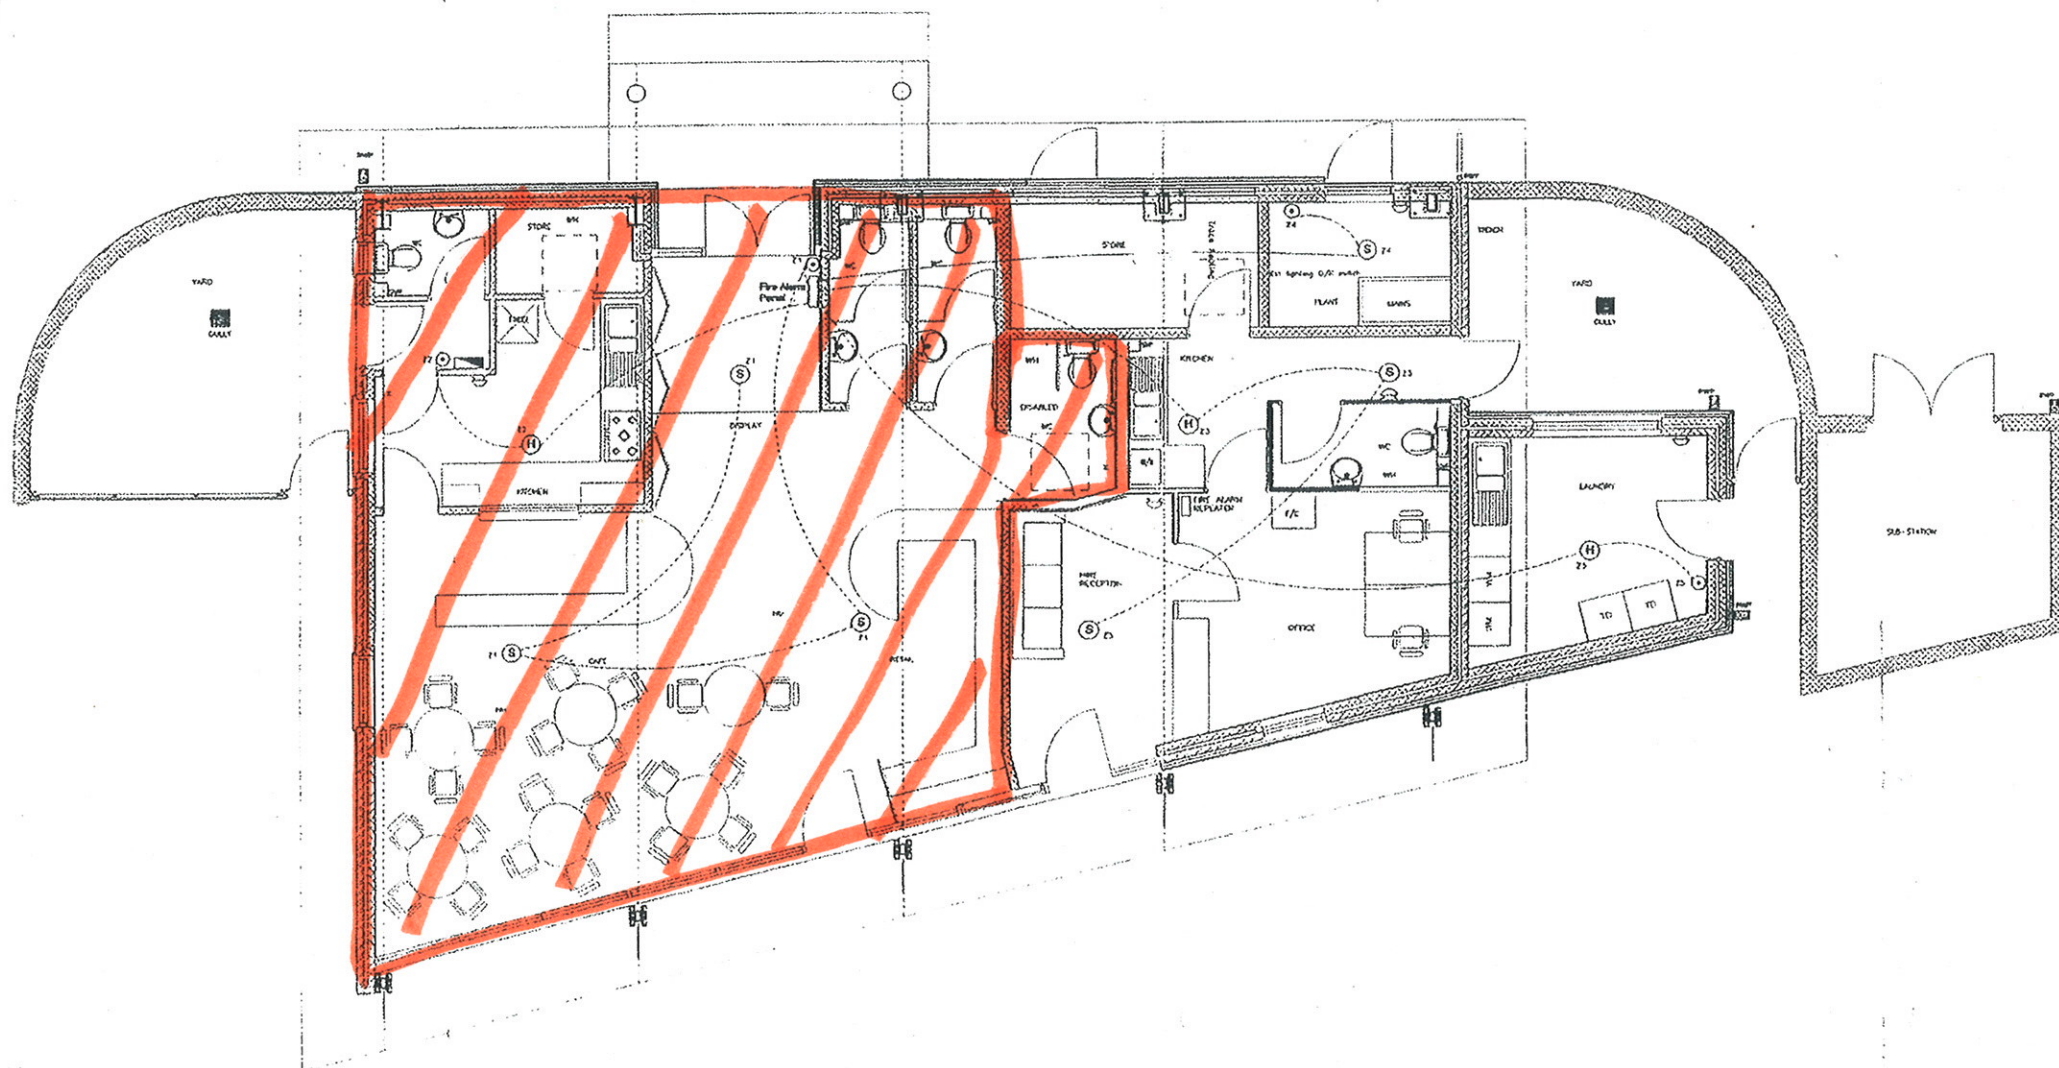

Scale 1:100 0 1m 5m 10m

Proposed Class D2

- LEGEND**
- (S) Smoke detector
 - (H) Heat detector
 - (G) Fire alarm break glass
 - (A) Fire alarm sounder

- ZONES**
- Z1 VISITOR CENTRE MAIN AREA
 - Z2 KITCHEN
 - Z3 HIRE CENTRE
 - Z4 PLANT ROOM
 - Z5 LAUNDRY

ISSUED AS FITTED	J.A.G.	23.01.03
REV	DESCRIPTION	DATE
STATUS	AS FITTED	
LORNE STEWART BUILDING SERVICES ENGINEERS Lorne Stewart PLC Lorne Stewart House Springfield Lyons Approach Springfield, Chesham Essex CM2 5EY Tel: 01245 459000 Fax: 01245 465560		
PROJECT COWLEY PEACHEY MARINA		
CLIENT EDMUND NUTTALL LTD		
EXISTING FLOOR PLANS		
SCALE 1:100		
DRAWN BY J.A.G.	CHECKED BY R.G.T.	
DATE 15.01.03	DATE 22.01.03	
DRAWING NUMBER 63065-E-007		REVISION 0
DRAWING SIZE A1 FOLIO NUMBER 1		