


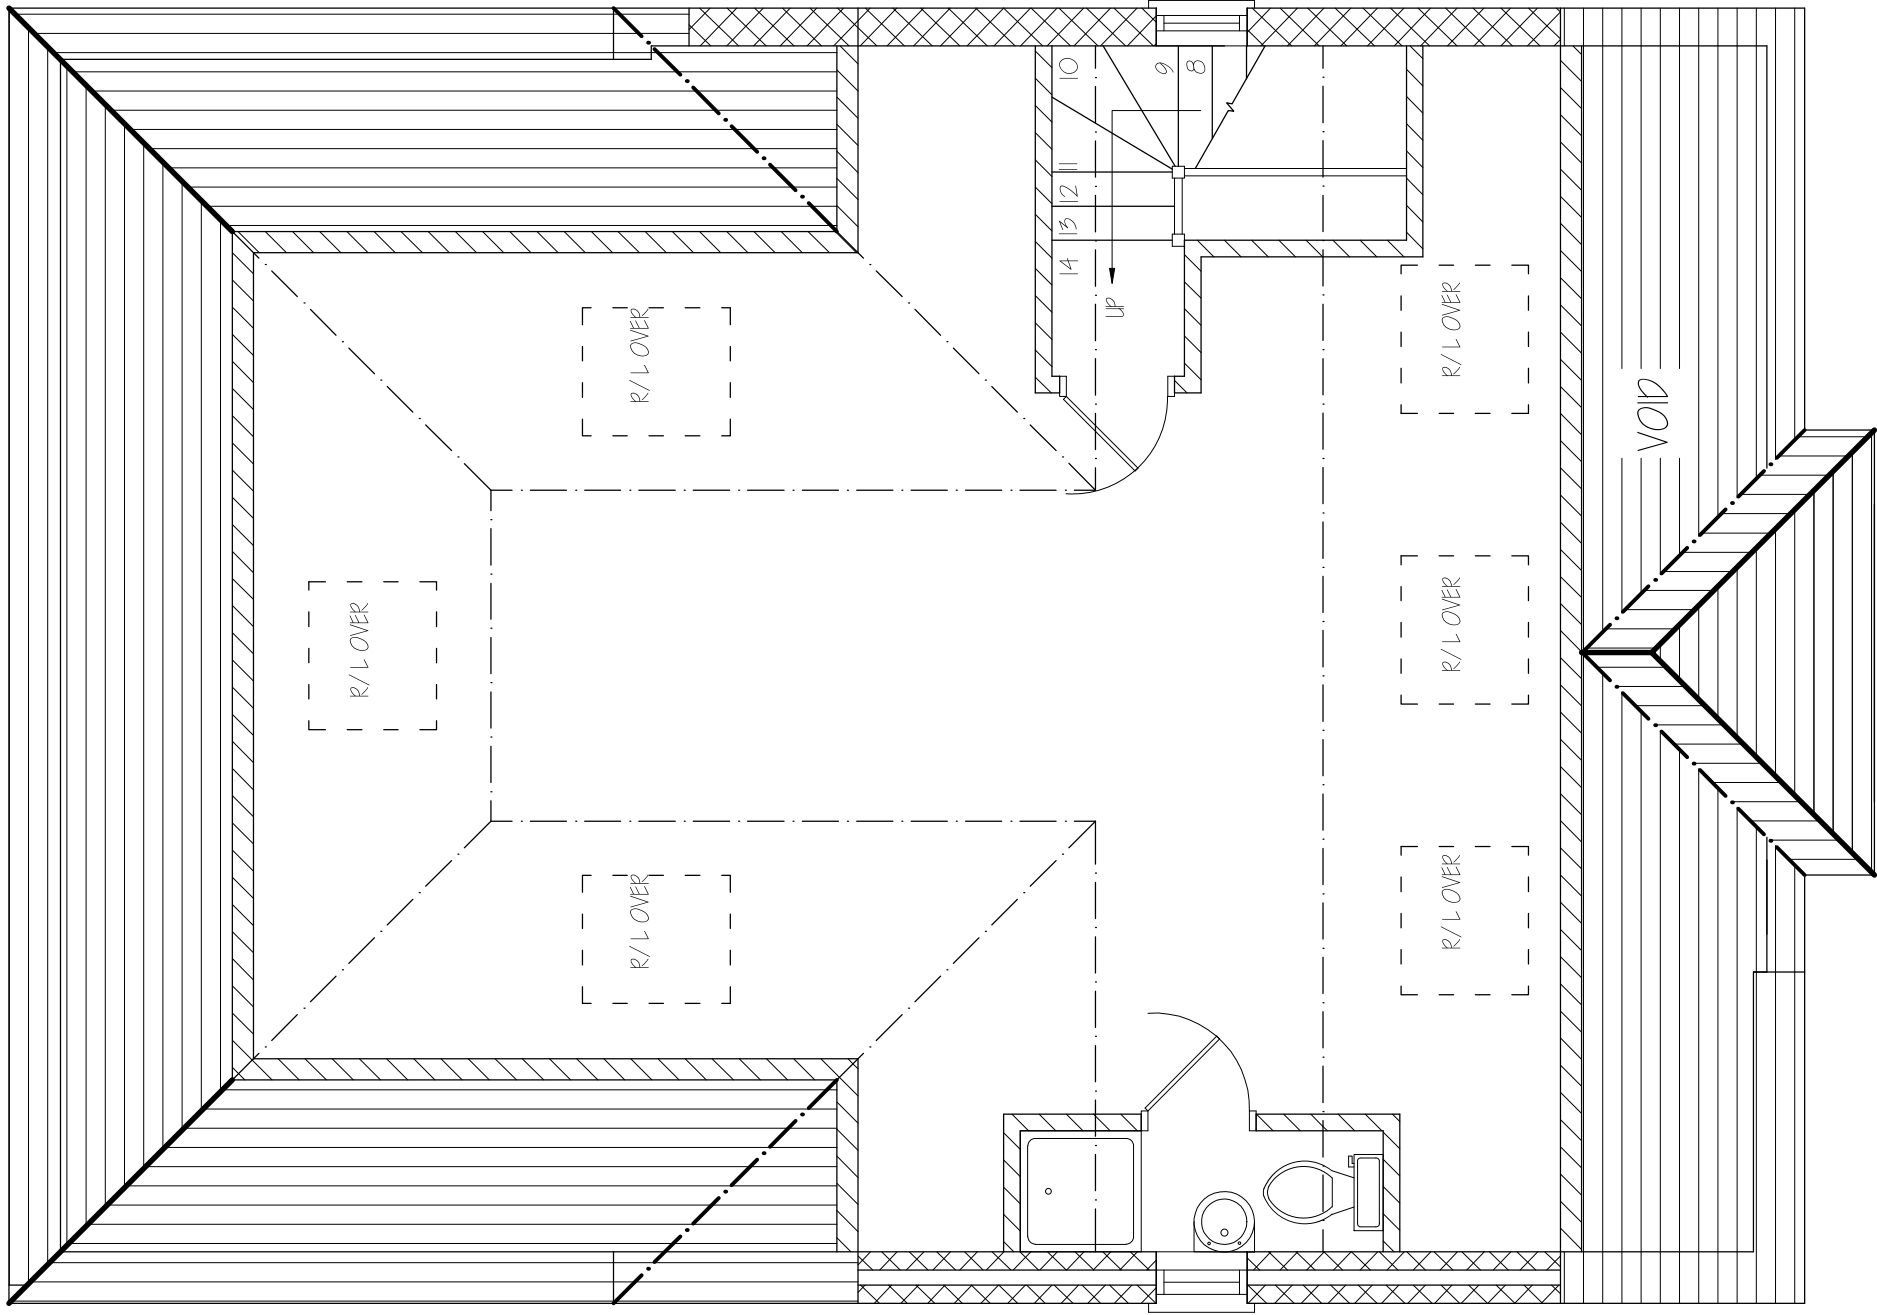

Nigel Fallon, B.Sc. (Hons)MBEng. **07768-408525**
Planning & Development Consultant, Building Engineer.

349, Chartridge Lane,
Chesham, HP5 2SH.

ADDRESS:
73 THORNHILL ROAD,
ICKENHAM, LB10 8SH.

DRAWING TITLE: PROPOSED SECOND FLOOR PLAN

NO. - 06 REV:

DATE: 20 / 01 / 2022

DWG. PAPER SIZE: A3

SCALE - 1:50

