


A	S651 + X799 + X805 Wall mounted IP66 LED downlight 7.1W 577lm 3000K CRI80 - Asymmetrical side optic On/off integral driver Wall mounted with X805 conduit box Quantity - 04no
B	S659 + X799 + X805 Ground mounted LED bollard 7.1W 577lm 3000K CRI80 - Asymmetrical forward optic On/off integral driver Wall mounted with X805 conduit box Quantity - 03no
C	iWay BW79 + X023 + B513 + X188 Ground mounted LED bollard 12.4W 540lm 3000K CRI80 - 180° asymmetric optic DALI-2 integral driver Ground mounted with B513 anchor plate Quantity - 01no

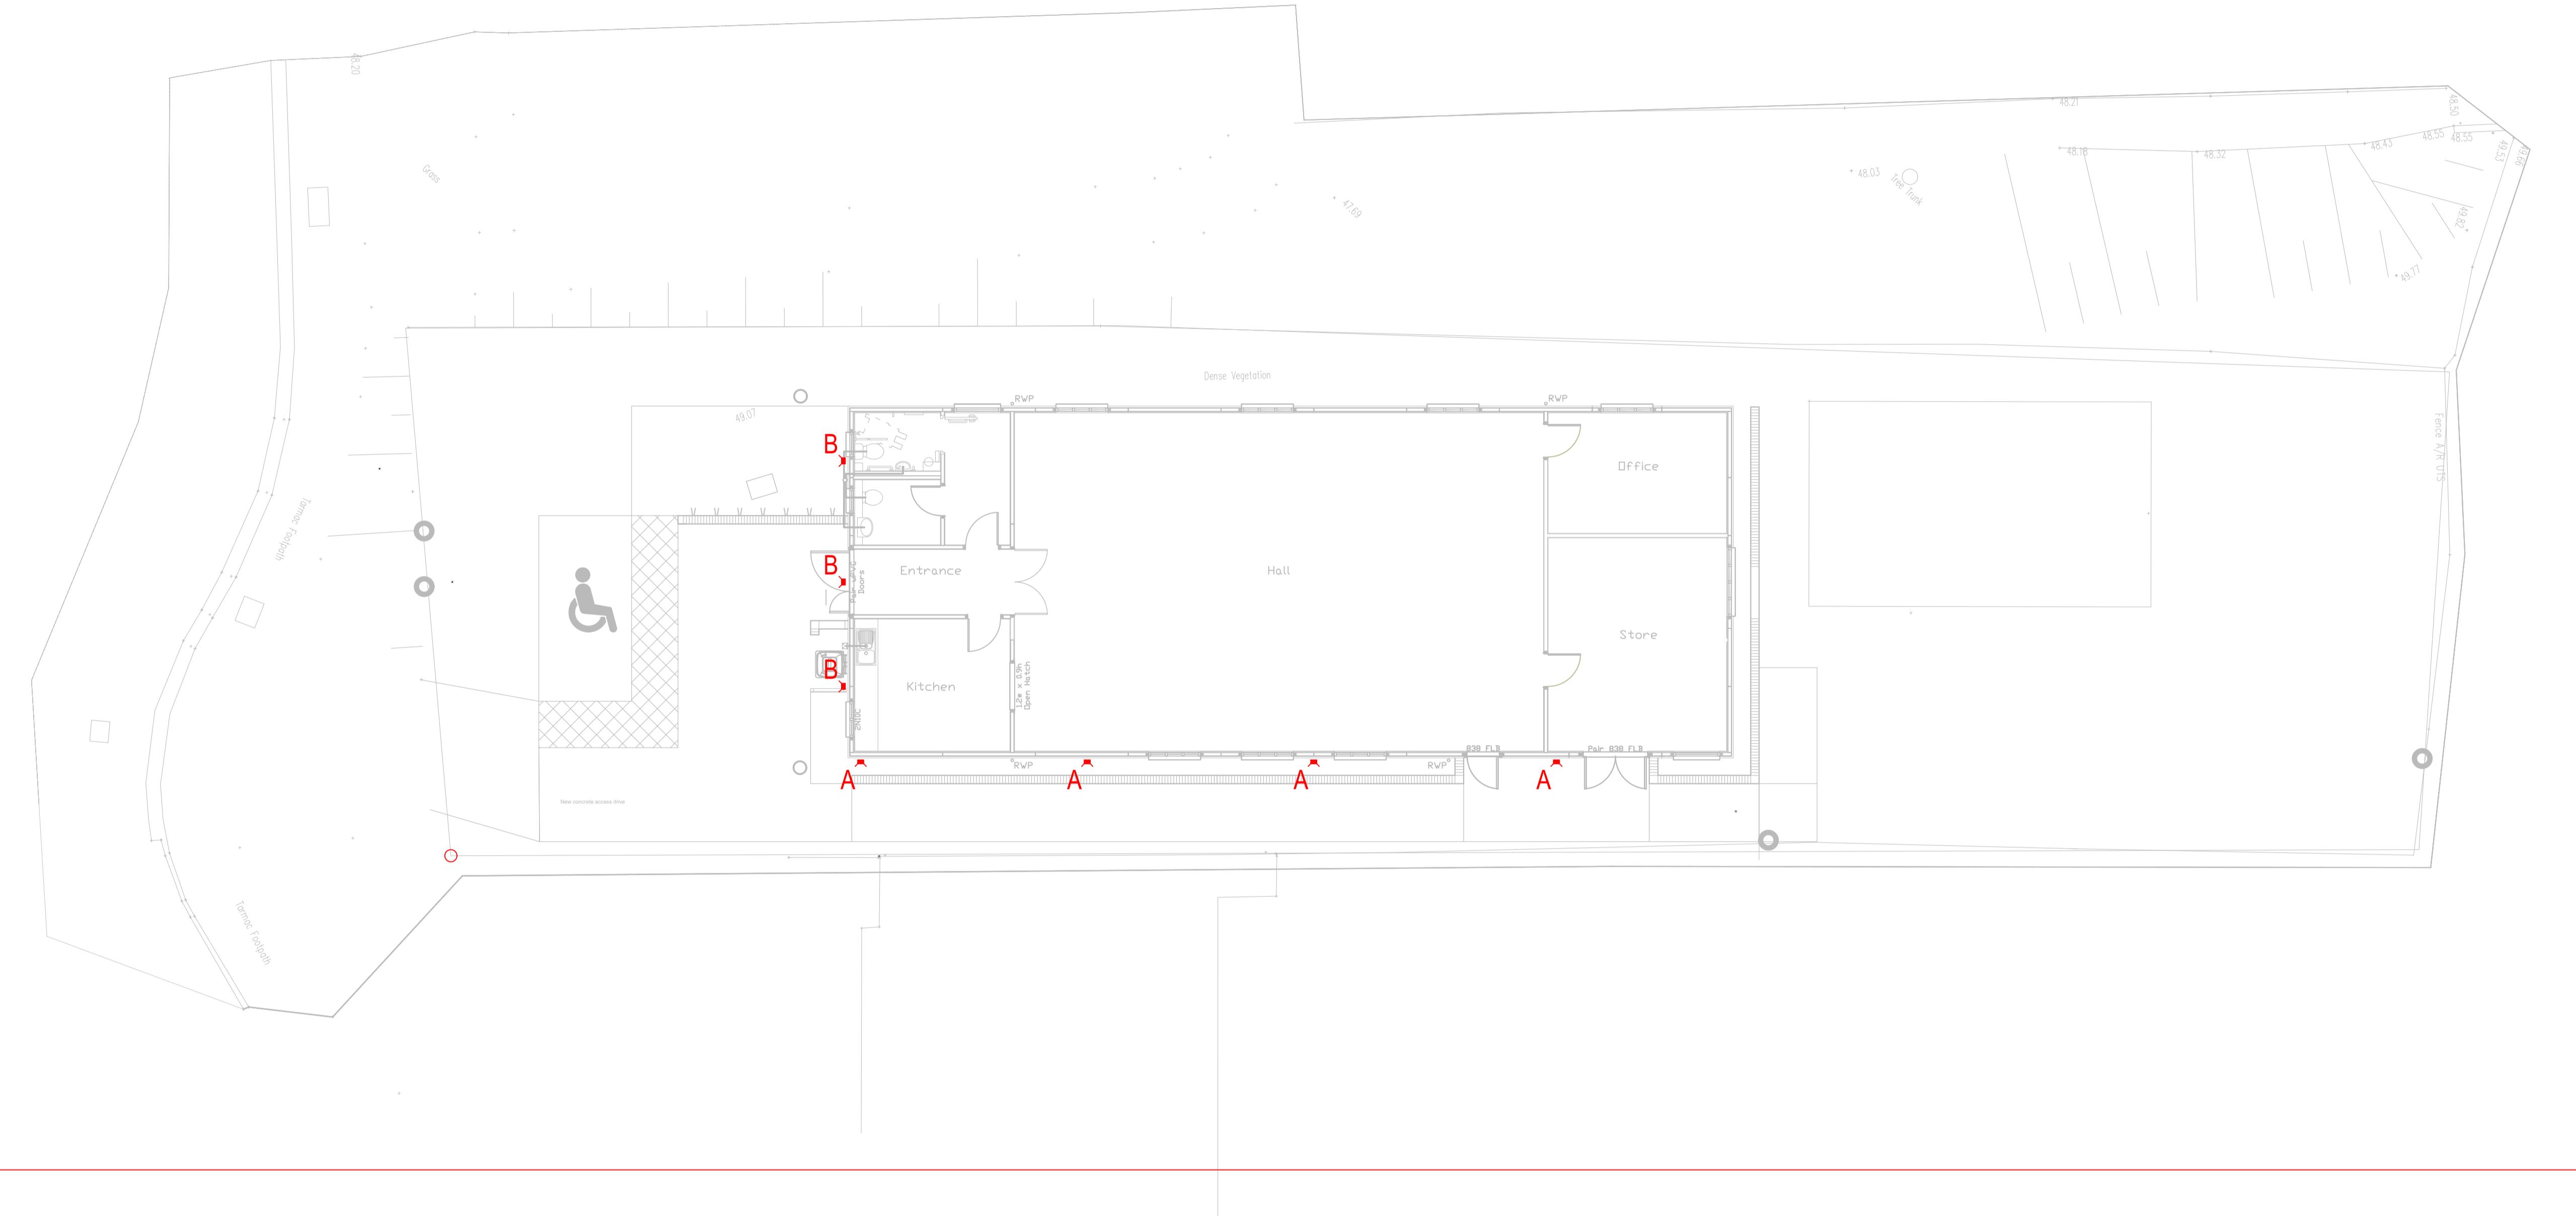

NOT FOR CONSTRUCTION

CLIENT
Light on Line LTD

PROJECT
Scout Hut - 18 St Catherines Road

OPPORTUNITY NUMBER
043125-00019

DRAWING TITLE
Lighting Layout Proposal
External Lighting - No Ramp

DESIGNER
PC
SCALE
1:100 @ A1

PM
NC
CHECKED
-
DATE
19.02.25
REVISION
01
DWG No
N/A

iGuzzini Illuminazione UK Ltd
Astotel Way, Astotel Business Park
Guildford, Surrey GU3 1NE, UK
T: 01483 468 000
F: 01483 468 001
E: uk@iguzzini.com
www.iguzzini.com



iGuzzini

GENERAL NOTES:
The lighting proposal is developed by the Lighting Solutions Department of iGuzzini in operational, technical and organizational authority, upon instructions by the Client/ Applicant, who is responsible for the information supplied for the development of the Lighting Concept.
The position of the lighting fixtures is for indicative purposes only. On-site tests are recommended for a better development of the lighting results.
The lighting results have an indicative value only and may differ from the real situation.
iGuzzini does not take any responsibility for the implementation of the project.

FIRE SAFETY and BUILDING REGULATION:
iGuzzini doesn't guarantee compliance of the proposed lighting fittings and lighting layout with The Building Regulation, specifically (but not only) Part L and Part P, and Part B. It is up to the client or third party to verify that iGuzzini proposed lighting fittings and lighting layout comply with The Building Regulations and they are fit for purpose, with particular attention to Fire Safety Approved Document L. iGuzzini doesn't power Approved Document L. iGuzzini doesn't take any responsibility for the installation of lighting fittings and lighting proposal not compliant with the above mentioned regulations.

EXIT SIGNS:
The lighting proposal doesn't include illuminated exit and emergency signs. It is assumed that the client or the contractor will install them as needed. See also emergency lighting note.
In case iGuzzini is required to provide illuminated exit and emergency sign, the client is to provide the exact quantities of illuminated signs required, specifying mounting types (e.g. wall, ceiling, floor, post, pole mounted) and the arrow direction for each sign. In case iGuzzini is required to indicate illuminated exit sign on the drawing, client should also mark up position of required signs in addition to the information above.