


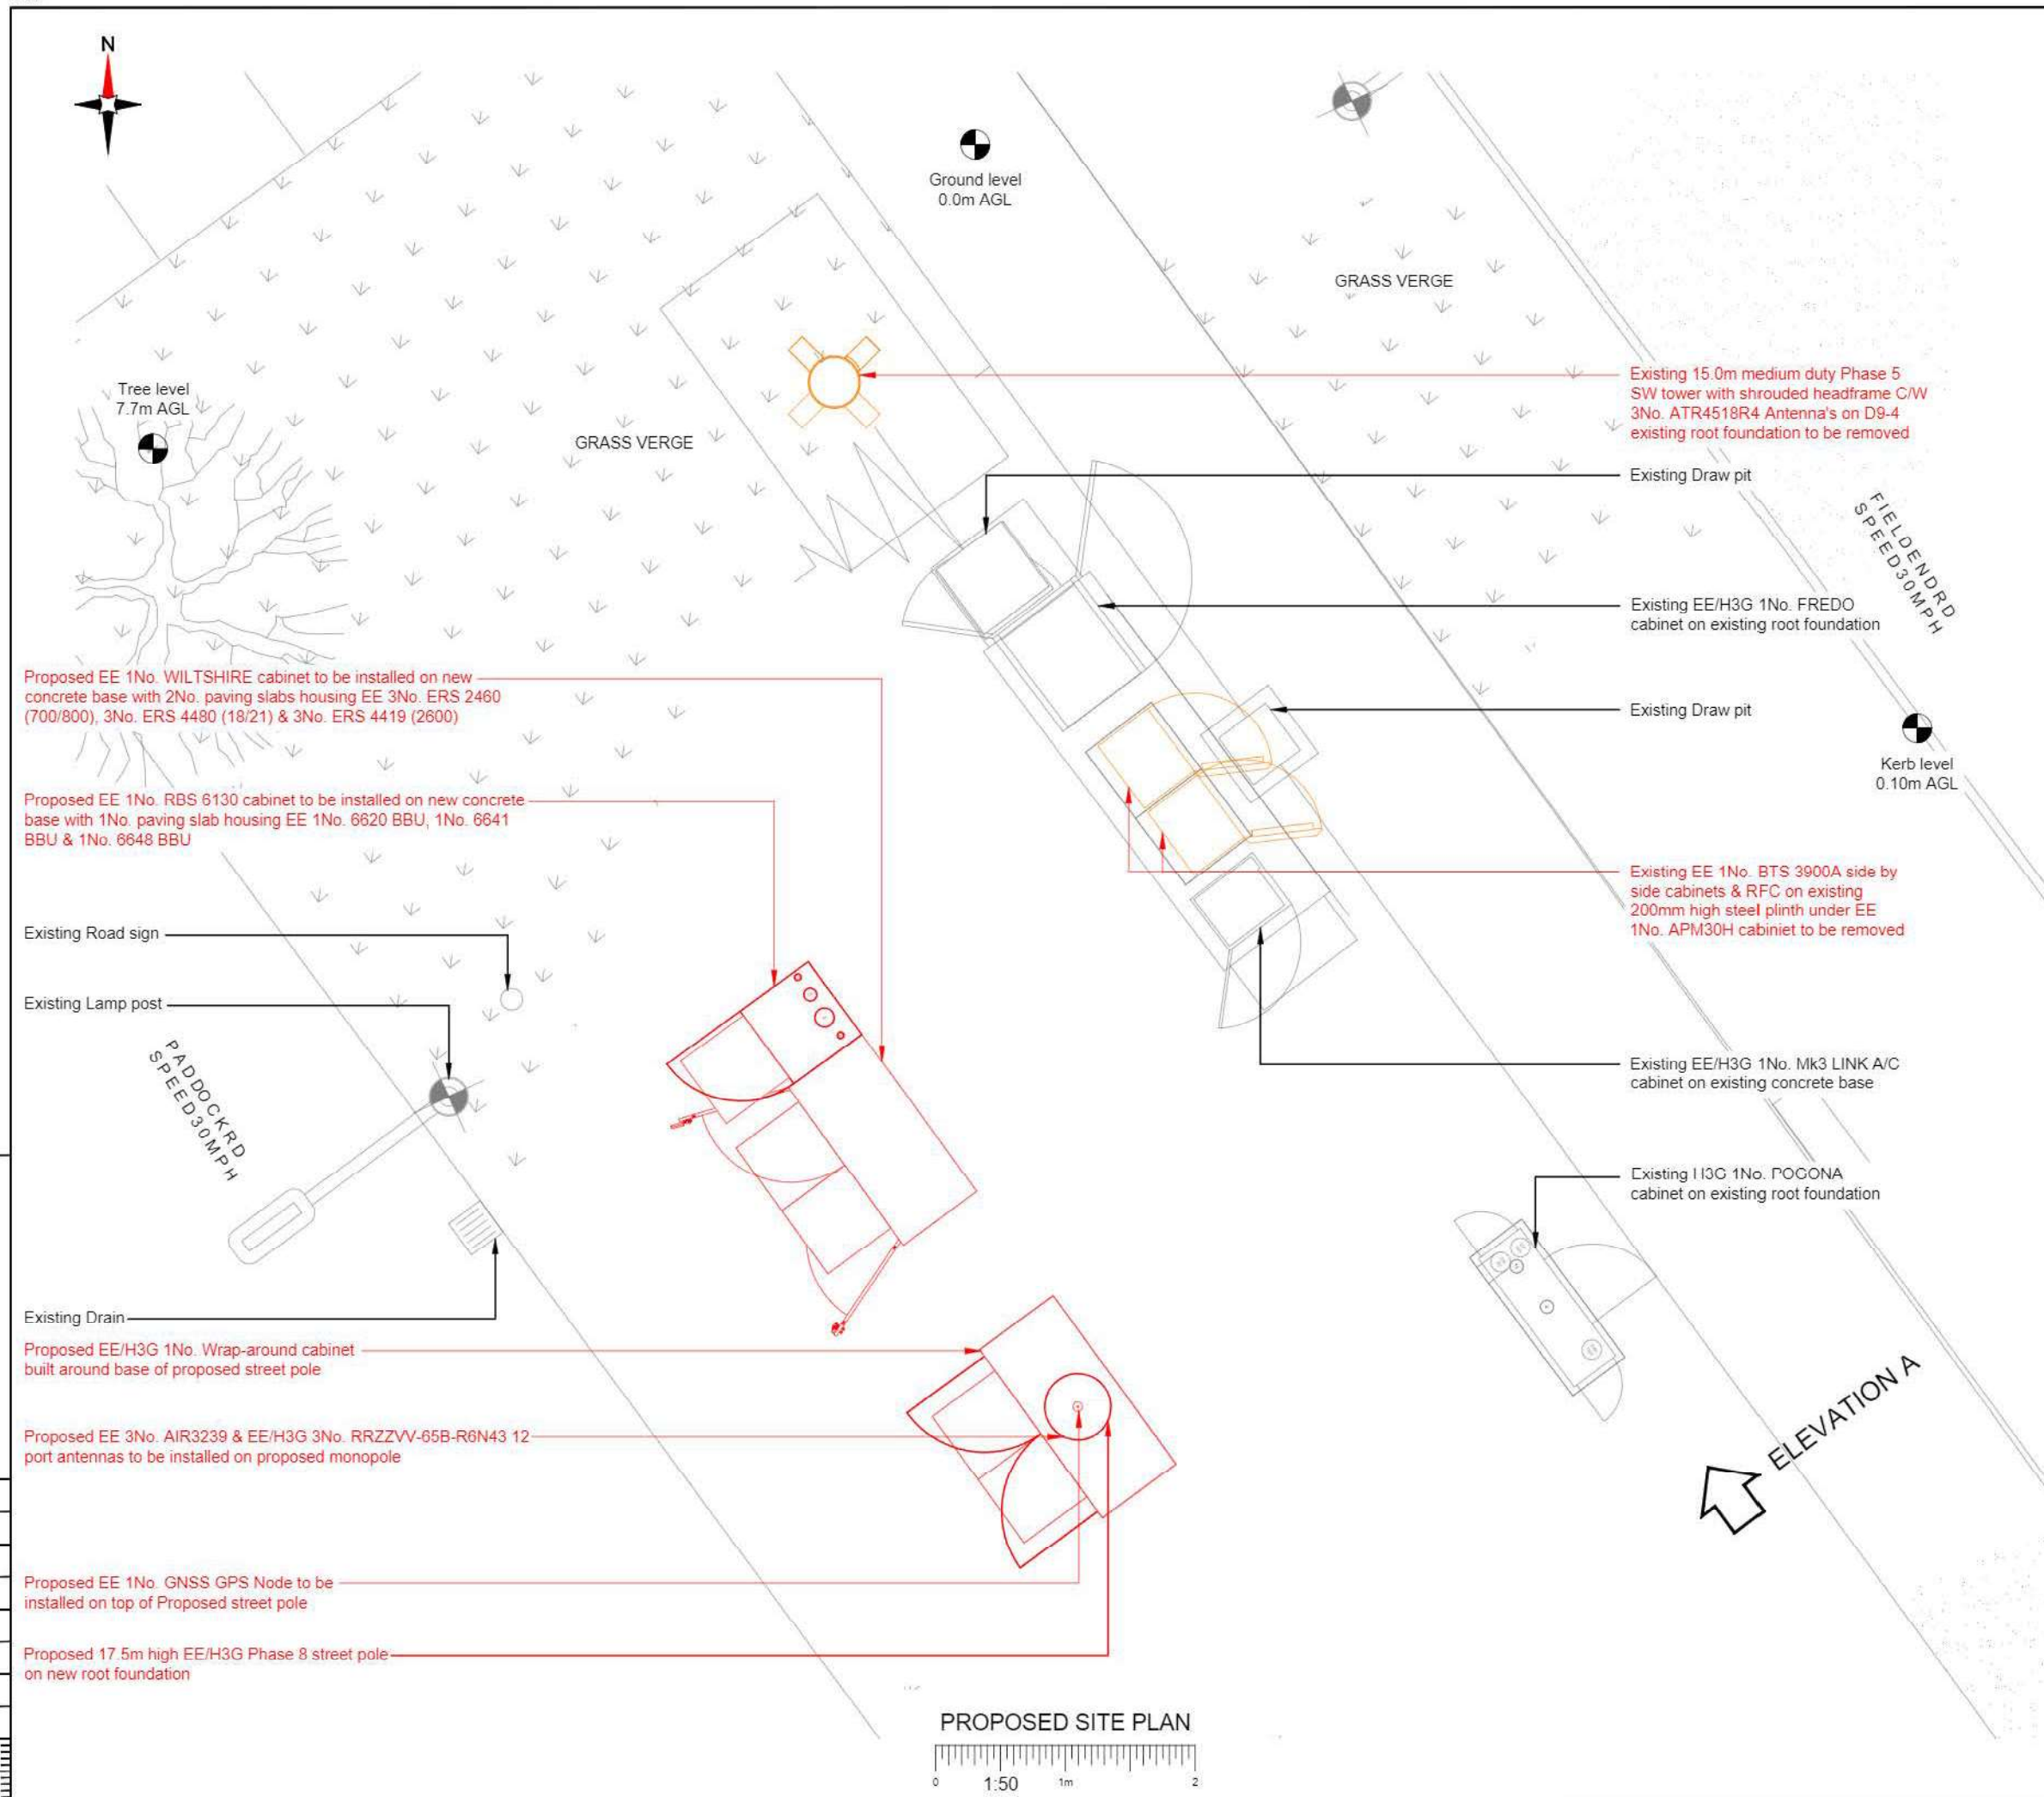

NOTES:

- ALL DIMENSIONS IN MM UNLESS OTHERWISE NOTED.

Note:
All Existing fibre / feeder cables to be re-used. Subject to testing. Un-used feeder cables to remain and be capped

Master:	MBNL / EE / H3G:	Project:	Purpose of Issue:	Issue:
M001	MBNL	VENDOR SWAP	Planning	A
Date:	30/06/2021	Revision / Upgrade Description:		
Drawn:	C.D.N	First Issue		
Checked:	N. Hoy			
Approved:	N. Hoy			



Hatfield Business Park
Hatfield
Hertfordshire
AL10 9BW

Tel: 01707 315000
Fax: 01707 319001

Design Consultant & Principal Contractor:

CLARKE
telecom

Unit E, Madison Place, Northampton Road,
Manchester, M40 5AG
Tel: 0161 785 4500 Fax: 0161 785 4501
Web: www.clarke-telecom.com

Site Name: FIELD END ROAD SW

Site ID: 982011

Address: SOUTH HARROW
HARROW
LONDON
HILLINGDON
HA4 0RG

Title: 200 PROPOSED SITE PLAN

Project: VENDOR SWAP

Purpose of Issue: GENERAL ARRANGEMENT

EE Cell ID:	MBNL Cell ID:	3UK Cell ID:
50688	HGN009	HAO103

Master Drawing No:	Issue:
982011_HGN009_50688_HAO103_M001	A