
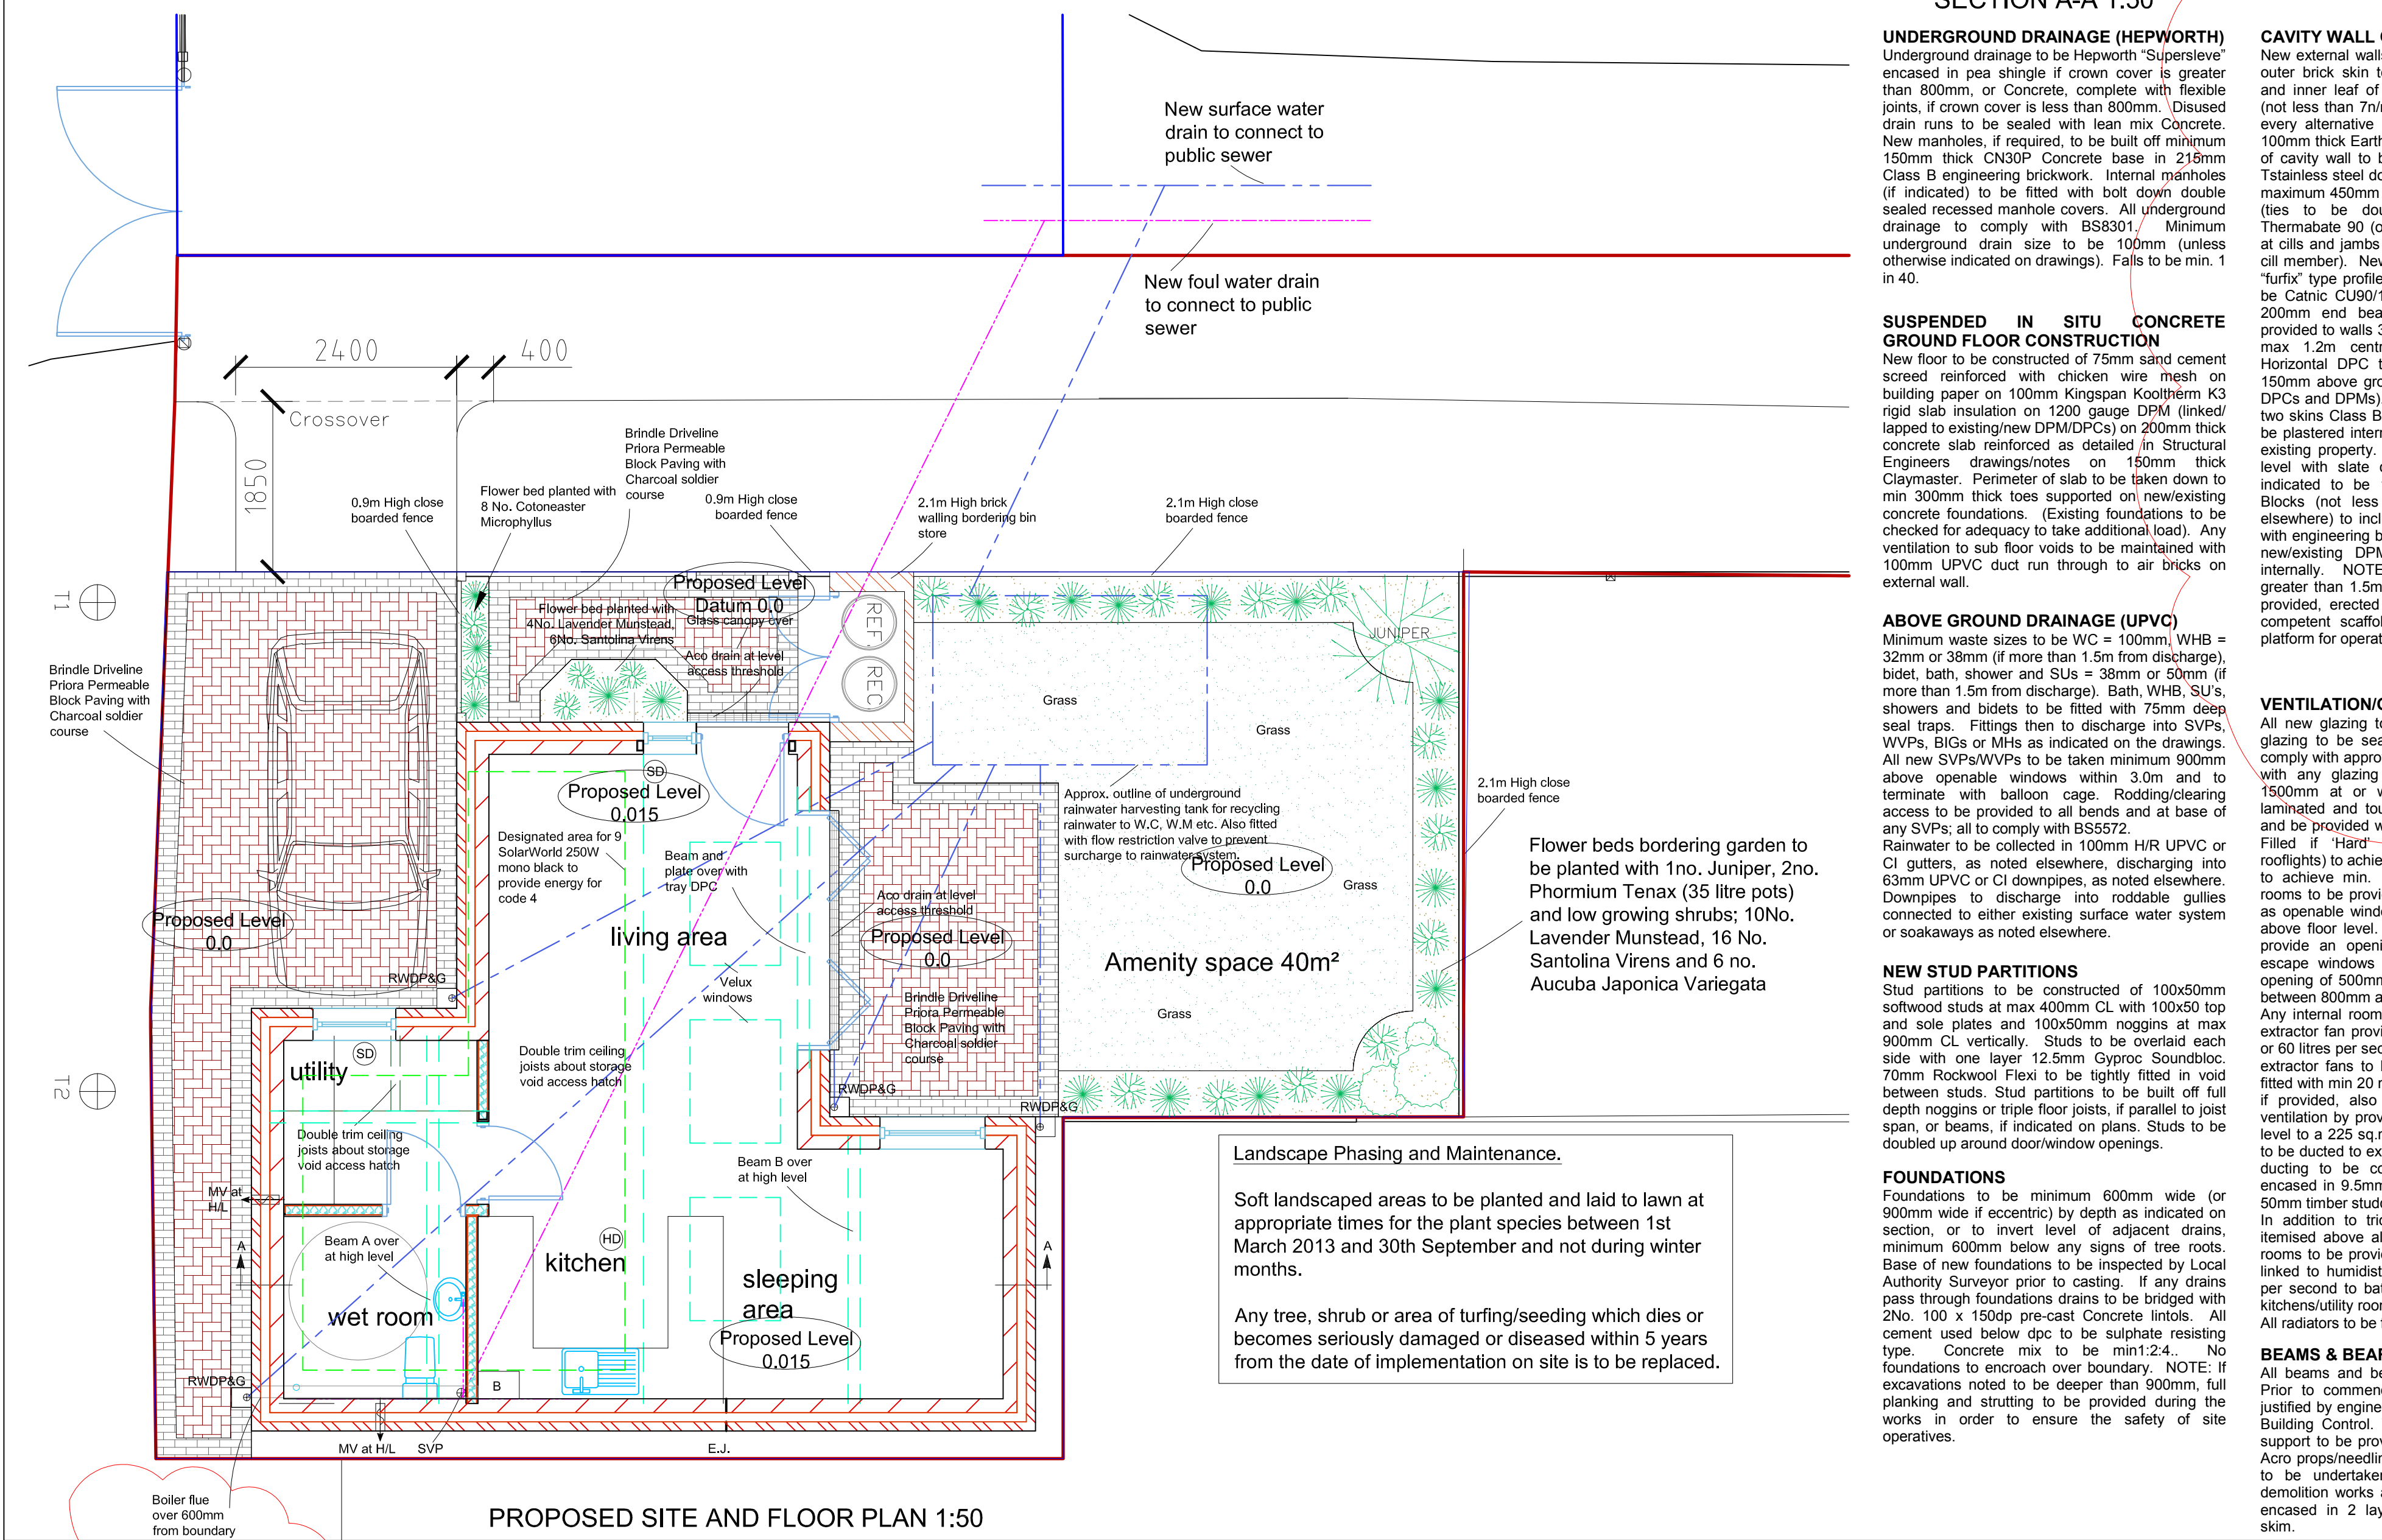
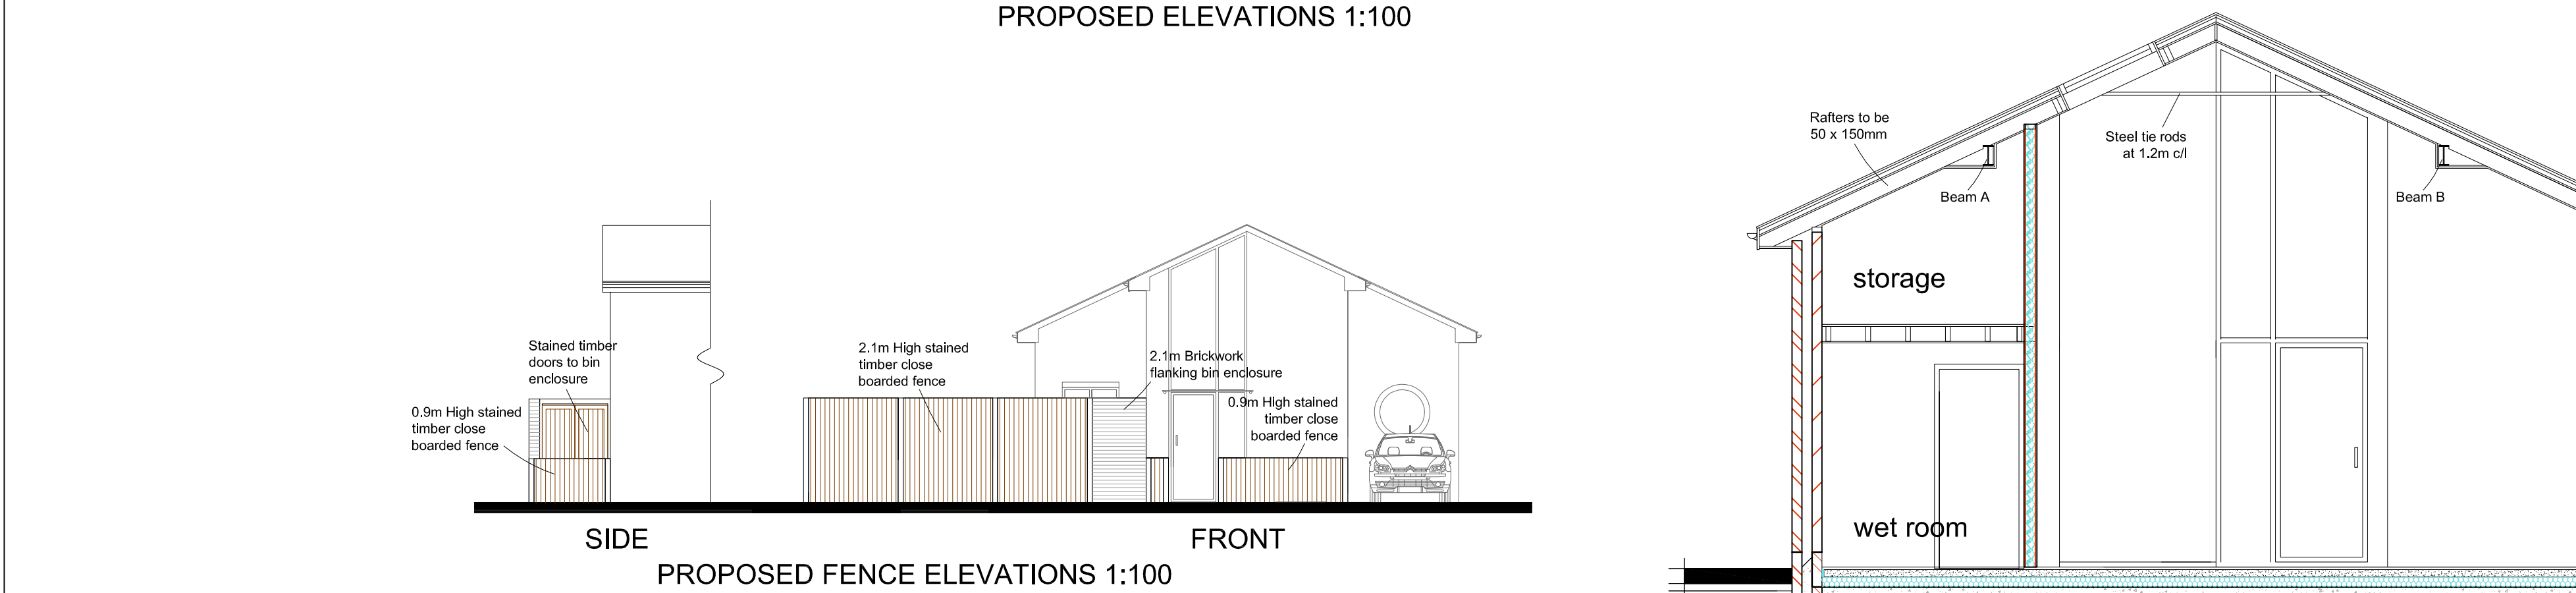


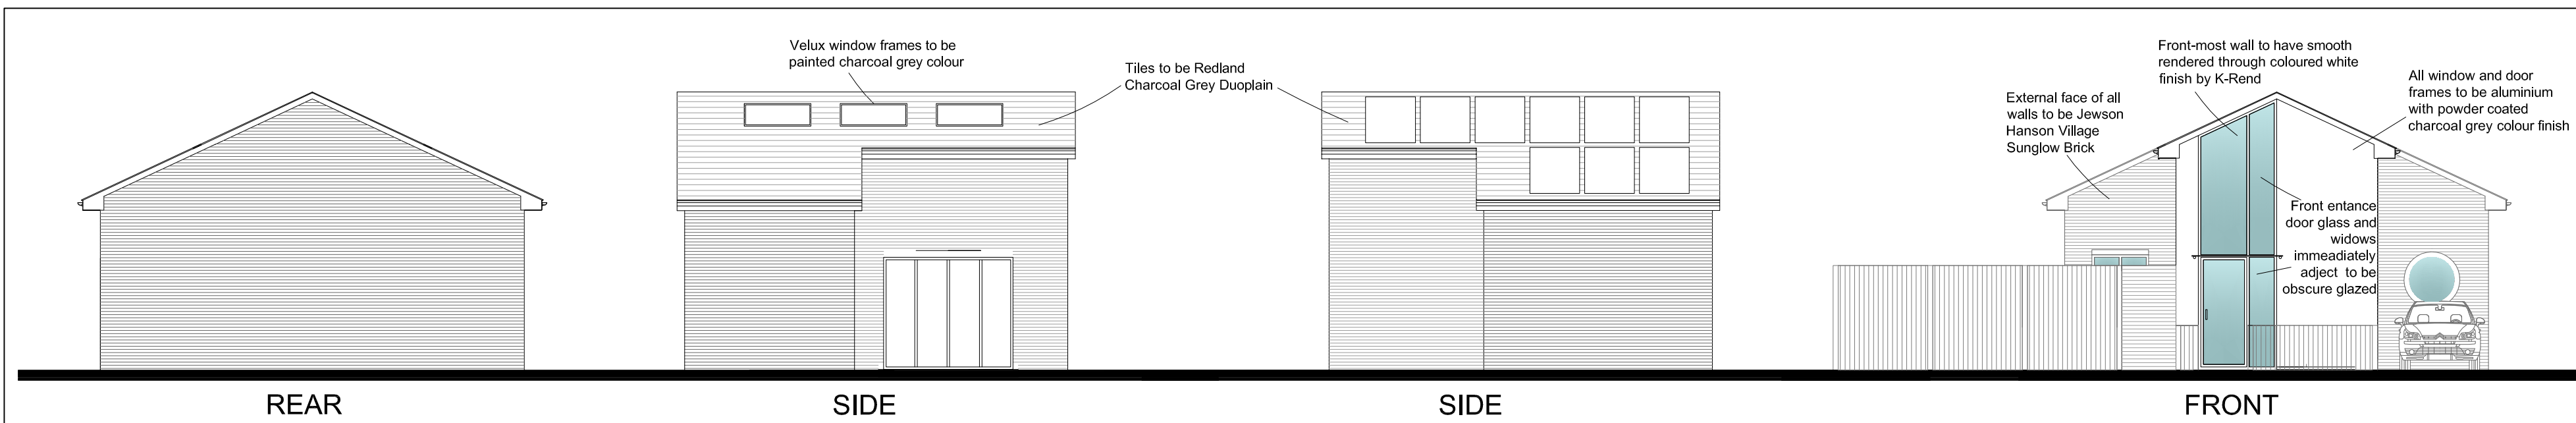

NEW FLOOR CONSTRUCTION

25mm T&G solid timber boarding on softwood joists at 400mm CL (size as noted on plans). Full depth noggins to be provided at mid thirds and under stud partitions perpendicular to joist span. Triple joists bolted at 600mm CL to be provided under stud partitions parallel to joist span and around staircases unless noted otherwise on drawings. Ceiling to be formed from 12.5mm plasterboard and plaster skim.

ELECTRICAL & LIGHTING

All wiring and electrical work will be designed, installed, inspected and tested in accordance with the requirements of BS7671, the IEE 17th edition Wiring Guidance and Building Regulation Part P (electrical safety) by a competent person registered with an electrical self-certification scheme authorised by the Secretary of State.

Replace lighting in all rooms with, fixed lighting that only take lamps having greater than 40 lumens per circuit-watt.

The competent person is to send to the local authority a self-certification certificate within 30 days of the electrical works' completion. The client must receive both a copy of the self-certification certificate and a BS7671 Electrical Installation Test Certificate.

Electrical cables should be fixed to the structure above insulation so that dissipate heat. Cables that pass through or are enclosed by insulation may need to be increased in size, even when in conduit. The circuits most likely to be affected are radial circuits serving cookers, immersion heaters, shower units and socket outlets. PVC insulated cables should not be in direct contact with any expanded polystyrene insulation. Subject to Approved Document B, where recessed fittings are to be used, those designed for compact fluorescent or low voltage tungsten halogen lamps should only be used within an enclosure, set between the joists, to dissipate heat. Additional measures will be necessary to ensure that the floor maintains a full half hour period of fire resistance under Requirement B3, if recessed light fittings are used. (B3/E2 – 2003 Edition)

In accordance with Approved Document M, underside of sockets to be minimum of 450mm above finished floor level (FFL) and underside of light switches to be maximum 1000mm above to FFL.

HEALTH & SAFETY

In designing this scheme Simon Hands and Associates has attempted to eliminate as many Health & Safety risks as possible. However the following risks could not be fully eliminated and contractor is to ensure he/she makes adequate provision for these risks.

Commercial – these works are to a commercial premises. The client is obliged to employ a competent Construction Design and Management Co-ordinator (CDMC) to adhere to the requirements of the Construction Design (and Management) Regulations, and to check the competency of the contractor and all consultants. The CDMC must be appointed before the design is being prepared for planning permission i.e. after initial feasibility stage.

The client and all parties are obliged to provide all relevant information likely to affect the works or any operatives. Works may not commence until health and safety issues are adequately resolved. If a Type 3 asbestos survey has not been undertaken it must be undertaken as a matter of urgency and any observations made known to all parties. Proper sanitary and mess facilities are to be provided for the entire duration of the works.

Demolition – before demolition all services are isolated. Excavation – during excavation ensure proper support is provided to the sides of all trenches. Installation of beams – mechanical lifting gear to be used to lift heavy weight beams. General – owners will occupy premises during works, all services to be maintained and the site isolated.

PITCHED ROOF WITH TLX INSULATION OVER RAFTERS

Tiles as specified elsewhere secured with aluminium alloy nails to 25x38mm tanalised softwood battens on Kiebo Permo Forte untearable quality roofing felt on 38 x 50mm counter battens on 33mm thick TLX Silver multifoil insulation on rafters size as specified on section at max 400mm CL. (Rafters can be underlined with 12.5mm Duplex plasterboard and plaster skim as required). 100mm Kingspan Thermapitch TP10 insulation to be laid between rafters supported on 10mm square battens (min. 25mm air space to be maintained between insulation layers). Insulation layers to achieve 0.18W/m² K u-value. Ceiling joists, size as specified elsewhere, to be at max 400mm CL with 12.5mm Duplex plasterboard and plaster skim. Wall plate and rafters each to be strapped to walls at max 1.2m CL with 30mm x 5mm x 1.2m long GMS straps. Ceiling joists also to be strapped to rafters at 1.2m CL with GMS straps with full depth noggins between joists where parallel to joist span. Valley gutters to be constructed in accordance with LSA manual. 4mm plywood valley boards to be laid flush between rafters supported on noggins. Valley boards to extend 225mm each side of the centre of the valley with tilting fillets positioned min 150mm each side of the centre. Distance between edges of tiles to be min 125mm. Code 4 lead linings to be laid directly over valley boards with sarking felt dressed into gutter but stopped before gutter sole. Lead saddle to be provided at junction of 2 valleys having min lap of 150mm over gutter linings each side. Support to pitched roof construction to be provided by trebling flat roof joists in position as indicated. Soffit joists to span between trebled joists and external wall and cantilevered to fascia. Rafters and vertical tilting to be formed on 100 x 50mm softwood timbers.

NOTES.

1) Fire alarm system to LD3/2 grade D standard to BS 5839 Part 6:2004 with mains operated, linked smoke and heat detectors. Smoke detectors to be optical type. System to be wired in compliance with BS7671 to a single independent circuit at the main distribution board (circuit to be clearly labelled Smoke & Heat Alarms)

Smoke Detector
Heat Detector

Additional smoke detectors will be required if ceilings in circulation areas are interrupted by existing/new down-stand beams etc.

2) All doors to be half hour fire resisting (FD30S) and fitted with rising butt hinges. All doors are to be fitted with smoke and intumescent seals.

Fire rated doors are to achieve the necessary fire resistance when tested to BS EN 1634-1: 2000 and smoke leakage shall conform to BS-476 31.1: 1983 (as amended Nov 1994).

3) Boiler to be a gas fired Combi with balanced flue and be of condensating type. All rads to be fitted with TRVs all pipework not providing heat to be lagged. Balanced flue outlet to be fitted with durable wire guard (chip pan). Boiler to achieve the required SEDBUK rating of 91.1% or better, eg Vaillant eco TEC plus.

Boiler to be installation to be carried out and certified by a member of a class of persons approved by the HSE; they must be registered with Gas Safe, the Council for Registered Gas Installers.

Commissioning certificates are to be submitted within 30 days installation.

4) In accordance with Approved Document M Section 8 switches and sockets in habitable rooms to be located between 450mm and 120mm from finished floor.

5) For the purpose of SAP calculations assume 15 Air changes per hour to prevent need for air tightness test.

6) Provide energy efficient light fittings in all rooms.

7) All rooms to be provided with ventilation in accordance with table 1.2A of approved document F1 (see also 1.3 to 1.6 and worked examples C1 and C5 in appendix.

8) Wholesome water shall be supplied to any place where drinking water is drawn off and where any sink is provided in an area where food is prepared. Wholesome water or softened wholesome water shall be supplied to any washbasin or bidet provided in or adjacent to a room containing a sanitary convenience and to any washbasin, bidet, fixed bath or shower in a bathroom.

9) Provide an inline blending valve complying with BS EN 111:1999 or BS EN 1287:1999 to be provided to the bath as close to the tap outlet as possible to limit the temperature of the hot water supply to 48 degrees Celsius.

10) WATER EFFICIENCY:
• WC to be Armitage Shanks Sandringham dual flush 4.0/2.6l
• Basin taps to be Armitage Shanks Priory with 4l/min. flow regulator
• Kitchen sink tap to be Sandringham SL mixer with 5l/min. flow regulator.
• Shower fitting to be Mira Vigour Thermofast Power Shower.
• Washing machines to have A+++ efficiency rating and achieve min. 4.63l/kg dry load water usage.


11) Time control for space and water heating to be in accordance with Table 2 of the Domestic Building Services Compliance Guide 2010.

12) Temperature control of space heating to be in accordance with Table 2 of the Domestic Building Services Compliance Guide 2010.

13) DISABLED ACCESS: the new house is designed to ensure full compliance with Approved Document M of the building regulations.

Notes:
All dimensions must be checked on site and not scaled from this drawing
Dwelling to comply with L1A building regulations as well as accredited construction details to table K1:

- All lighting to be 100% low energy lighting.
- Heating system to be fitted with an enhanced weather compensator and a delayed start thermostat.
- Once construction has been completed, an air pressure test is to be taken and to achieve a result of 6.00 or less.
- Doors to have a U-value of 1.60W/m² K or less.
- Windows and roof lights to have a U value of 1.60W/m² K or less.
- Ventilation system to have intermittent extract fans.
- Time and temperature zone controls to be installed.
- Radiators to be fitted as emitters.
- Boiler to be minimum 89% SEDBUK SAP 2009.

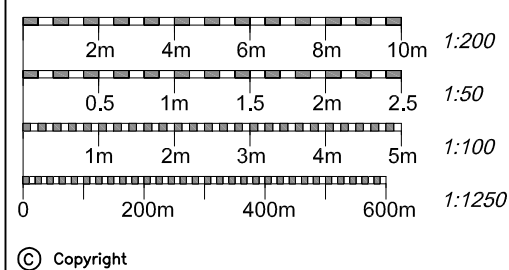

© Copyright

C	27.4.15	HIGHLIGHTED LEVELS	TX	CL
B	20.4.15	REVISED DRAWING	BY	CL
A	9.1.15	B/C SE REV		SEC

Simon Hands and Associates
Chartered Surveyors & Architects
12 Ruislip Road
Greenford
Middlesex
UB8 9QN
Tel 020 8575 5959
Fax 020 8575 8866
email: enquiries@shandsassociates.co.uk

Client
Median Properties Ltd.

Job Title
**New House at
SCHOOL APPROACH
FREDORA AVENUE
HAYES
UB4 8RH**

Drawing Title
**PROPOSED PLAN, ELEVATIONS &
SECTION**

Scale
1:50 1:100

Date
APR 2014

Job No
2011215

Page No
102

Rev
C