


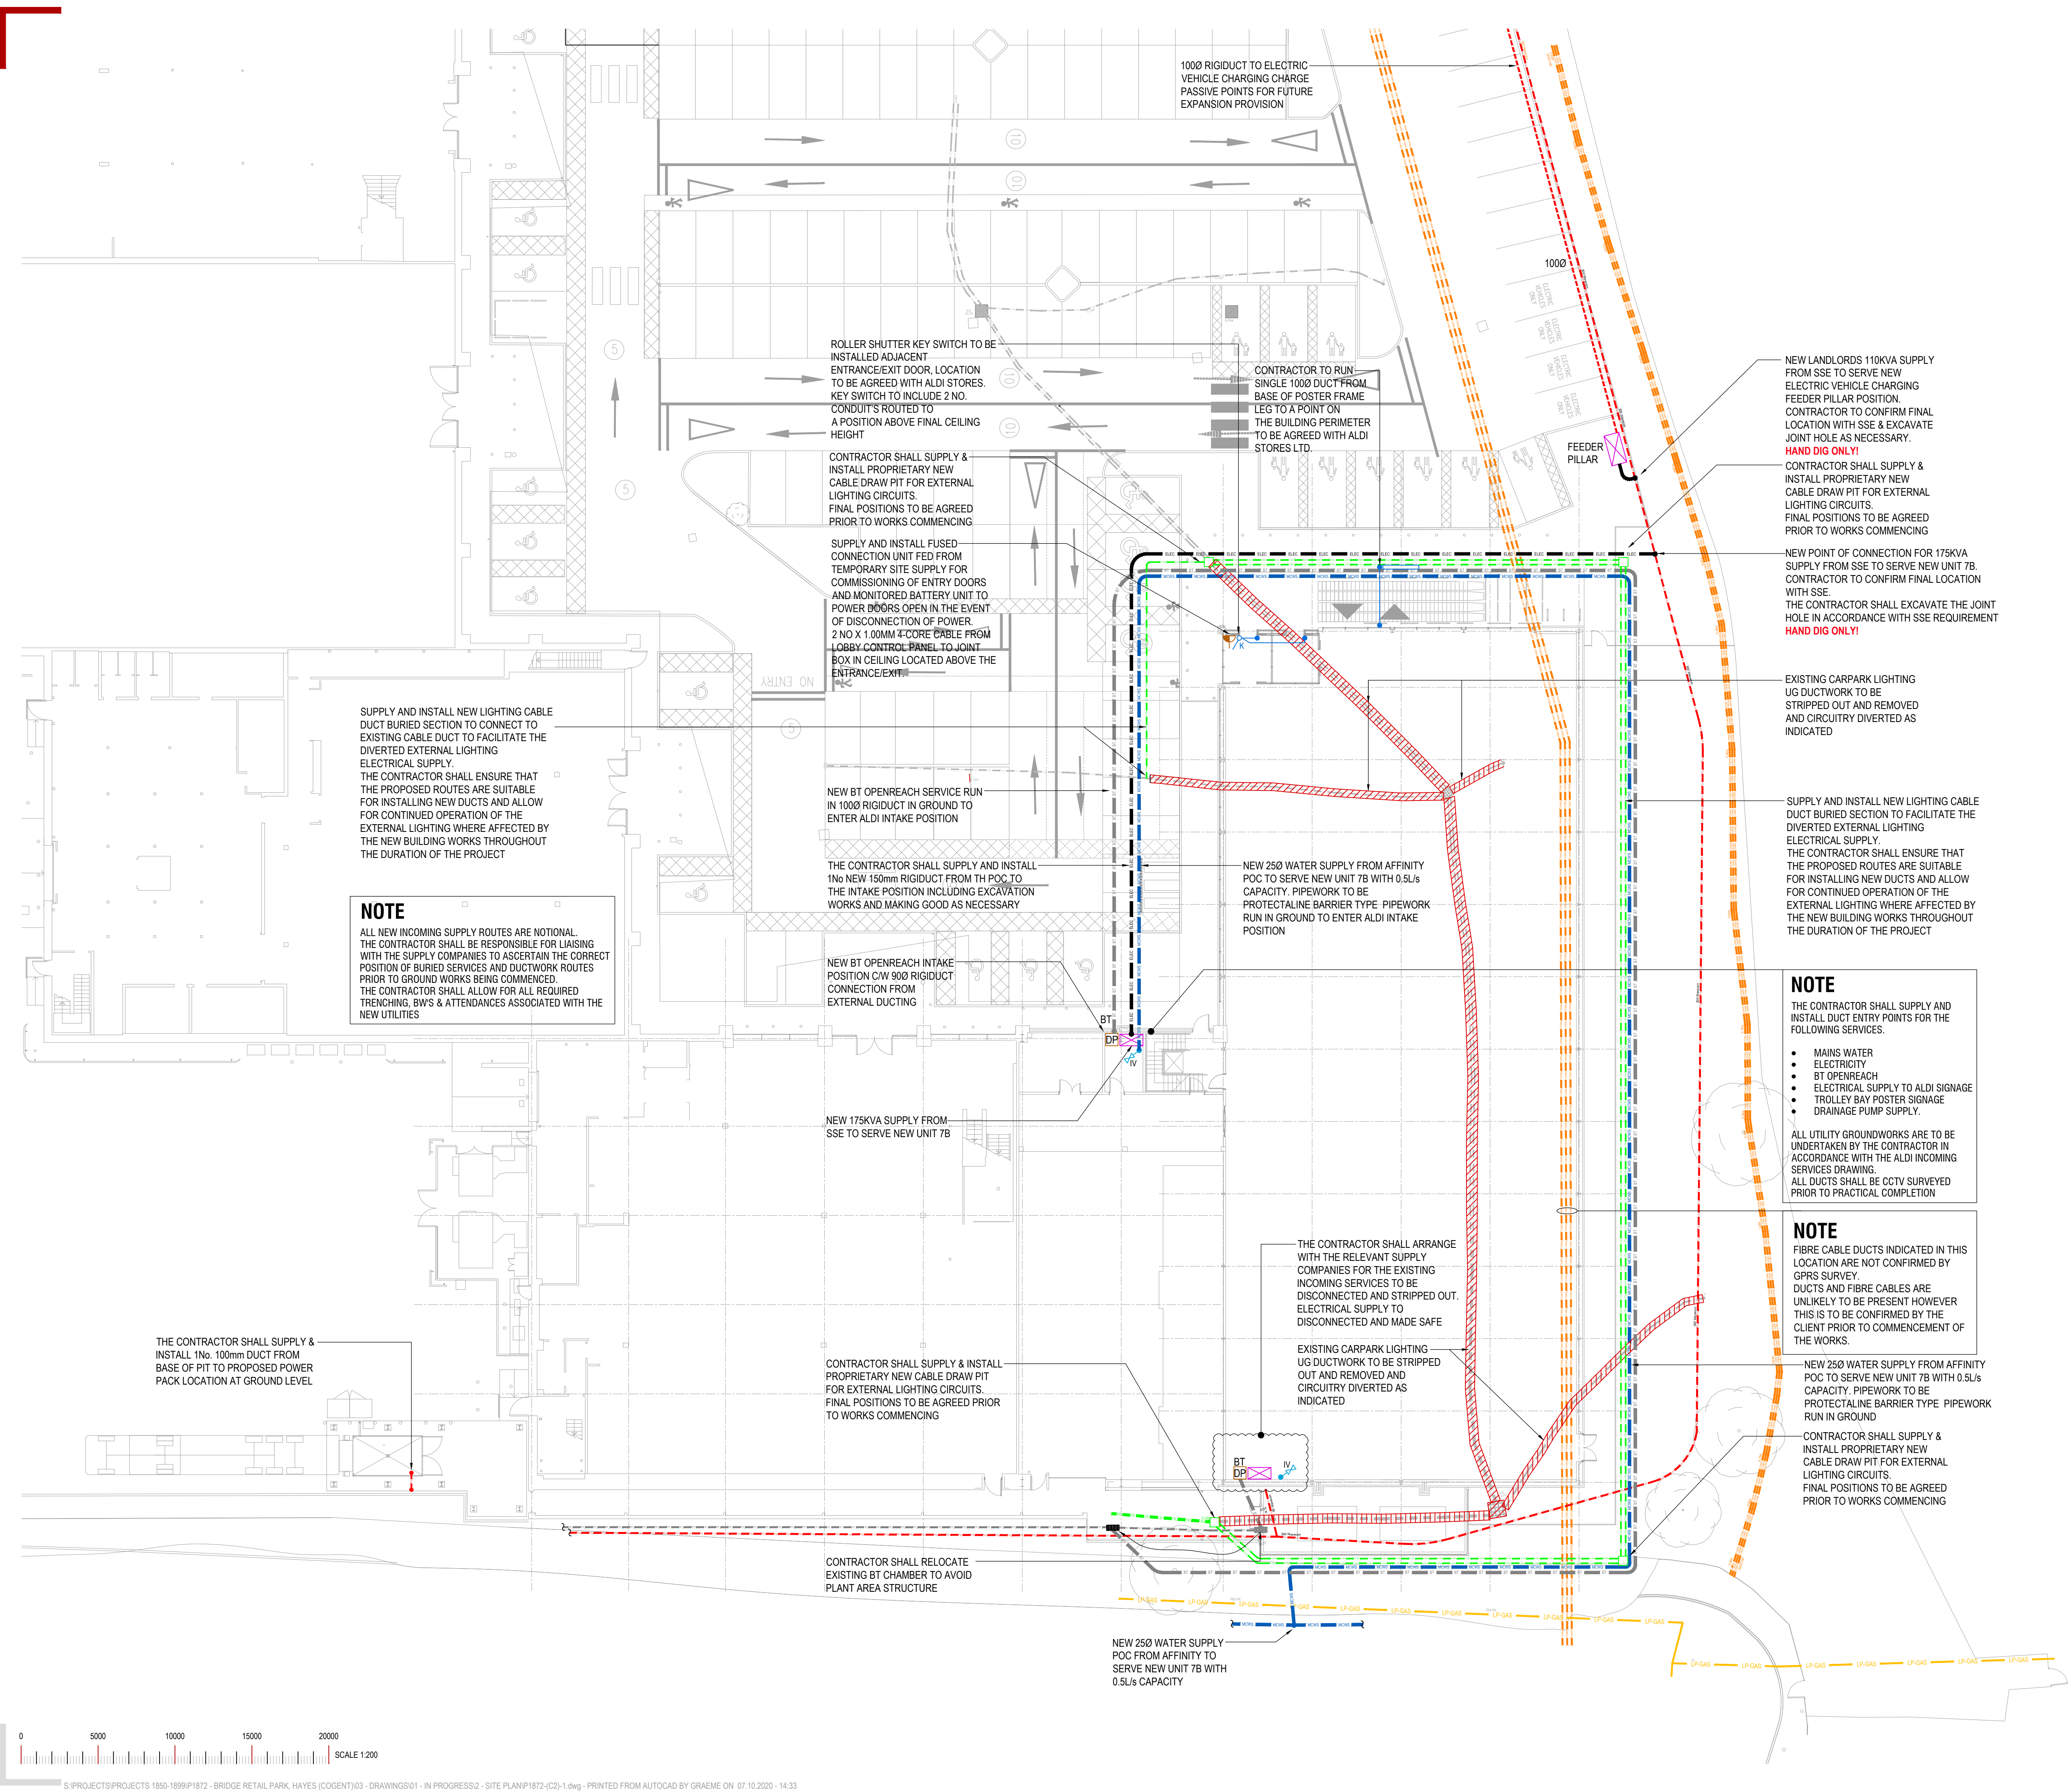

GENERAL NOTES

- THIS DRAWING SHALL BE READ IN CONJUNCTION WITH ALL PROJECT RELEVANT QUINNROSS INFORMATION, THE CONTRACT SPECIFICATION, ALL ARCHITECTS & CONSULTANTS LATEST INFORMATION & ALL RELEVANT THIRD PARTY INFORMATION.
- ALL DIMENSIONS ARE IN MILLIMETRES (mm) UNLESS OTHERWISE STATED.
- PLEASE REFER TO ARCHITECTS SETTING OUT ARRANGEMENTS FOR FINAL LOCATION OF EQUIPMENT.
- MEP SERVICES SHALL BE TESTED & COMMISSIONED IN ACCORDANCE WITH MEP SPECIFICATION.

ELECTRICAL STANDARDS COMPLIANCE

THE COMPLETE ELECTRICAL SYSTEM AND ASSOCIATED SERVICES WILL BE SUPPLIED INSTALLED, TESTED, COMMISSIONED, SET TO WORK, DEMONSTRATED, ETC. BY THE CONTRACTOR IN ACCORDANCE WITH BUT NOT LIMITED TO THE CURRENT EDITIONS (INCLUDING AMENDMENTS) OF THE FOLLOWING:

- THE FULL EMPLOYER'S REQUIREMENTS AVAILABLE FROM THE MAIN CONTRACTOR
- ELECTRICAL SAFETY, QUALITY AND CONTINUITY REGULATIONS
- BRITISH STANDARDS AS APPROPRIATE
- HEALTH AND SAFETY AT WORK ACTS
- ELECTRICITY AT WORK ACT 1989
- CBS CODE FOR INTERIOR LIGHTING
- SLL LIGHTING GUIDES
- BS7671 - IET WIRING REGULATIONS 18TH EDITION, INCLUDING LATEST AMENDMENTS AND APPLICABLE GUIDANCE NOTES
- BS 5266 (LATEST EDITION)
- BS 9991 / 9999 (LATEST EDITION)
- BUILDING REGULATIONS APPROVED DOCUMENTS
- ALL APPLICABLE BUILDING REGULATIONS APPROVED DOCUMENTS INCLUDING PART L, PART M & PART P

BURIED SERVICES

Electrical

- elec S&E CABLE / DUCT
- LV LV CABLE/DUCT
- LVS LIGHTING CABLE/DUCT
- COMMS FIBRE COMMS CABLE/DUCT
- BT BT CABLE/DUCT
- CCTV CCTV CABLE/DUCT

Mechanical

- MW Mains Cold Water Service
- MP-GAS Medium Pressure Gas
- LP-GAS Low Pressure Gas
- SWD Surface Water Drainage

WARNING
THERE MAY HAVE BEEN SUBSEQUENT ALTERATIONS TO THE SURFACE LEVELS. TRIAL HOLES MUST BE TAKEN TO DETERMINE POSITIONS AND DEPTHS OF CABLES.
HS (G) 47 BOOKLET FROM THE HEALTH & SAFETY EXECUTIVE - AVOIDING DANGER FROM BURIED CABLES - SHOULD BE CONSULTED BEFORE COMMENCING EXCAVATION WORK.
WHEN WORKING IN THE VICINITY OF OVERHEAD LINES THE HEALTH & SAFETY GUIDANCE NOTE G6S SHOULD BE CONSULTED
(AVAILABLE FROM THE HSE WEBSITE)

T1	30.09.20	TENDER ISSUE	GD	SQ
P1	20.08.20	ISSUED FOR COMMENT	GD	SQ
REV	DATE	DESCRIPTION	DRN	CHK

THIS DRAWING IS THE PROPERTY OF QUINNROSS CONSULTANTS LTD. & IS ISSUED IN CONFIDENCE. IT MUST NOT BE COPIED OR DISCLOSED TO THIRD PARTIES WITHOUT WRITTEN PERMISSION OF THE COMPANY.

QuinnRoss
CONSULTANTS LTD

KENT | M25 8NY
LONDON | N1 9JU
T: 01755 841035
W: www.quinnross.com
E: admin@quinnross.com

TENDER ISSUE

CLIENT
BRITISH AIRWAYS PENSION TRUSTEES LTD

PROJECT
HAYES BRIDGE RETAIL PARK
HAYES UB4 0RH
PROPOSED NEW RETAIL UNITS

TITLE
SITE PLAN
COMBINED SERVICES
UNIT 7B - EXISTING BURIED SERVICES &
NEW INCOMING SERVICES LAYOUT

SCALE	SIZE	PLOTTED
1:200	A1	GRAEME

DRAWING No.	REV
P1872-(C2)-1-001	T1