


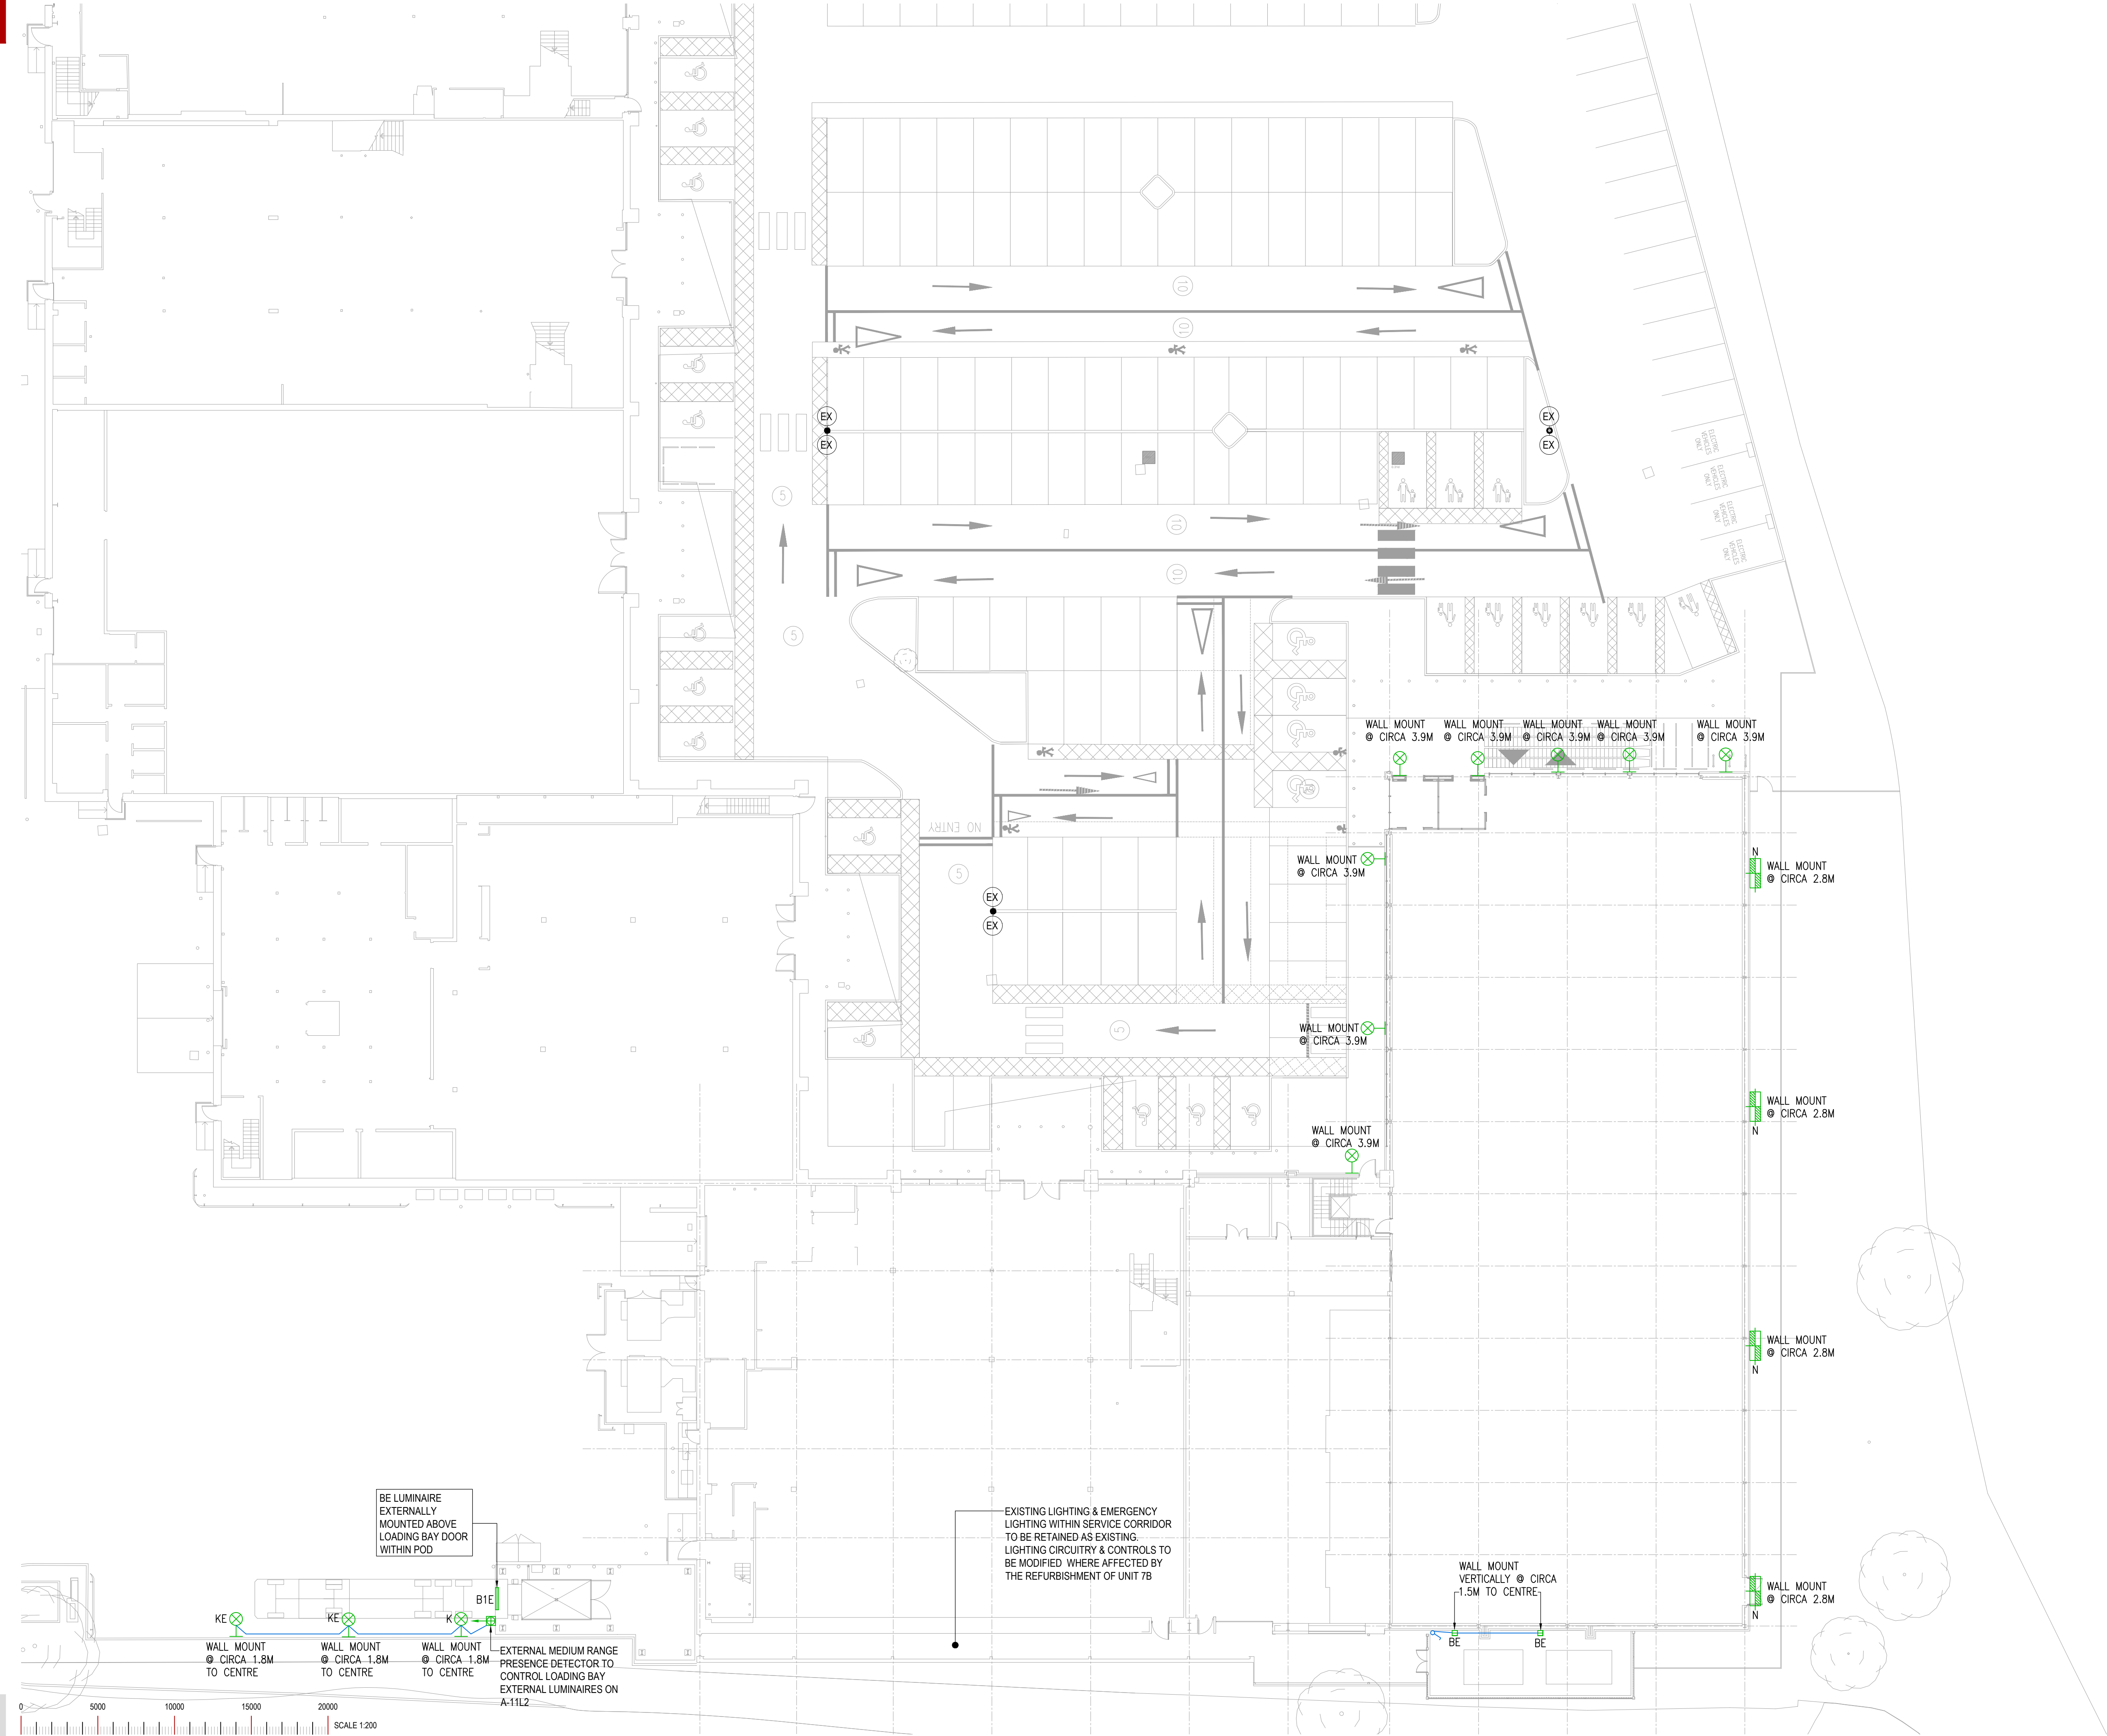

GENERAL NOTES

- THIS DRAWING SHALL BE READ IN CONJUNCTION WITH ALL PROJECT RELEVANT QUINNROSS INFORMATION, THE CONTRACT SPECIFICATION, ALL ARCHITECTS & CONSULTANTS LATEST INFORMATION & ALL RELEVANT THIRD PARTY INFORMATION.
- ALL DIMENSIONS ARE IN MILLIMETRES (mm) UNLESS OTHERWISE STATED.
- PLEASE REFER TO ARCHITECTS SETTING OUT ARRANGEMENTS FOR FINAL LOCATION OF EQUIPMENT.
- MEP SERVICES SHALL BE TESTED & COMMISSIONED IN ACCORDANCE WITH MEP SPECIFICATION.
- THE CONTRACTOR SHALL UNDERTAKE A SURVEY OF THE EXISTING EXTERNAL LIGHTING INSTALLATION, IDENTIFYING AND VALIDATING THE EXISTING CARPARK EXTERNAL LIGHTING CIRCUITRY FROM POINT OF SUPPLY.
- EXISTING EXTERNAL CARPARK LIGHTING CIRCUITS TO BE MODIFIED TO SUIT THE NEW BUILDING ARRANGEMENTS.
- EXISTING RETAINED / RE-USED LIGHTING COLUMNS WITHIN THE DEVELOPMENT ZONE SHALL REDECORATED / OVERHAULED AND HEADS CLEANED AND RELMPOED TO ENSURE CORRECT OPERATION.

ELECTRICAL STANDARDS COMPLIANCE

THE COMPLETE ELECTRICAL SYSTEM AND ASSOCIATED SERVICES WILL BE SUPPLIED INSTALLED, TESTED, COMMISSIONED, SET TO WORK, DEMONSTRATED, ETC. BY THE CONTRACTOR IN ACCORDANCE WITH BUT NOT LIMITED TO THE CURRENT EDITIONS (INCLUDING AMENDMENTS) OF THE FOLLOWING:

- THE FULL EMPLOYER'S REQUIREMENTS AVAILABLE FROM THE MAIN CONTRACTOR
- ELECTRICAL SAFETY, QUALITY AND CONTINUITY REGULATIONS
- BRITISH STANDARDS AS APPROPRIATE
- HEALTH AND SAFETY AT WORK ACTS
- ELECTRICITY AT WORK ACT 1989
- CBSSE CODE FOR INTERIOR LIGHTING
- SLL LIGHTING GUIDES
- BS7671 - IET WIRING REGULATIONS 18TH EDITION, INCLUDING LATEST AMENDMENTS AND APPLICABLE GUIDANCE NOTES
- BS 5266 (LATEST EDITION)
- BS 9991 / 9999 (LATEST EDITION)
- BUILDING REGULATIONS APPROVED DOCUMENTS
- ALL APPLICABLE BUILDING REGULATIONS APPROVED DOCUMENTS INCLUDING PART L, PART M & PART P

EXTERNAL LIGHTING LEGEND

- EX EX EXISTING TWIN HEAD AMENITY LUMINAIRE MOUNTED ON 6M POLE TO BE RETAINED UNLESS INDICATED OTHERWISE
- COCO LIGHTING HURRICANE M3 LED 1 HOUR EMG. BULKHEAD, SEMI RECESSED MOUNTED WHERE POSSIBLE.
- B DEXTRA ALDS65 L40 PC C84 IP65, TOTALLY ENCLOSED NON-CORROSIVE LUMINAIRE, SS CLIPS, POLYCARB DIFFUSER, 36.5W, 4,000 Lm, 4000K
- BE DEXTRA ALDS 65 L40 E3 PC C84, IP65, TOTALLY ENCLOSED NON-CORROSIVE LUMINAIRE, POLYCARB DIFFUSER, 36.5W, 4,000 Lm, 4000K, SS CLIPS, EMG.
- B1 DEXTRA ALDS65 L40 R25E PC C84 IP65, TOTALLY ENCLOSED NON-CORROSIVE LUMINAIRE, POLYCARB DIFFUSER, 36.5W, 4,000 Lm, 4000K, SS CLIPS & PIR SENSOR.
- B1E DEXTRA ALDS 65 L40 R25E E3 PC C84, IP65, TOTALLY ENCLOSED NON-CORROSIVE LUMINAIRE, POLYCARB DIFFUSER, 36.5W, 4,000 Lm, 4000K, EMG, SS CLIPS & PIR SENSOR.
- K CIVIC LIGHTING APOLLO MTA.5404.157.AS.37, 30.8W, 4000K, WALL MOUNTED LUMINAIRE WITH ASYMMETRIC DISTRIBUTION, ANTHRACITE OR SILVER TO MATCH CLADDING.
- KE CIVIC LIGHTING APOLLO MTA.5404.157.AS.37/M3 30.8W, 4000K, WALL MOUNTED LUMINAIRE WITH ASYMMETRIC DISTRIBUTION, INTEGRAL EMERGENCY, ANTHRACITE OR SILVER TO MATCH CLADDING.

FI	30.09.20	ISSUED FOR INFORMATION	GD	SQ
P1	20.08.20	ISSUED FOR COMMENT	GD	SQ
REV	DATE	DESCRIPTION	DRN	CHK

THIS DRAWING IS THE PROPERTY OF QUINNROSS CONSULTANTS LTD. & IS ISSUED IN CONFIDENCE. IT MUST NOT BE COPIED OR DISCLOSED TO THIRD PARTIES WITHOUT WRITTEN PERMISSION OF THE COMPANY.

QuinnRoss
CONSULTANTS LTD

KENT | ME8 8NY
LONDON | N1 9JU
T: 01755 841035
W: www.quinnross.com
E: admin@quinnross.com

FOR INFORMATION

CLIENT	BRITISH AIRWAYS PENSION TRUSTEES LTD		
PROJECT	HAYES BRIDGE RETAIL PARK HAYES UB4 0RH PROPOSED NEW RETAIL UNITS		
TITLE	SITE PLAN ELECTRICAL SERVICES UNIT 7B - EXTERNAL LIGHTING LAYOUT		
SCALE	1:200	SIZE	A1
PLOTTED	GRAEME		
DRAWING No.	P1872-(E2)-4-001		REV
		FI	