


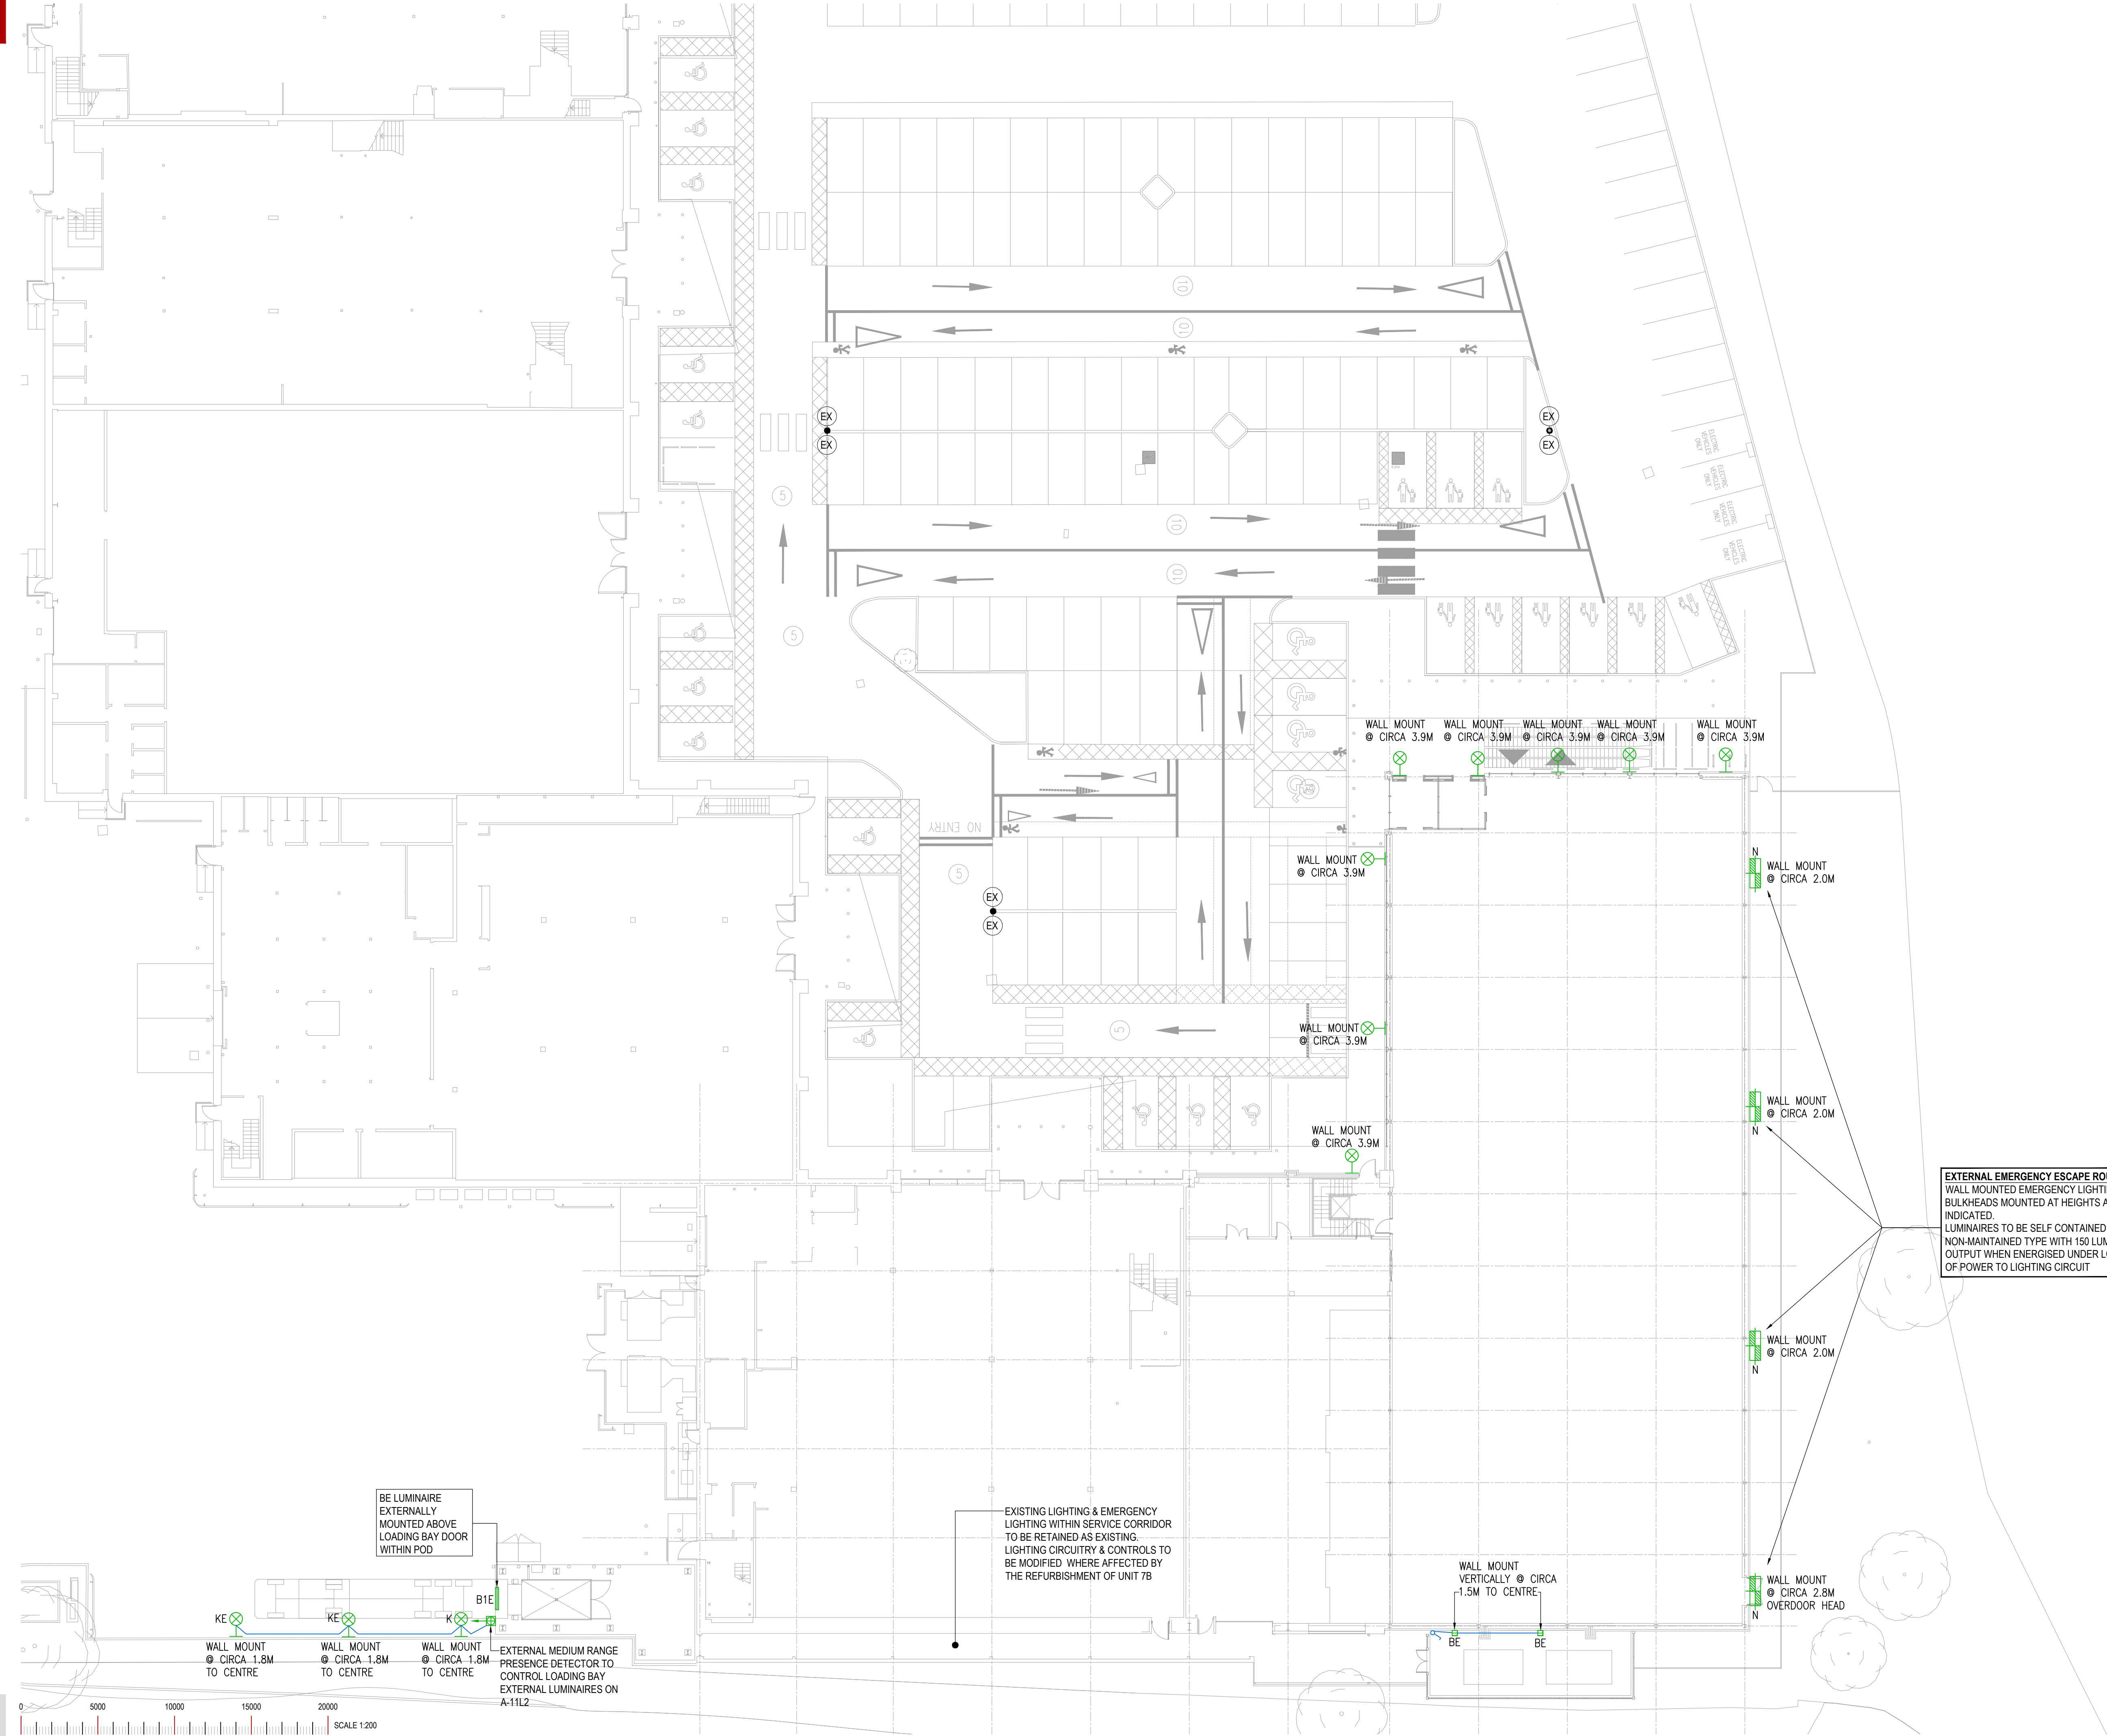

GENERAL NOTES

- THIS DRAWING SHALL BE READ IN CONJUNCTION WITH ALL PROJECT RELEVANT QUINNROSS INFORMATION, THE CONTRACT SPECIFICATION, ALL ARCHITECTS & CONSULTANTS LATEST INFORMATION & ALL RELEVANT THIRD PARTY INFORMATION.
- ALL DIMENSIONS ARE IN MILLIMETRES (mm) UNLESS OTHERWISE STATED.
- PLEASE REFER TO ARCHITECTS SETTING OUT ARRANGEMENTS FOR FINAL LOCATION OF EQUIPMENT.
- MEP SERVICES SHALL BE TESTED & COMMISSIONED IN ACCORDANCE WITH MEP SPECIFICATION.
- THE CONTRACTOR SHALL UNDERTAKE A SURVEY OF THE EXISTING EXTERNAL LIGHTING INSTALLATION, IDENTIFYING AND VALIDATING THE EXISTING CARPARK EXTERNAL LIGHTING CIRCUITRY FROM POINT OF SUPPLY.
- EXISTING EXTERNAL CARPARK LIGHTING CIRCUITS TO BE MODIFIED TO SUIT THE NEW BUILDING ARRANGEMENTS.
- EXISTING RETAINED / RE-USED LIGHTING COLUMNS WITHIN THE DEVELOPMENT ZONE SHALL REDECORATED / OVERHAULED AND HEADS CLEANED AND RELAMPED TO ENSURE CORRECT OPERATION.

ELECTRICAL STANDARDS COMPLIANCE

THE COMPLETE ELECTRICAL SYSTEM AND ASSOCIATED SERVICES WILL BE SUPPLIED INSTALLED, TESTED, COMMISSIONED, SET TO WORK, DEMONSTRATED, ETC. BY THE CONTRACTOR IN ACCORDANCE WITH BUT NOT LIMITED TO THE CURRENT EDITIONS (INCLUDING AMENDMENTS) OF THE FOLLOWING:

- THE FULL EMPLOYER'S REQUIREMENTS AVAILABLE FROM THE MAIN CONTRACTOR
- ELECTRICAL SAFETY, QUALITY AND CONTINUITY REGULATIONS
- BRITISH STANDARDS AS APPROPRIATE
- HEALTH AND SAFETY AT WORK ACTS
- ELECTRICITY AT WORK ACT 1989
- CBSSE CODE FOR INTERIOR LIGHTING
- SLL LIGHTING GUIDES
- BS7671 - IET WIRING REGULATIONS 18TH EDITION, INCLUDING LATEST AMENDMENTS AND APPLICABLE GUIDANCE NOTES
- BS 5266 (LATEST EDITION)
- BS 9991 / 9999 (LATEST EDITION)
- BUILDING REGULATIONS APPROVED DOCUMENTS
- ALL APPLICABLE BUILDING REGULATIONS APPROVED DOCUMENTS INCLUDING PART L, PART M & PART P

EXTERNAL LIGHTING LEGEND

- EX EX** EXISTING TWIN HEAD AMENITY LUMINAIRE MOUNTED ON 6M POLE TO BE RETAINED UNLESS INDICATED OTHERWISE
- N** CICO LIGHTING HURRICANE M3 LED 1 HOUR EMERGENCY LIGHTING BULKHEAD, SEMI RECESSED MOUNTED WHERE POSSIBLE
- B** DEXTRA ALDS65 L40 PC C84 IP65, TOTALLY ENCLOSED NON-CORROSIVE LUMINAIRE, SS CLIPS, POLYCARB DIFFUSER, 36.5W, 4,000 Lm, 4000K
- BE** DEXTRA ALDS 65 L40 E3 PC C84, IP65, TOTALLY ENCLOSED NON-CORROSIVE LUMINAIRE, POLYCARB DIFFUSER, 36.5W, 4,000 Lm, 4000K, SS CLIPS, EMS
- B1** DEXTRA ALDS65 L40 R25E PC C84 IP65, TOTALLY ENCLOSED NON-CORROSIVE LUMINAIRE, POLYCARB DIFFUSER, 36.5W, 4,000 Lm, 4000K, SS CLIPS & PIR SENSOR
- B1E** DEXTRA ALDS 65 L40 R25E E3 PC C84, IP65, TOTALLY ENCLOSED NON-CORROSIVE LUMINAIRE, POLYCARB DIFFUSER, 36.5W, 4,000 Lm, 4000K, EMS, SS CLIPS & PIR SENSOR
- K** CIVIC LIGHTING APOLLO MTA 5404.157 AS.37, 30.8W, 4000K, WALL MOUNTED LUMINAIRE WITH ASYMMETRIC DISTRIBUTION, ANTHRACITE OR SILVER TO MATCH CLADDING
- KE** CIVIC LIGHTING APOLLO MTA 5404.157 AS.37/M3 30.8W, 4000K, WALL MOUNTED LUMINAIRE WITH ASYMMETRIC DISTRIBUTION, INTEGRAL EMERGENCY, ANTHRACITE OR SILVER TO MATCH CLADDING

FI-2	19.04.21	EMERGENCY LIGHTING IDENTIFIED	GD	SQ
FI	30.09.20	ISSUED FOR INFORMATION	GD	SQ
P1	20.08.20	ISSUED FOR COMMENT	GD	SQ
REV	DATE	DESCRIPTION	DRN	CHK

THIS DRAWING IS THE PROPERTY OF QUINNROSS CONSULTANTS LTD. & IS ISSUED IN CONFIDENCE. IT MUST NOT BE COPIED OR DISCLOSED TO THIRD PARTIES WITHOUT WRITTEN PERMISSION OF THE COMPANY.

QuinnRoss
CONSULTANTS LTD

KENT | M25 8NY
LONDON | N1 9JU
T: 01755 841035
W: www.quinnross.com
E: admin@quinnross.com

FOR INFORMATION

CLIENT
M7 REAL ESTATE

PROJECT
HAYES BRIDGE RETAIL PARK
HAYES UB4 0RH
PROPOSED NEW RETAIL UNITS

TITLE
SITE PLAN
ELECTRICAL SERVICES
UNIT 7B - EXTERNAL LIGHTING LAYOUT

SCALE
1:200

SIZE
A1

PLOTTED
GRAEME

DRAWING No.
P1872-(E2)-4-001

REV
FI-2