


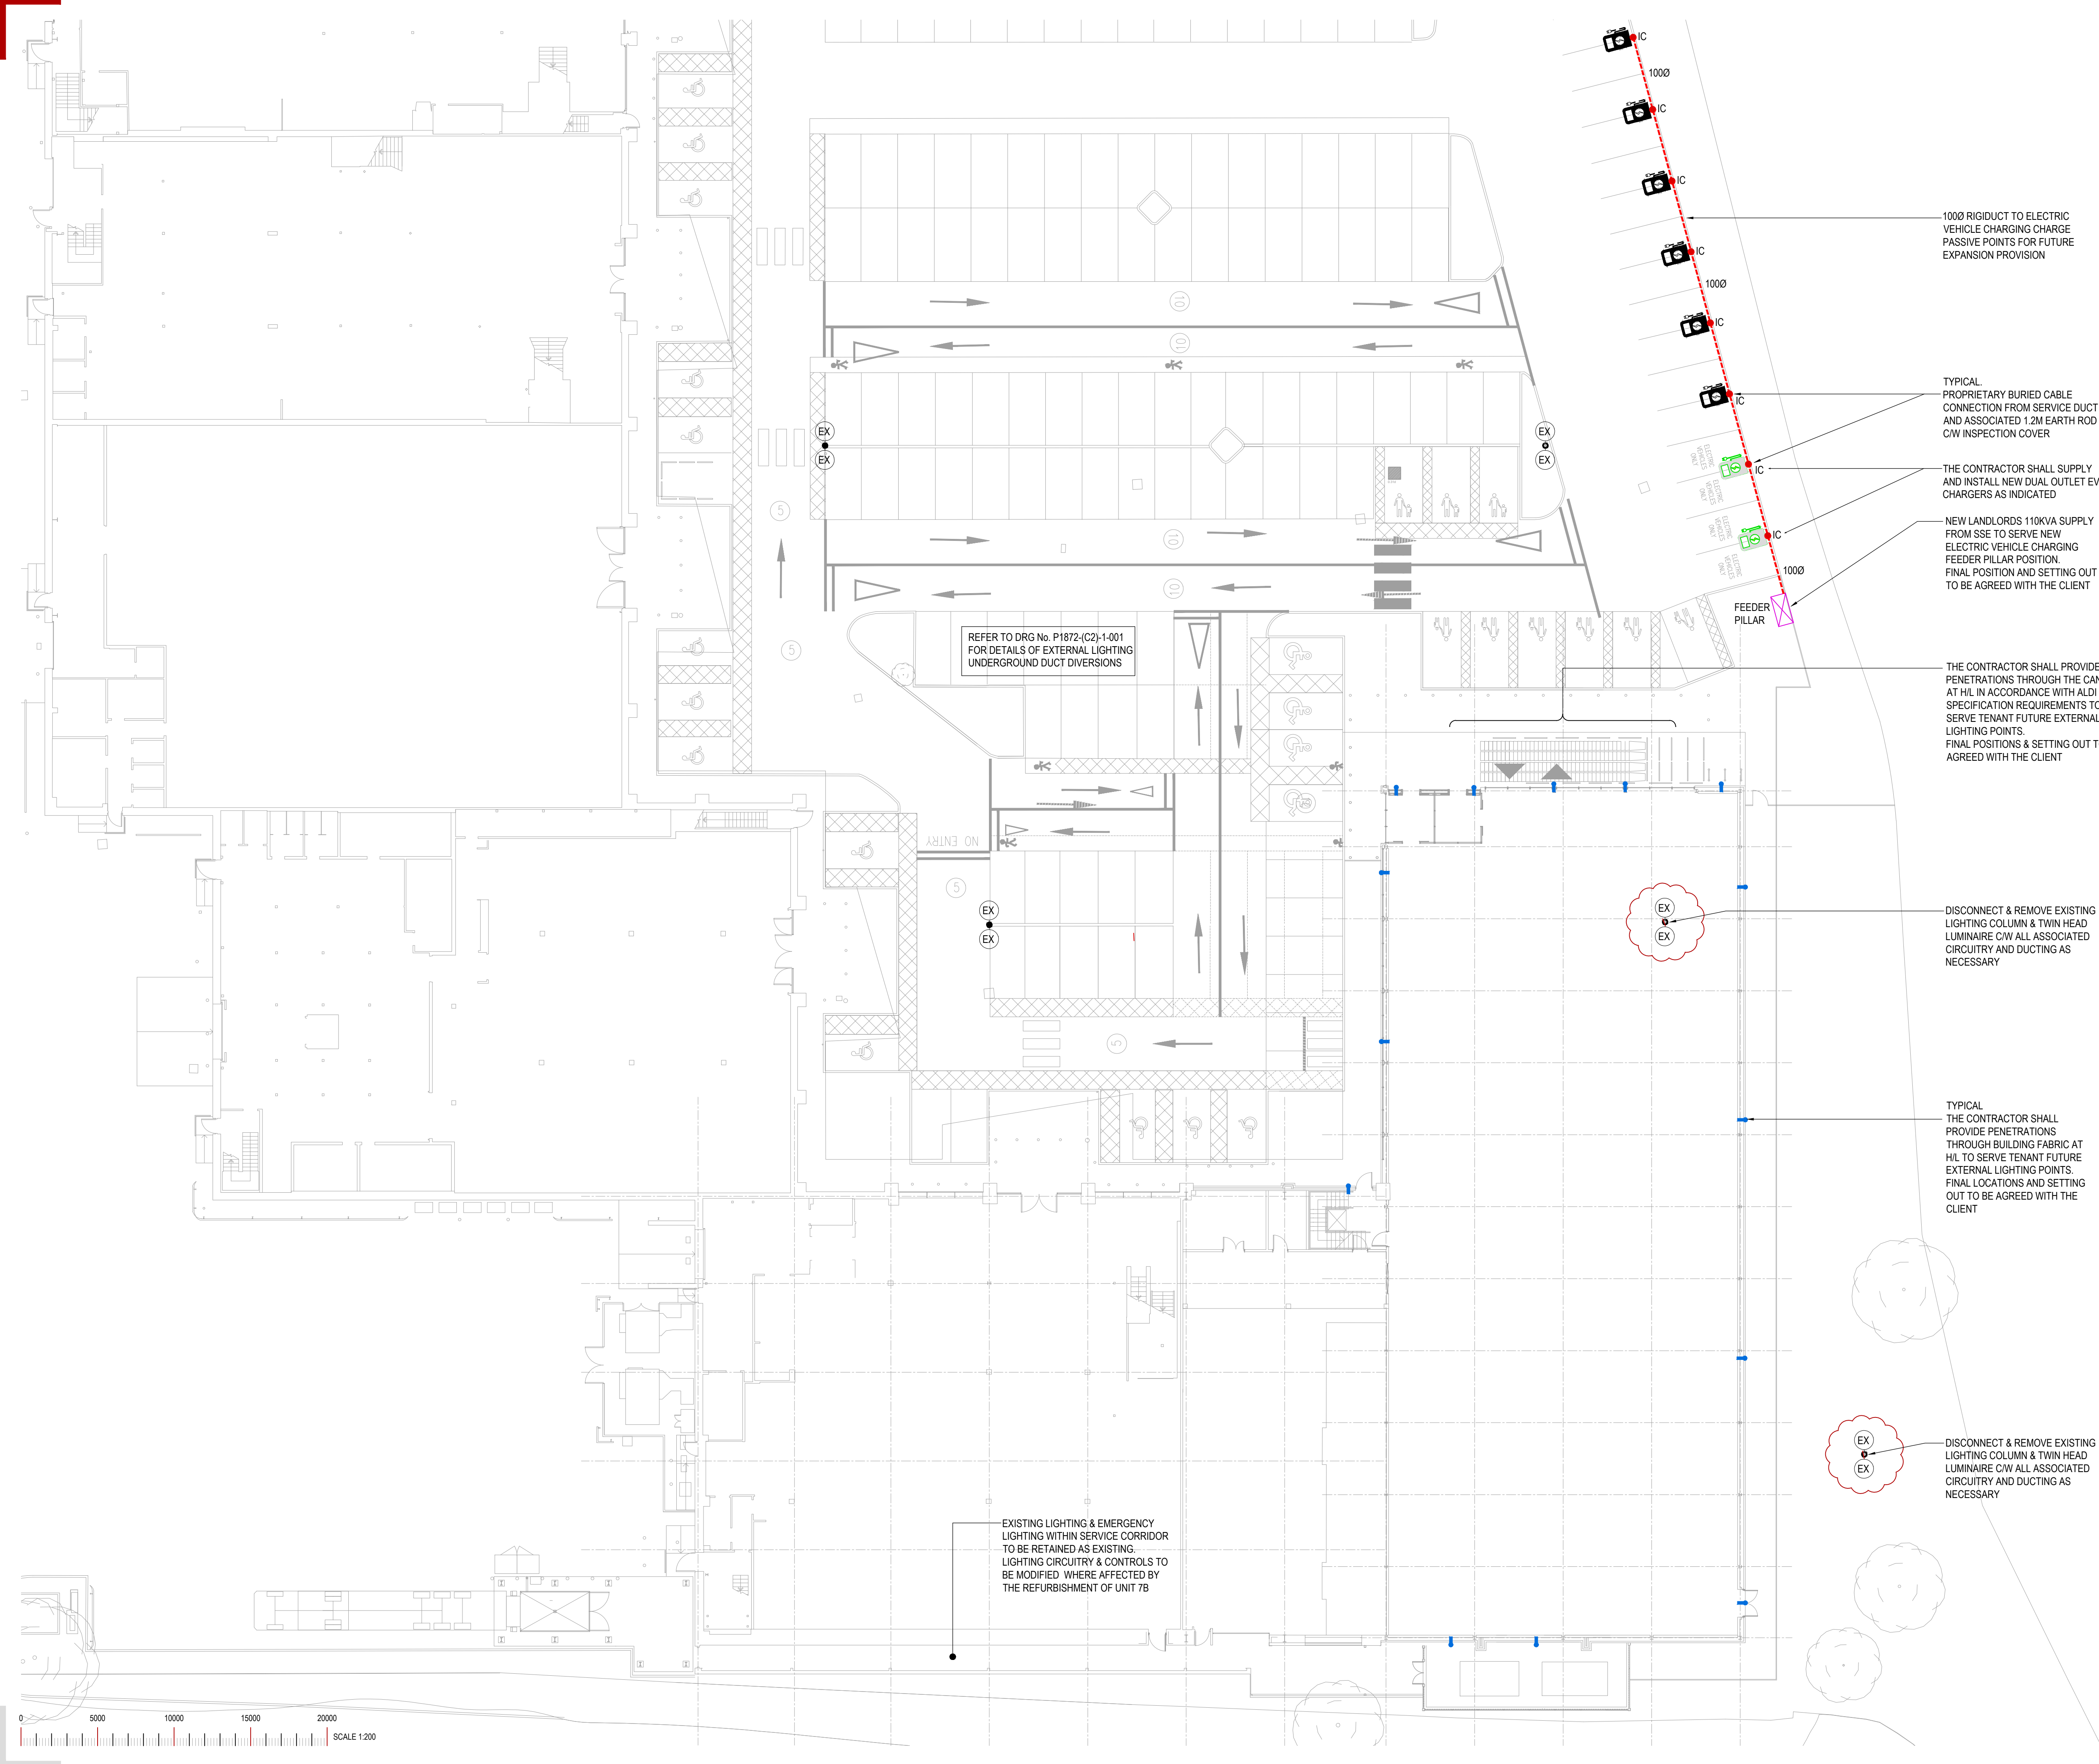

GENERAL NOTES

1. THIS DRAWING SHALL BE READ IN CONJUNCTION WITH ALL PROJECT RELEVANT QUINNROSS INFORMATION, THE CONTRACT SPECIFICATION, ALL ARCHITECTS & CONSULTANTS LATEST INFORMATION & ALL RELEVANT THIRD PARTY INFORMATION.
2. ALL DIMENSIONS ARE IN MILLIMETRES (mm) UNLESS OTHERWISE STATED.
3. PLEASE REFER TO ARCHITECTS SETTING OUT ARRANGEMENTS FOR FINAL LOCATION OF EQUIPMENT.
4. MEP SERVICES SHALL BE TESTED & COMMISSIONED IN ACCORDANCE WITH MEP SPECIFICATION.
5. THE CONTRACTOR SHALL UNDERTAKE A SURVEY OF THE EXISTING EXTERNAL LIGHTING INSTALLATION, IDENTIFYING AND VALIDATING THE EXISTING CARPARK EXTERNAL LIGHTING CIRCUITRY FROM POINT OF SUPPLY.
6. EXISTING EXTERNAL CARPARK LIGHTING CIRCUITS TO BE MODIFIED TO SUIT THE NEW BUILDING ARRANGEMENTS.
7. EXISTING RETAINED / RE-USED LIGHTING COLUMNS WITHIN THE DEVELOPMENT ZONE SHALL REDECORATED / OVERHAULED AND HEADS CLEANED AND RELAMPED TO ENSURE CORRECT OPERATION.

ELECTRICAL STANDARDS COMPLIANCE

THE COMPLETE ELECTRICAL SYSTEM AND ASSOCIATED SERVICES WILL BE SUPPLIED INSTALLED, TESTED, COMMISSIONED, SET TO WORK, DEMONSTRATED, ETC. BY THE CONTRACTOR IN ACCORDANCE WITH BUT NOT LIMITED TO THE CURRENT EDITIONS (INCLUDING AMENDMENTS) OF THE FOLLOWING:

- THE FULL EMPLOYER'S REQUIREMENTS AVAILABLE FROM THE MAIN CONTRACTOR
- ELECTRICAL SAFETY, QUALITY AND CONTINUITY REGULATIONS
- BRITISH STANDARDS AS APPROPRIATE
- HEALTH AND SAFETY AT WORK ACTS
- ELECTRICITY AT WORK ACT 1989
- OHSSE CODE FOR INTERIOR LIGHTING
- SLL LIGHTING GUIDES
- BS7671 - IET WIRING REGULATIONS 18TH EDITION, INCLUDING LATEST AMENDMENTS AND APPLICABLE GUIDANCE NOTES
- BS 5266 (LATEST EDITION)
- BS 9991 / 9999 (LATEST EDITION)
- BUILDING REGULATIONS APPROVED DOCUMENTS
- ALL APPLICABLE BUILDING REGULATIONS APPROVED DOCUMENTS INCLUDING PART L, PART M & PART P

EXTERNAL LIGHTING LEGEND

- EX EX EXISTING TWIN HEAD AMENITY LUMINAIRE MOUNTED ON 6M POLE TO BE RETAINED UNLESS NOTED OTHERWISE

ELECTRIC VEHICLE CHARGING

- 7.5KW EV DUAL CHARGE OUTLET - PASSIVE POINT
- 7.5KW EV DUAL CHARGE OUTLET - ACTIVE POINT
- IC PROPRIETARY BURIED CABLE CONNECTION FROM SERVICE DUCT AND ASSOCIATED 1.2M EARTH ROD C/W INSPECTION COVER
- LANDLORDS 110KVA FEEDER PILLAR POSITION

T1	30.09.20	TENDER ISSUE	GD	SQ
P1	20.08.20	ISSUED FOR COMMENT	GD	SQ
REV	DATE	DESCRIPTION	DRN	CHK

THIS DRAWING IS THE PROPERTY OF QUINNROSS CONSULTANTS LTD. & IS ISSUED IN CONFIDENCE. IT MUST NOT BE COPIED OR DISCLOSED TO THIRD PARTIES WITHOUT WRITTEN PERMISSION OF THE COMPANY.

QuinnRoss
CONSULTANTS LTD

KENT | ME9 8NY
LONDON | N1 9JU
T: 01755 841035
W: www.quinnross.com
E: admin@quinnross.com

TENDER ISSUE

CLIENT
BRITISH AIRWAYS PENSION TRUSTEES LTD

PROJECT
HAYES BRIDGE RETAIL PARK
HAYES UB4 0RH
PROPOSED NEW RETAIL UNITS

TITLE
SITE PLAN
ELECTRICAL SERVICES
UNIT 7B - EXTERNAL LIGHTING AND
ELECTRIC VEHICLE CHARGING LAYOUT

SCALE	SIZE	PLOTTED
1:200	A1	GRAEME

DRAWING No.	REV
P1872-(E4)-1-001	T1