
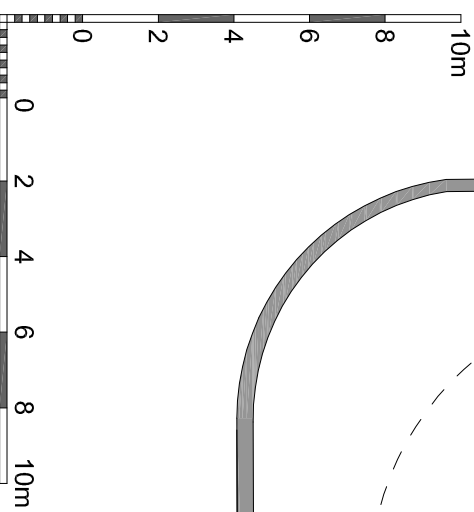


USE PRINTED DIMENSIONS ONLY, DO NOT SCALE FROM THE DRAWING. ALL DIMENSIONS IN METERS.
CHECKED BY THE ARCHITECT AND THE ENGINEER. THE DRAWING IS THE PROPERTY OF BROOKS MURRAY ARCHITECTS AND THE ENGINEER. IT IS NOT TO BE REPRODUCED OR TRANSMITTED IN ANY FORM OR BY ANY MEANS, ELECTRONIC OR MECHANICAL, INCLUDING PHOTOCOPYING, RECORDING, OR BY ANY INFORMATION STORAGE AND RETRIEVAL SYSTEM. THE USER OF THIS DRAWING SHALL BE RESPONSIBLE FOR OBTAINING ALL NECESSARY PERMITS AND APPROVALS FROM THE LOCAL AUTHORITY. THE USER SHALL BE RESPONSIBLE FOR OBTAINING ALL NECESSARY PERMITS AND APPROVALS FROM THE LOCAL AUTHORITY. THE USER SHALL BE RESPONSIBLE FOR OBTAINING ALL NECESSARY PERMITS AND APPROVALS FROM THE LOCAL AUTHORITY.

REV.	AMENDMENT	BY:	DATE
------	-----------	-----	------

EVCP	Electrical vehicle charging point
Parking schedule (Basement&Ground Floor)	
80 Total Car Parking Spacings (1.9 per flat)	
16 EV Parking Spaces (every 5 spaces)	
42 Bike Parking Spaces (1per flat)	
8 Accessible Parking Spacings (10 % of total)	

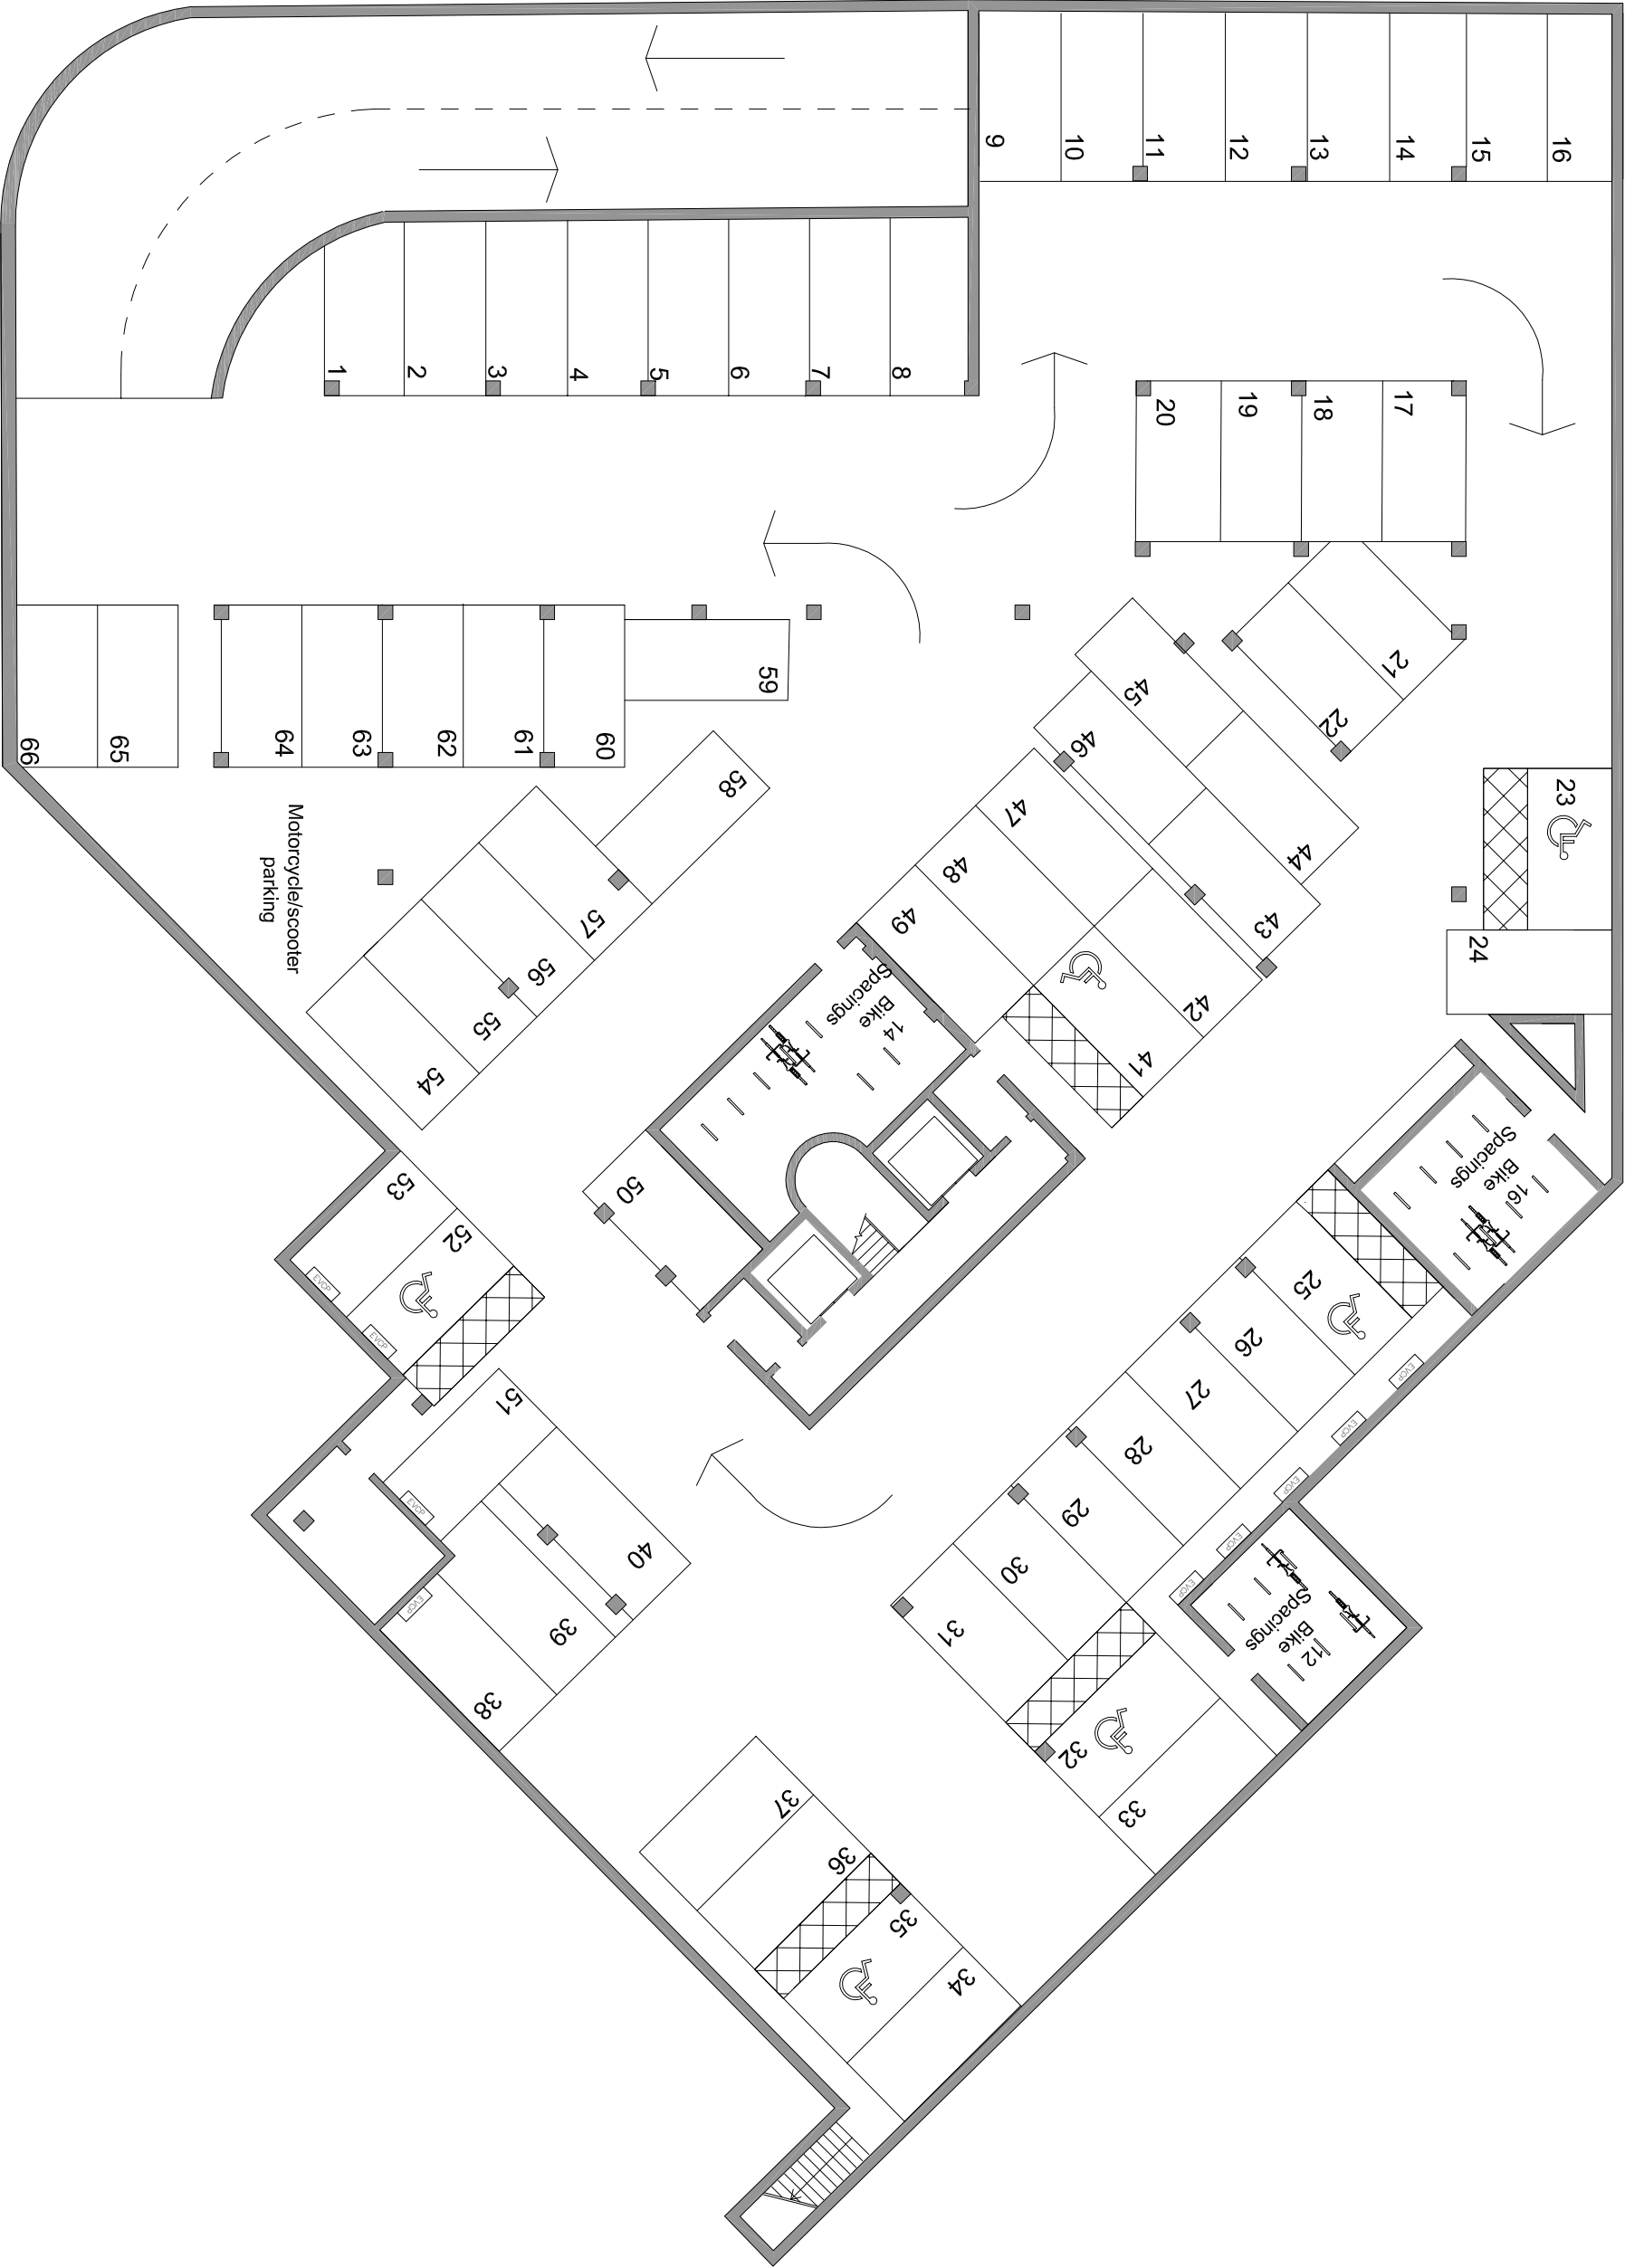

1

Brooks Murray Architects
8-10 New North Place, London EC2A 4JA
+44 (0)2077399955
architects@brooks-murray.co.uk

**brooks
murray**

CLIENT:

JOB:
Q-House
Heathrow UB3 5AR

DRAWING TITLE:
Basement Floor Plan

SCALE:
1:200 @ A3
DATE:
NOV 2016
STATUS:
Planning
DRAWING NUMBER: REV. CM
ISSUED BY:
SK-030