


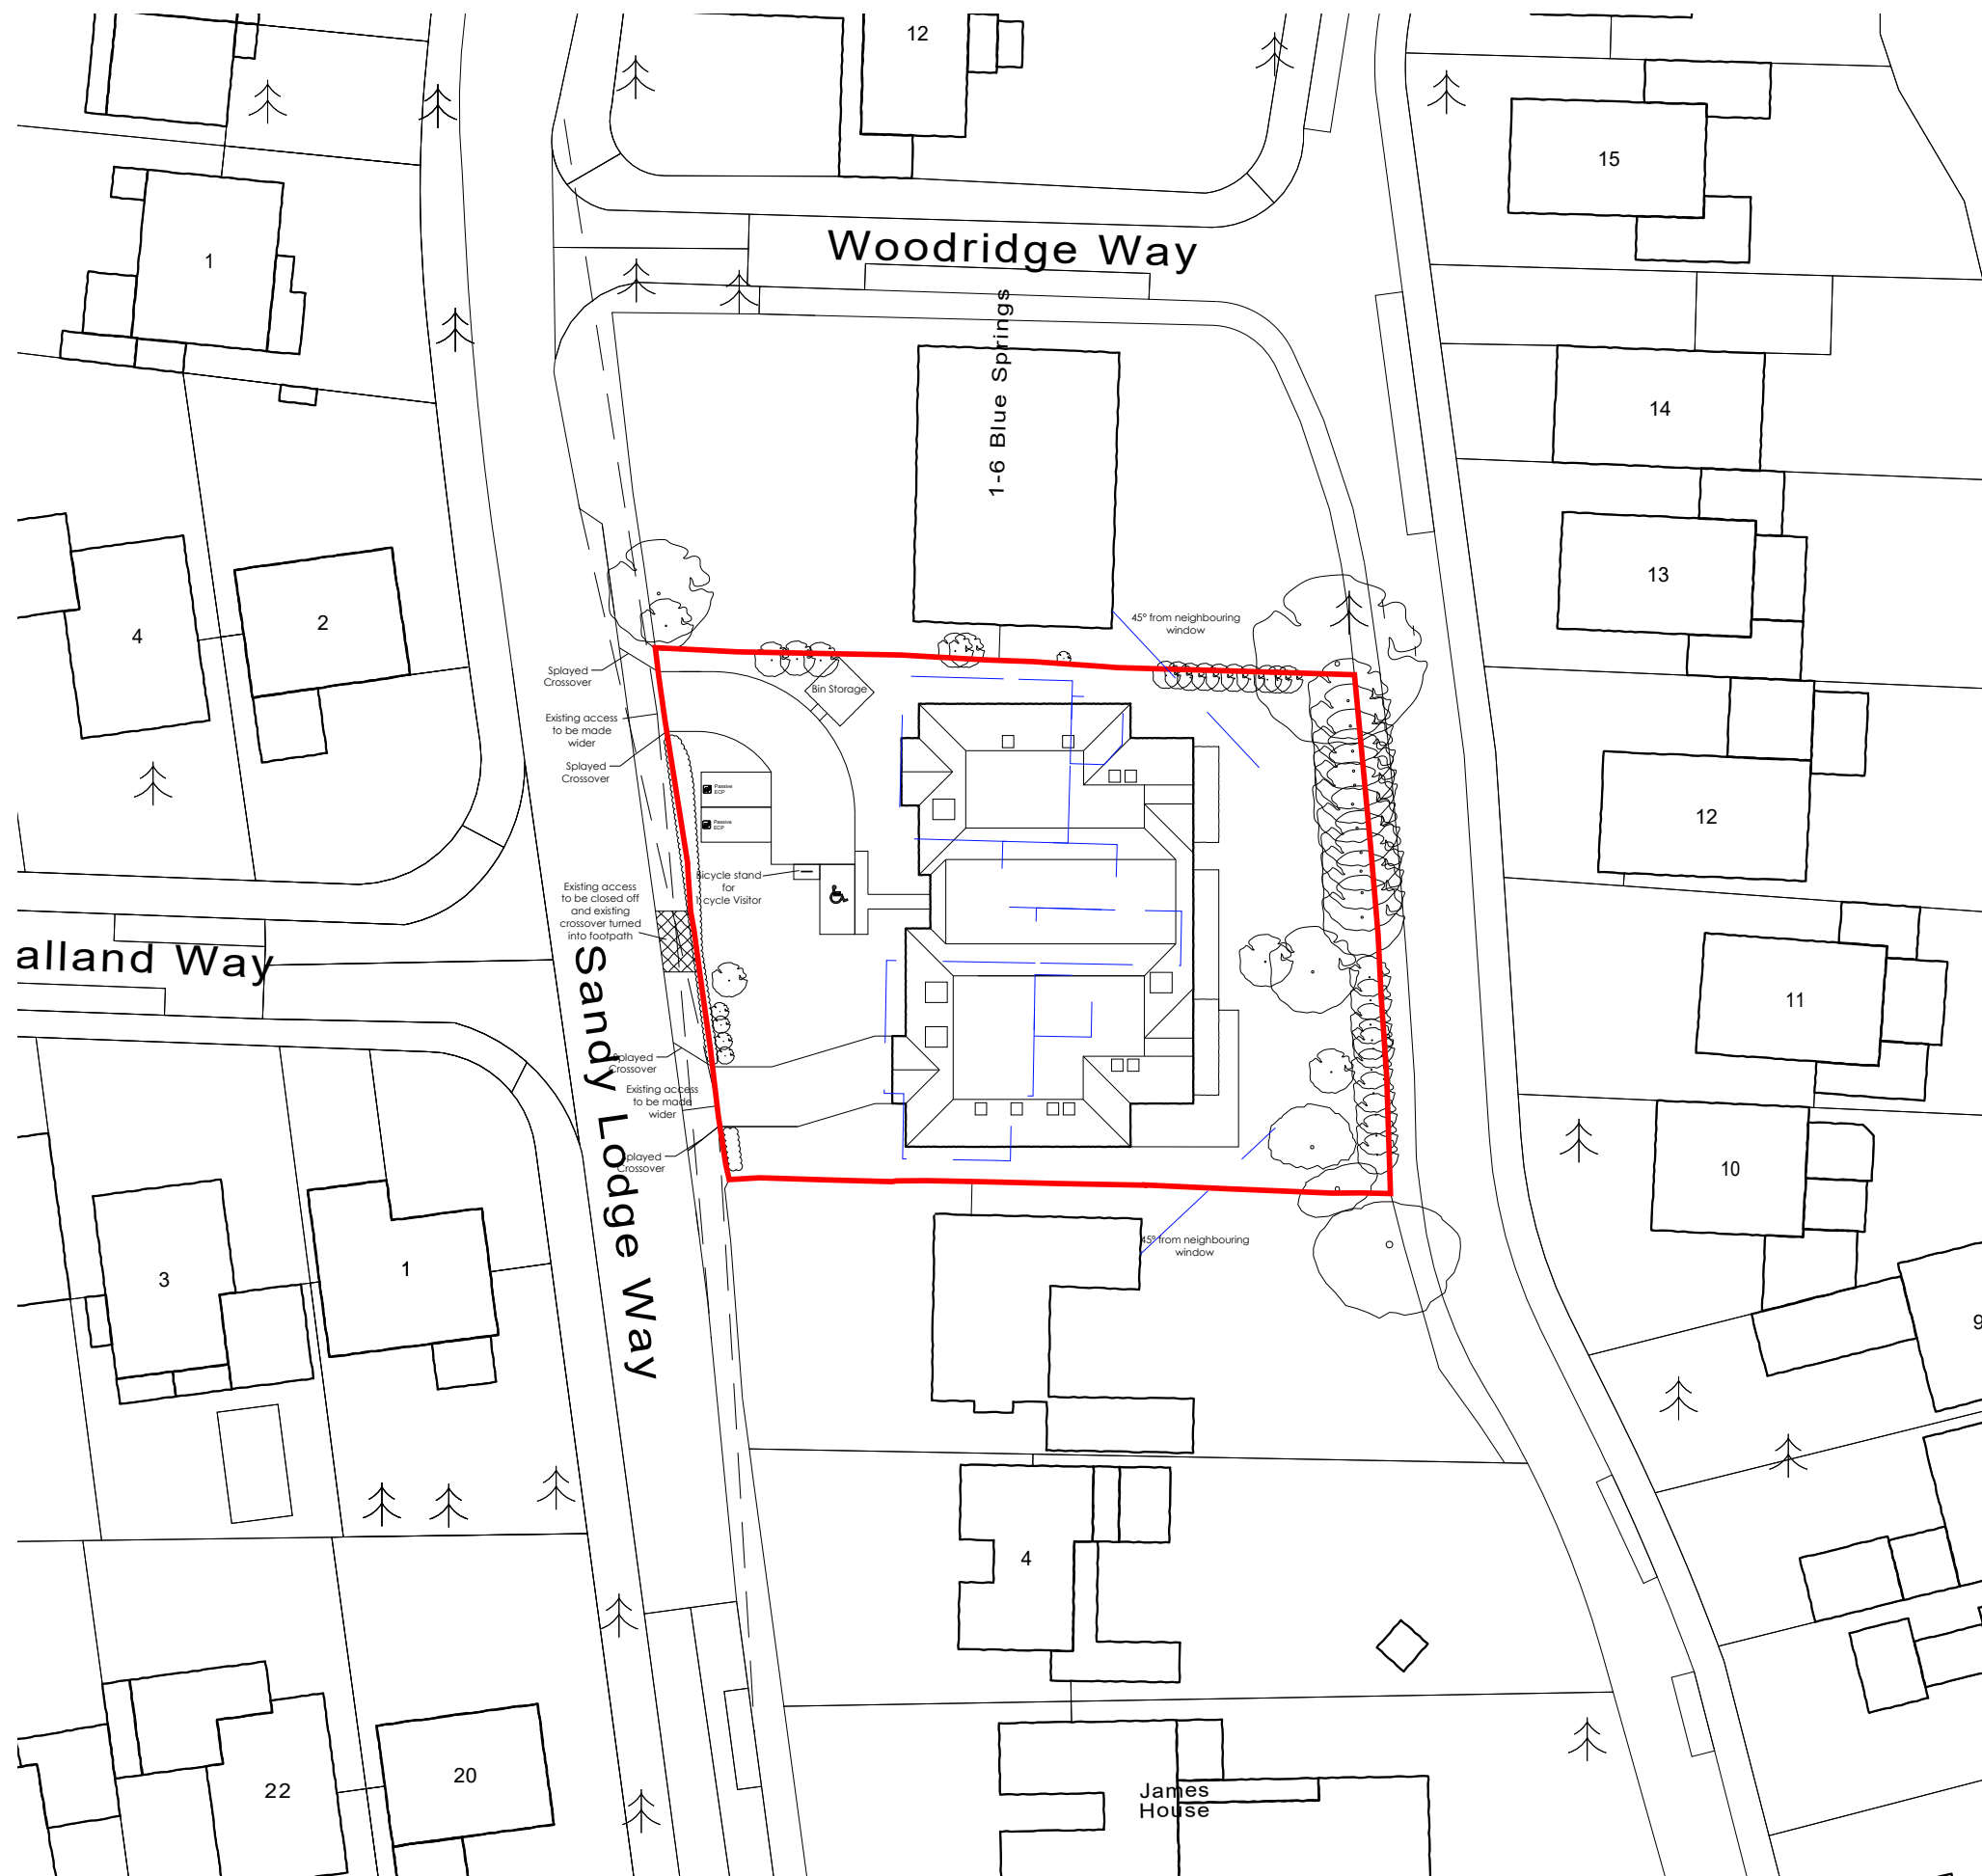


Rev	Date	Description



FLUENT
ARCHITECTURAL DESIGN SERVICES
221 CLARE ROAD, STAINES,
MIDDLESEX, TW19 7EF
TEL: 01784 391674 MOB: 07841 848473
E-MAIL: TOMMILLIN@FLUENT-ADS.CO.UK
WEB: FLUENT-ADS.CO.UK

8-10 Sandy Lodge Way
Northwood

 Site Plan



Scale 1:500@A3	Dwg No. FLU.587.02
Date 18.04.16	Rev S
Drawn N.Millin	