
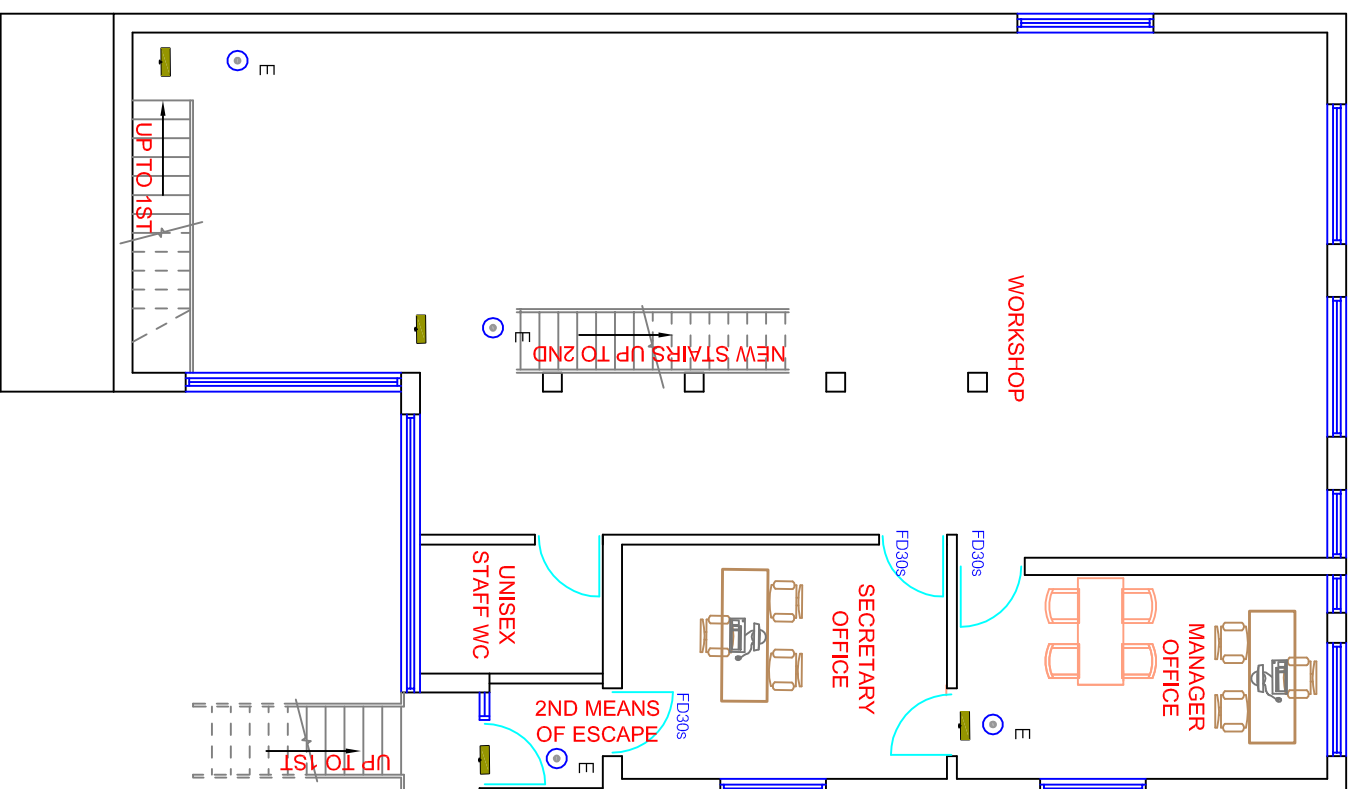


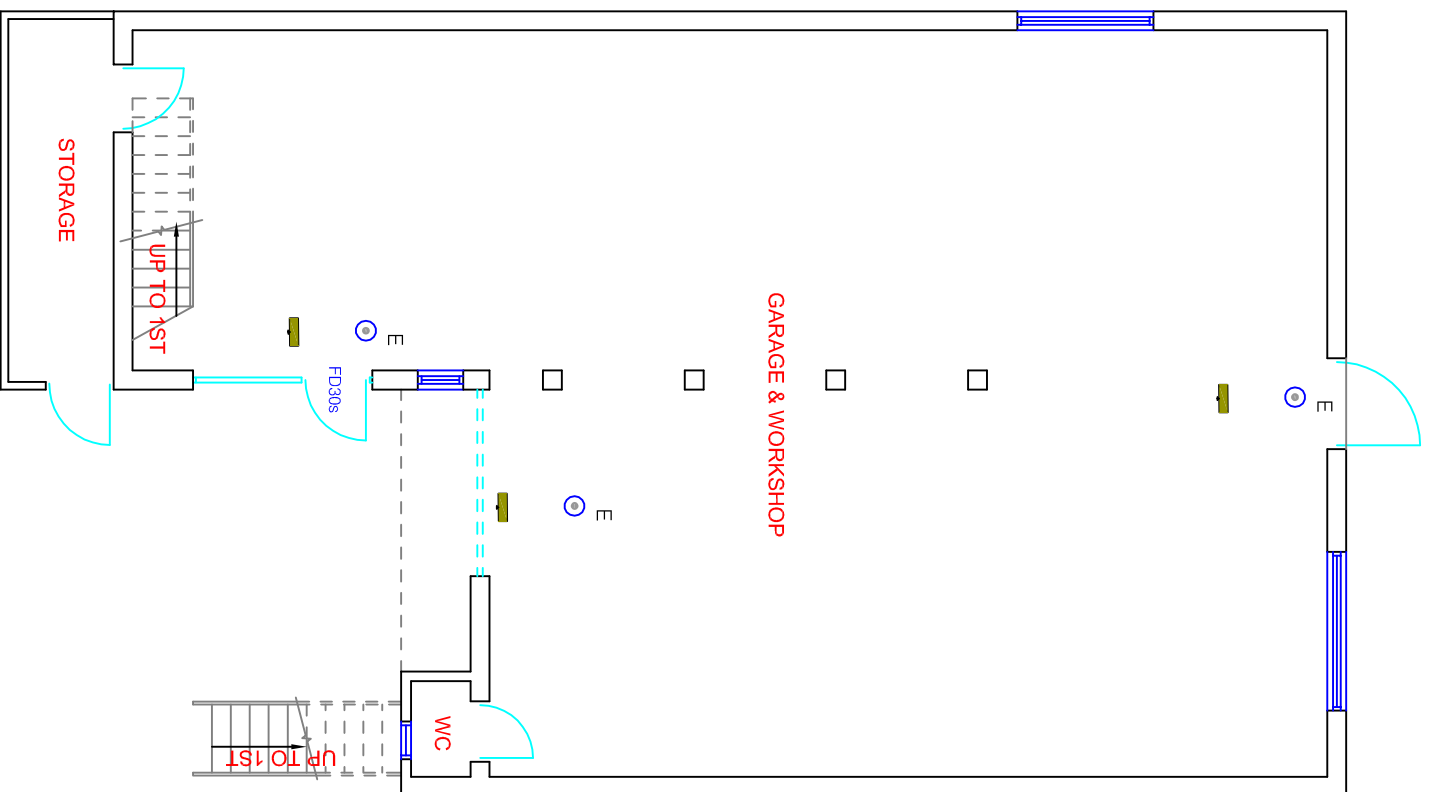

- h: HEAT DETECTORS TO ALL KITCHEN AREAS & CONNECTED TO SMOKE DETECTORS CIRCUIT
- S: SMOKE DETECTOR SYSTEM CONNECTED TO INDEPENDENT CIRCUIT & BRITISH STANDARDS
- ⬤ MECHANICAL EXTRACT FANS, KITCHEN WITH (30L/s) & BATH AREAS TO BE 15L/s EXTRACT FAN FITTED TO LIGHT SWITCH WITH 15MINUTES OVER RUN IN ACCORDANCE TO APPROVED DOC-F
- ⦿ EMERGENCY FIRE ESCAPE SIGNAGE WITH EMERGENCY LIGHT FITTING TO INDEPENDANT CIRCUIT LINKED WITH FIRE ALARM SYSTEM

PROPOSED GROUND FLOOR PLAN

PREMISES USED AS SUI GENERIS

GROUND FLOOR G.I.A: 140m-sq TO BE RETAINED

PROPOSED FIRST FLOOR PLAN

PREMISES USED AS SUI GENERIS

FIRST FLOOR G.I.A: 140m-sq TO BE RETAINED

			
HOMES DESIGN			
www.homesdesignltd.co.uk			
email: info@homesdesignltd.co.uk			
40 WISE LANE MILL HILL LONDON NW7 2RE			
title PROPOSED GROUND AND FIRST FLOOR PLANS		project 75 A - BRIDGE ROAD - UXBRIDGE - MIDDLESEX UB8 2QW	
drawing no ABC78/1002	contract no. ABC78	scale 1:100 @ A3	date 03/2018
drawn by R. L			

