
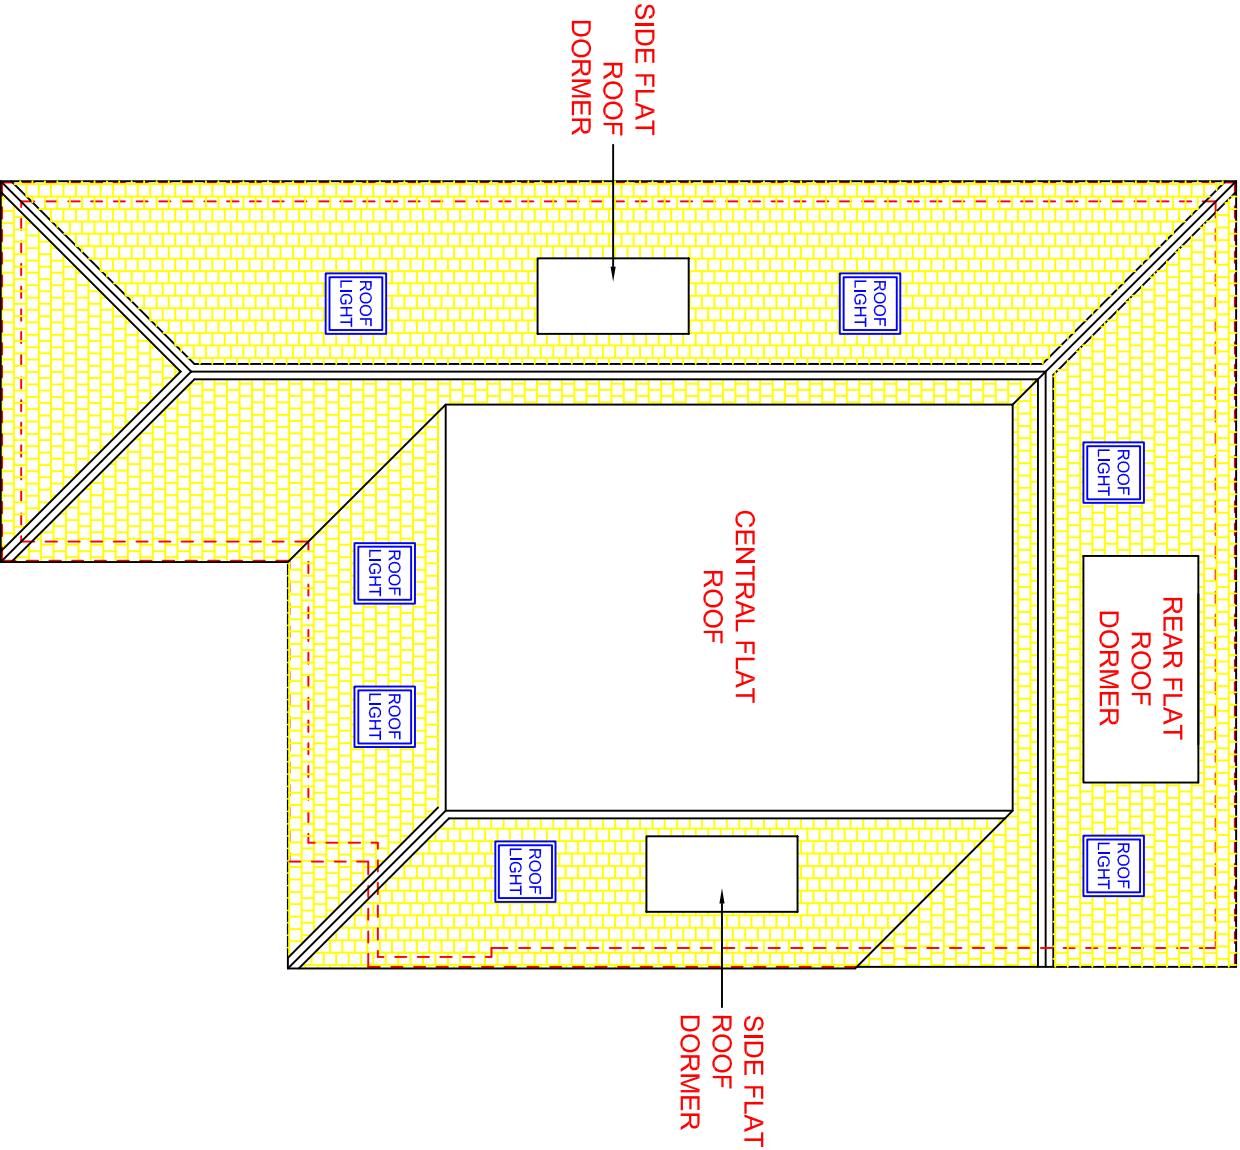


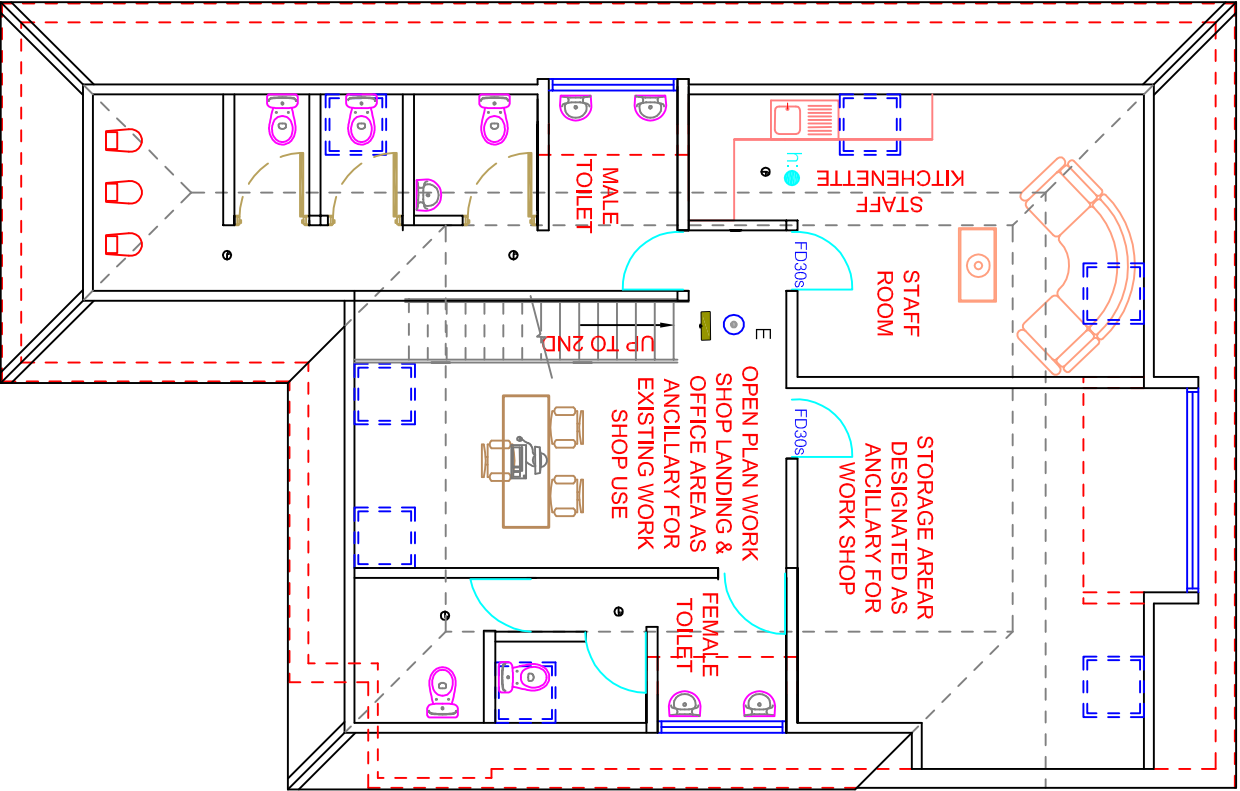

h:●HEAT DETECTORS TO ALL KITCHEN AREAS & CONNECTED TO SMOKE DETECTORS CIRCUIT

S:●SMOKE DETECTOR SYSTEM CONNECTED TO INDEPENDENT CIRCUIT & BRITISH STANDARDS

MECHANICAL EXTRACT FANS. KITCHEN WITH (30L/s) & BATH AREAS TO BE 15L/s EXTRACT FAN FITTED TO LIGHT SWITCH WITH 15MINUTES OVER RUN IN ACCORDANCE TO APPROVED DOC-F

EMERGENCY FIRE ESCAPE SIGNAGE WITH EMERGENCY LIGHT FITTING TO INDEPENDANT CIRCUIT LINKED WITH FIRE ALARM SYSTEM

PROPOSED LOFT PLAN

PREMISES USED AS SUI GENERIS
PROPOSED LOFT FLOOR G.I.A:
98m-sq TO BE RETAINED

PROPOSED ROOF PLAN

HOMES DESIGN	40 WISE LANE	title		PROPOSED LOFT & ROOF PLANS	
	MILL HILL LONDON NW7 2RE	project	75 A - BRIDGE ROAD - UXBRIDGE - MIDDLESEX UB8 2QW		
	email: info@homedesignltd.co.uk	drawing no	ABC78/1003	rev:	scale 1:100 @ A3
	www.homedesignltd.co.uk	drawn by R. L	contract no.	ABC78	date 03/2018

