


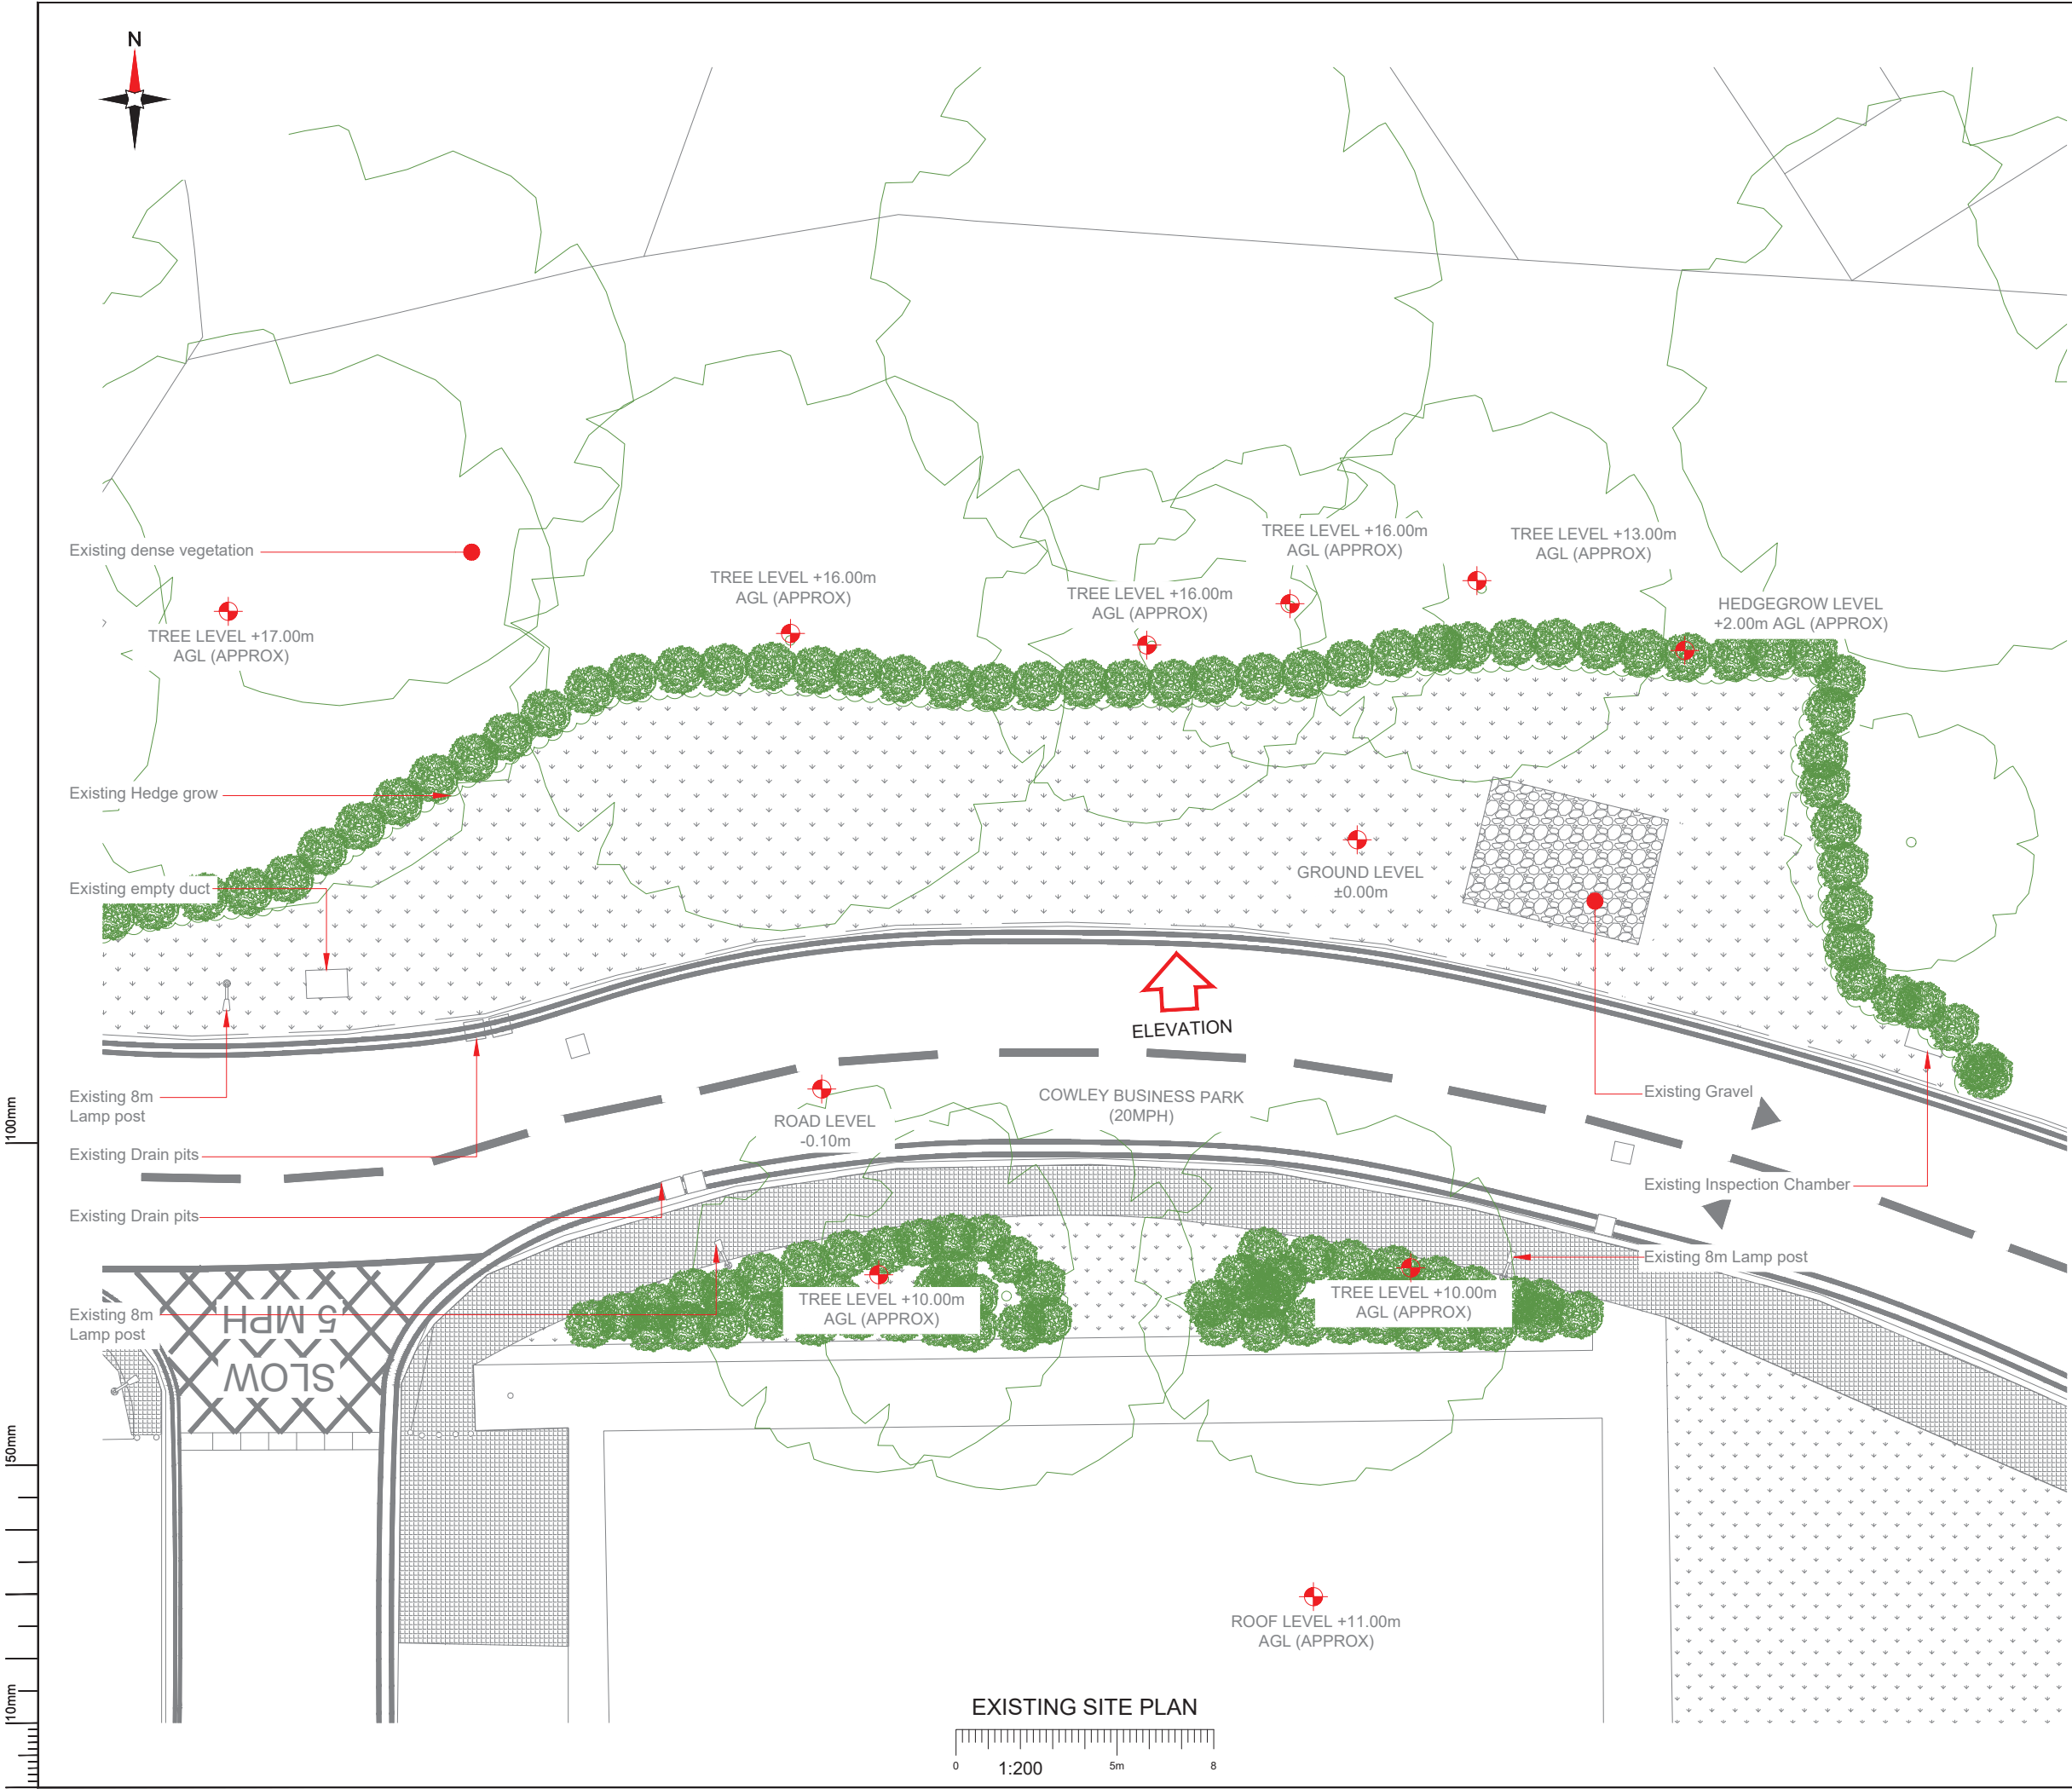

NOTES:

1. ALL DIMENSIONS IN MM UNLESS OTHERWISE NOTED.

Master:	MBNL / EE / H3G:	Project:	Purpose of Issue:	Issue:
M001	MBNL	NTQ	GA	A
Date:	22/05/2020	Revision / Upgrade Description:		
Drawn:	SKA	First Issue - Site nomination dated: 20-09-19		
Checked:	ABB			
Approved:	F Dejene			

Hutchison 3G UK Limited
Star House, 20 Grenfell Road
Maidenhead, SL6 1EH
Tel: 01628 765 000
Fax: 01628 765 001

H3G Base Station Information line:
0845 6043000
Available 8am-8pm Monday to Friday

Hatfield Business Park
Hatfield
Hertfordshire
AL10 9BW

Tel: 01707 315000
Fax: 01707 319001

Mobile Broadband Network Limited
Sixth Floor, Thames Tower, Station Road, Reading, RG1 1LX


Design Consultant & Principal Contractor:

WALDON TELECOM
PHOENIX HOUSE
PYRFORD ROAD
WEST BYFLEET
SURREY
KT14 6RA

TEL : 01932 411011
FAX : 01932 411012

Site Name:		
COWLEY BUSINESS PARK		
Site ID:		
1549968		
Address:		
COWLEY BUSINESS PARK UXBRIDGE LONDON UB8 2AD		
Title:		
100 EXISTING SITE PLAN		
Project:		
NTQ		
Purpose of Issue:		
GENERAL ARRANGEMENT		
EE Cell ID:	MBNL Cell ID:	3UK Cell ID:
77573	HGN247	UB0281
Master Drawing No:		Issue:
1549968_HGN247_77573_UB0281_M001		A

100mm
50mm
10mm

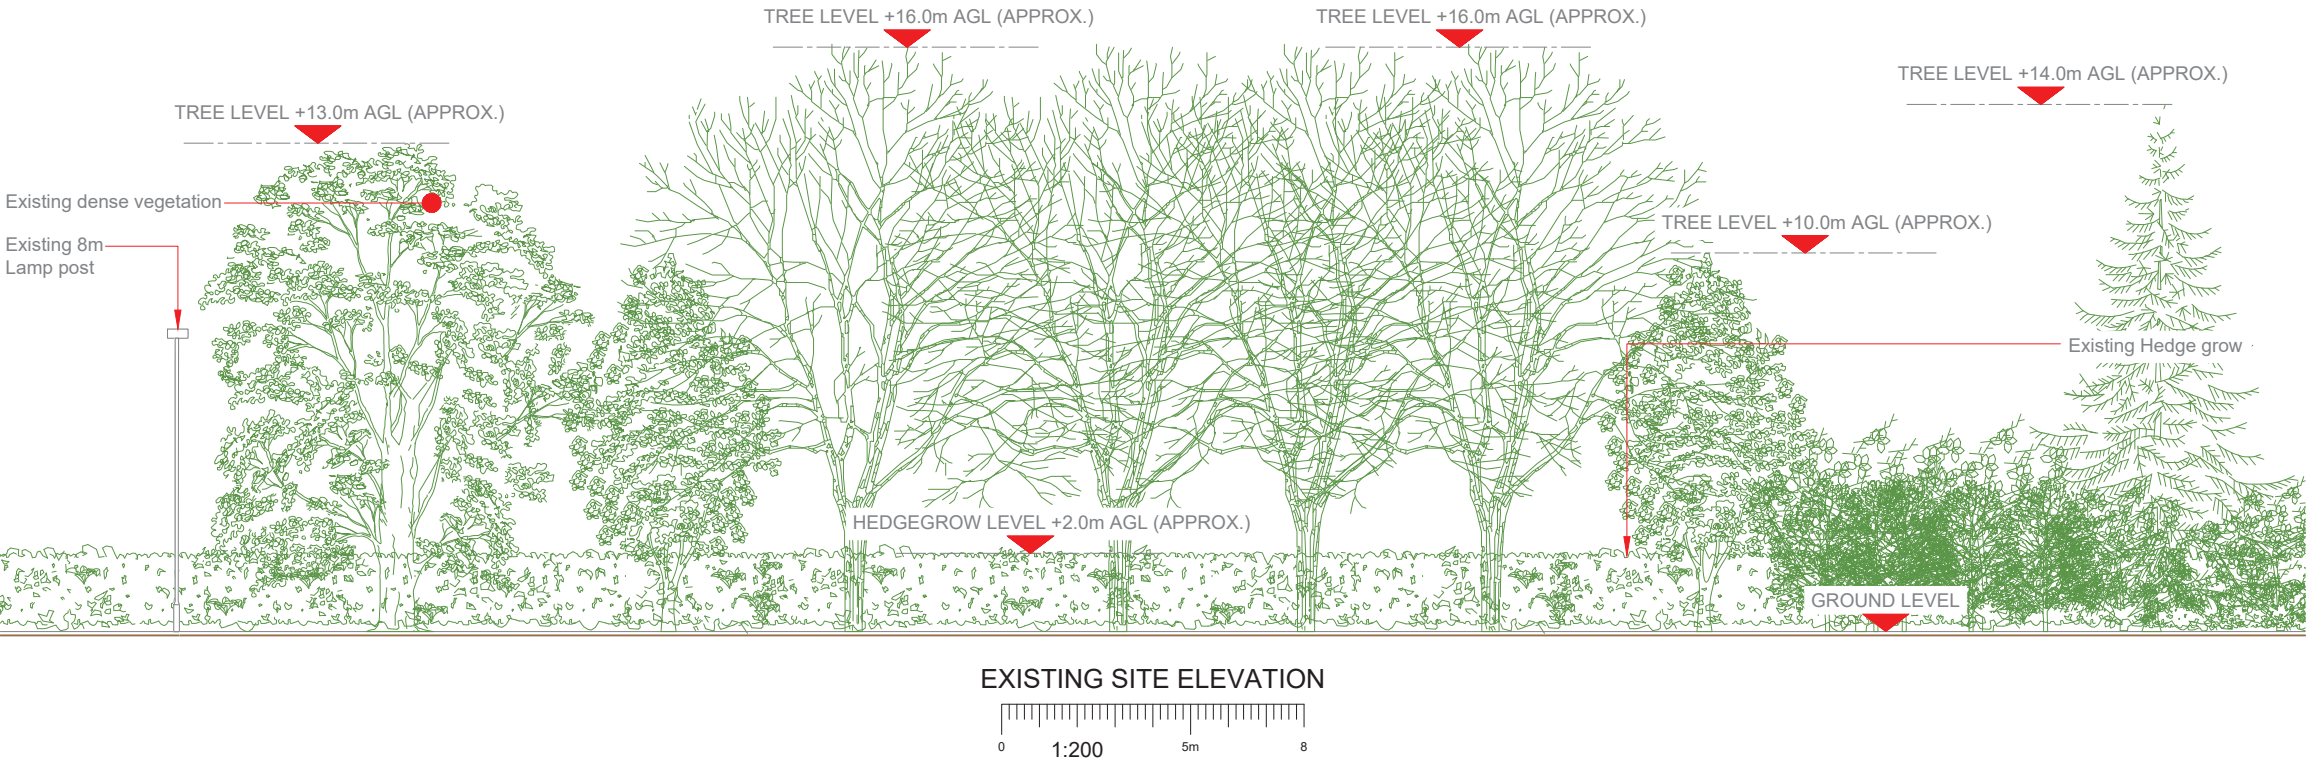

NOTES:

1. ALL DIMENSIONS IN MM UNLESS OTHERWISE NOTED.

Master:	MBNL / EE / H3G:	Project:	Purpose of Issue:	Issue:
M001	MBNL	NTQ	GA	A
Date:	22/05/2020	Revision / Upgrade Description:		
Drawn:	SKA	First Issue - Site nomination dated: 20-09-19		
Checked:	ABB			
Approved:	F Dejene			

Hutchison 3G UK Limited
Star House, 20 Grenfell Road
Maidenhead, SL6 1EH
Tel: 01628 765 000
Fax: 01628 765 001

H3G Base Station Information line:
0845 6043000
Available 8am-8pm Monday to Friday

Hatfield Business Park
Hatfield
Hertfordshire
AL10 9BW

Tel: 01707 315000
Fax: 01707 319001

Mobile Broadband Network Limited
Sixth Floor, Thames Tower, Station Road, Reading, RG1 1LX

Design Consultant & Principal Contractor:

WALDON TELECOM
PHOENIX HOUSE
PYRFORD ROAD
WEST BYFLEET
SURREY
KT14 6RA

TEL : 01932 411011
FAX : 01932 411012

Site Name:
COWLEY BUSINESS PARK

Site ID:
1549968

Address:
COWLEY BUSINESS PARK
UXBRIDGE
LONDON
UB8 2AD


Title:
150 EXISTING SITE ELEVATION

Project:
NTQ

Purpose of Issue:
GENERAL ARRANGEMENT

EE Cell ID: 77573	MBNL Cell ID: HGN247	3UK Cell ID: UB0281
----------------------	-------------------------	------------------------

Master Drawing No: 1549968_HGN247_77573_UB0281_M001	Issue: A
--	-------------

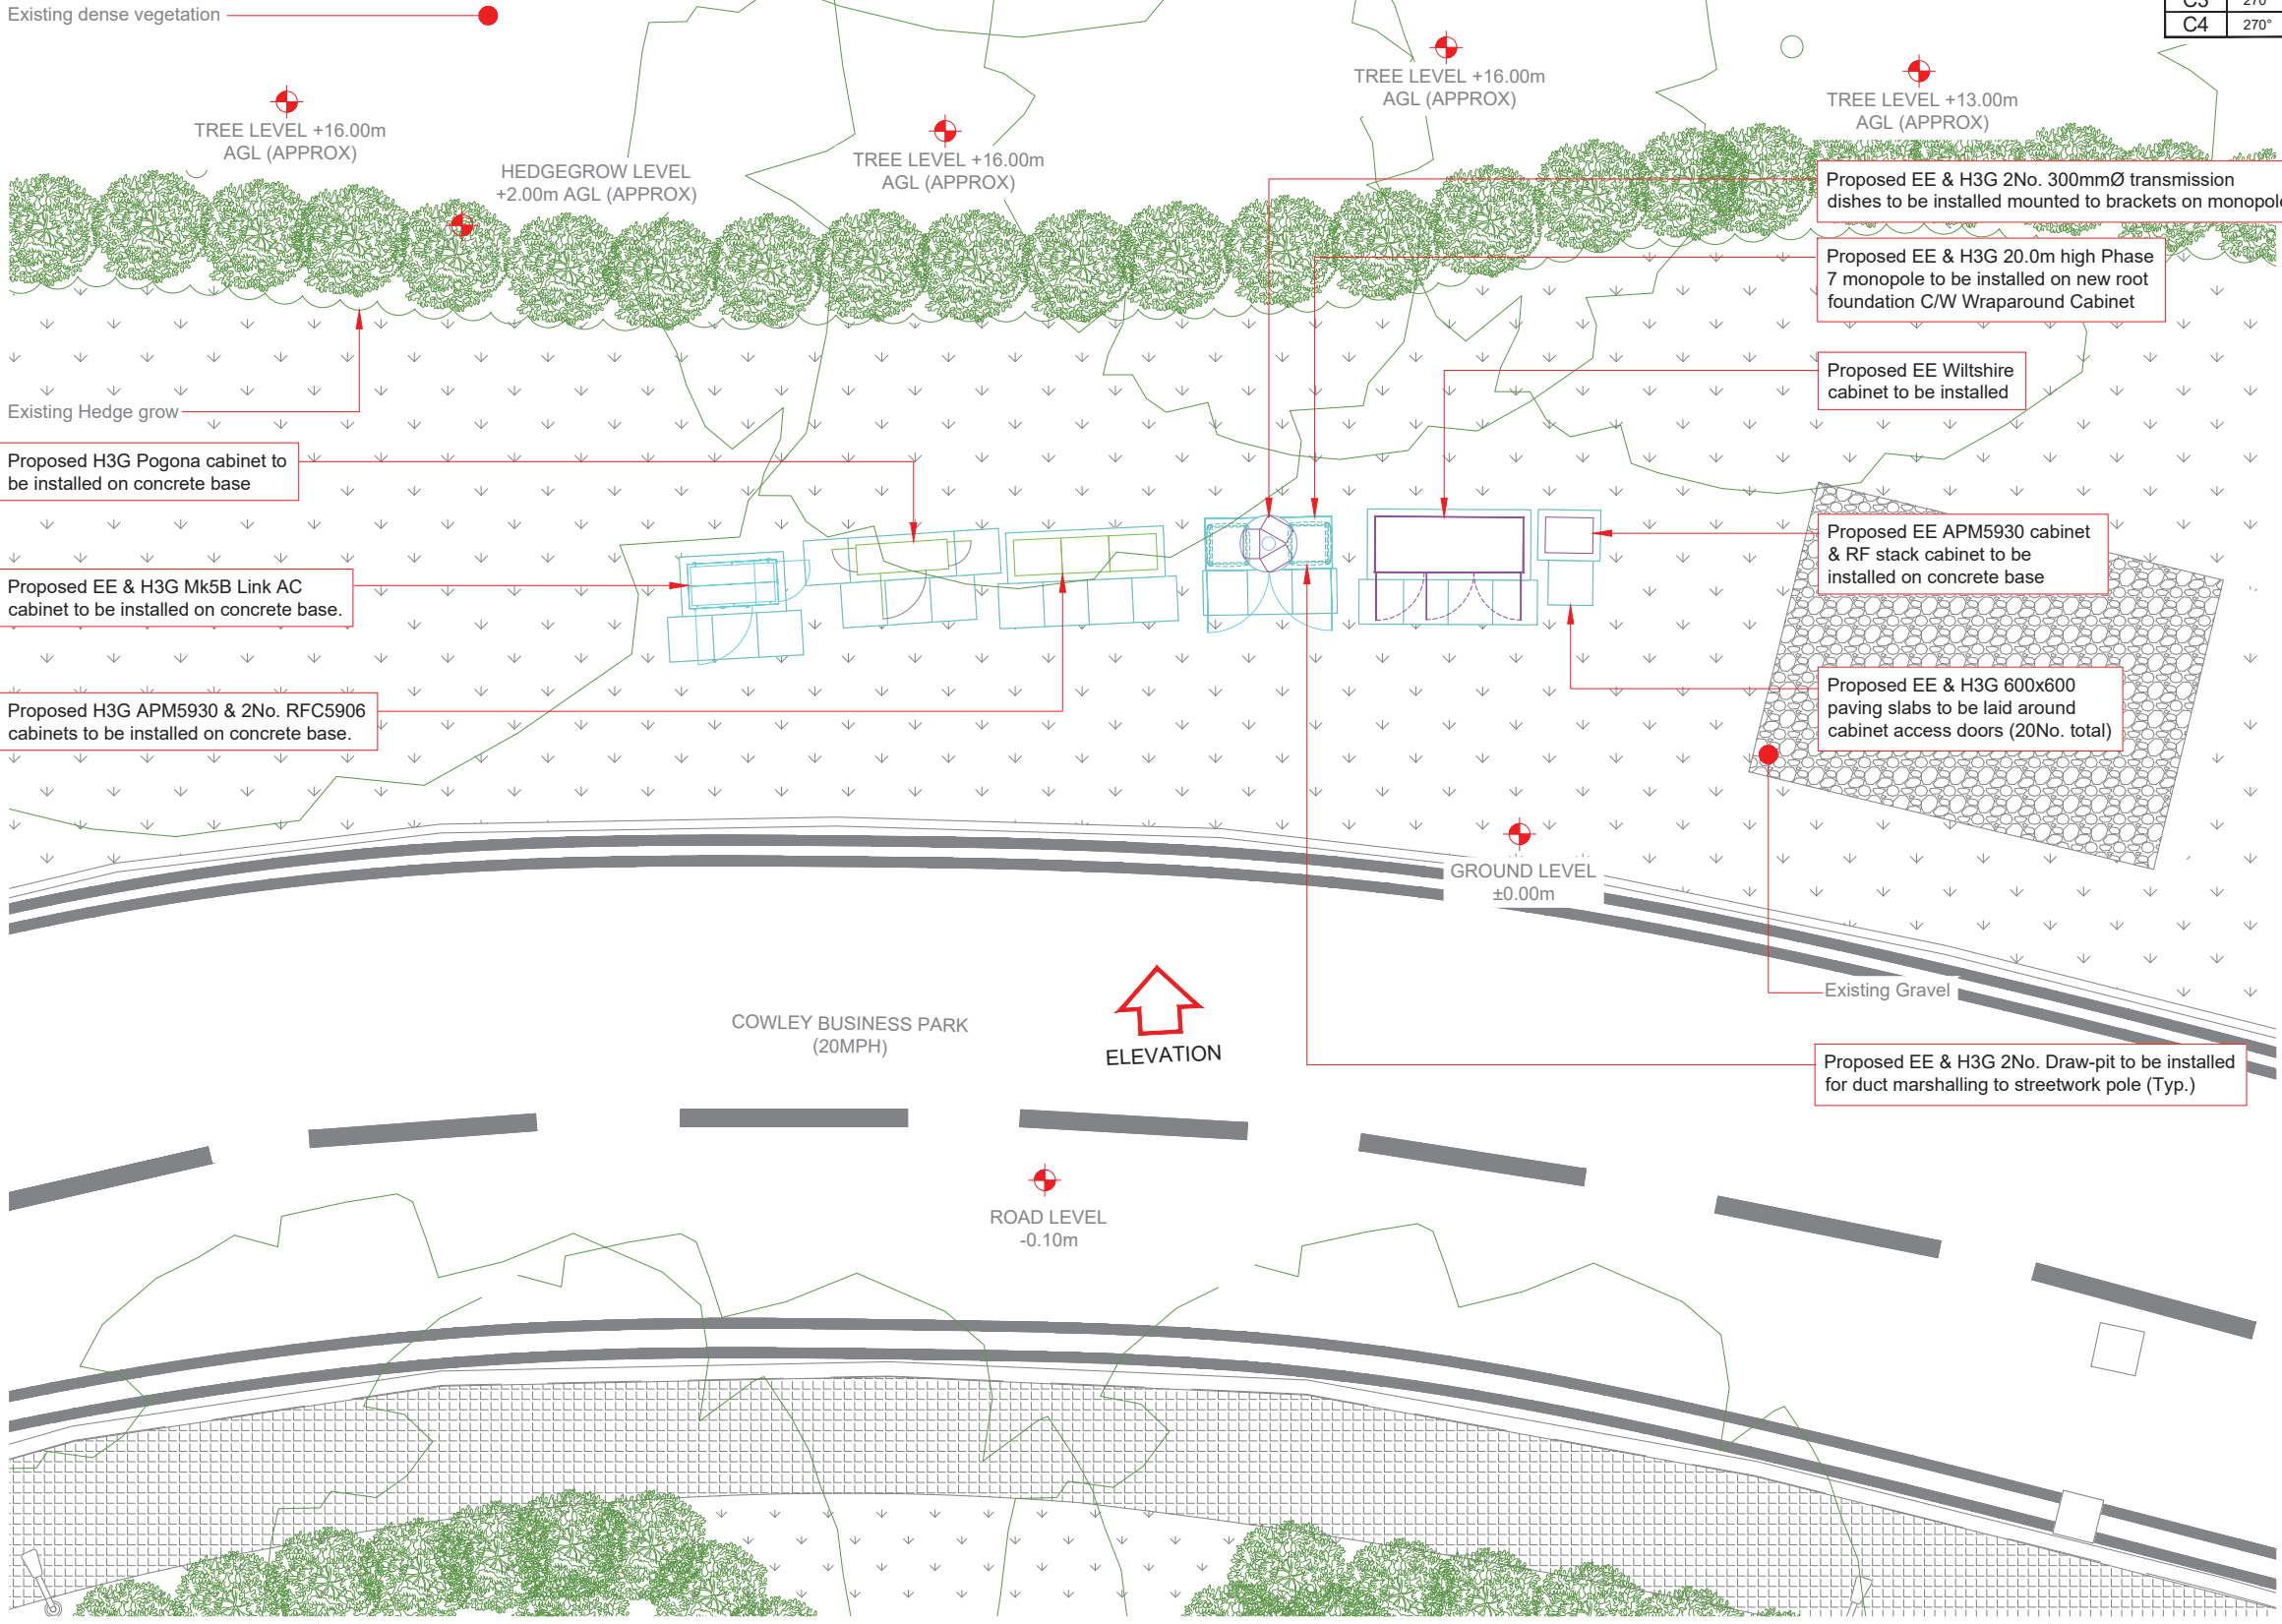

Proposed H3G Pogona cabinet to be installed on concrete base

Proposed EE & H3G Mk5B Link AC cabinet to be installed on concrete base.

Proposed H3G APM5930 & 2No. RFC5906 cabinets to be installed on concrete base.

Proposed EE & H3G 2No. 300mmØ transmission dishes to be installed mounted to brackets on monopole

Proposed EE & H3G 20.0m high Phase 7 monopole to be installed on new root foundation C/W Wraparound Cabinet

Proposed EE Wiltshire cabinet to be installed

Proposed EE APM5930 cabinet & RF stack cabinet to be installed on concrete base

Proposed EE & H3G 600x600 paving slabs to be laid around cabinet access doors (20No. total)

Proposed EE & H3G 2No. Draw-pit to be installed for duct marshalling to streetwork pole (Typ.)

Antenna Aperture ID	Proposed 4G/5G Bearing	Operator: Shared/ EE/H3G
A1	30°	EE
A2	30°	H3G
A3	30°	H3G/EE
A4	30°	H3G/EE
B1	150°	EE
B2	150°	H3G
B3	150°	H3G/EE
B4	150°	H3G/EE
C1	270°	EE
C2	270°	H3G
C3	270°	H3G/EE
C4	270°	H3G/EE

NOTES:
1. ALL DIMENSIONS IN MM UNLESS OTHERWISE NOTED.

Master: M001	MBNL / EE / H3G: MBNL	Project: NTQ	Purpose of Issue: GA	Issue: A
Date: 22/05/2020	Drawn: SKA	Checked: ABB	Approved: F Dejene	Revision / Upgrade Description: First Issue - Site nomination dated: 20-09-19



Hutchison 3G UK Limited
Star House, 20 Grenfell Road
Maidenhead, SL6 1E4
Tel: 01628 765 000
Fax: 01628 765 001

H3G Base Station Information line:
0845 6043000
Available 8am-8pm Monday to Friday



Hatfield Business Park
Hatfield
Hertfordshire
AL10 9BW

Tel: 01707 315000
Fax: 01707 319001



Mobile Broadband Network Limited
Sixth Floor, Thames Tower, Station Road, Reading, RG1 1LX

Design Consultant & Principal Contractor:



WALDON TELECOM
PHOENIX HOUSE
PYRFORD ROAD
WEST BYFLEET
SURREY
KT14 6RA

TEL : 01932 411011
FAX : 01932 411012


Site Name: COWLEY BUSINESS PARK		
Site ID: 1549968		
Address: COWLEY BUSINESS PARK UXBRIDGE LONDON UB8 2AD		
Title: 215 MAX CONFIGURATION SITE PLAN		
Project: NTQ		
Purpose of Issue: GENERAL ARRANGEMENT		
EE Cell ID: 77573	MBNL Cell ID: HGN247	3UK Cell ID: UB0281
Master Drawing No: 1549968_HGN247_77573_UB0281_M001		Issue: A

Passive Infrastructure Equipment Capacity & Lead Operator			
A	B	C	LEAD
HS2	HS2	HS2	TBC


100mm

50mm

10mm

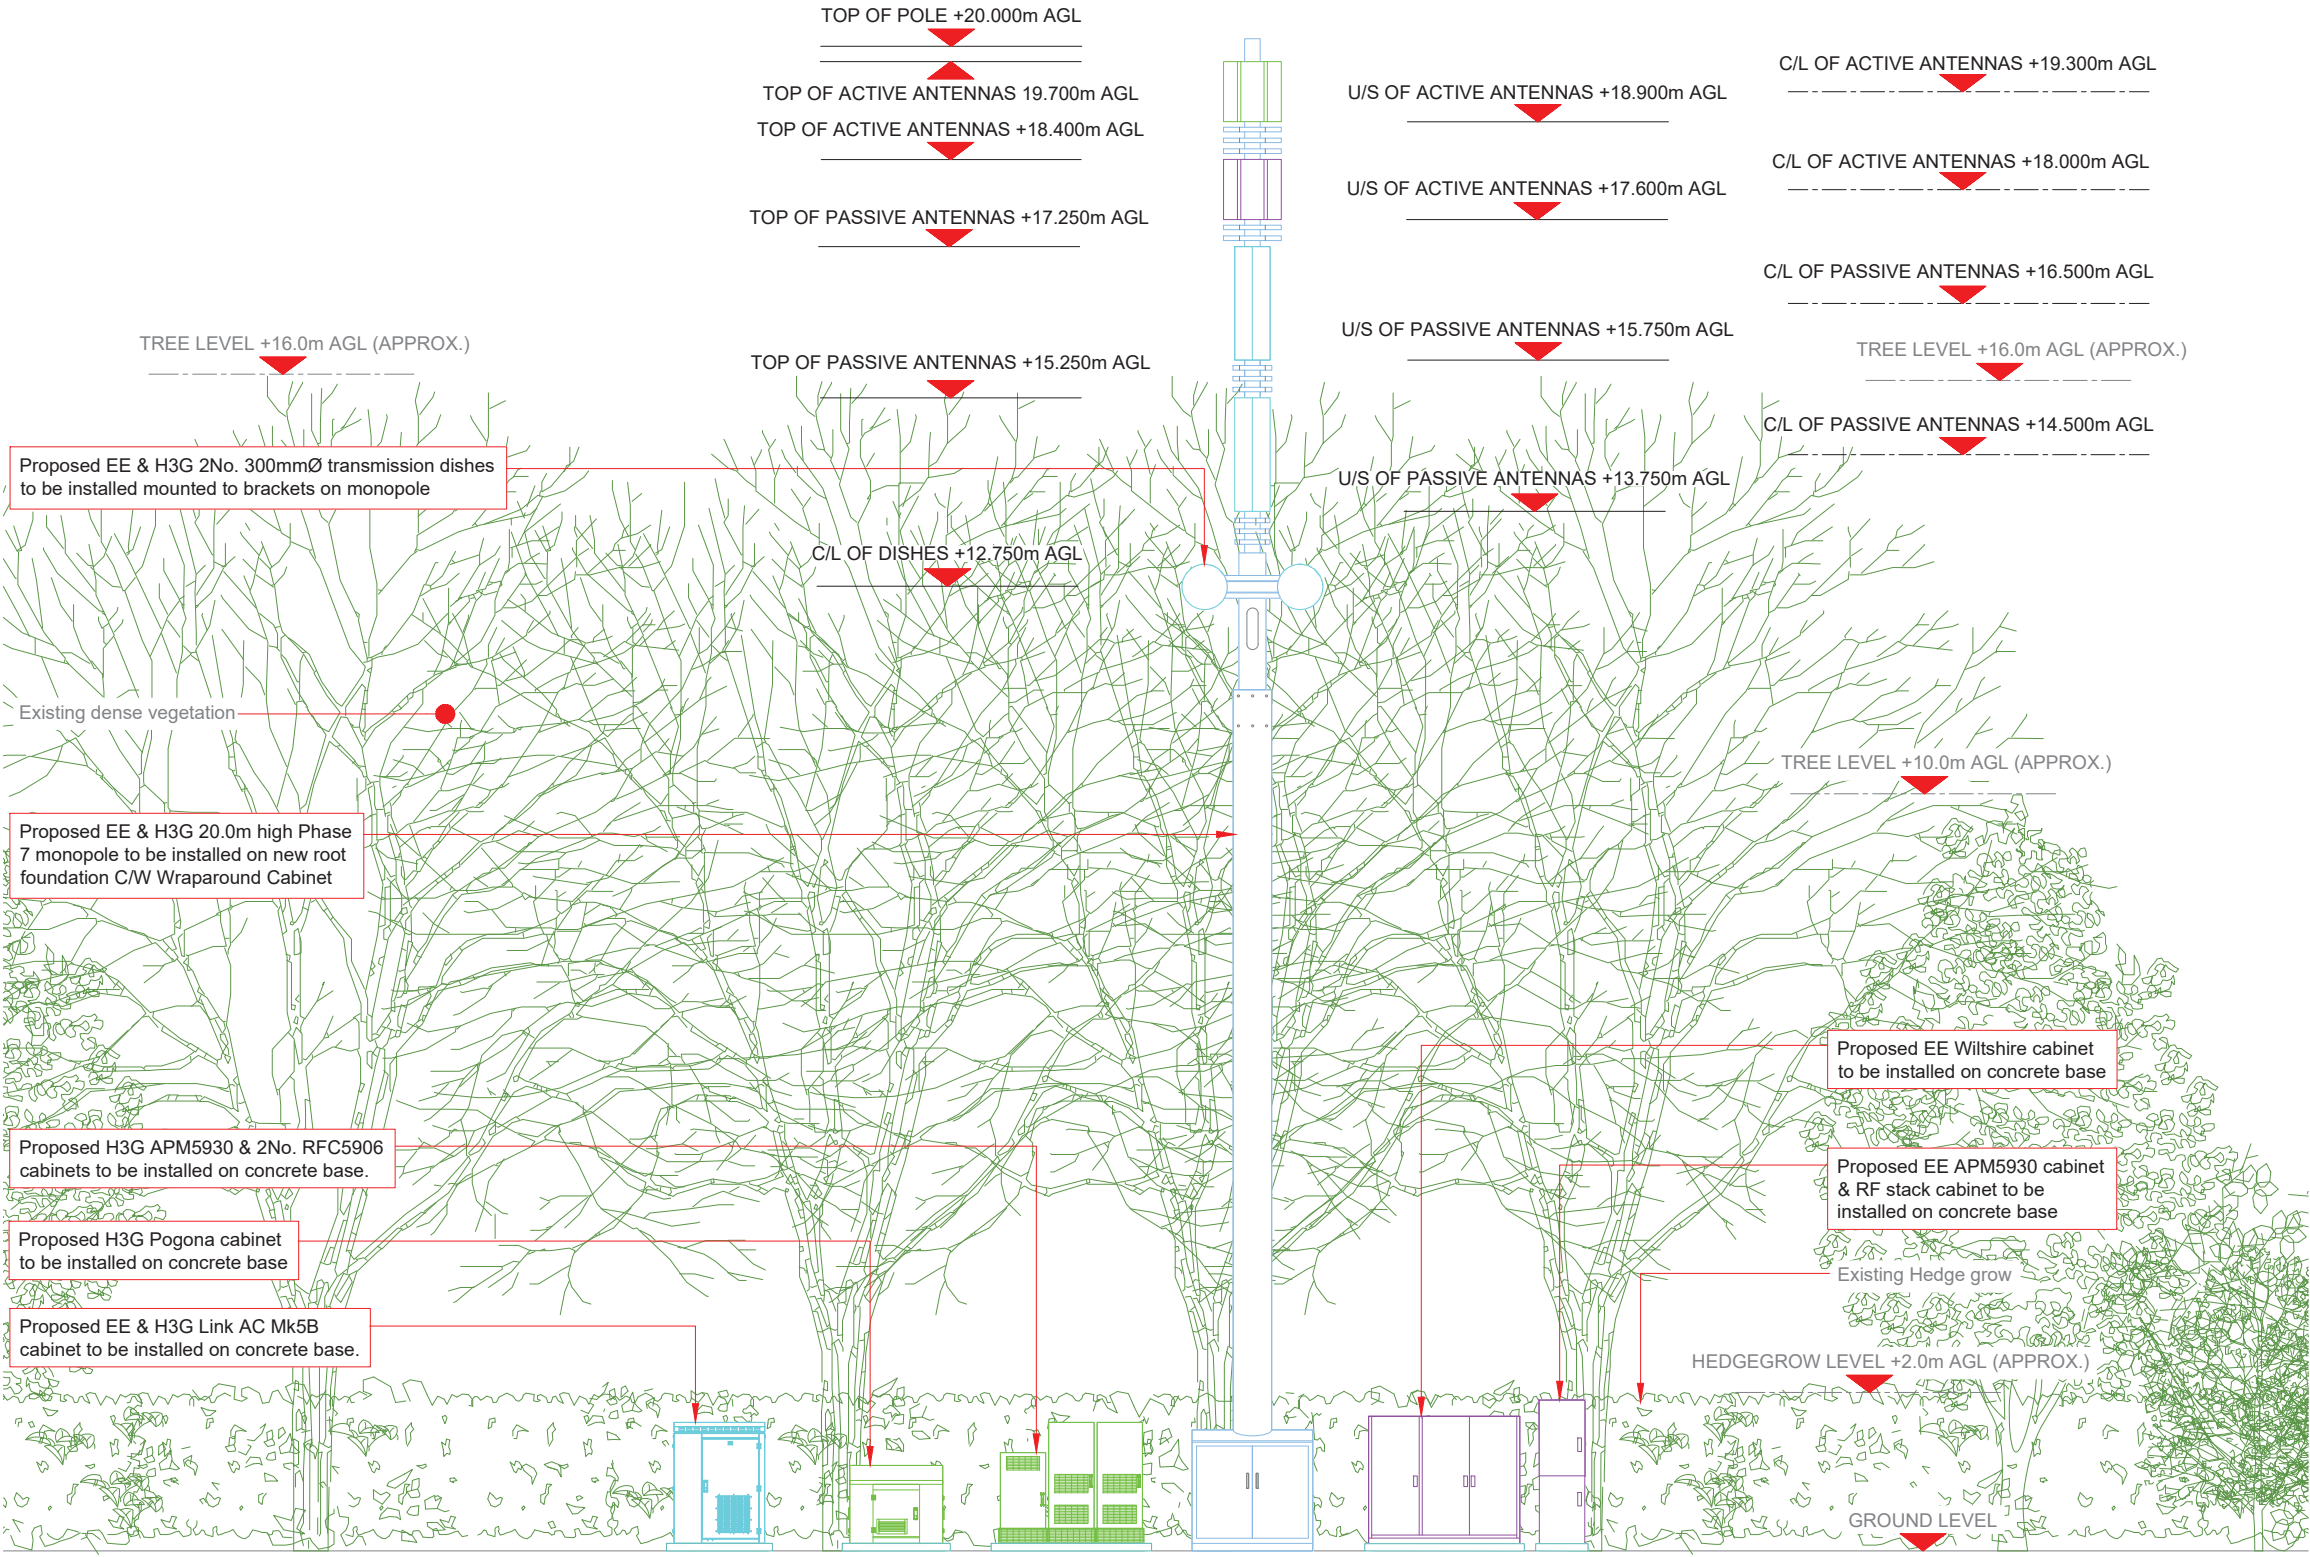

MAX CONFIGURATION ELEVATION

 

Antenna Aperture ID	Proposed 4G/5G Bearing	Operator: Shared/ EE/H3G
A1	30°	EE
A2	30°	H3G
A3	30°	H3G/EE
A4	30°	H3G/EE
B1	150°	EE
B2	150°	H3G
B3	150°	H3G/EE
B4	150°	H3G/EE
C1	270°	EE
C2	270°	H3G
C3	270°	H3G/EE
C4	270°	H3G/EE

NOTES:
1. ALL DIMENSIONS IN MM UNLESS OTHERWISE NOTED.

Master:	MBNL / EE / H3G:	Project:	Purpose of Issue:	Issue:
M001	MBNL	NTQ	GA	A
Date:	22/05/2020	Revision / Upgrade Description:		
Drawn:	SKA	First Issue - Site nomination dated: 20-09-19		
Checked:	ABB			
Approved:	F Dejene			



Hutchison 3G UK Limited
Star House, 20 Grenfell Road
Maidenhead, SL6 1EH
Tel: 01628 765 000
Fax: 01628 765 001



Hatfield Business Park
Hatfield
Hertfordshire
AL10 9BW
Tel: 01707 315000
Fax: 01707 319001



Mobile Broadband Network Limited
Sixth Floor, Thames Tower, Station Road, Reading, RG1 1LX

Design Consultant & Principal Contractor:



WALDON TELECOM
PHOENIX HOUSE
PYRFORD ROAD
WEST BYFLEET
SURREY
KT14 6RA

TEL : 01932 411011
FAX : 01932 411012

Site Name:
COWLEY BUSINESS PARK

Site ID:
1549968

Address:
COWLEY BUSINESS PARK
UXBRIDGE
LONDON
UB8 2AD

Title:
265 MAX CONFIGURATION ELEVATION

Project:
NTQ

Purpose of Issue:
GENERAL ARRANGEMENT

EE Cell ID: 77573	MBNL Cell ID: HGN247	3UK Cell ID: UB0281
----------------------	-------------------------	------------------------

Master Drawing No: 1549968_HGN247_77573_UB0281_M001	Issue: A
--	-------------

Passive Infrastructure Equipment Capacity & Lead Operator			
A	B	C	LEAD
HS2	HS2	HS2	TBC