
 


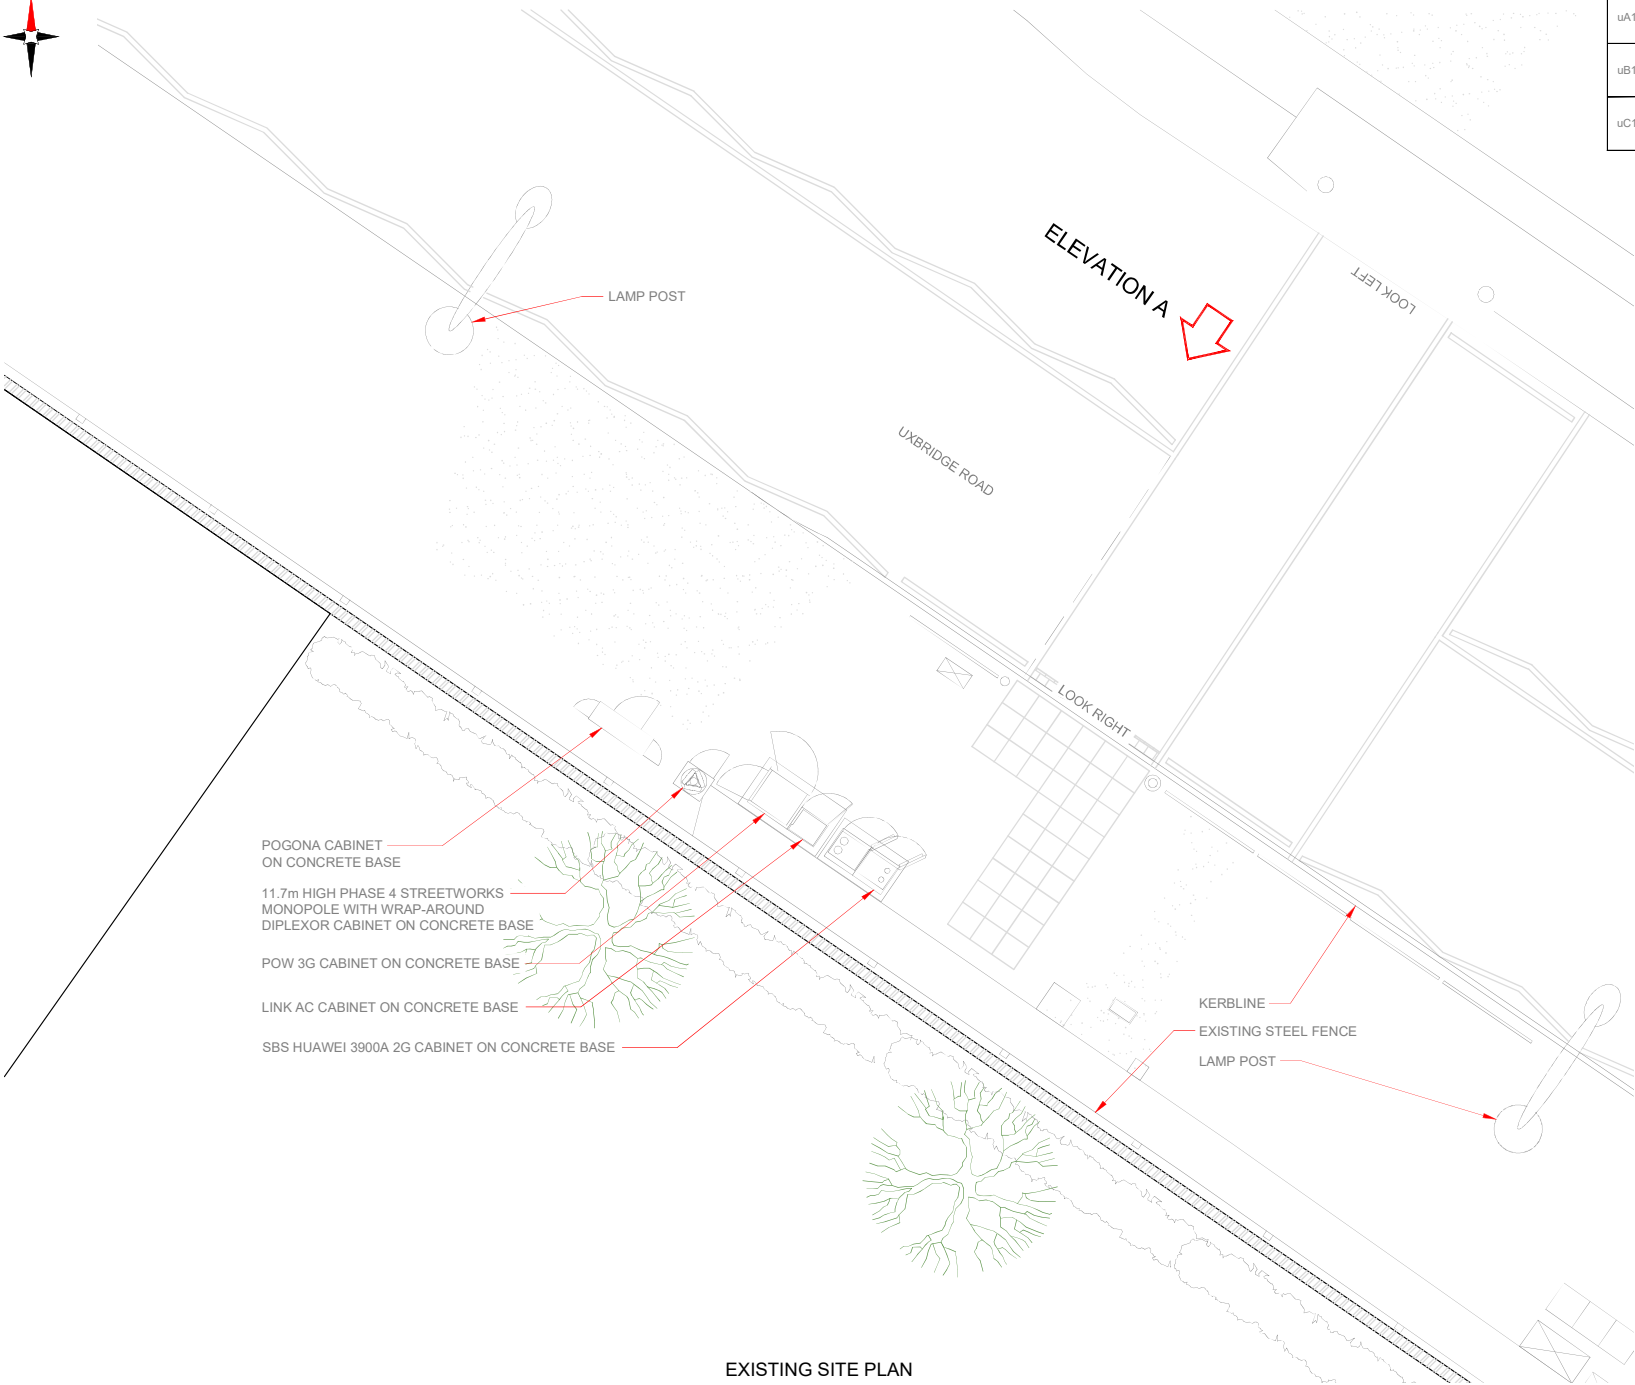

EXISTING SITE PLAN



3G Antenna ID	Existing 3G Bearing
uA1	70°
uB1	190°
uC1	310°

NOTES:

1. ALL DIMENSIONS IN MM UNLESS OTHERWISE NOTED.

Master:	MBNL / EE / H3G:	Project:	Purpose of Issue:	Issue:
M001	MBNL	T&A	Planning	A
Date:	30/05/2019	Revision / Upgrade Description:		
Drawn:	S. Mohan	First Issue		
Checked:	T. Clifford	ACQ		
Approved:	M. Venner			

ACQ



Hutchison 3G UK Limited
Star House, 25 Garsfield Road
Maidenhead, SL6 6TH
Tel: 01628 765 000
Fax: 01628 765 001



Hatfield Business Park
Hatfield
Hertfordshire
AL10 9BW
Tel: 01707 315000
Fax: 01707 319001



Mobile Broadband Network Limited
Sixth Floor, Thames Tower, Station Road, Reading, RG1 1LX




BEACONCOMMS

UNIT E3 FITTS CLEAVE INDUSTRIAL ESTATE, TAVISTOCK, DEVON, PL19 0PW
sales@beaconcomms.co.uk Tel: +44 (0)1822 610610

Site Name:	WESTBORNE ROAD DNS		
Site ID:	980575		
Address:	UXBRIDGE ROAD HILLINGDON HEATH UXBRIDGE LONDON UB10 0PD		
Title:	100 EXISTING SITE PLAN		
Project:	T & A		
Purpose of Issue:	GENERAL ARRANGEMENT		
EE Cell ID:	MBNL Cell ID:	3UK Cell ID:	
50682	HGN008	UB0149	
Master Drawing No:			Issue:
980575_HGN008_50682_UB0149_M001			A



NOTES:			
1. ALL DIMENSIONS IN MM UNLESS OTHERWISE NOTED.			
Master: MBNL / E3 / F432G M001 MBNL		Project: T&A Revision: / Upgrade Description: First Issue	
Date: 30/05/2019 Drawn: S. Mohan Checked: T. Clifford Approved: M. Venner		Purpose of Issue: Planning ACQ	
 Hutchison 3G UK Limited Six Hoxa, 20 Greatford Road Macclesfield, SK11 1SR T: +44 (0)1628 785 000 F: +44 (0)1628 785 001 #3G Everywhere Information Line 0845 6043000 Available 8am-8pm Monday to Friday		 Hatfield Business Park Hatfield Hertfordshire AL10 9BW Tel: 01707 315000 Fax: 01707 319001	
 BEACONCOMMS UNIT E3 PITTS CLEAVE INDUSTRIAL ESTATE, TAVISTOCK, DEVON, PL19 0PW sales@beaconcomms.co.uk			
Site Name: WESTBORNE ROAD DNS			
Site ID: 980575			
Address: UXBRIDGE ROAD HILLINGDON HEATH UXBRIDGE LONDON UB10 0PD			
Title: 150 EXISTING ELEVATION A			
Project: T & A			
Purpose of Issue: GENERAL ARRANGEMENT			
EE Cell ID: 50682		MBNL Cell ID: HGN008	
Master Drawing No: 980575 HGN008 50682 UB0149 M001		SUK Cell ID: UB0149	
		Issue: A	

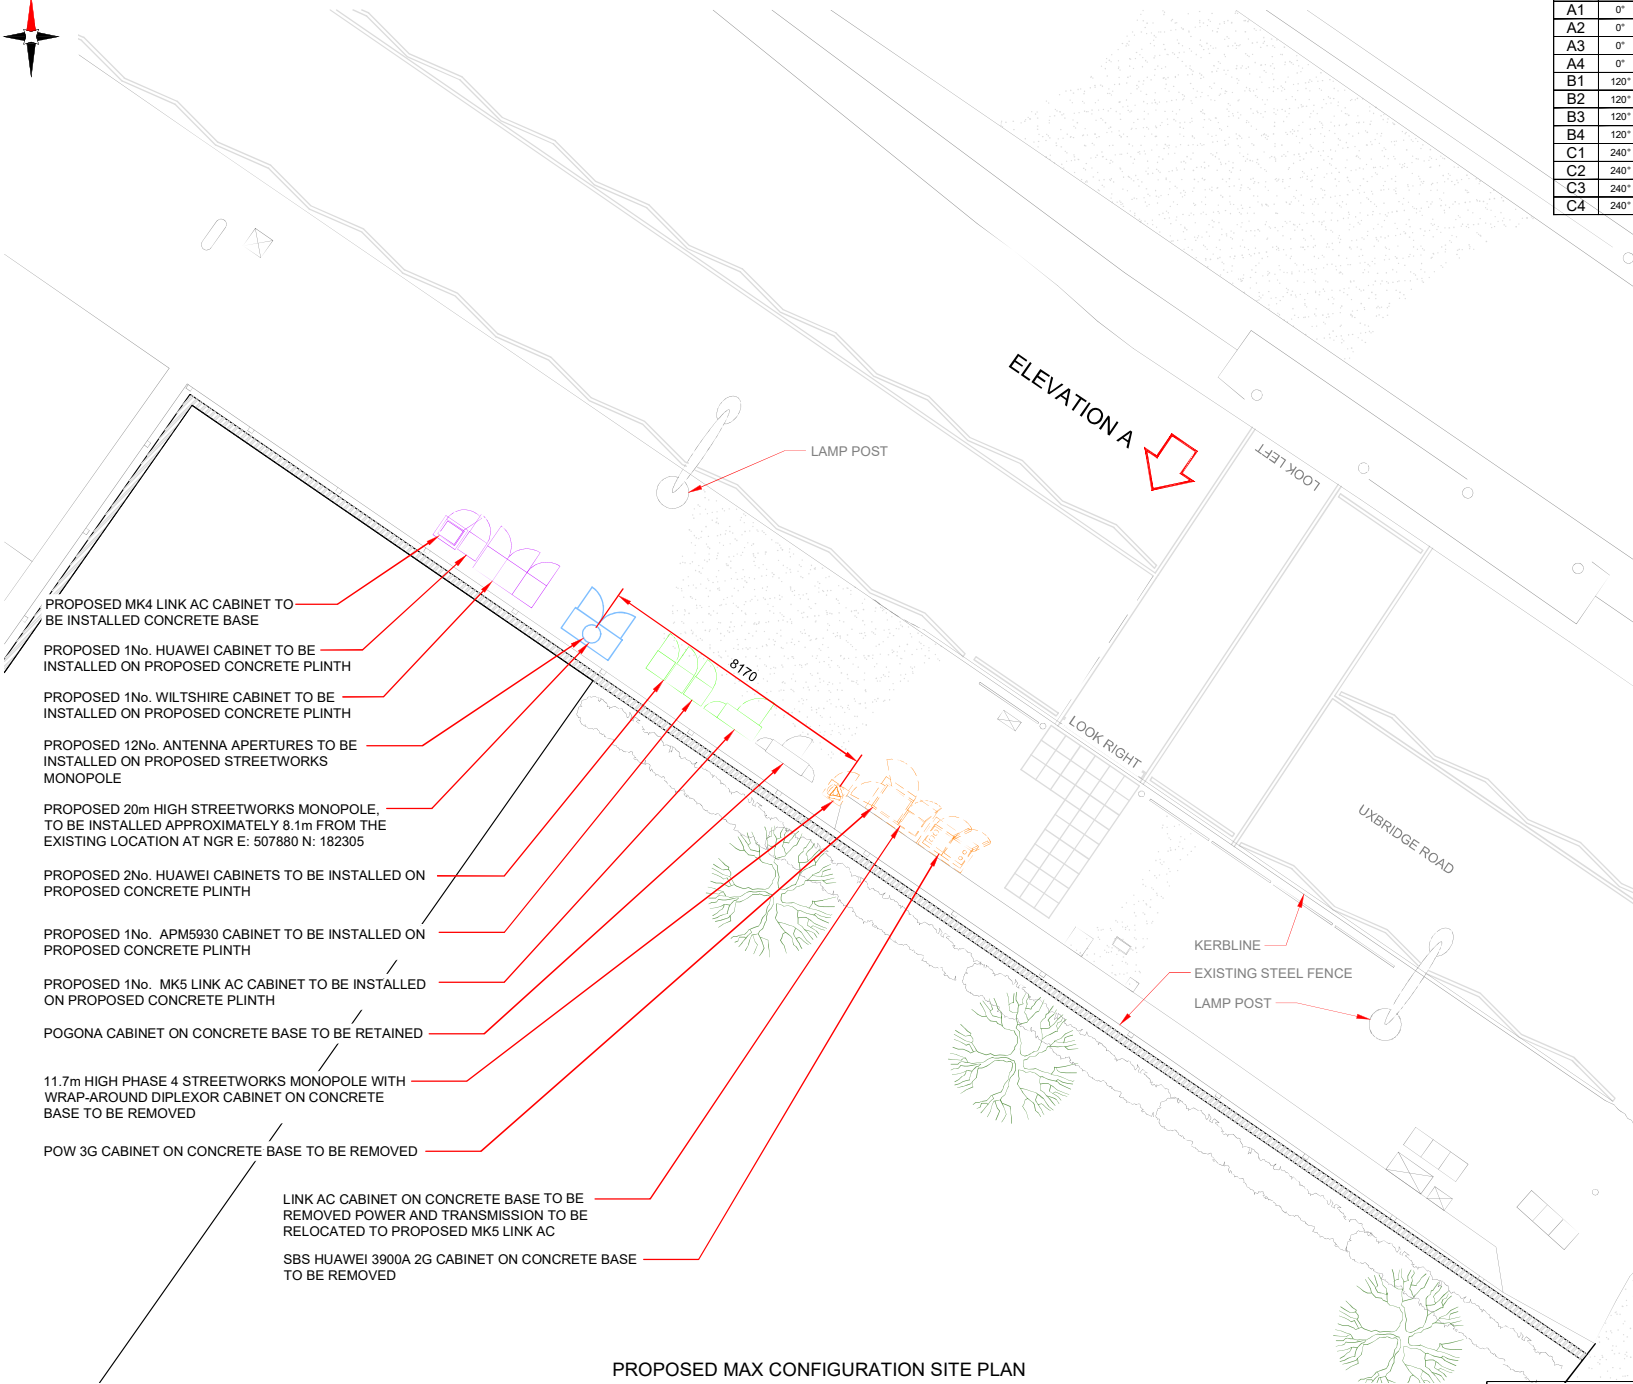

- PROPOSED MK4 LINK AC CABINET TO BE INSTALLED ON PROPOSED CONCRETE BASE
- PROPOSED 1No. HUAWEI CABINET TO BE INSTALLED ON PROPOSED CONCRETE PLINTH
- PROPOSED 1No. WILTSHIRE CABINET TO BE INSTALLED ON PROPOSED CONCRETE PLINTH
- PROPOSED 12No. ANTENNA APERTURES TO BE INSTALLED ON PROPOSED STREETWORKS MONOPOLE
- PROPOSED 20m HIGH STREETWORKS MONOPOLE, TO BE INSTALLED APPROXIMATELY 8.1m FROM THE EXISTING LOCATION AT NGR E: 507880 N: 182305
- PROPOSED 2No. HUAWEI CABINETS TO BE INSTALLED ON PROPOSED CONCRETE PLINTH
- PROPOSED 1No. APM5930 CABINET TO BE INSTALLED ON PROPOSED CONCRETE PLINTH
- PROPOSED 1No. MK5 LINK AC CABINET TO BE INSTALLED ON PROPOSED CONCRETE PLINTH
- POGONA CABINET ON CONCRETE BASE TO BE RETAINED
- 11.7m HIGH PHASE 4 STREETWORKS MONOPOLE WITH WRAP-AROUND DIPLEXOR CABINET ON CONCRETE BASE TO BE REMOVED
- POW 3G CABINET ON CONCRETE BASE TO BE REMOVED
- LINK AC CABINET ON CONCRETE BASE TO BE REMOVED POWER AND TRANSMISSION TO BE RELOCATED TO PROPOSED MK5 LINK AC
- SBS HUAWEI 3900A 2G CABINET ON CONCRETE BASE TO BE REMOVED

PROPOSED MAX CONFIGURATION SITE PLAN



Antenna Aperture ID	Proposed 4G/5G Bearing	Operator Shared/ EE/H3G
A1	0°	EE
A2	0°	H3G
A3	0°	EE/H3G
A4	0°	EE/H3G
B1	120°	EE
B2	120°	H3G
B3	120°	EE/H3G
B4	120°	EE/H3G
C1	240°	EE
C2	240°	H3G
C3	240°	EE/H3G
C4	240°	EE/H3G

NOTES:
1. ALL DIMENSIONS IN MM UNLESS OTHERWISE NOTED.

Master: M001
Date: 30/05/2019
Drawn: S. Mohan
Checked: T. Clifford
Approved: M. Vemmer

MBNL
Revision / Upgrade Description:
First Issue

Project: T&A
Purpose of Issue: Planning
Issue: A

ACQ

Hutchison 3G UK Limited
Star House, 25 Garsfield Road
Maidenhead, SL6 8XH
Tel: 01628 700 000
Fax: 01628 700 001
H3G Base Station Information line
045 6043001
Available from 9pm Monday to Friday

Hartfield Business Park
Hartfield
Hertfordshire
AL10 9BW
Tel: 01707 315000
Fax: 01707 319001


Mobile Broadband Network Limited
Sixth Floor, Thames Tower, Station Road, Reading, RG1 1LX

BEACONCOMMS
UNIT E3 FITTS CLEAVE INDUSTRIAL ESTATE, TAVISTOCK, DEVON, PL19 0PW
sales@beaconcomms.co.uk Tel: +44 (0)1822 610610

Site Name:	WESTBORNE ROAD DNS		
Site ID:	980575		
Address:	UXBRIDGE ROAD HILLINGDON HEATH UXBRIDGE LONDON UB10 0PD		
Title:	215 MAX CONFIGURATION SITE PLAN		
Project:	T & A		
Purpose of Issue:	GENERAL ARRANGEMENT		
EE Cell ID:	50682	MBNL Cell ID:	HGN008
3UK Cell ID:	UB0149		Issue:
Master Drawing No: 980575_HGN008_50682_UB0149_M001			A

SITE CAPACITY BY SECTOR		
A	B	C
HS2	HS2	HS2

100mm
150mm
100mm

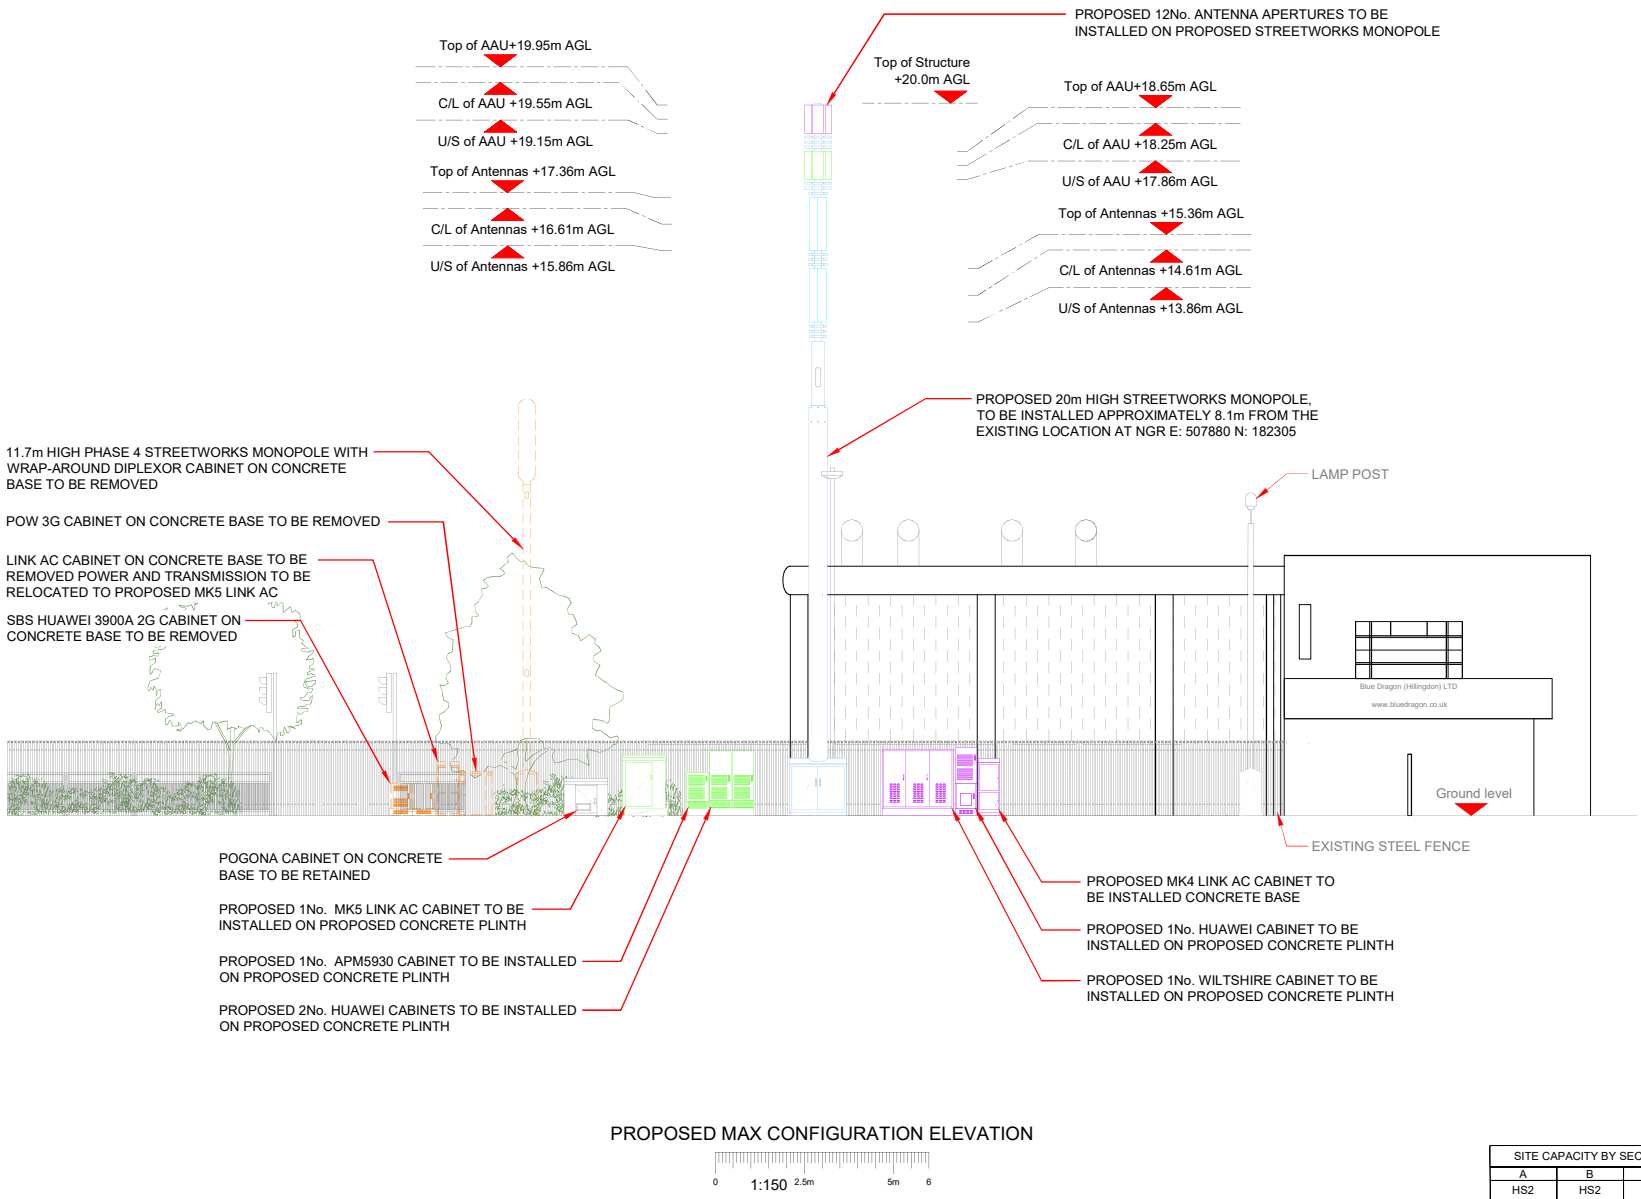

Antenna Aperture ID	Proposed 4G/5G Bearing	Operator Shared/ EE/H3G
A1	0°	EE
A2	0°	H3G
A3	0°	EE/H3G
A4	0°	EE/H3G
B1	120°	EE
B2	120°	H3G
B3	120°	EE/H3G
B4	120°	EE/H3G
C1	240°	EE
C2	240°	H3G
C3	240°	EE/H3G
C4	240°	EE/H3G

NOTES:

1. ALL DIMENSIONS IN MM UNLESS OTHERWISE NOTED.

Master:	MBNL / EE / H3G	Project:	T&A	Purpose of Issue:	Planning	Issue:	A
M001	MBNL	Revision / Upgrade Description:	First Issue	ACQ			
Date:	30/05/2019	Drawn:	S. Mohan				
Checked:	T. Clifford	Approved:	M. Venner				

Hutchison 3G UK Limited
Star House, 25 Garsfield Road
Maidenhead, SL6 1EH
Tel: 01628 785000
Fax: 01628 785001
H3G Base Station Information line: 0845 6043001
Available from 9pm Monday to Friday

Hatfield Business Park
Hatfield
Hertfordshire
AL10 9BW
Tel: 01707 315000
Fax: 01707 319001

MBNL Mobile Broadband Network Limited
Sixth Floor, Thames Tower, Station Road, Reading, RG1 1LX

BEACONCOMMS
UNIT E3 FITTS CLEAVE INDUSTRIAL ESTATE, TAVISTOCK, DEVON, PL19 0PW
sales@beaconcomms.co.uk Tel: +44 (0)1822 610610

Site Name: WESTBORNE ROAD DNS

Site ID: 980575

Address: UXBRIDGE ROAD
HILLINGDON HEATH
UXBRIDGE
LONDON
UB10 0PD

Title: 265 MAX CONFIGURATION ELEVATION

Project: T & A

Purpose of Issue: GENERAL ARRANGEMENT

EE Cell ID:	50682	MBNL Cell ID:	HGN008	3UK Cell ID:	UB0149
-------------	-------	---------------	--------	--------------	--------

Master Drawing No: 980575_HGN008_50682_UB0149_M001

Issue: A

SITE CAPACITY BY SECTOR		
A	B	C
HS2	HS2	HS2