


YTHROP DRIVE

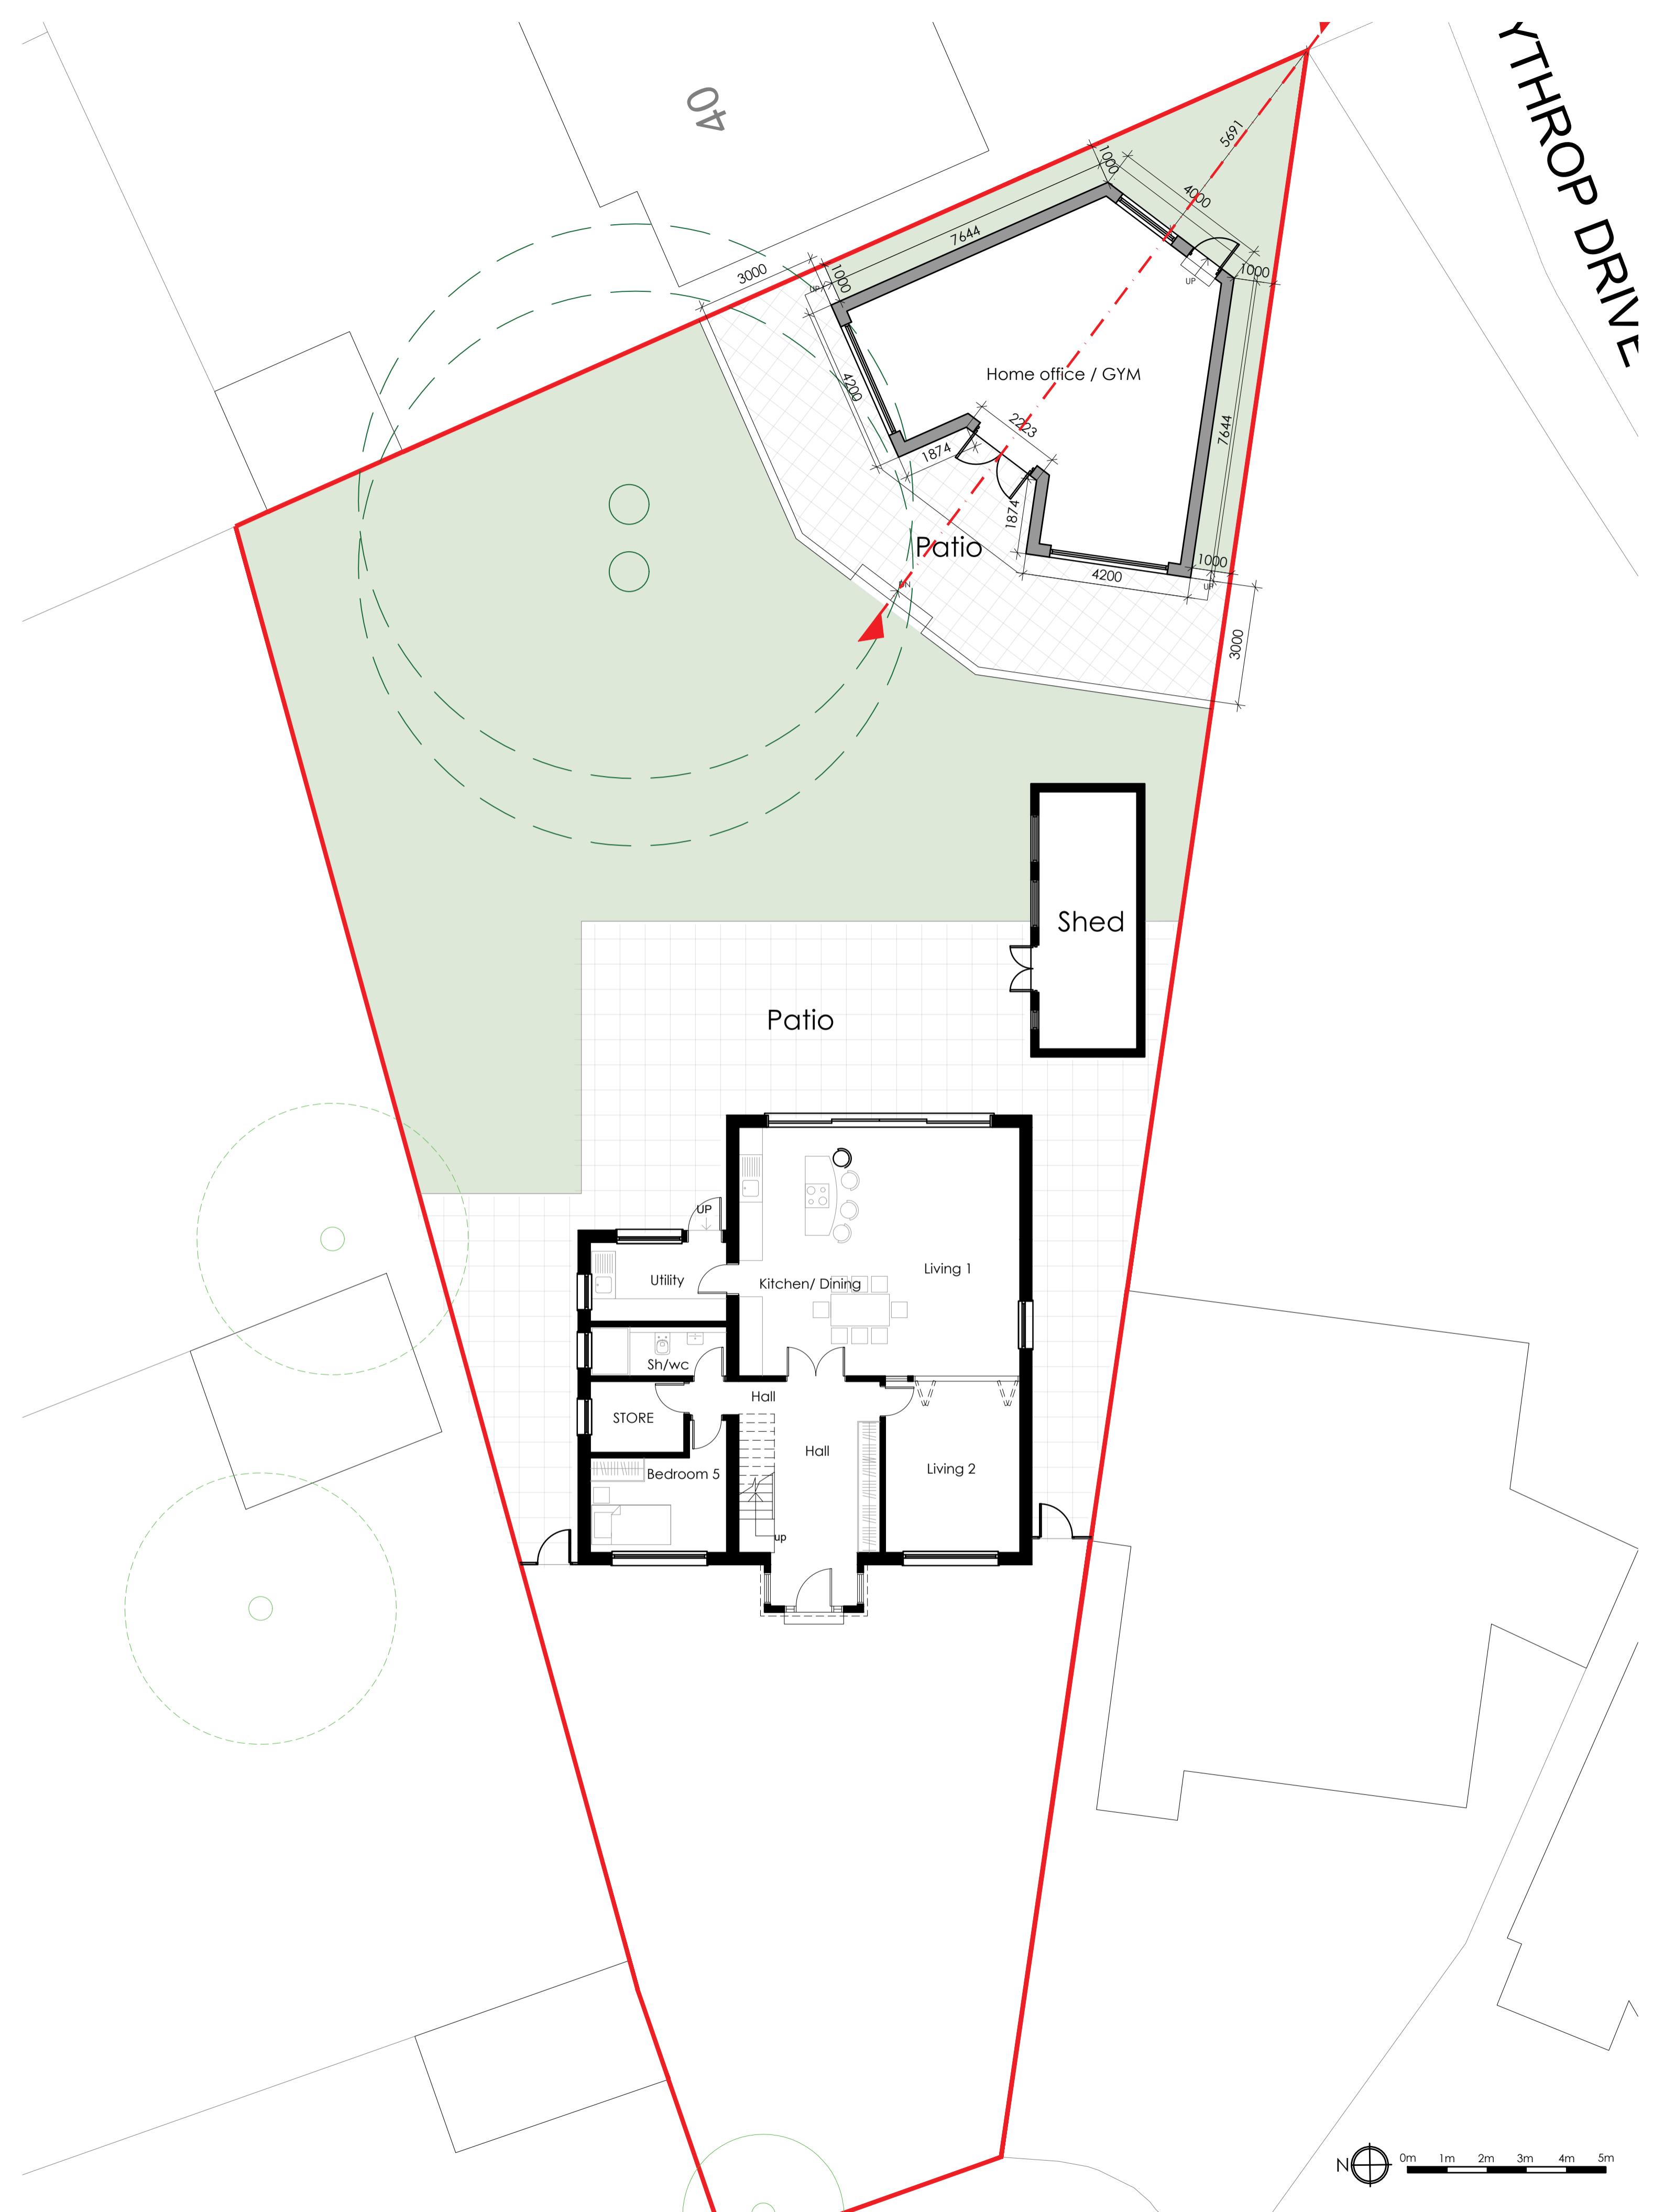

PROJECT	DWG NO.	SCALE	DETAIL	28.11.2022	21.02.2023	18.07.2023					PROJECT NO.	P R Architecture Ltd.
1 WINDRUSH CLOSE, ICKENHAM UB10 8EJ	02	1:100 @ A2	SITE PLAN	ISSUED FOR DISCUSSION	SUBMITTED FOR PLANNING	SENT TO PLANNING OFFICER					20.10	Chartered Architect
PLANNING												120, Pinner Road, Harrow, HA1 4JD. Tel: 0208 357 2304