 


SITE LOCATION




Reproduced by permission of Ordnance Survey on behalf of the Controller of Her Majesty's Stationary Office
All rights reserved. © Crown Copyright licence no. 100022432

SITE AREA PLAN




SITE PHOTOGRAPH

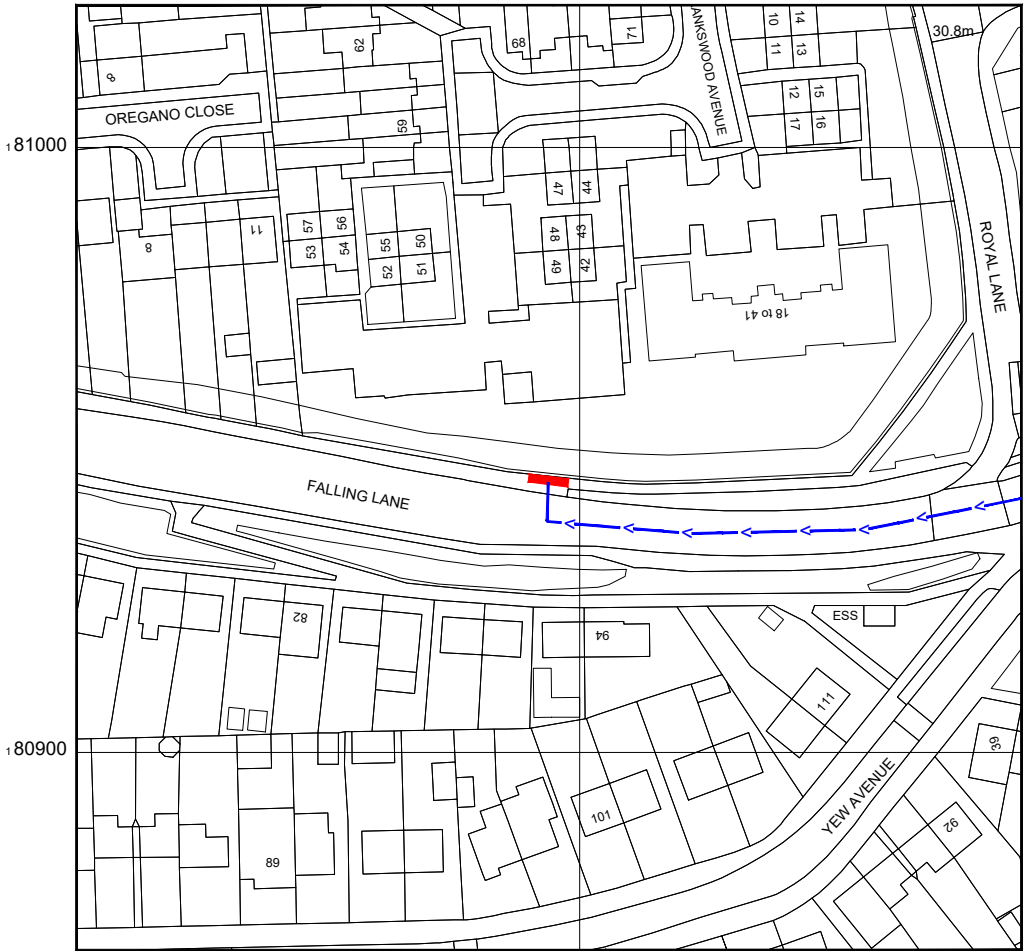

Reproduced by permission of Ordnance Survey on behalf of the Controller of Her Majesty's Stationary Office
All rights reserved. © Crown Copyright licence no. 100062043

NGR E: 506602 N: 180946

 SITE LOCATION PLAN



GOOGLE MAPS QR CODE

GOOGLE MAPS - <https://goo.gl/maps/xYEC7CKqbHzJPt6s7>

GOOGLE STREETVIEW - <https://goo.gl/maps/WZsjFvtyP6SjKbPe9>

NOTES:

1. ALL DIMENSIONS IN MM UNLESS OTHERWISE NOTED.

DIRECTIONS TO SITE:

Follow A4 to M4
Follow M4 to Stockley Rd. Take exit 4 from M4
At the roundabout, take the 2nd exit onto Stockley Rd
At the roundabout, take the 1st exit onto Stockley Rd/A408
At the roundabout, take the 1st exit and stay on Stockley Rd/A408. Go through 2 roundabouts
Site location is on the right hand side.
Falling Ln, Yiewsley, West Drayton, Hillingdon, UB7 8PD

Site Provider's
Property Boundary:



Access Route To Site:



Access Route:



Master:	MBNL / EE / H3G:	Project:	Purpose of Issue:	Issue:
M001	MBNL	H3G 5G UNILATERAL	Planning	A
Date:	12/08/2020	Revision / Upgrade Description:	First Issue - Site nomination dated: TBC	
Drawn:	CDN	Checked:	DH	
Approved:	SD			



Hutchison 3G UK Limited
Star House, 20 Grenfell Road
Maidenhead, SL6 1EH
Tel: 01628 765 000
Fax: 01628 765 001

H3G Base Station Information line:
0845 6043000
Available 8am-8pm Monday to Friday


Design Consultant & Principal Contractor:



WHP Telecoms
Unit 1 Maple Park,
Low Fields Avenue, Leeds
LS12 6HH

Tel: 01133023550
e-mail: info@whptelecoms.com

Site Name:	FALLING LANE		
Site ID:	HGN12097		
Address:	FALLING LANE YIEWSLEY LONDON BOROUGH OF HILLINGDON, LONDON, GREATER LONDON ENGLAND UB7 8PD		
Title:	002 SITE LOCATION PLAN		
Project:	H3G 5G UNILATERAL		
Purpose of Issue:	PLANNING		
EE Cell ID:	N/A	MBNL Cell ID:	N/A
3UK Cell ID:	N/A		
Master Drawing No:	HGN12097_M001		Issue:
			A

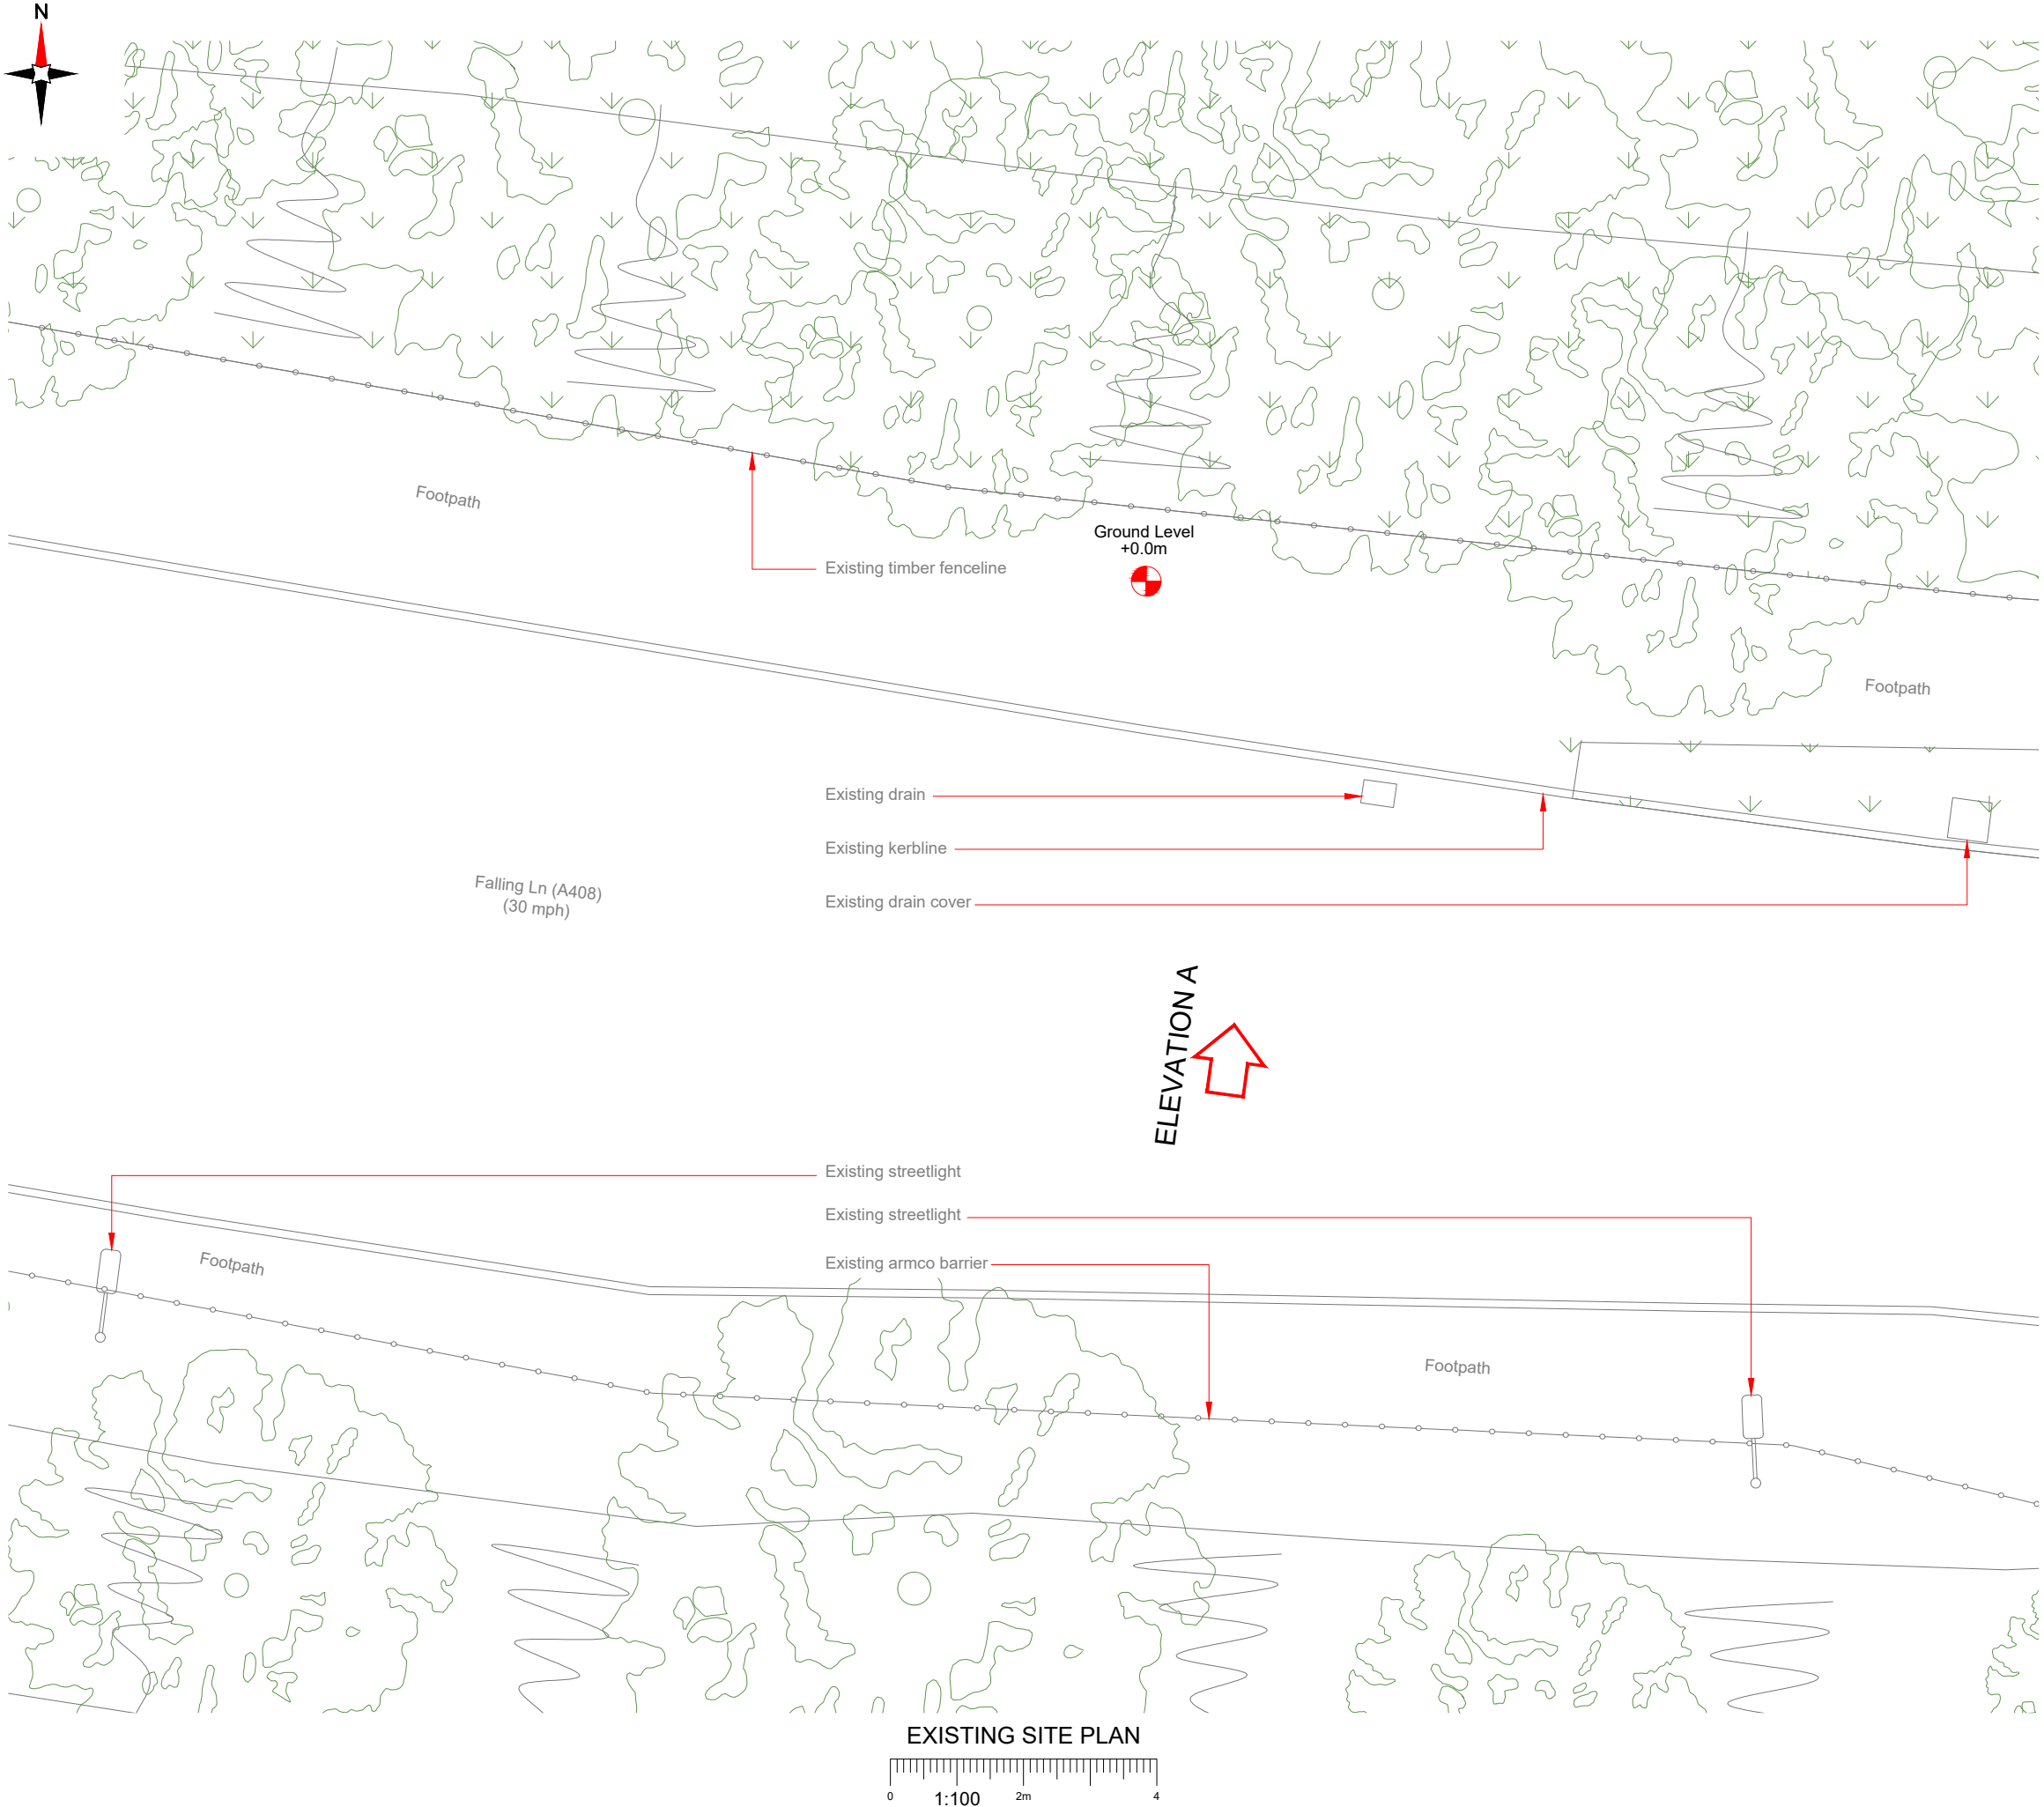

NOTES:

- ALL DIMENSIONS IN MM UNLESS OTHERWISE NOTED.

Master:	MBNL / EE / H3G:	Project:	Purpose of Issue:	Issue:
M001	MBNL	H3G 5G UNILATERAL	Planning	A
Date:	12/08/2020	Revision / Upgrade Description:		
Drawn:	CDN	First Issue - Site nomination dated: TBC		
Checked:	DH			
Approved:	SD			



Hutchison 3G UK Limited
Star House, 20 Grenfell Road
Maidenhead, SL6 1EH
Tel: 01628 765 000
Fax: 01628 765 001

H3G Base Station Information line:
0845 6043000
Available 8am-8pm Monday to Friday

Design Consultant & Principal Contractor:



WHP Telecoms
Unit 1 Maple Park,
Low Fields Avenue, Leeds
LS12 6HH

Tel: 01133023550
e-mail: info@whptelecoms.com

Site Name:

FALLING LANE

Site ID:

HGN12097

Address:

FALLING LANE
YIEWSLEY
LONDON BOROUGH OF HILLINGDON,
LONDON, GREATER LONDON
ENGLAND
UB7 8PD

Title:

100 EXISTING SITE PLAN

Project:

H3G 5G UNILATERAL

Purpose of Issue:

PLANNING

EE Cell ID:	MBNL Cell ID:	3UK Cell ID:
N/A	N/A	N/A

Master Drawing No:

HGN12097_M001


Issue:

A


100mm

50mm

10mm

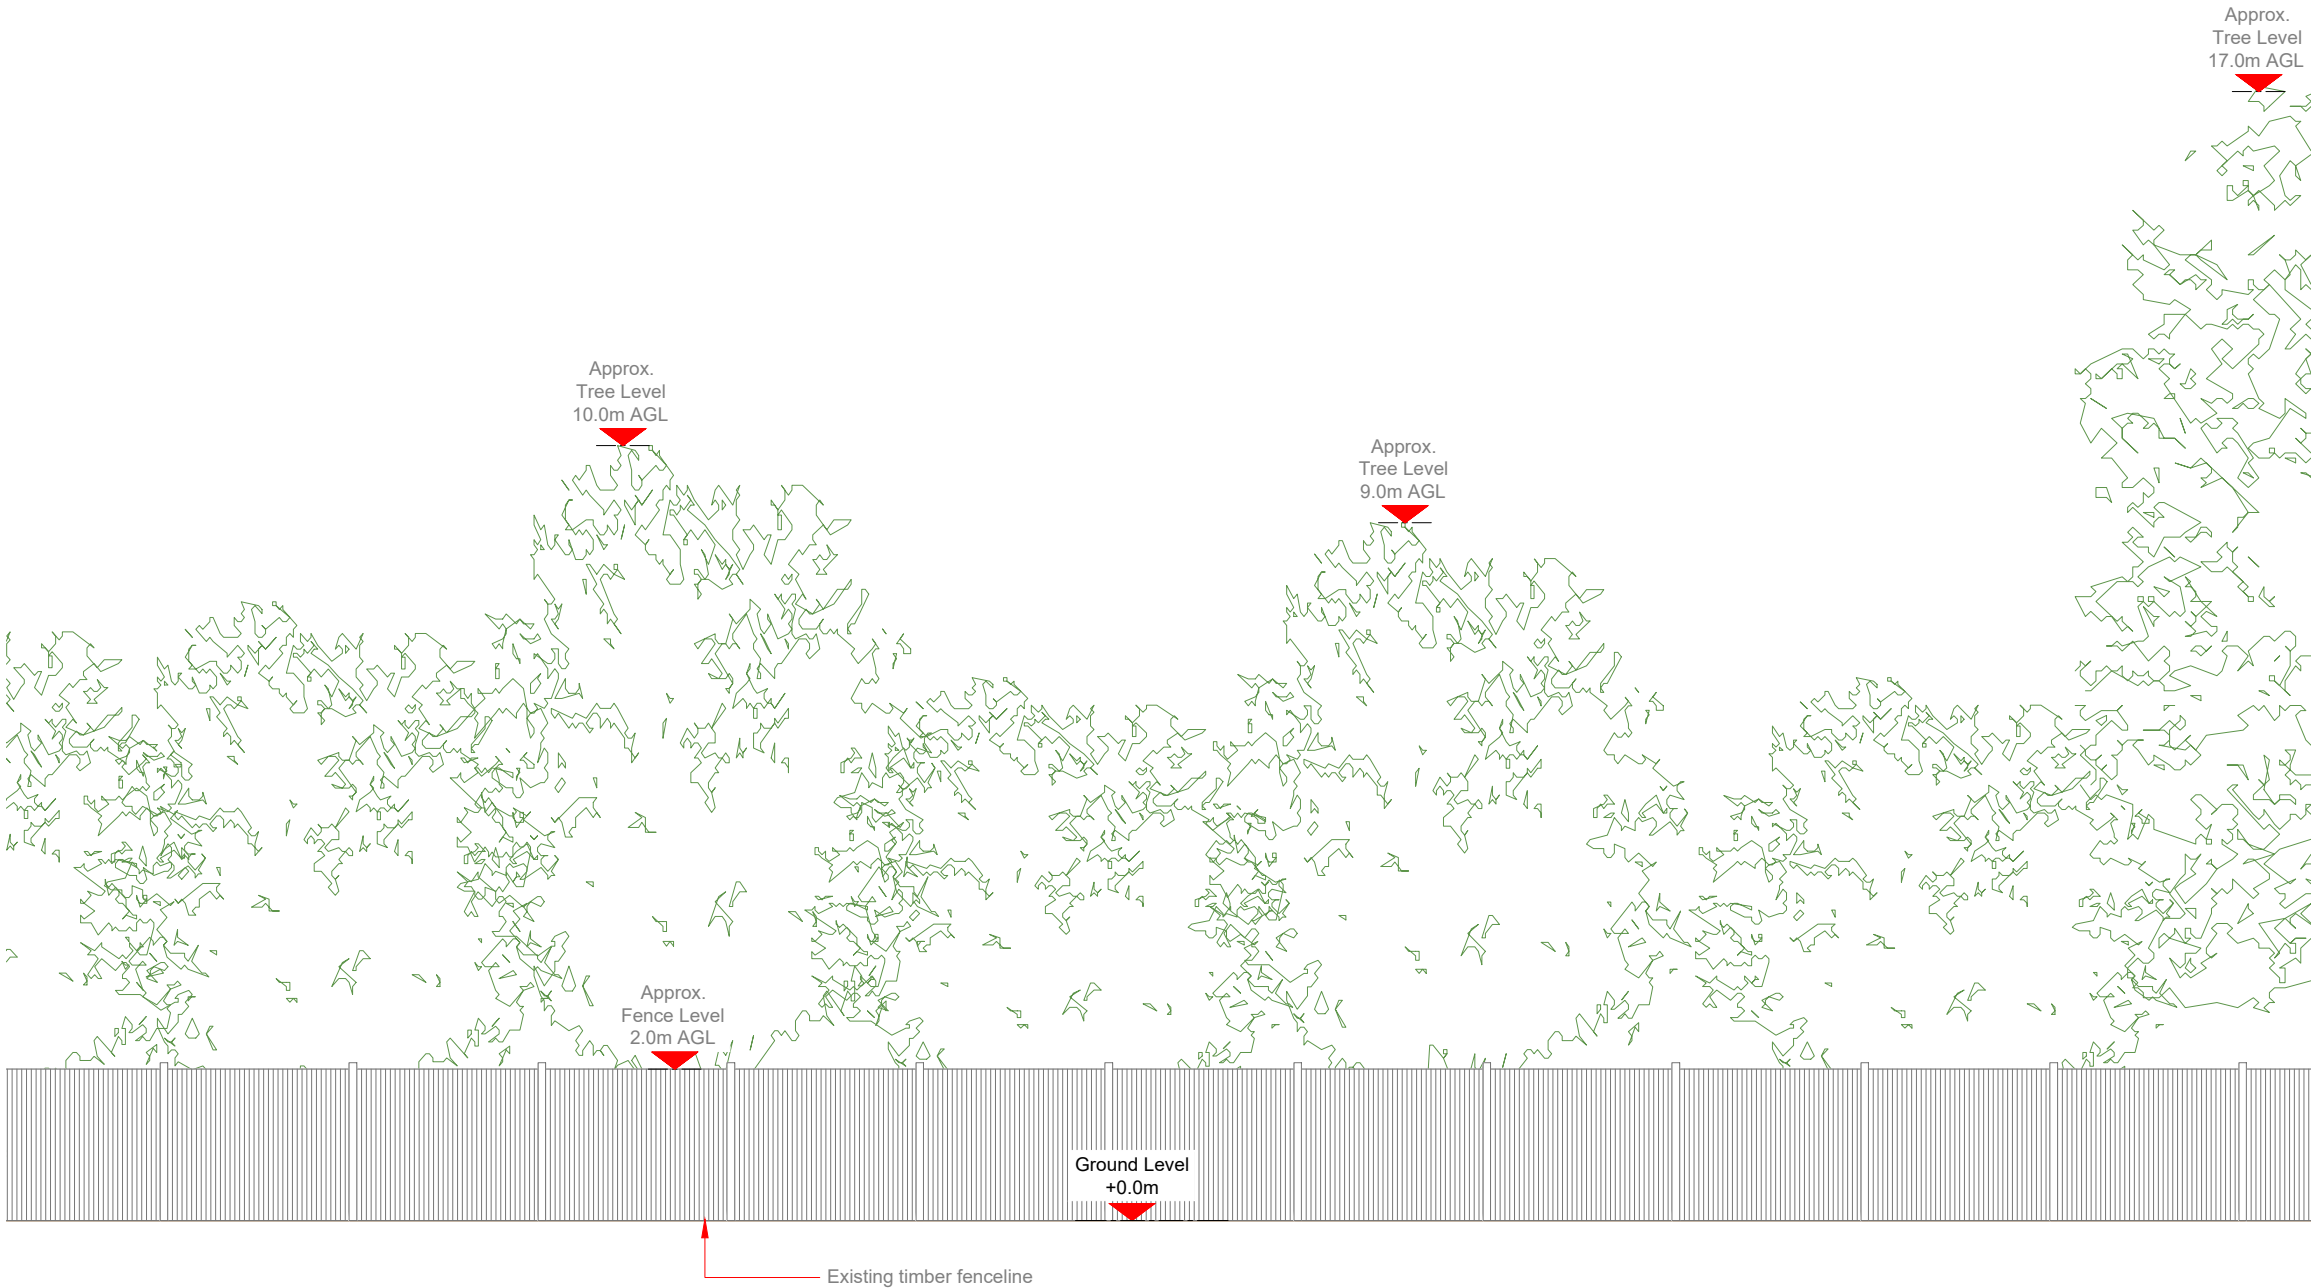

EXISTING ELEVATION A

 

NOTES:

1. ALL DIMENSIONS IN MM UNLESS OTHERWISE NOTED.

Master:	MBNL / EE / H3G:	Project:	Purpose of Issue:	Issue:
M001	MBNL	H3G 5G UNILATERAL	Planning	A
Date:	12/08/2020	Revision / Upgrade Description:		
Drawn:	CDN	First Issue - Site nomination dated: TBC		
Checked:	DH			
Approved:	SD			



Hutchison 3G UK Limited
Star House, 20 Grenfell Road
Maidenhead, SL6 1EH
Tel: 01628 765 000
Fax: 01628 765 001

H3G Base Station Information line:
0845 6043000
Available 8am-8pm Monday to Friday

Design Consultant & Principal Contractor:



WHP Telecoms
Unit 1 Maple Park,
Low Fields Avenue, Leeds
LS12 6HH

Tel: 01133023550
e-mail: info@whptelecoms.com

Site Name: FALLING LANE

Site ID: HGN12097

Address: FALLING LANE
YIEWSLEY
LONDON BOROUGH OF HILLINGDON,
LONDON, GREATER LONDON
ENGLAND
UB7 8PD


Title: 150 EXISTING ELEVATION A

Project: H3G 5G UNILATERAL


Purpose of Issue: PLANNING

EE Cell ID:	MBNL Cell ID:	3UK Cell ID:
N/A	N/A	N/A

Master Drawing No:	Issue:
HGN12097_M001	A

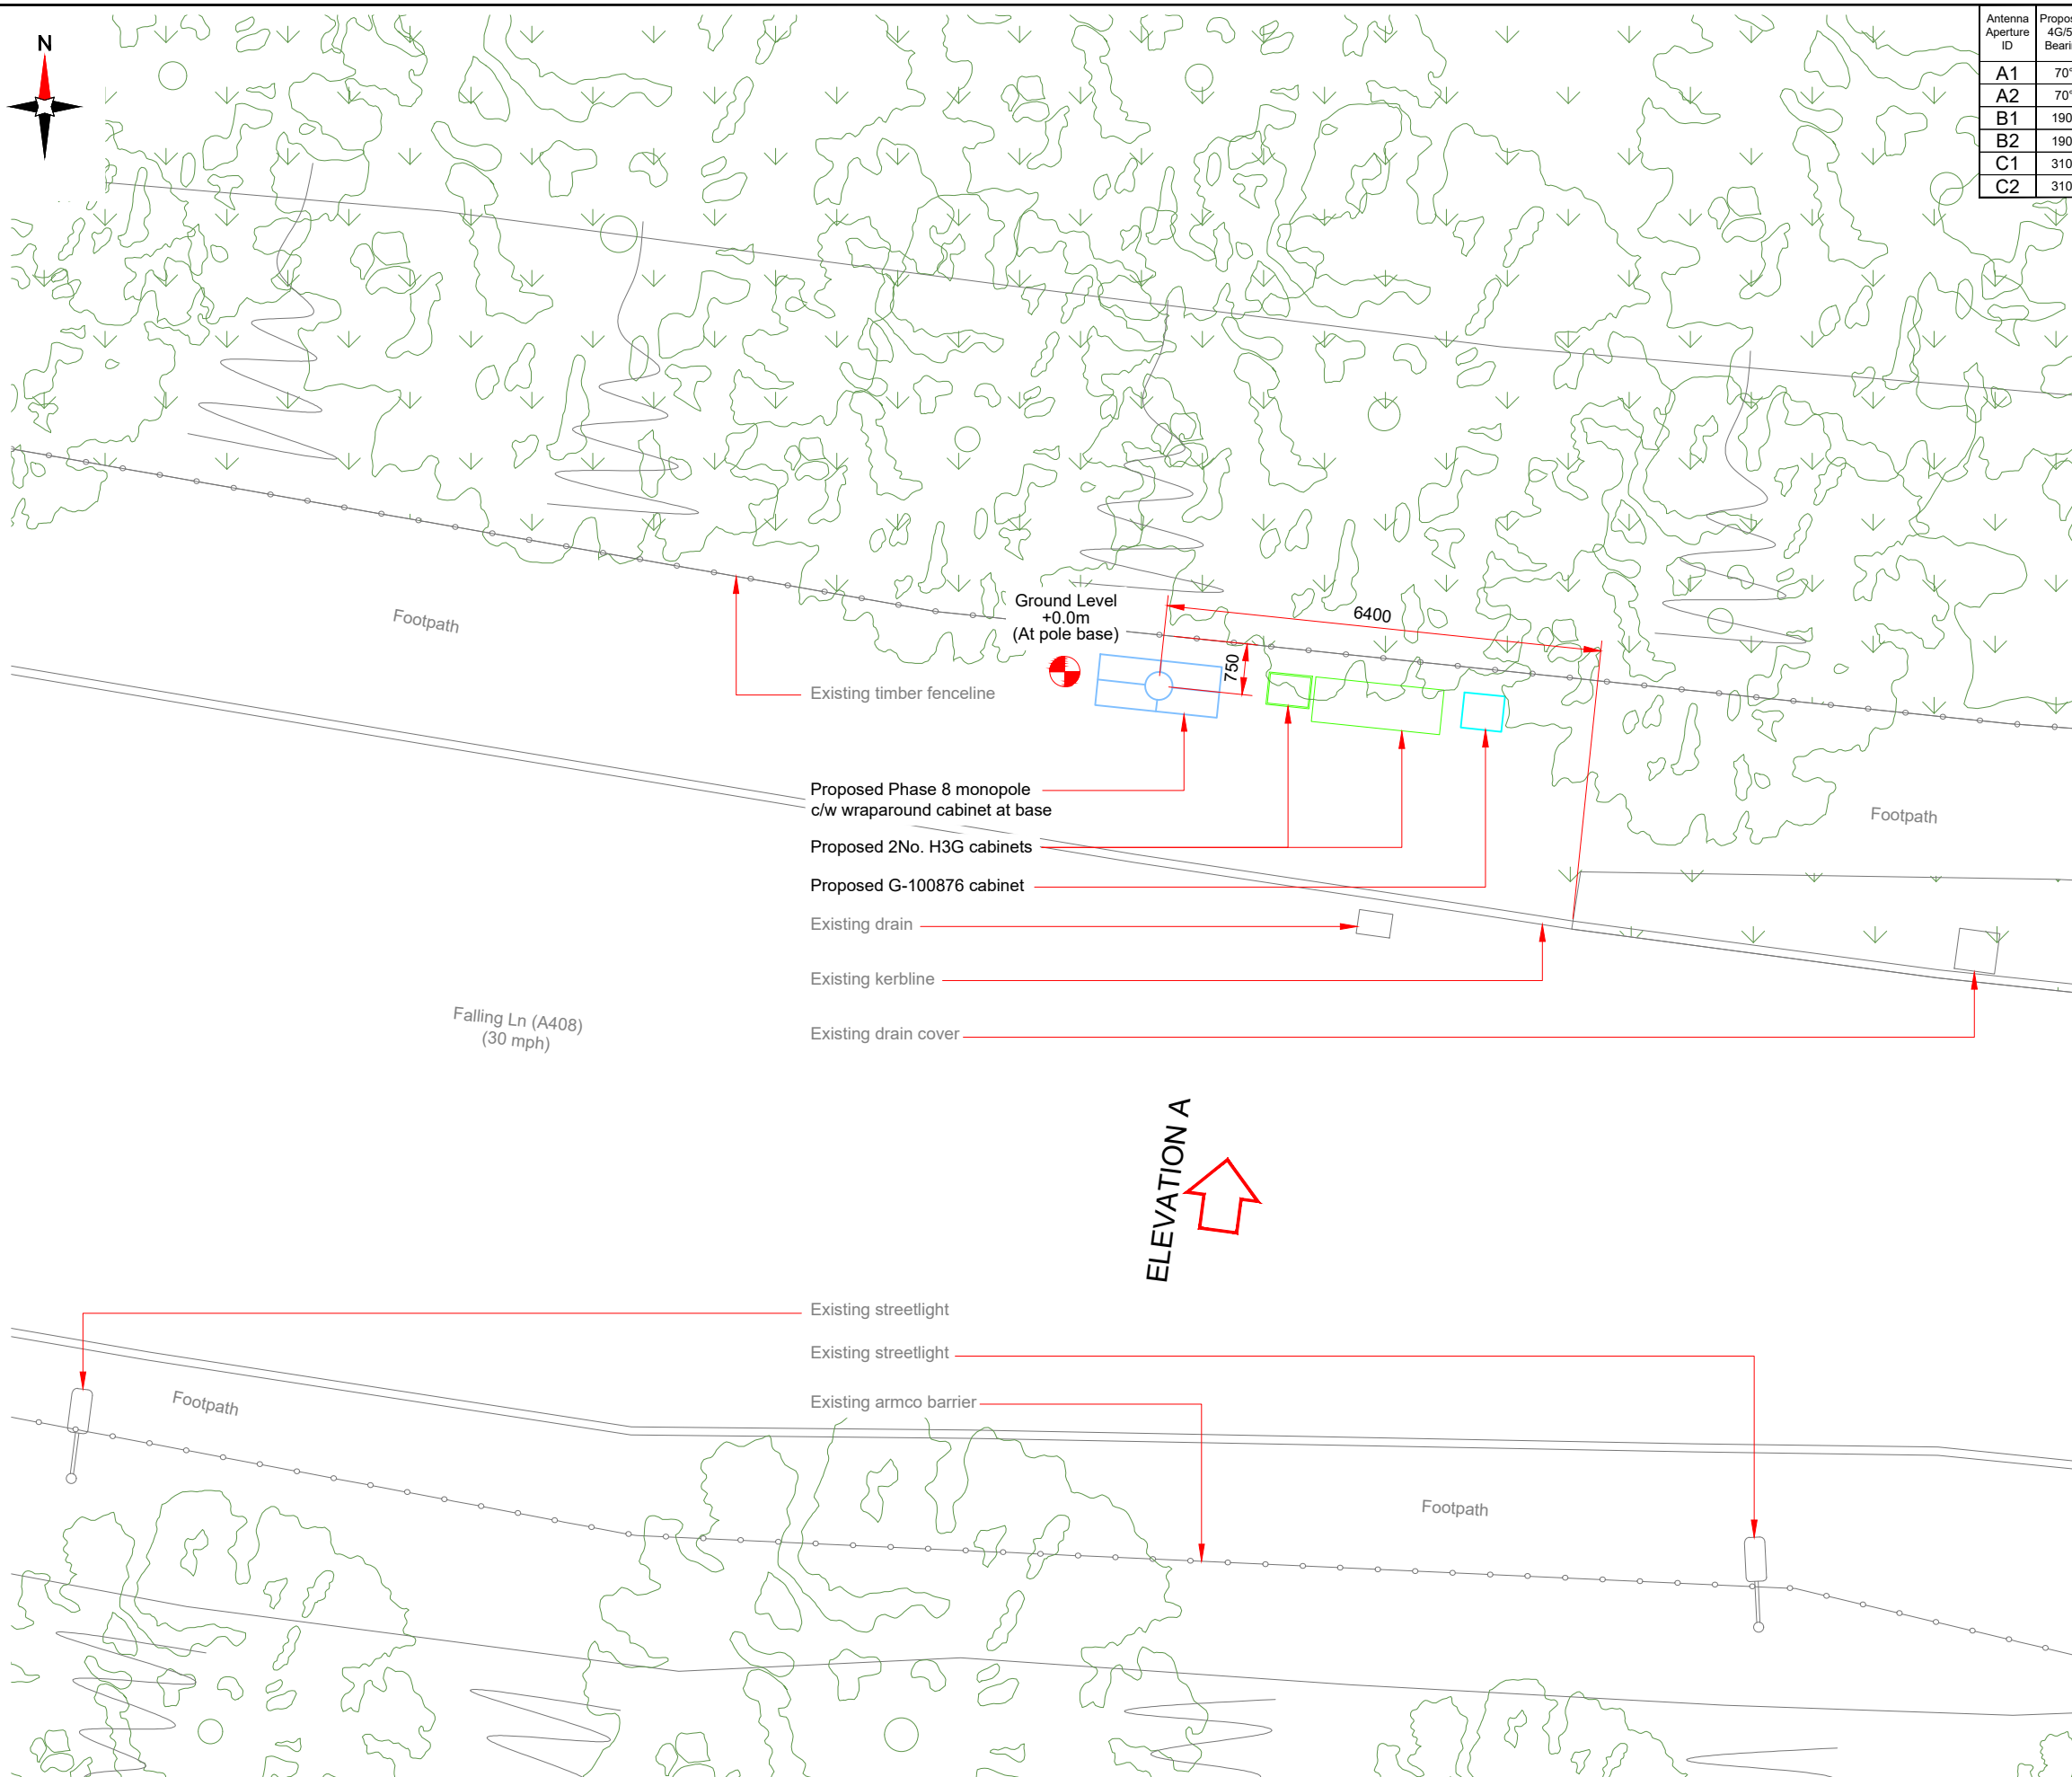

PROPOSED H3G SITE PLAN

 

Antenna Aperture ID	Proposed 4G/5G Bearing	Operator Shared EE/H3G
A1	70°	H3G
A2	70°	H3G
B1	190°	H3G
B2	190°	H3G
C1	310°	H3G
C2	310°	H3G

NOTES:

1. ALL DIMENSIONS IN MM UNLESS OTHERWISE NOTED.

Master:	MBNL / EE / H3G:	Project:	Purpose of Issue:	Issue:
M001	MBNL	H3G 5G UNILATERAL	Planning	A
Date:	12/08/2020	Revision / Upgrade Description:		
Drawn:	CDN	First Issue - Site nomination dated: TBC		
Checked:	DH			
Approved:	SD			



Hutchison 3G UK Limited
Star House, 20 Grenfell Road
Maidenhead, SL6 1EH
Tel: 01628 765 000
Fax: 01628 765 001

H3G Base Station Information line:
0845 6043000
Available 8am-8pm Monday to Friday

Design Consultant & Principal Contractor:



WHP Telecoms
Unit 1 Maple Park,
Low Fields Avenue, Leeds
LS12 6HH

Tel: 01133023550
e-mail: info@whptelecoms.com

Site Name:

FALLING LANE

Site ID:

HGN12097

Address:

Address: FALLING LANE
YIEWSLEY
LONDON BOROUGH OF HILLINGDON,
LONDON, GREATER LONDON
ENGLAND
UB7 8PD

Title:

210 PROPOSED H3G SITE PLAN

Project:

H3G 5G UNILATERAL

Purpose of Issue:	
-------------------	--

PLANNING

EE Cell ID: N/A	MBNL Cell ID: N/A	3UK Cell ID: N/A
---------------------------	-----------------------------	----------------------------


Master Drawing No:

HGN12097 M001

Issue:

A

100mm
50mm
10mm

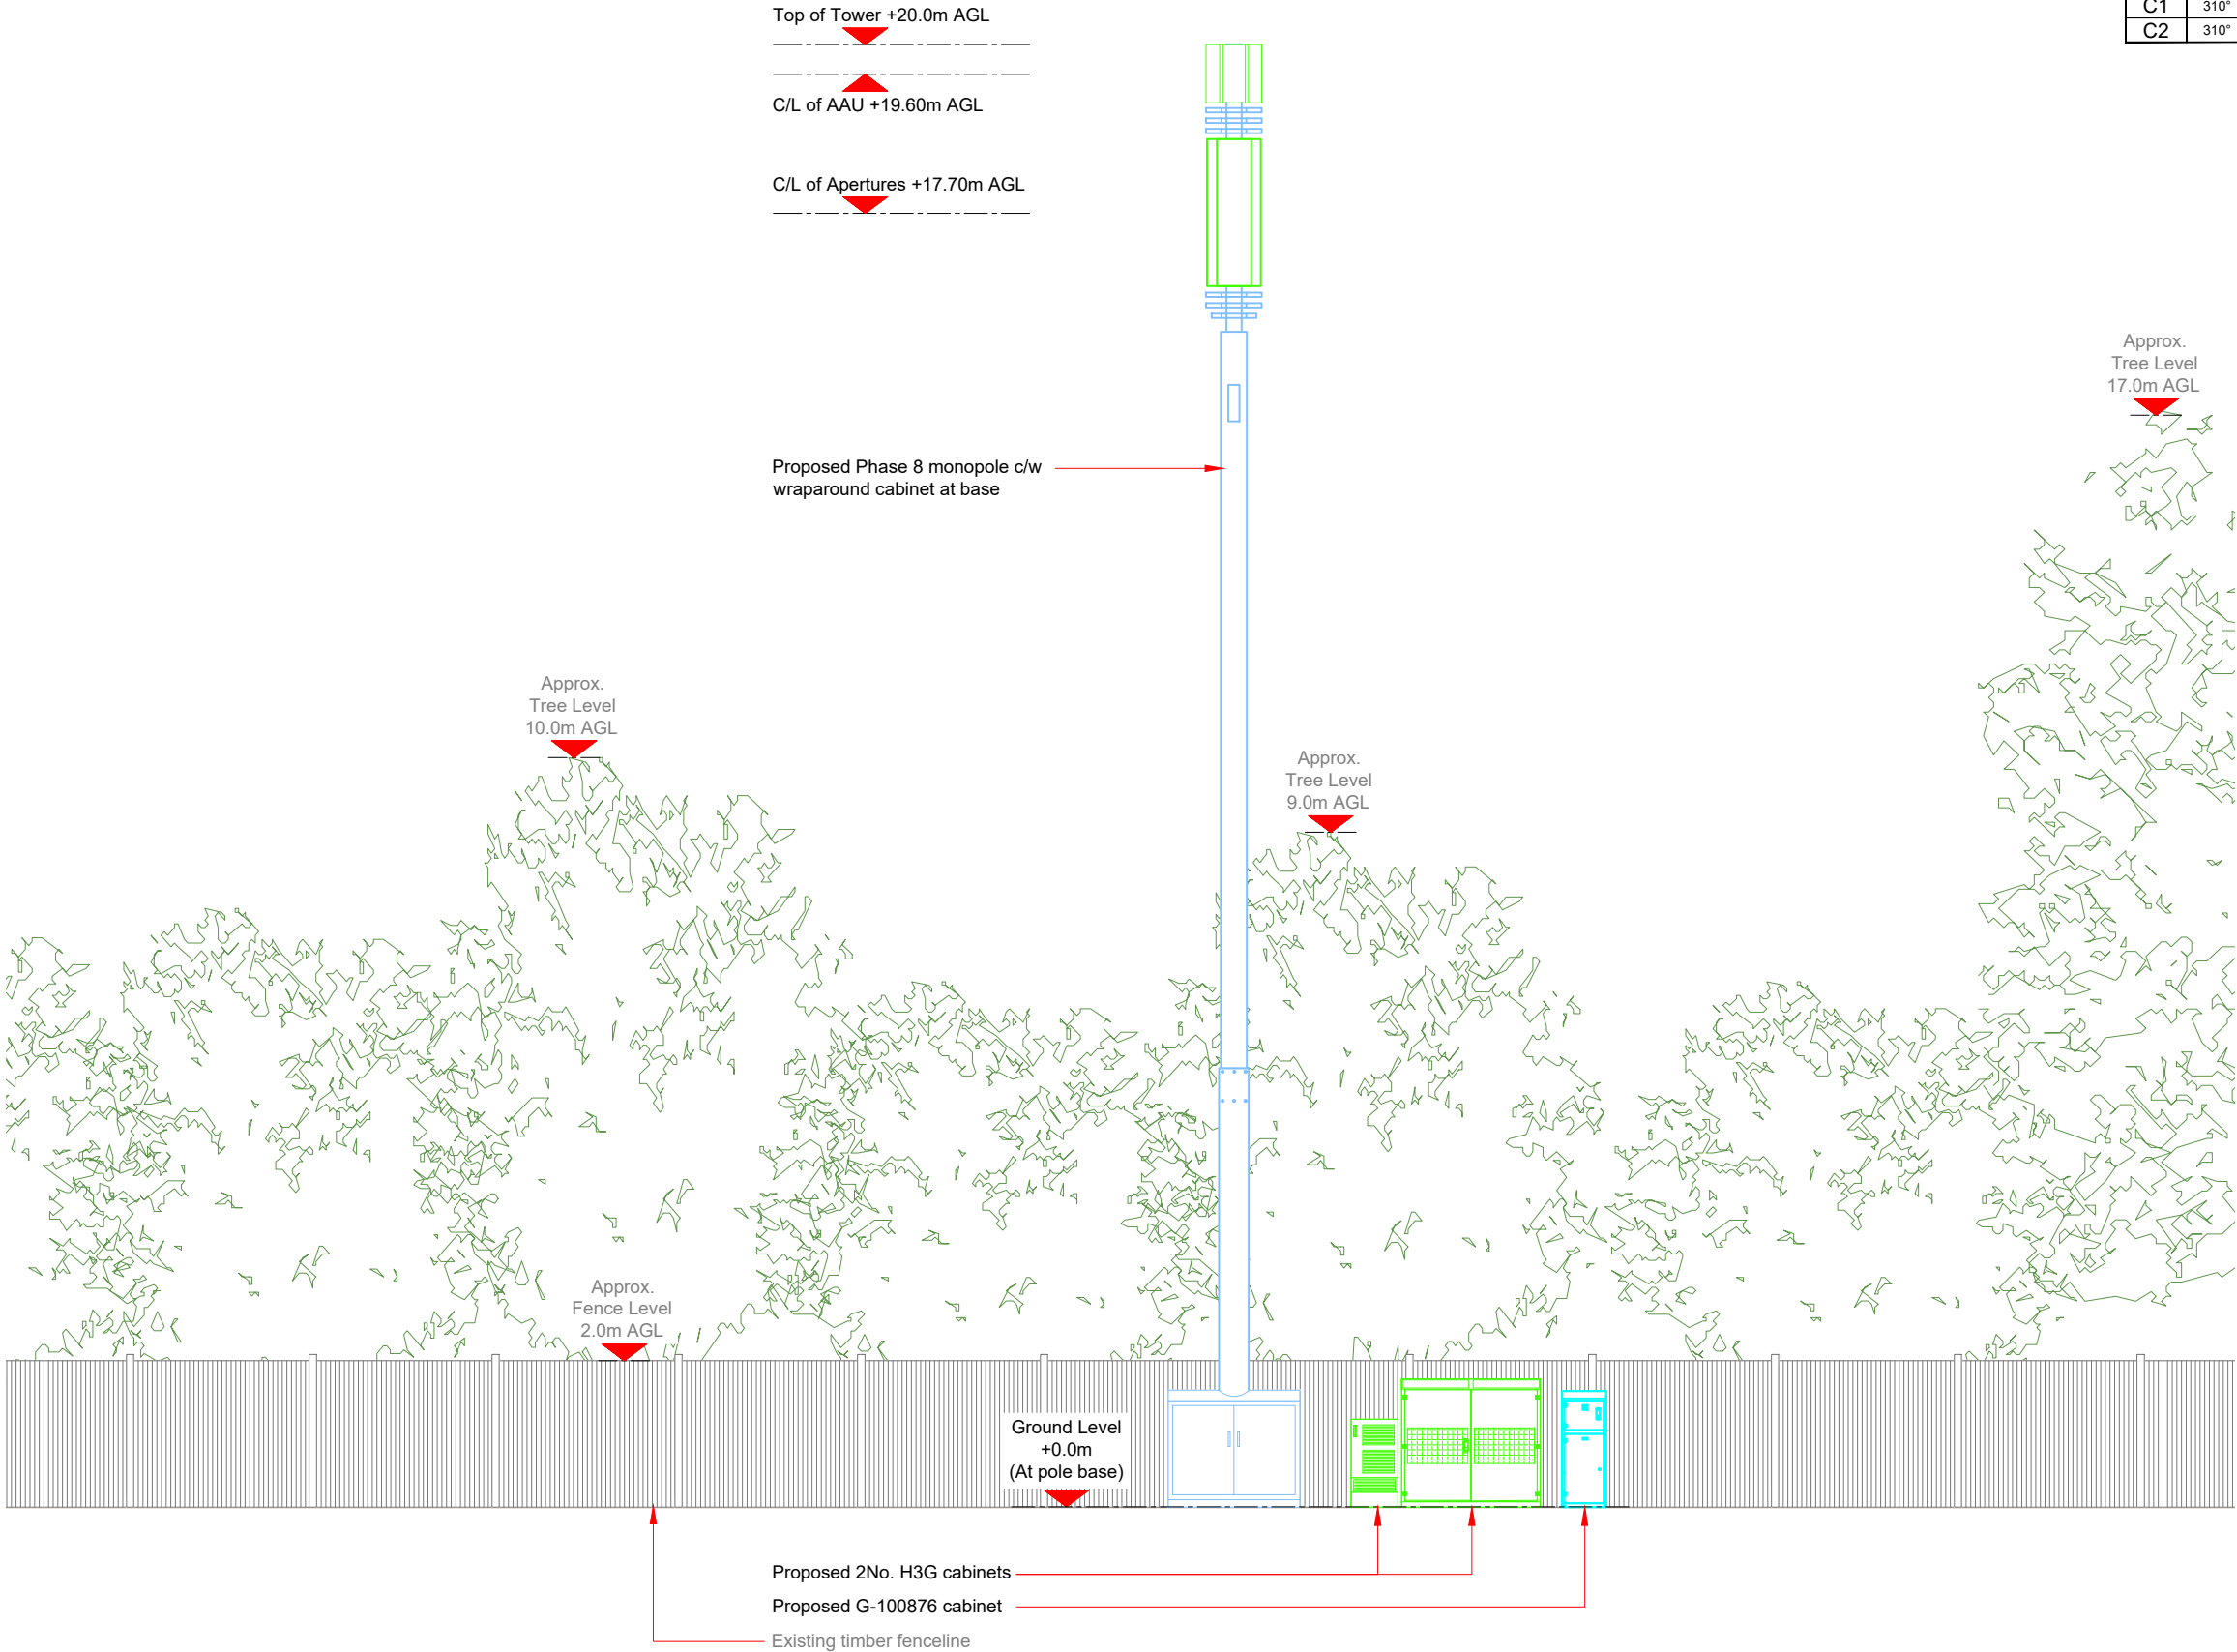

Antenna Aperture ID	Proposed 4G/5G Bearing	Operator: Shared/ EE/H3G
A1	70°	H3G
A2	70°	H3G
B1	190°	H3G
B2	190°	H3G
C1	310°	H3G
C2	310°	H3G

NOTES:

1. ALL DIMENSIONS IN MM UNLESS OTHERWISE NOTED.

Master:	MBNL / EE / H3G:	Project:	Purpose of Issue:	Issue:
M001	MBNL	H3G 5G UNILATERAL	Planning	A
Date:	12/08/2020	Revision / Upgrade Description:		
Drawn:	CDN	First Issue - Site nomination dated: TBC		
Checked:	DH			
Approved:	SD			



Hutchison 3G UK Limited
Star House, 20 Grenfell Road
Maidenhead, SL6 1EH
Tel: 01628 765 000
Fax: 01628 765 001

H3G Base Station Information line:
0845 6043000
Available 8am-8pm Monday to Friday

Design Consultant & Principal Contractor:



WHP Telecoms
Unit 1 Maple Park,
Low Fields Avenue, Leeds
LS12 6HH

Tel: 01133023550
e-mail: info@whptelecoms.com

Site Name: FALLING LANE

Site ID: HGN12097

Address: FALLING LANE
YIEWSLEY
LONDON BOROUGH OF HILLINGDON,
LONDON, GREATER LONDON
ENGLAND
UB7 8PD

Title: 260 PROPOSED H3G ELEVATION


Project: H3G 5G UNILATERAL

Purpose of Issue: PLANNING

EE Cell ID:	MBNL Cell ID:	3UK Cell ID:
N/A	N/A	N/A

Master Drawing No:	Issue:
HGN12097_M001	A

Proposed H3G Antenna Aperture Schedule & RF Equipment Capacity																	
Antenna Aperture ID	Antenna Aperture Size (Length x Width x Depth)	Aperture Height C/L	Aperture Max Weight (kg)	Proposed 4G/5G Bearing	Tech: 4G/5G	Operator: Shared/ EE/H3G	Antenna Aperture Coordinates		RRU No. Max Size & Weight L=320mm W=400mm D=150mm Weight=25kg	MHA No. Max Size & Weight L=300mm W=300mm D=150mm Weight=10kg	Main Feeder			BOB Max Size & Weight (300x300x250mm & 5kg)		Active Router No. Max Size & Weight (370x260x150mm & 10kg)	Passive Router No. Max Size & Weight (350x220x150mm & 10kg)
							Eastings	Northings			Size	Length	No.	No. Top	No. Bottom		
A1	795x395x220mm	19.60m	45kg	70°	5G	H3G	-	-	0	0	TBC	TBC	4	1	1	1	1
A2	2009x469x206mm	17.70m	TBC	70°	3G/4G	H3G	-	-	3	0	TBC	TBC	4	1	1	1	1
B1	795x395x220mm	19.60m	45kg	190°	5G	H3G	-	-	0	0	TBC	TBC	4	1	1	1	1
B2	2009x469x206mm	17.70m	TBC	190°	3G/4G	H3G	-	-	3	0	TBC	TBC	4	1	1	1	1
C1	795x395x220mm	19.60m	45kg	310°	5G	H3G	-	-	0	0	TBC	TBC	4	1	1	1	1
C2	2009x469x206mm	17.70m	TBC	310°	3G/4G	H3G	-	-	3	0	TBC	TBC	4	1	1	1	1

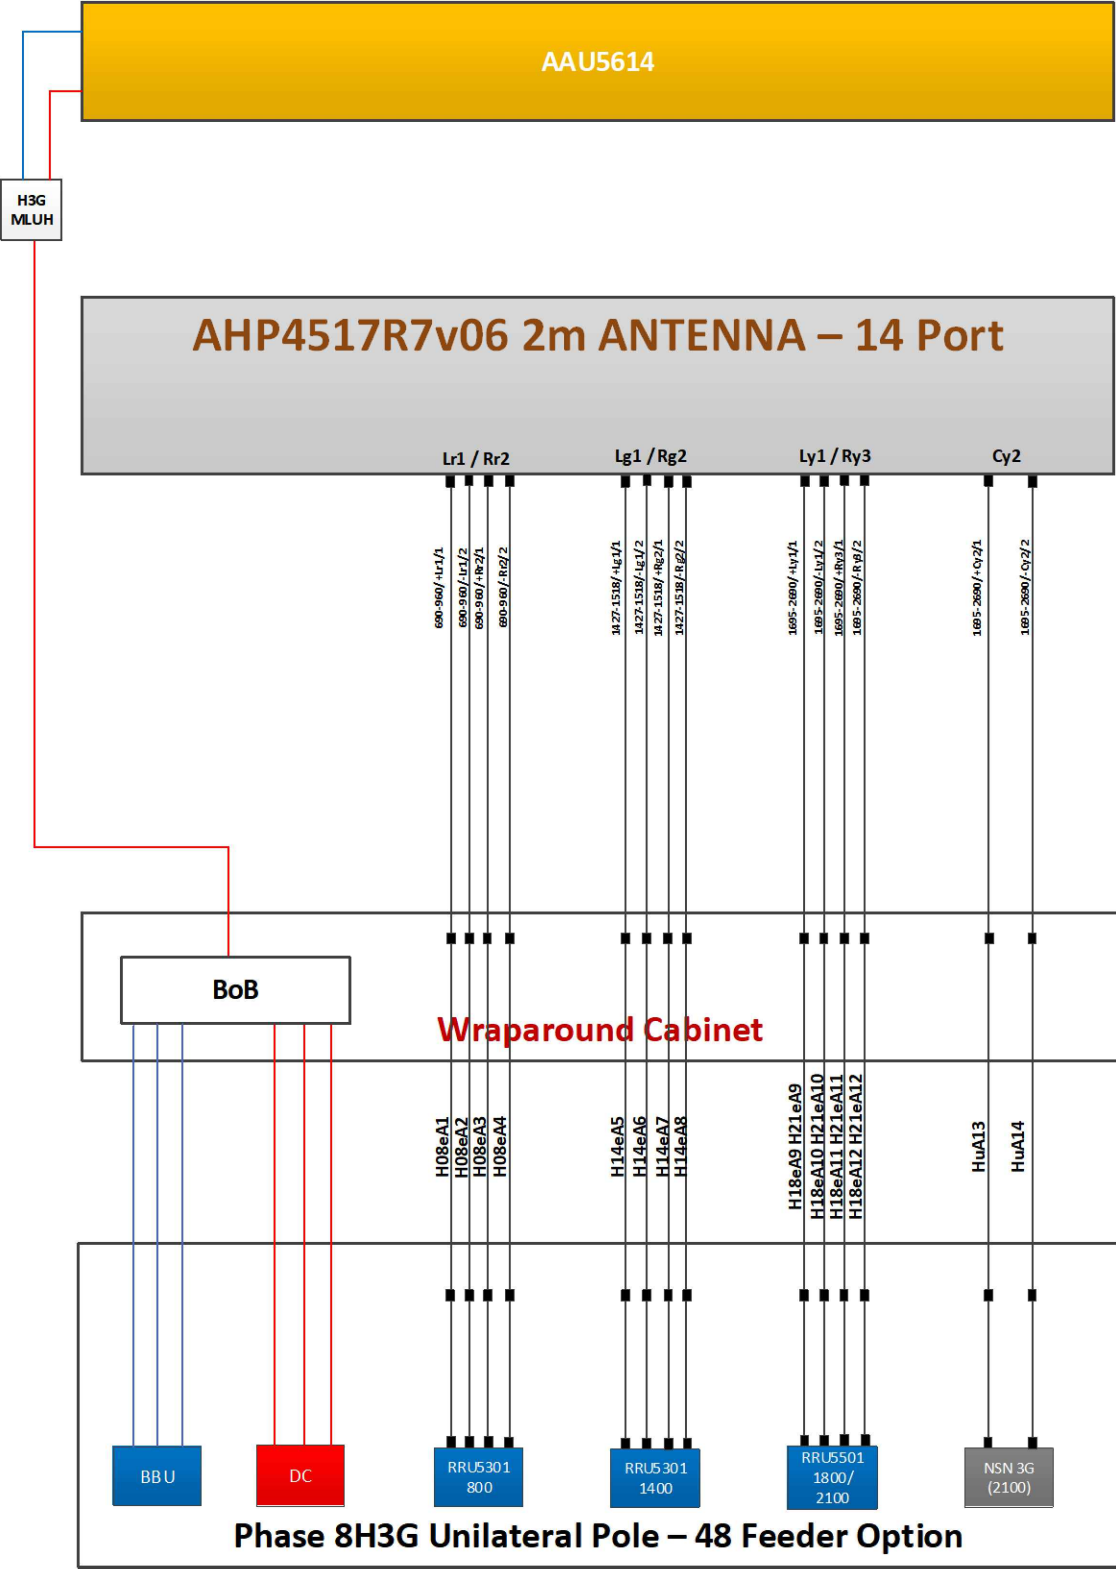

STATUS KEY:

Installed: Existing

Retain: Existing and to remain

Relocate: Existing and to be relocated

Remove: Existing to be removed from site

Proposed: New on site

Master:	MBNL / EE / H3G:	Project:	Purpose of Issue:	Issue:
M001	MBNL	H3G 5G UNILATERAL	Planning	A
Date:	12/08/2020	Revision / Upgrade Description:		
Drawn:	CDN	First Issue - Site nomination dated: TBC		
Checked:	DH			
Approved:	SD			



Hutchison 3G UK Limited
Star House, 20 Grenfell Road
Maidenhead, SL6 1EH
Tel: 01628 765 000
Fax: 01628 765 001

H3G Base Station Information line:
0845 6043000
Available 8am-8pm Monday to Friday

Design Consultant & Principal Contractor:

WHP Telecoms
Unit 1 Maple Park,
Low Fields Avenue, Leeds
LS12 6HH

Tel: 01133023550
e-mail: info@whptelecoms.com

Site Name: **FALLING LANE**

Site ID: **HGN12097**

Address: **FALLING LANE
YIEWSLEY
LONDON BOROUGH OF HILLINGDON,
LONDON, GREATER LONDON
ENGLAND
UB7 8PD**

Title: **303 PROPOSED H3G ANTENNA
SCHEDULE & LINE CONFIGURATION**

Project: **H3G 5G UNILATERAL**

Purpose of Issue: **PLANNING**

EE Cell ID:	MBNL Cell ID:	3UK Cell ID:
N/A	N/A	N/A

Master Drawing No:	Issue:
HGN12097_M001	A

Support Structure Schedule										
Structure ID	Status	Equipment Description / Type	Structure Manufacturer	Height AGL (m)	Colour (RAL Colour)	Headframe Details	Foundation / Support Grillage / Host Structure Details	Support Bolt Details	MBNL Ref:	Comments
ST1	Proposed	Phase 8	-	20.0m	Galvanised	-	Root Foundation	-	-	

--	--	--	--	--	--	--	--	--	--	--

Equipment Schedule													
Equipment ID	Quantity	Status	Equipment Description / Type	Equipment Manufacturer	Dimensions (W x D x H)	Weight (kg)	Colour (RAL Colour)	Material	Location	Power	Power cable length (m)	MBNL Ref:	Comments
CAB1	1	Proposed	H3g - Bowler	-	1900x600x1752	-	Grey	Steel	Outdoor	-	-	-	
CAB2	1	Proposed	H3g - APM5930	-	640x480x1200	-	Grey	Steel	Outdoor	-	-	-	
CAB3	1	Proposed	G-100876	-	600x520x1585	-	Grey	Steel	Outdoor	-	-	-	
CAB4	1	Proposed	Diplexer Cabinet	-	1800x750x1600	-	Grey	Steel	Outdoor	-	-	-	

--	--	--	--	--	--	--	--	--	--	--	--	--	--

STATUS KEY:

Installed:

Existing

Retain:

Existing and to remain

Relocate:

Existing and to be relocated

Remove:

Existing to be removed from site

Proposed:

New on site

LOCATION KEY:

Outdoor:

Located outside

Indoor:

Located within an equipment cabin or equipment room

Internal:

located inside a cabinet or item of equipment

Master:	MBNL / EE / H3G:	Project:	Purpose of Issue:	Issue:
M001	MBNL	H3G 5G UNILATERAL	Planning	A
Date:	12/08/2020	Revision / Upgrade Description:		
Drawn:	CDN	First Issue - Site nomination dated: TBC		
Checked:	DH			
Approved:	SD			



Hutchison 3G UK Limited

Star House, 20 Grenfell Road

Maidenhead, SL6 1EH

Tel: 01628 765 000

Fax: 01628 765 001

H3G Base Station Information line:

0845 6043000

Available 8am-8pm Monday to Friday

Design Consultant & Principal Contractor:



WHP Telecoms

Unit 1 Maple Park,

Low Fields Avenue, Leeds

LS12 6HH

Tel: 01133023550

e-mail: info@whptelecoms.com

Site Name:

FALLING LANE

Site ID:

HGN12097

Address:

FALLING LANE

YIEWSLEY

LONDON BOROUGH OF HILLINGDON,

LONDON, GREATER LONDON

ENGLAND

UB7 8PD

Title:

305 EQUIPMENT SCHEDULE & SUPPORT STRUCTURE DETAILS

Project:

H3G 5G UNILATERAL

Purpose of Issue:

PLANNING

EE Cell ID:	MBNL Cell ID:	3UK Cell ID:
N/A	N/A	N/A

Master Drawing No:

HGN12097_M001

Issue:

A

100mm

50mm

10mm

100mm

50mm

10mm

100mm

50mm

10mm