


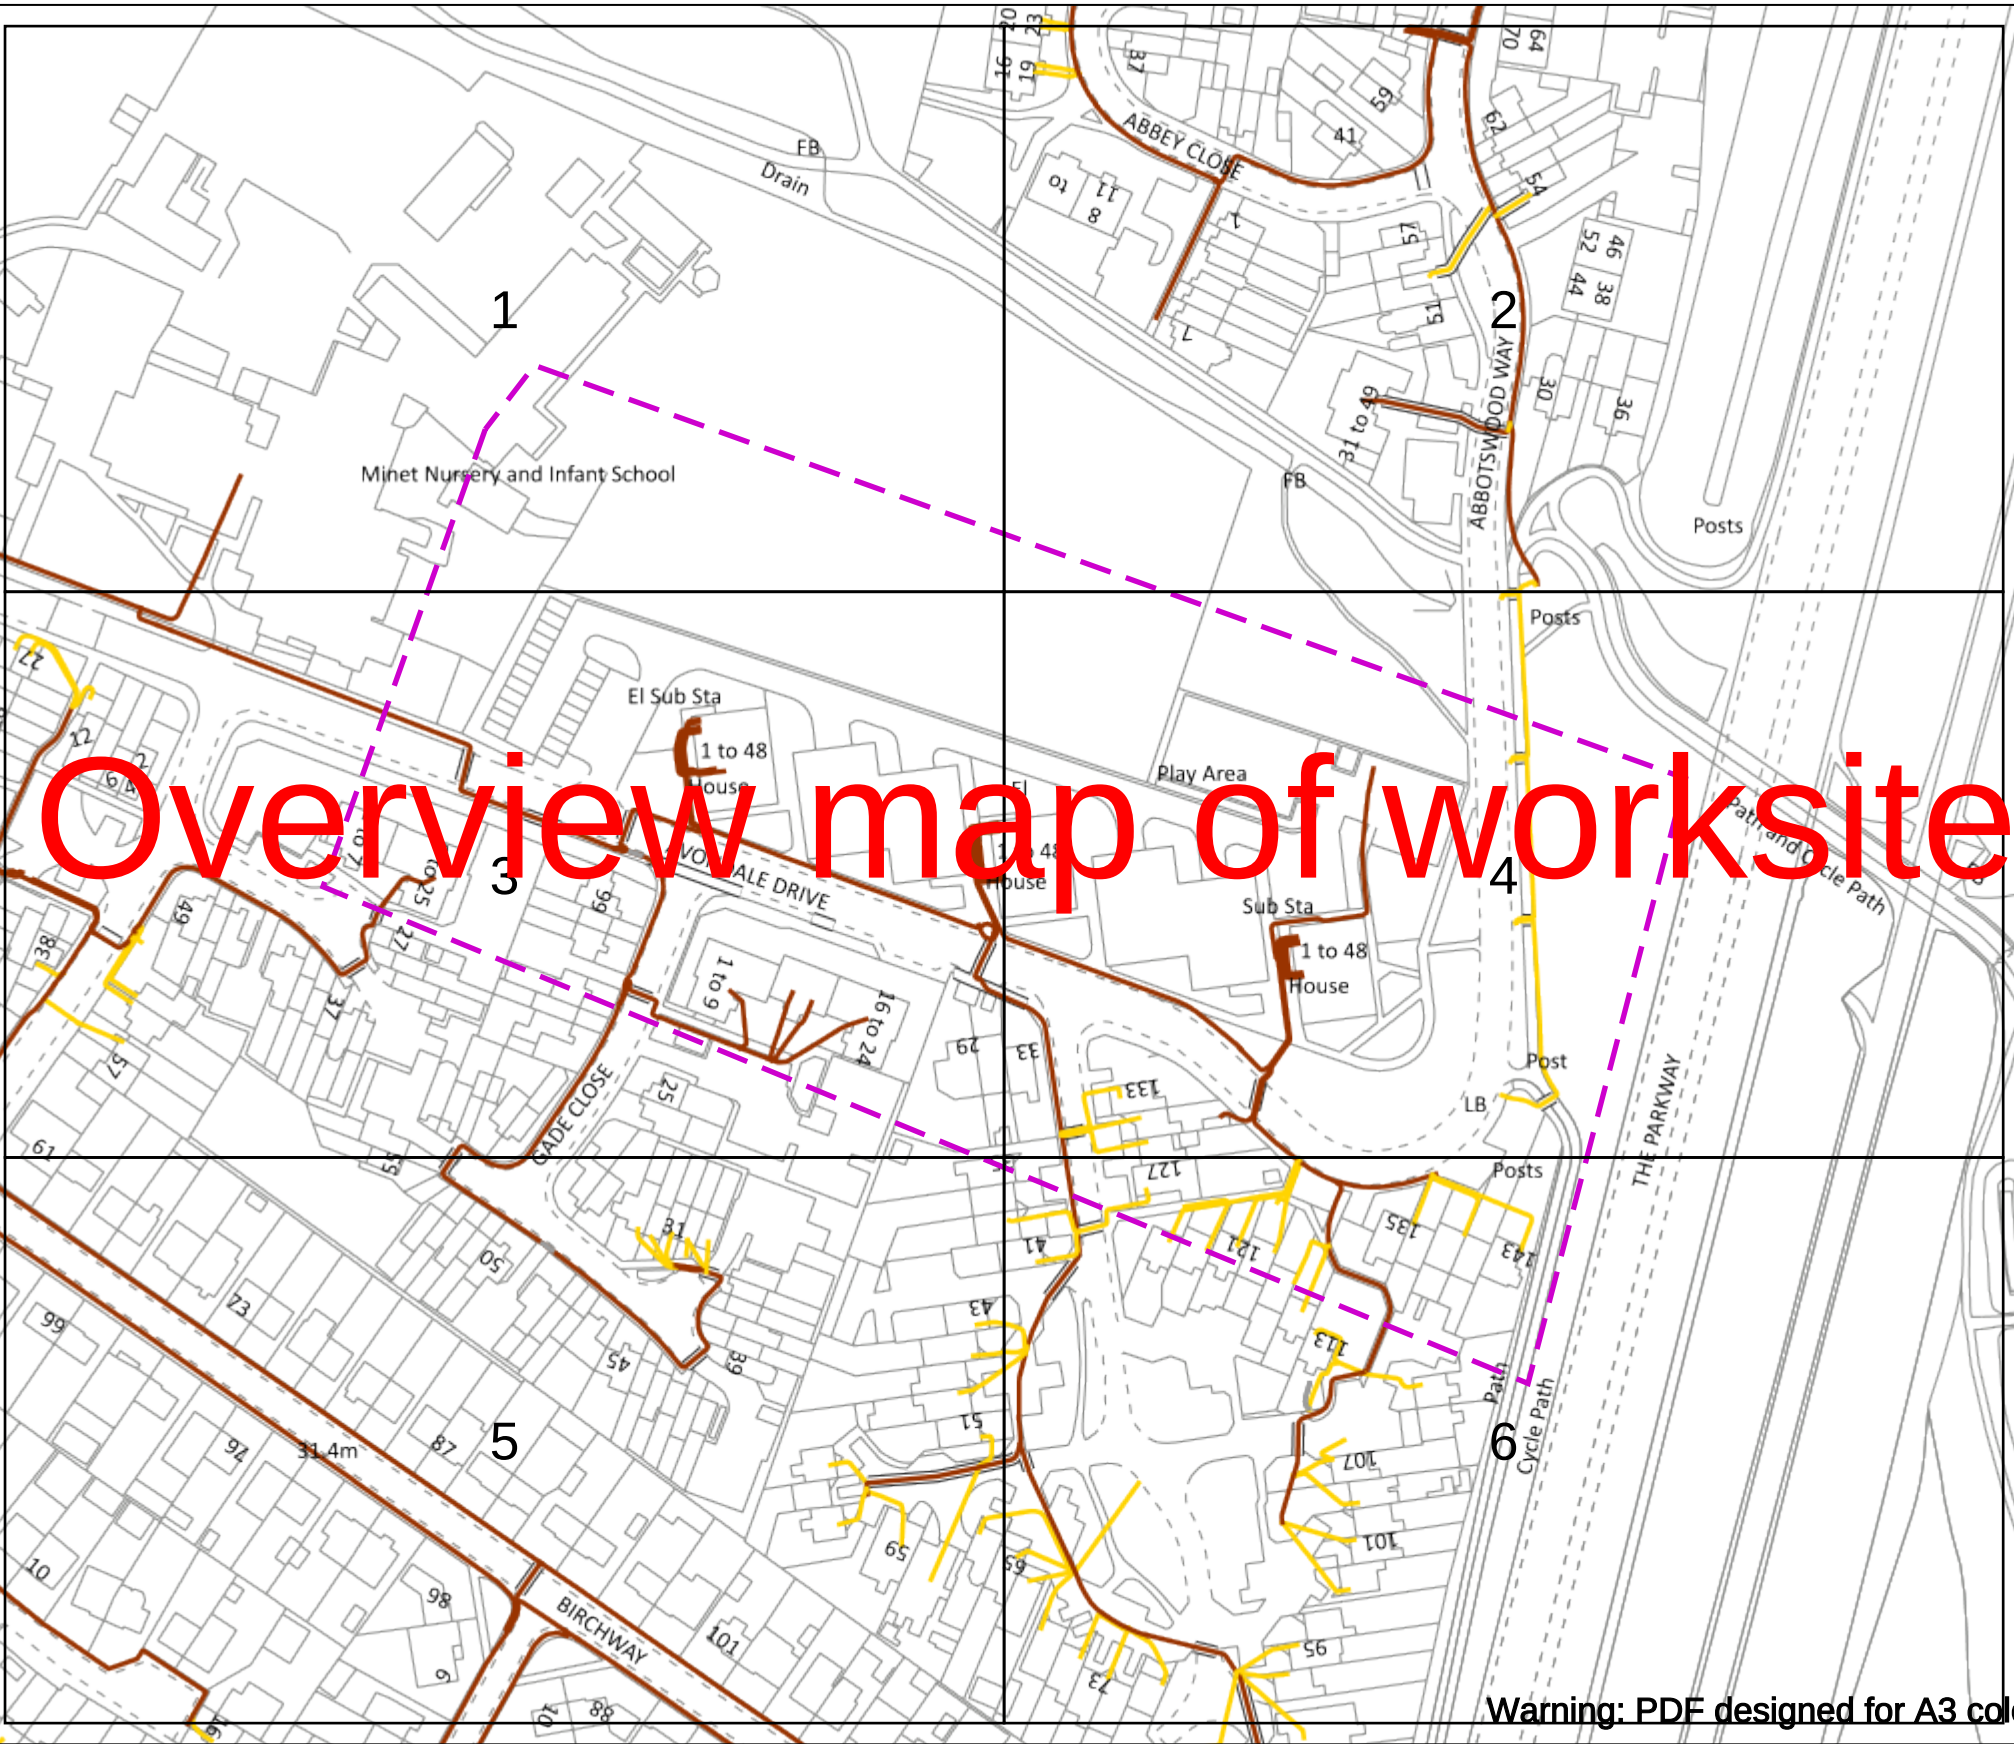

Warning: PDF designed for A3 colour print only with no page scaling

Date Requested: 15/09/2021
Job Reference: 23270156
Site Location: 510755 180225
Requested by:
Mr Brian McMaster
Your Scheme/Reference:
NOC/BGJHM742

Scale: 1:1538 (When plotted at A3)

WARNING

There may have been subsequent alteration to the surface levels. Trial holes must be undertaken to determine position and depths of cables. HS (G) 47 Booklet from the Health and Safety Executive – Avoiding Danger from Buried Cables – should be consulted before commencing excavation work.

WHEN WORKING IN THE VICINITY OF OVERHEAD LINES THE HEALTH AND SAFETY GUIDANCE NOTES GS6 SHOULD BE CONSULTED (AVAILABLE FROM THE HSE WEBSITE)

Dig Sites Area: Line:

	Voltages (V)			
LV (Low Voltage) and Services	Up to 1,000V			
HV (High Voltage)	Over 1,000V to 11,000V			
EHV (Extra High Voltage)	22,000V to 132,000V			
Transmission	275,000V and 400,000V			

	NORMAL DEPTH TO THE TOP OF THE CABLE WHEN LAID			
	Services	LV	HV	EHV
Footpath/Unmade	0.45m	0.45m	0.6m	0.8m
Road Crossing	0.6m	0.6m	0.75m	0.9m
Agricultural	1m	1m	1m	1.1m

Legend

- Service Cable
- LV Mains
- 2 – 3.3kV
- 6.6kV
- 11kV
- 22kV
- 33kV
- 66kV
- 132kV
- 275kV
- 400kV
- Fibre Optic
- Pilot Cable

Distribution Structures (Electric)

- Pole, Existing Location
- Pole Structure, Existing Location - Single
- Pole Structure, Existing Location - H
- Duct Route
- Cross Section Route

Scottish & Southern
Electricity Networks


Southern Electric Power Distribution plc
Registered Office: No.1 Forbury Place
43 Forbury Road Reading RG1 3JH
Registered In England & Wales No.04094290

If you're unsure & need to seek advice before commencing excavations please contact:
General Enquiries: 0800 048 3516

Subject to revision – Master held by SSEN Asset Data Team:
Asset.Data@sse.com
01256 337 294

BASED UPON THE ORDNANCE SURVEY MAP WITH THE SANCTION OF THE CONTROLLER OF H.M STATIONERY OFFICE CROWN COPYRIGHT RESERVED.

This copy has been made by or with the authority of Scottish and Southern Energy Power Distribution Ltd. Pursuant to section 47 of the Copyright, Designs and Patents Act 1988 ('The Act'). Unless the Act provides a relevant exception to copyright the copy must not be copied without prior permission of the copyright owner. Plans generated by DigSAFE Pro™ software provided by LinesearchbeforeUdig.

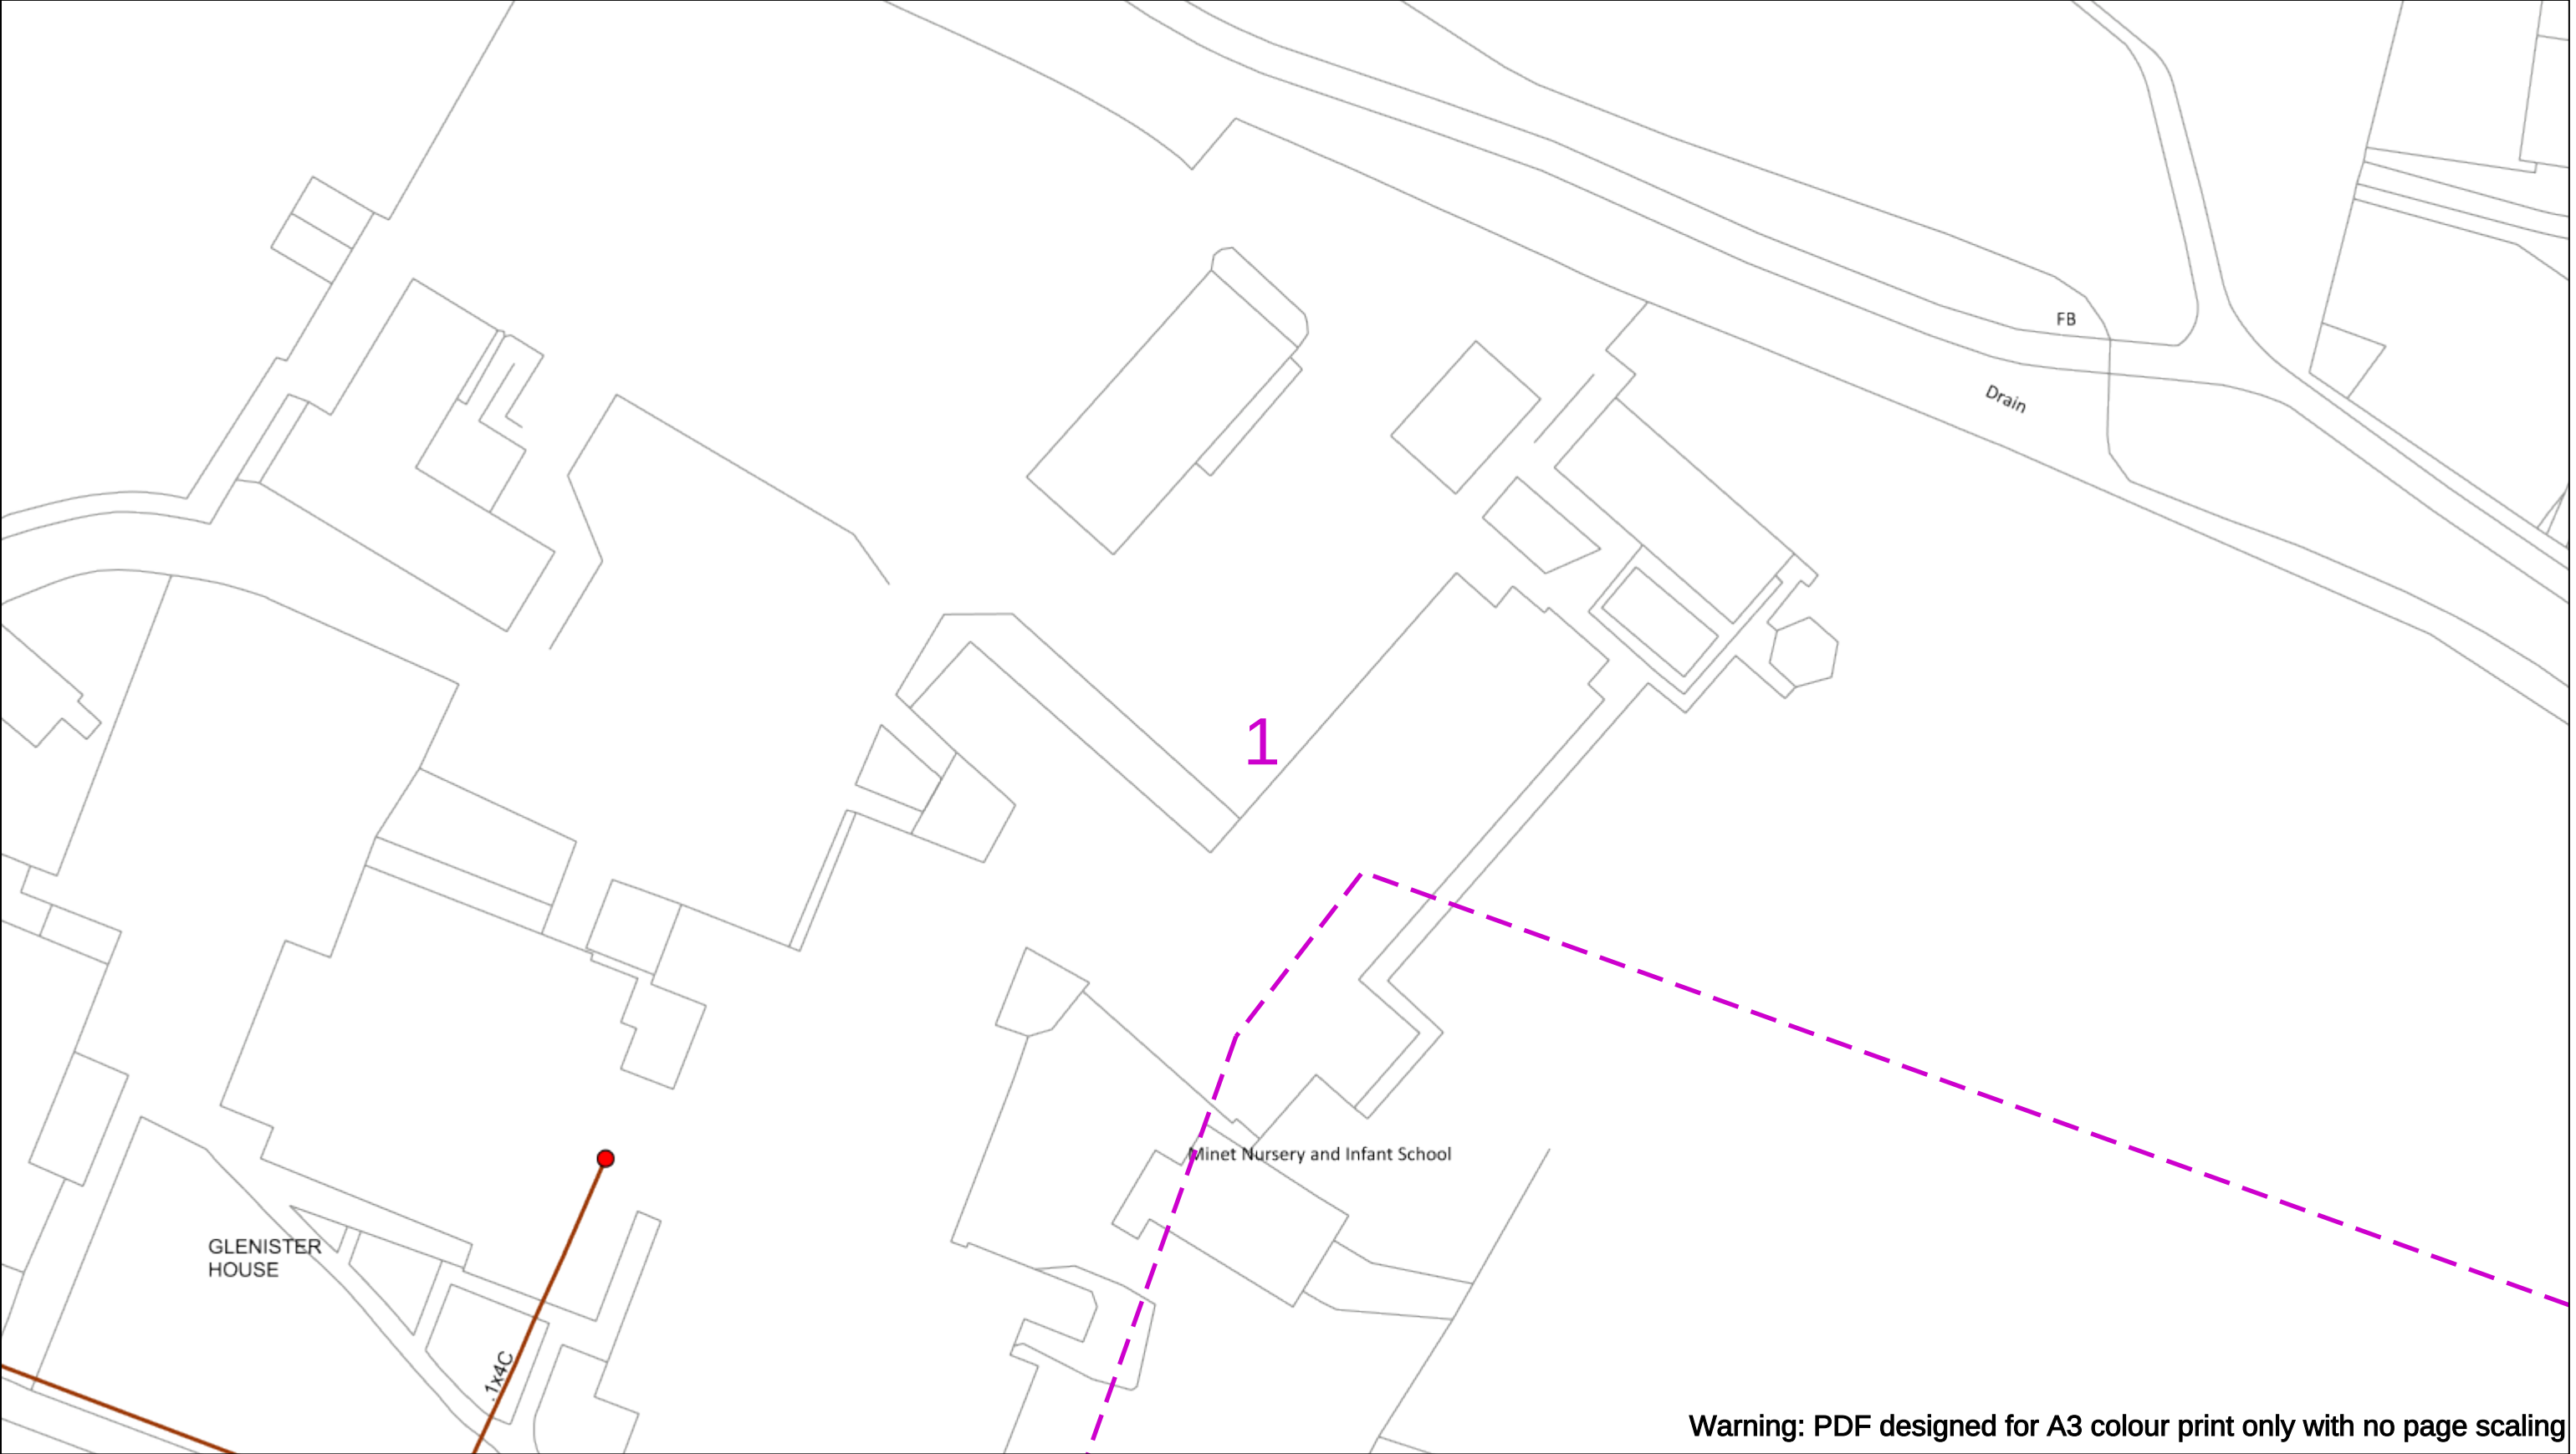

Warning: PDF designed for A3 colour print only with no page scaling

050m

Dig Sites

Area:

Line:

Date Requested: 15/09/2021

Job Reference: 23270156

Site Location: 510755 180225

Requested by:
Mr Brian McMaster

Your Scheme/Reference:
NOC/BGJHM742

WARNING

There may have been subsequent alteration to the surface levels. Trial holes must be undertaken to determine position and depths of cables. HS (G) 47 Booklet from the Health and Safety Executive – Avoiding Danger from Buried Cables – should be consulted before commencing excavation work.

WHEN WORKING IN THE VICINITY OF OVERHEAD LINES THE HEALTH AND SAFETY GUIDANCE NOTES GS6 SHOULD BE CONSULTED (AVAILABLE FROM THE HSE WEBSITE)

Scale: 1:500 (When plotted at A3)

Voltages (V)

LV (Low Voltage) and ServicesUp to 1,000V

HV (High Voltage)Over 1,000V to 11,000V

EHV (Extra High Voltage)22,000V to 132,000V

Transmission275,000V and 400,000V

NORMAL DEPTH TO THE TOP OF THE CABLE WHEN LAID

	Services	LV	HV	EHV
Footpath/Unmade	0.45m	0.45m	0.6m	0.8m
Road Crossing	0.6m	0.6m	0.75m	0.9m
Agricultural	1m	1m	1m	1.1m

Legend

Service Cable

LV Mains

2 – 3.3kV

6.6kV

11kV

22kV

33kV

66kV

132kV

275kV

400kV

Fibre Optic

Pilot Cable

Distribution Structures (Electric)

Pole, Existing Location

Pole Structure, Existing Location - Single

Pole Structure, Existing Location - H

Duct Route

Cross Section Route

Scottish & Southern
Electricity Networks

Southern Electric Power Distribution plc

Registered Office: No.1 Forbury Place

43 Forbury Road Reading RG1 3JH

Registered In England & Wales No.04094290

If you're unsure & need to seek advice before commencing excavations please contact:

General Enquiries: 0800 048 3516

Subject to revision – Master held by SSEN Asset Data Team:

Asset.Data@sse.com

01256 337 294

BASED UPON THE ORDNANCE SURVEY MAP WITH THE SANCTION OF THE CONTROLLER OF H.M STATIONERY OFFICE CROWN COPYRIGHT RESERVED.

This copy has been made by or with the authority of Scottish and Southern Energy Power Distribution Ltd. Pursuant to section 47 of the Copyright, Designs and Patents Act 1988 ('The Act'). Unless the Act provides a relevant exception to copyright the copy must not be copied without prior permission of the copyright owner. Plans generated by DigSAFE Pro™ software provided by LinesearchbeforeUdig.



Scale: 1:500 (When plotted at A3)

Legend

- Service Cable
- LV Mains
- 2 – 3.3kV
- 6.6kV
- 11kV
- 22kV
- 33kV
- 66kV
- 132kV
- 275kV
- 400kV
- Fibre Optic
- Pilot Cable

Southern Electric Power Distribution plc
Registered Office: No.1 Forbury Place
43 Forbury Road Reading RG1 3JH
Registered in England & Wales No.04094290

If you're unsure & need to seek advice before commencing excavations please contact:
General Enquiries: 0800 048 3516

Subject to revision – Master held by SSEN Asset Data Team:
Asset.Data@sse.com
01256 337 294

BASED UPON THE ORDNANCE SURVEY MAP WITH THE SANCTION OF THE CONTROLLER OF H.M STATIONERY OFFICE CROWN COPYRIGHT RESERVED.
This copy has been made by or with the authority of Scottish and Southern Energy Power Distribution Ltd. Pursuant to section 47 of the Copyright, Designs and Patents Act 1988 ('The Act'). Unless the Act provides a relevant exception to copyright the copy must not be copied without prior permission of the copyright owner. Plans generated by DigSAFE Pro™ software provided by LinesearchbeforeUdig.



Dig Sites Area: Line:

 




Southern Electric Power Distribution plc
Registered Office: No.1 Forbury Place
43 Forbury Road Reading RG1 3JH
Registered in England & Wales No.04094290


If you're unsure & need to seek advice before commencing excavations please contact:
General Enquiries: 0800 048 3516

Subject to revision – Master held by SSEN Asset Data Team:
Asset_Data@sse.com
01256 337 294

This copy has been made by or with the authority of Scottish and Southern Energy Power Distribution Ltd. Pursuant to section 47 of the Copyright, Designs and Patents Act 1988 ('The Act'). Unless the Act provides a relevant exception to copyright the copy must not be copied without prior permission of the copyright owner. Plans generated by DigSAFE Pro™ software provided by LinesearchbeforeUdig.



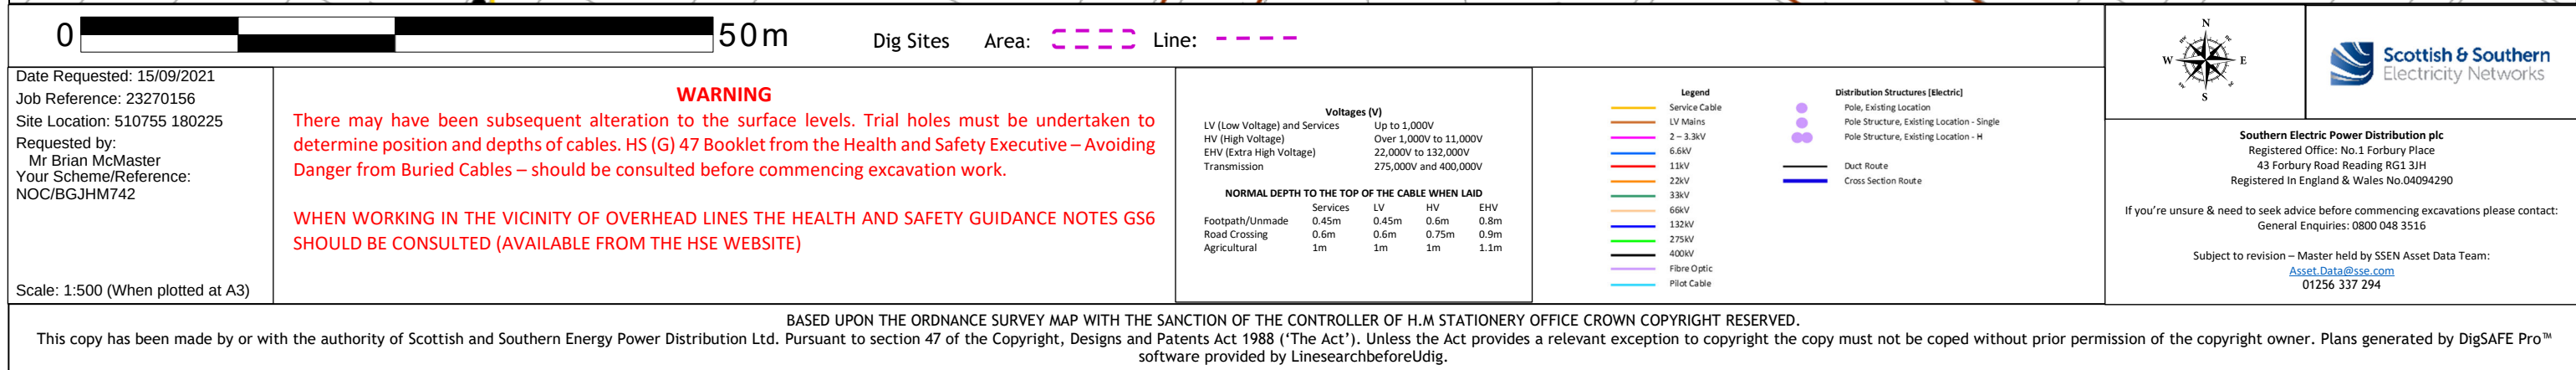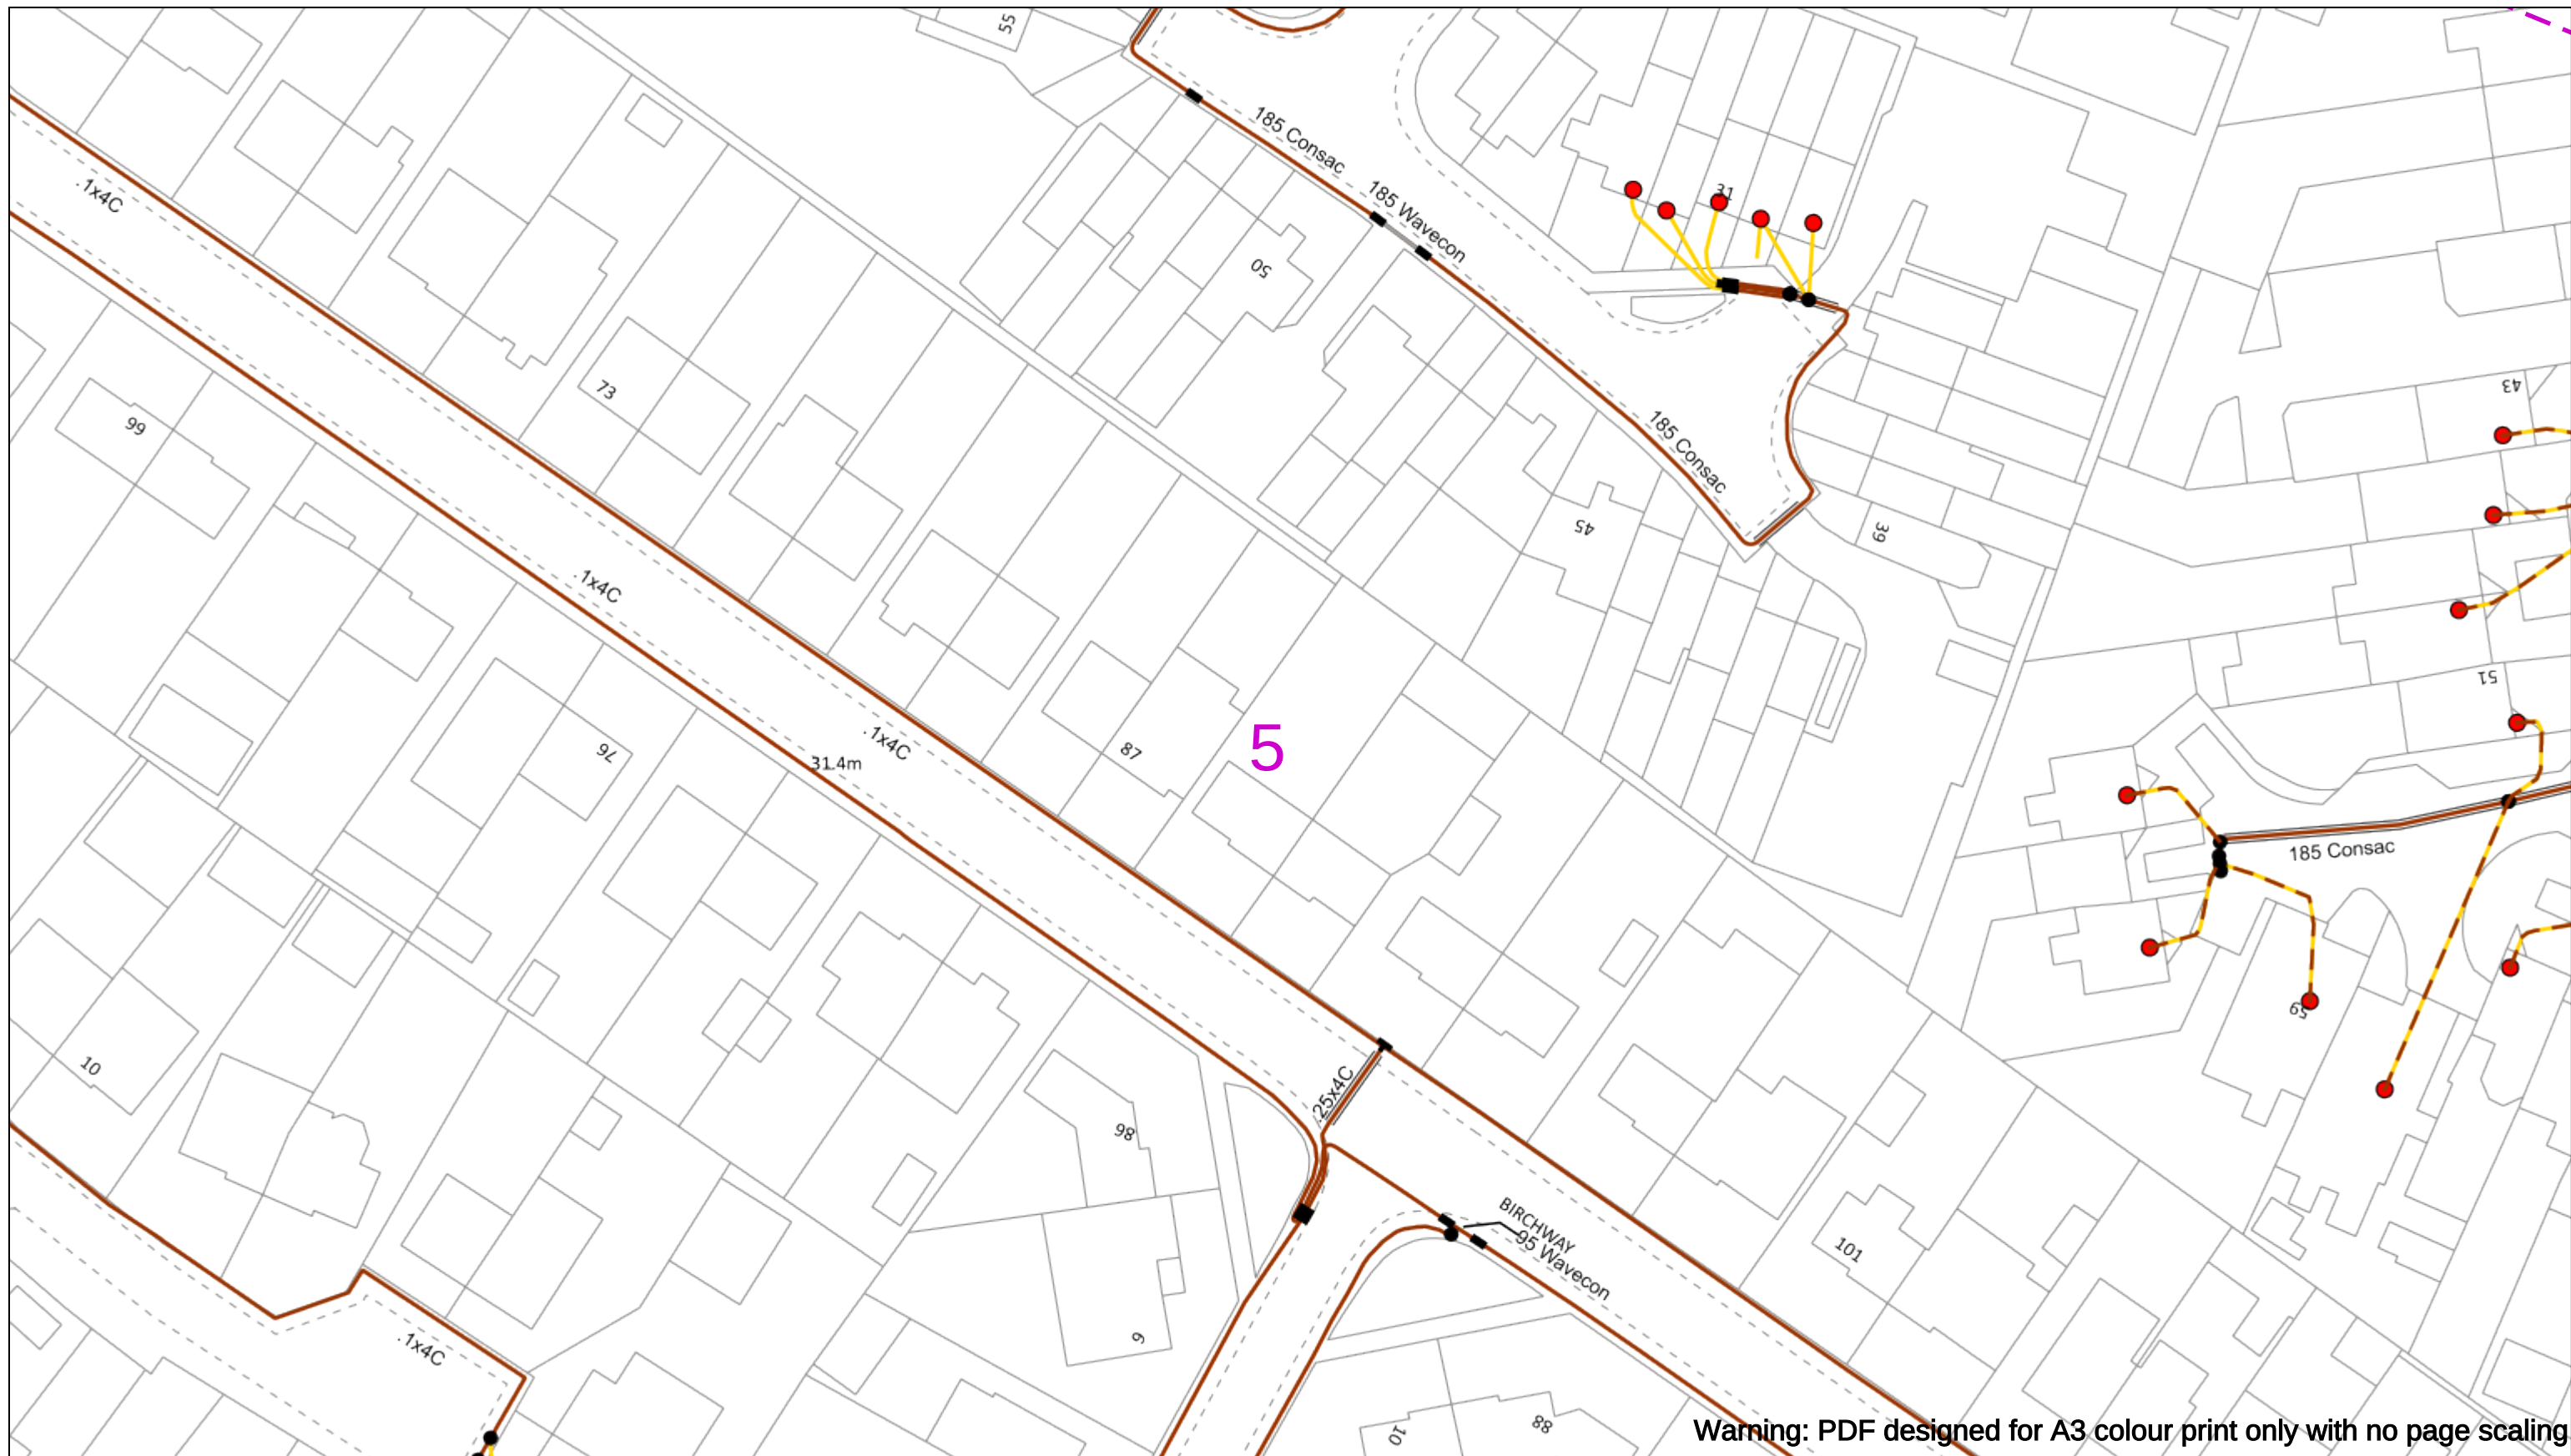

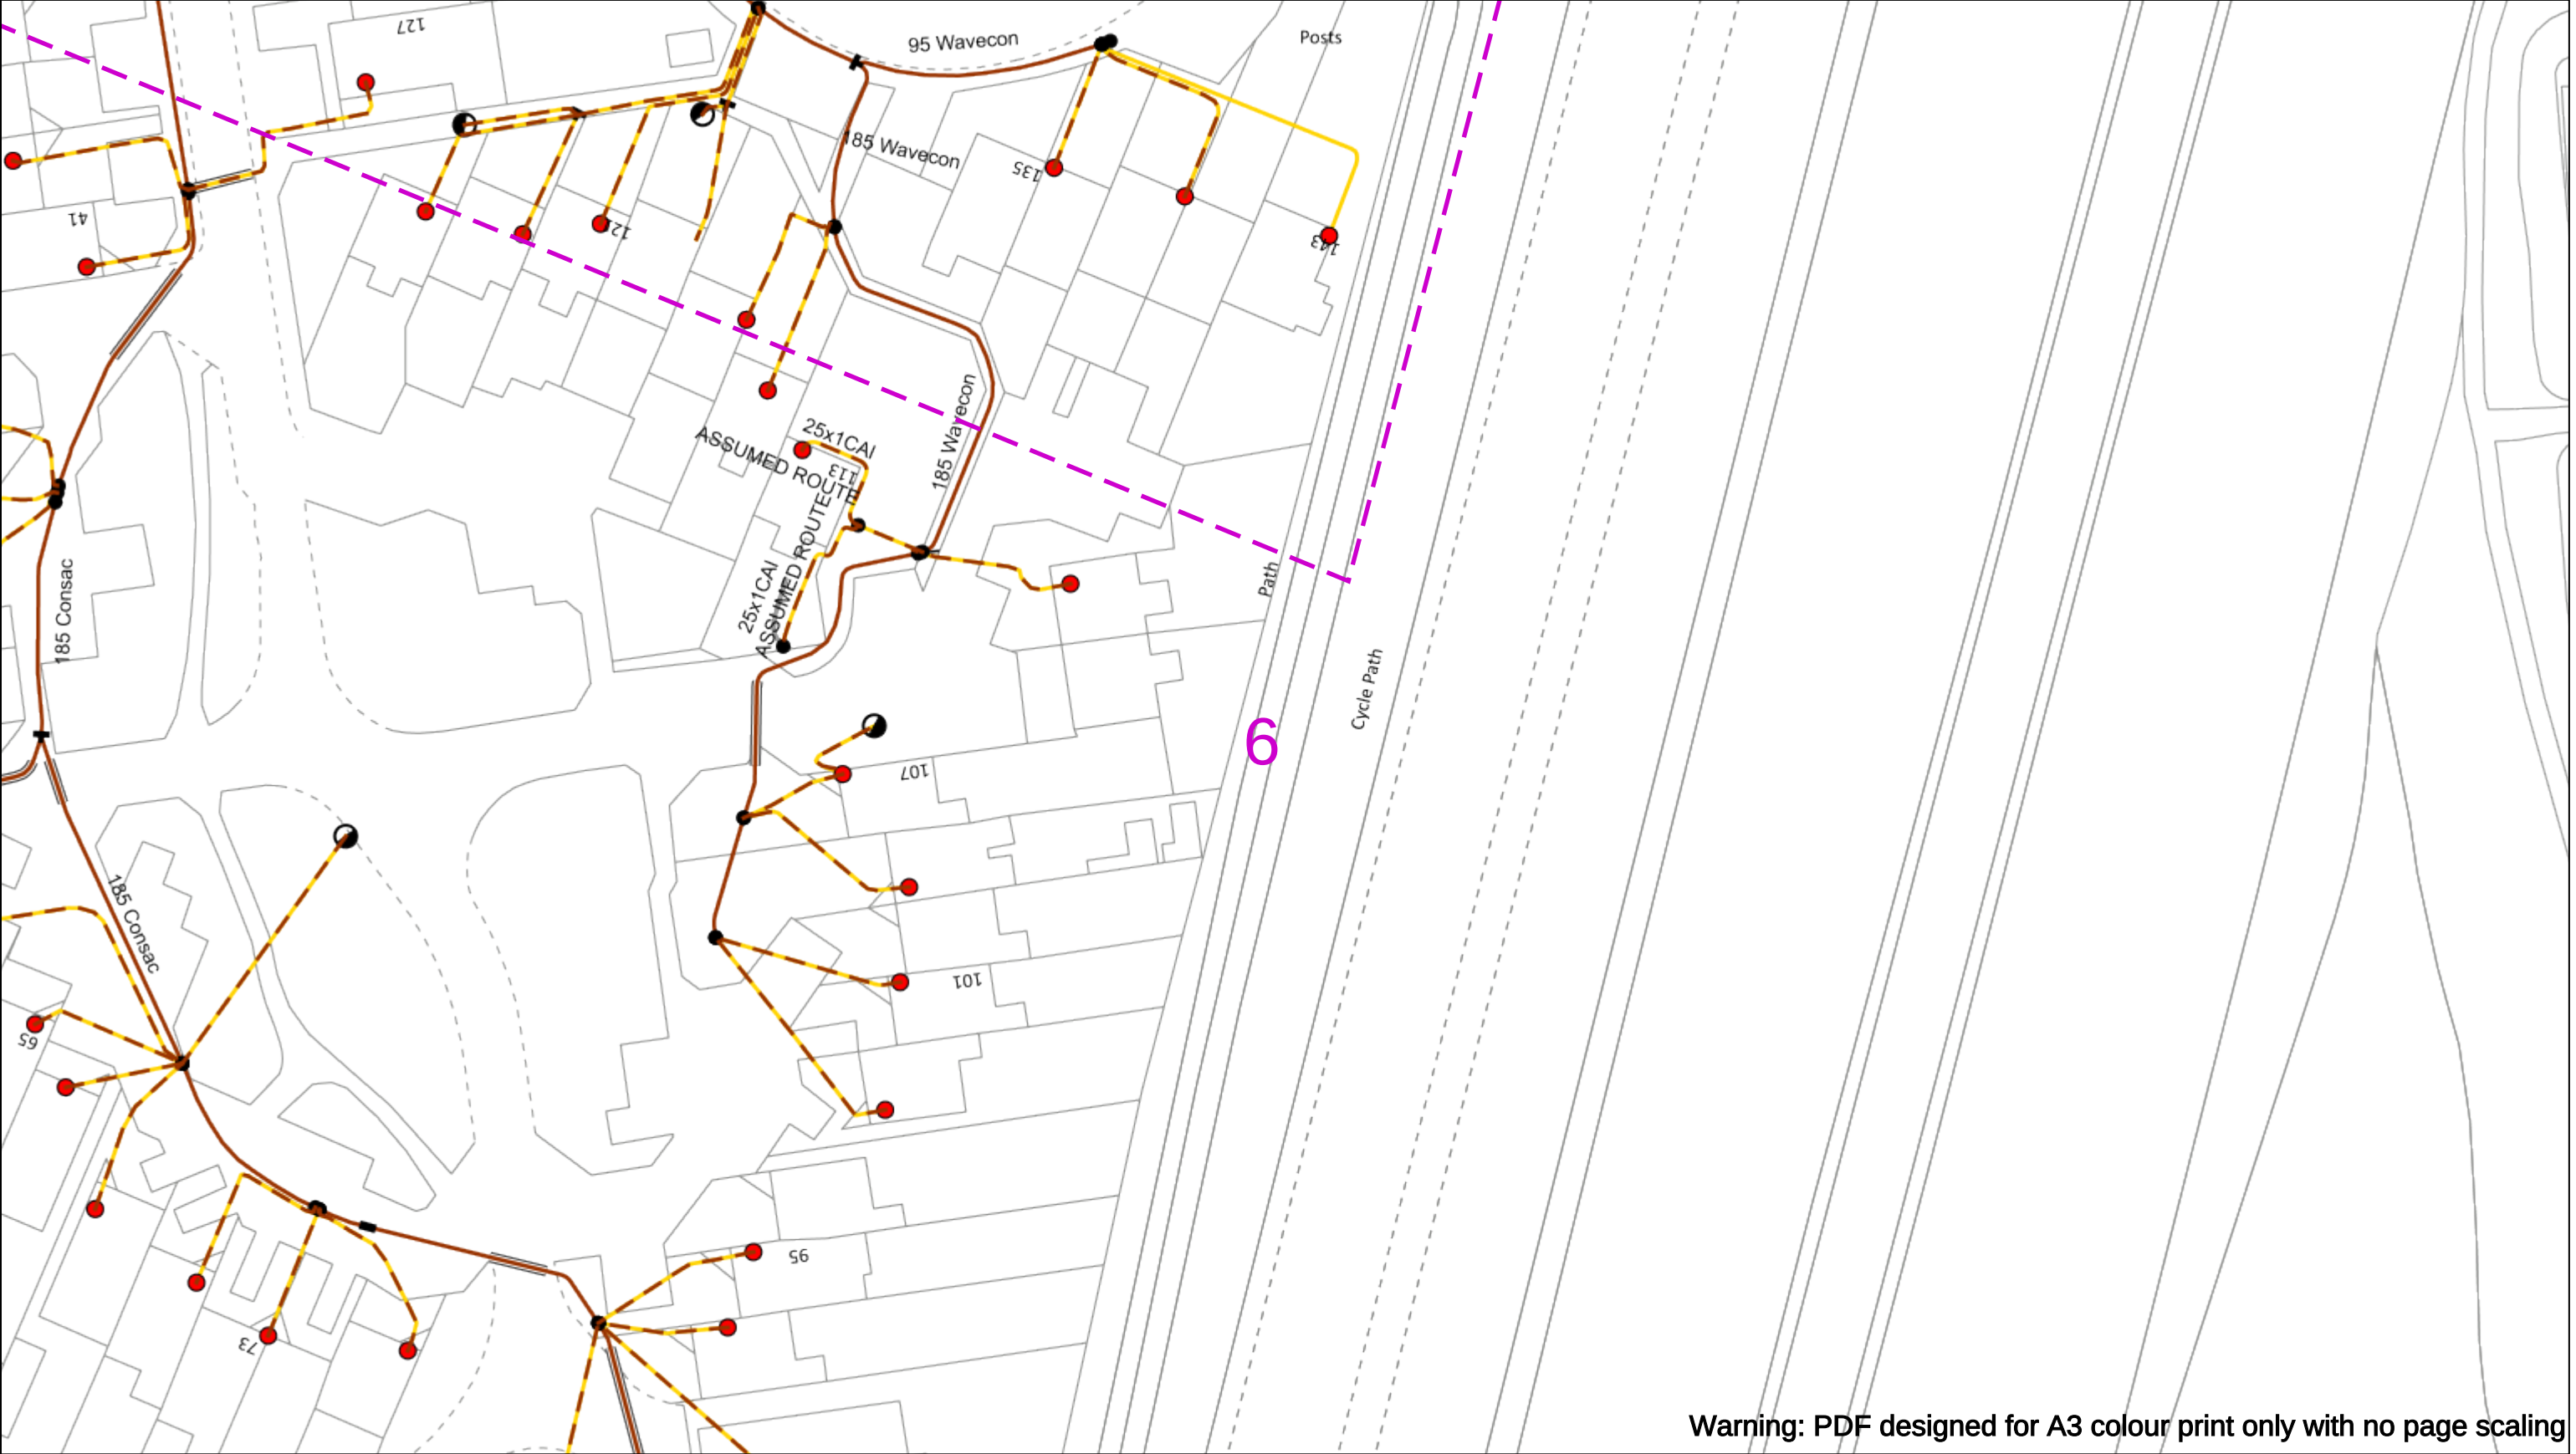

Warning: PDF designed for A3 colour print only with no page scaling

050m

Dig Sites

Area:

Line:

Date Requested: 15/09/2021

Job Reference: 23270156

Site Location: 510755 180225

Requested by:
Mr Brian McMaster
Your Scheme/Reference:
NOC/BGJHM742

WARNING

There may have been subsequent alteration to the surface levels. Trial holes must be undertaken to determine position and depths of cables. HS (G) 47 Booklet from the Health and Safety Executive – Avoiding Danger from Buried Cables – should be consulted before commencing excavation work.

WHEN WORKING IN THE VICINITY OF OVERHEAD LINES THE HEALTH AND SAFETY GUIDANCE NOTES GS6 SHOULD BE CONSULTED (AVAILABLE FROM THE HSE WEBSITE)

	Voltages (V)			
LV (Low Voltage) and Services	Up to 1,000V			
HV (High Voltage)	Over 1,000V to 11,000V			
EHV (Extra High Voltage)	22,000V to 132,000V			
Transmission	275,000V and 400,000V			

	NORMAL DEPTH TO THE TOP OF THE CABLE WHEN LAID			
	Services	LV	HV	EHV
Footpath/Unmade	0.45m	0.45m	0.6m	0.8m
Road Crossing	0.6m	0.6m	0.75m	0.9m
Agricultural	1m	1m	1m	1.1m

Legend

Service Cable

LV Mains

2 – 3.3kV

6.6kV

11kV

22kV

33kV

66kV

132kV

275kV

400kV

Fibre Optic

Pilot Cable

Distribution Structures (Electric)

Pole, Existing Location

Pole Structure, Existing Location - Single

Pole Structure, Existing Location - H

Duct Route

Cross Section Route

Scottish & Southern
Electricity Networks

Southern Electric Power Distribution plc
Registered Office: No.1 Forbury Place
43 Forbury Road Reading RG1 3JH
Registered In England & Wales No.04094290


If you're unsure & need to seek advice before commencing excavations please contact:
General Enquiries: 0800 048 3516

Subject to revision – Master held by SSEN Asset Data Team:
Asset.Data@sse.com
01256 337 294

Scale: 1:500 (When plotted at A3)

BASED UPON THE ORDNANCE SURVEY MAP WITH THE SANCTION OF THE CONTROLLER OF H.M STATIONERY OFFICE CROWN COPYRIGHT RESERVED.

This copy has been made by or with the authority of Scottish and Southern Energy Power Distribution Ltd. Pursuant to section 47 of the Copyright, Designs and Patents Act 1988 ('The Act'). Unless the Act provides a relevant exception to copyright the copy must not be copied without prior permission of the copyright owner. Plans generated by DigSAFE Pro™ software provided by LinesearchbeforeUdig.

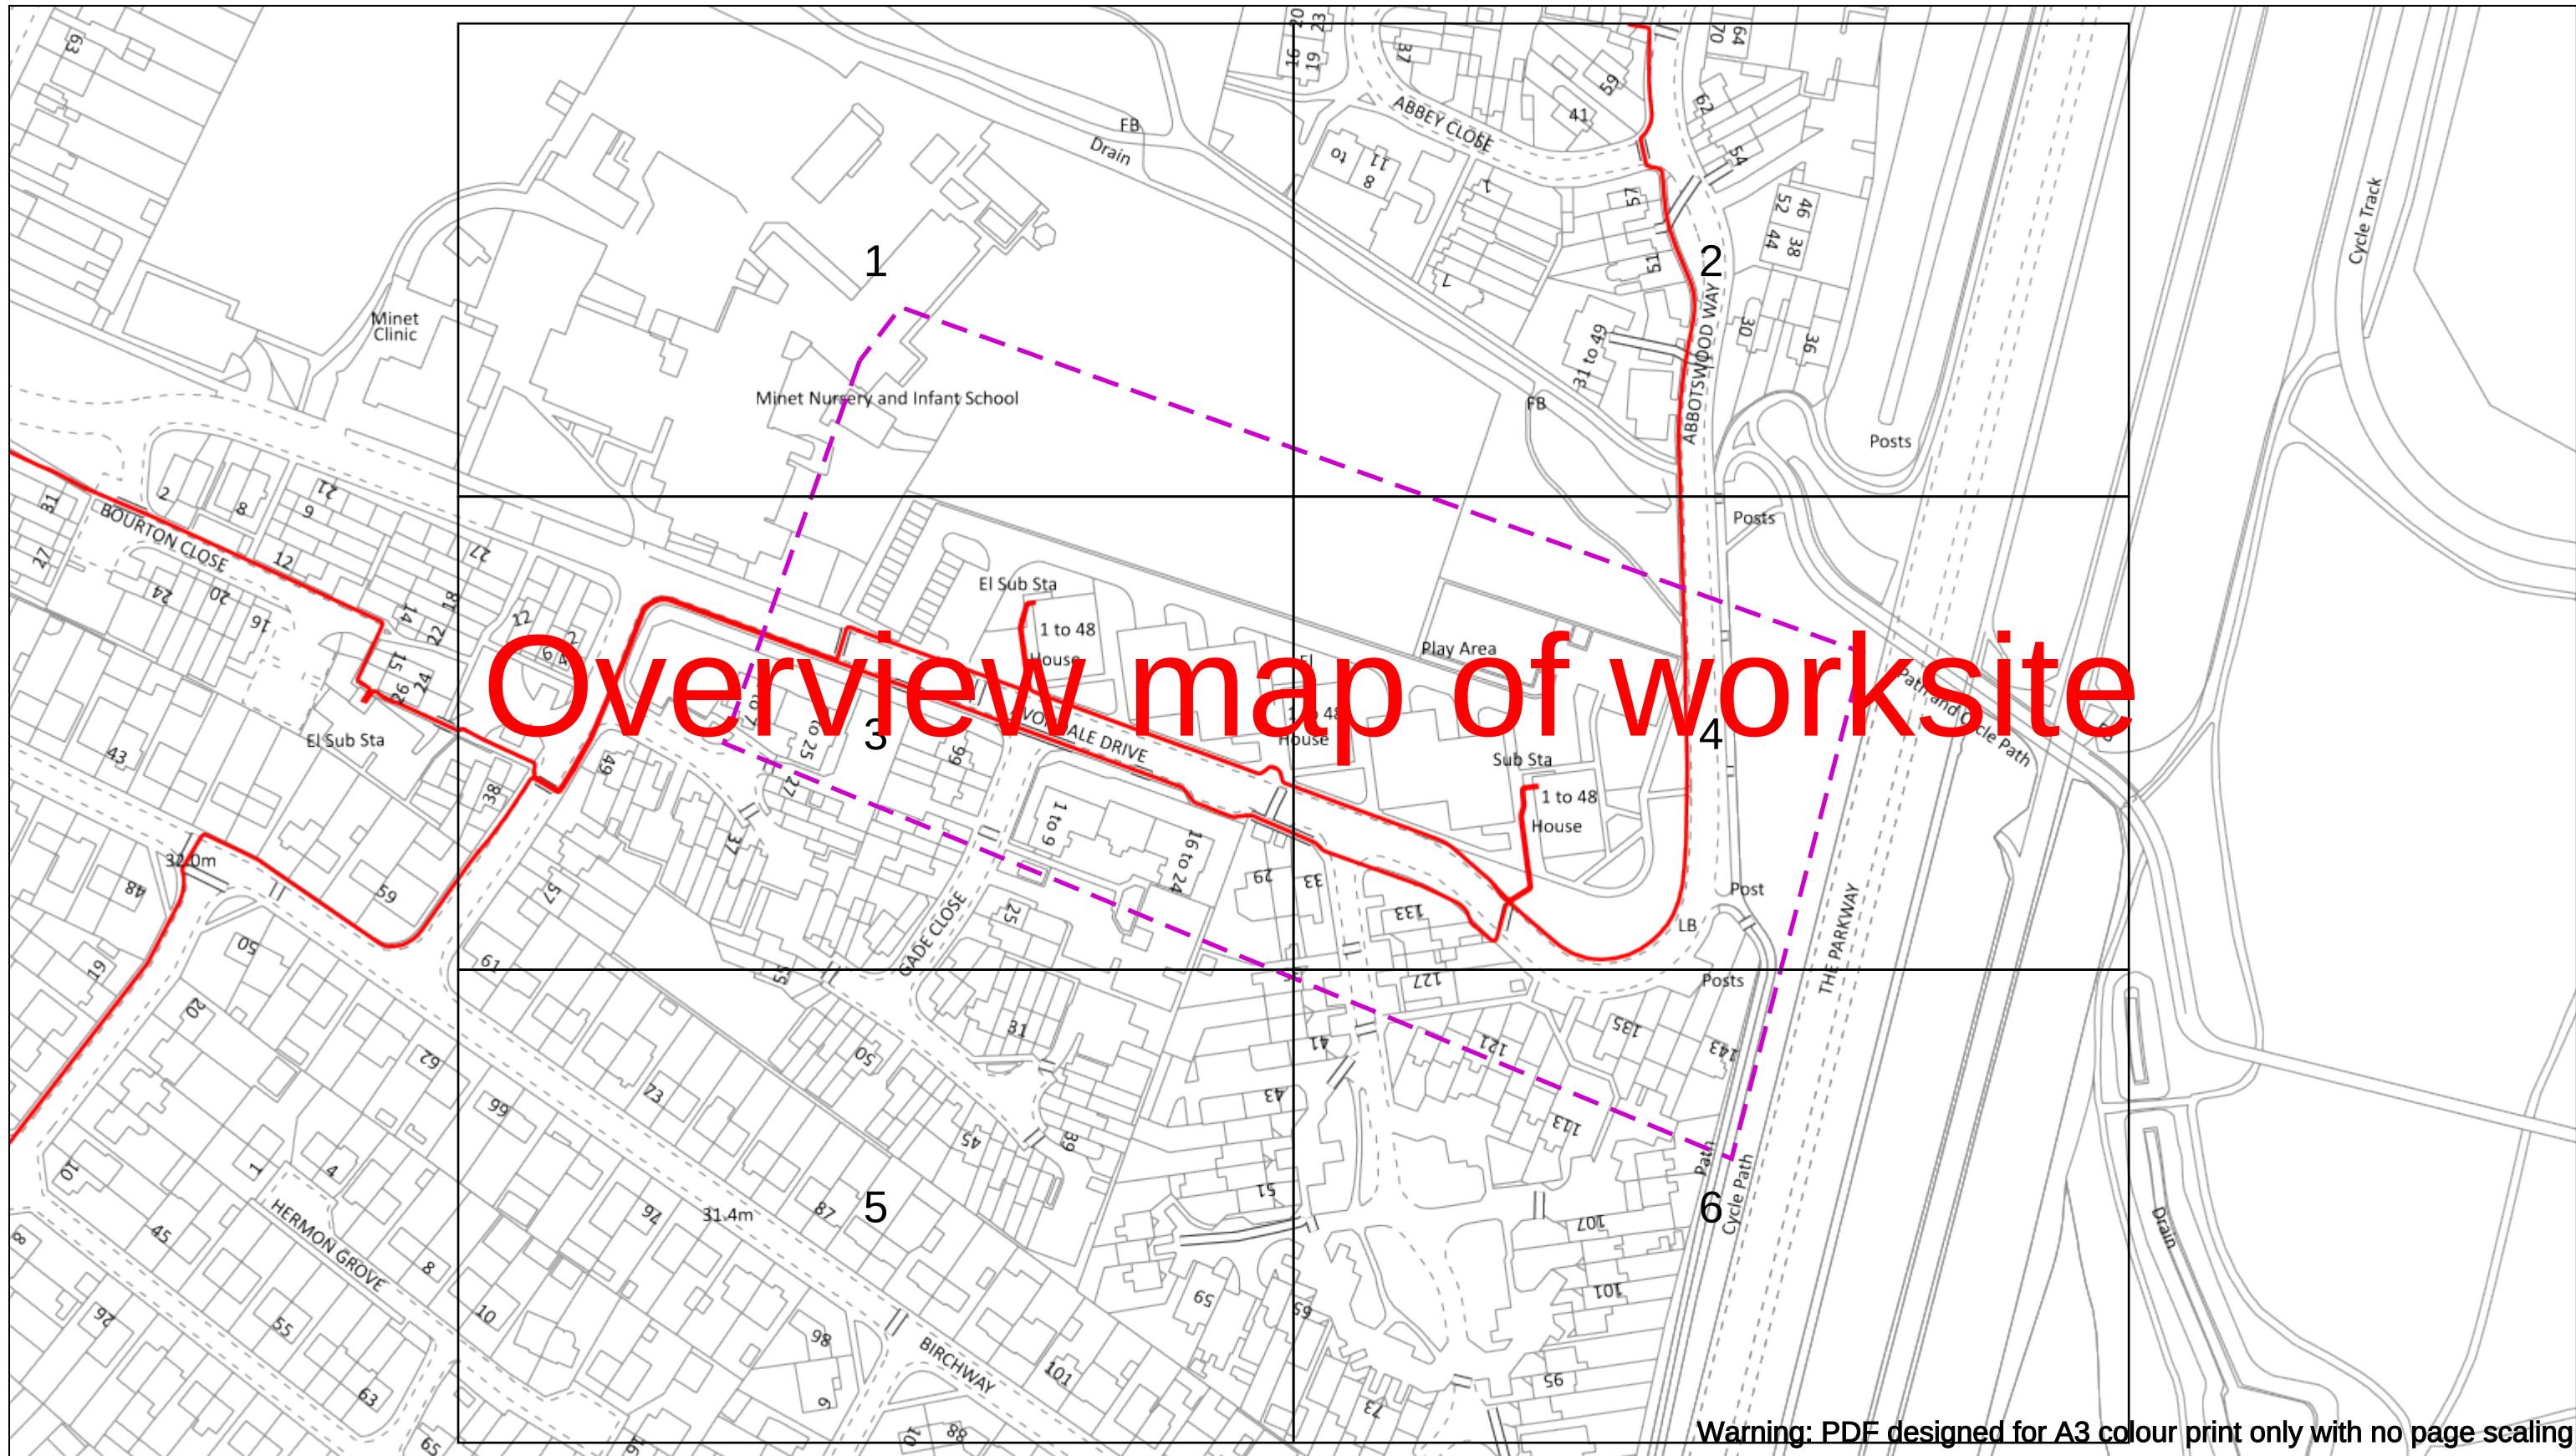

Warning: PDF designed for A3 colour print only with no page scaling

Dig Sites Area: Line:



Date Requested: 15/09/2021
Job Reference: 23270156
Site Location: 510755 180225
Requested by:
Mr Brian McMaster
Your Scheme/Reference:
NOC/BGJHM742

WARNING

There may have been subsequent alteration to the surface levels. Trial holes must be undertaken to determine position and depths of cables. HS (G) 47 Booklet from the Health and Safety Executive – Avoiding Danger from Buried Cables – should be consulted before commencing excavation work.

WHEN WORKING IN THE VICINITY OF OVERHEAD LINES THE HEALTH AND SAFETY GUIDANCE NOTES GS6 SHOULD BE CONSULTED (AVAILABLE FROM THE HSE WEBSITE)

Voltages (V)				
LV (Low Voltage) and Services		Up to 1,000V		
HV (High Voltage)		Over 1,000V to 11,000V		
EHV (Extra High Voltage)		22,000V to 132,000V		
Transmission		275,000V and 400,000V		
NORMAL DEPTH TO THE TOP OF THE CABLE WHEN LAID				
	Services	LV	HV	EHV
Footpath/Unmade	0.45m	0.45m	0.6m	0.6m
Road Crossing	0.6m	0.6m	0.75m	0.6m
Agricultural	1m	1m	1m	1m

	Services	LV	HV	E
Footpath/Unmade	0.45m	0.45m	0.6m	0
Road Crossing	0.6m	0.6m	0.75m	0
Agricultural	1m	1m	1m	1

Legend

- Service Cable
- LV Mains
- 2 – 3.3kV
- 6.6kV
- 11kV
- 22kV
- 33kV
- 66kV
- 132kV
- 275kV
- 400kV
- Fibre Optic
- Pilot Cable

Distribution Structures [Electric]

- Pole, Existing Location
- Pole Structure, Existing Location - Single
- Pole Structure, Existing Location - H
- Duct Route
- Cross Section Route

Southern Electric Power Distribution plc
Registered Office: No.1 Forbury Place
43 Forbury Road Reading RG1 3JH
Registered In England & Wales No.04094290


If you're unsure & need to seek advice before commencing excavations please contact:
General Enquiries: 0800 048 3516

Subject to revision – Master held by SSEN Asset Data Team:
Asset.Data@sse.com
 01256 337 294

Scale: 1:1538 (When plotted at A3)

BASED UPON THE ORDNANCE SURVEY MAP WITH THE SANCTION OF THE CONTROLLER OF H.M STATIONERY OFFICE CROWN COPYRIGHT RESERVED.

This copy has been made by or with the authority of Scottish and Southern Energy Power Distribution Ltd. Pursuant to section 47 of the Copyright, Designs and Patents Act 1988 ("The Act"). Unless the Act provides a relevant exception to copyright the copy must not be copied without prior permission of the copyright owner. Plans generated by DigSAFE Pro™ software provided by LinesearchbeforeUdig.

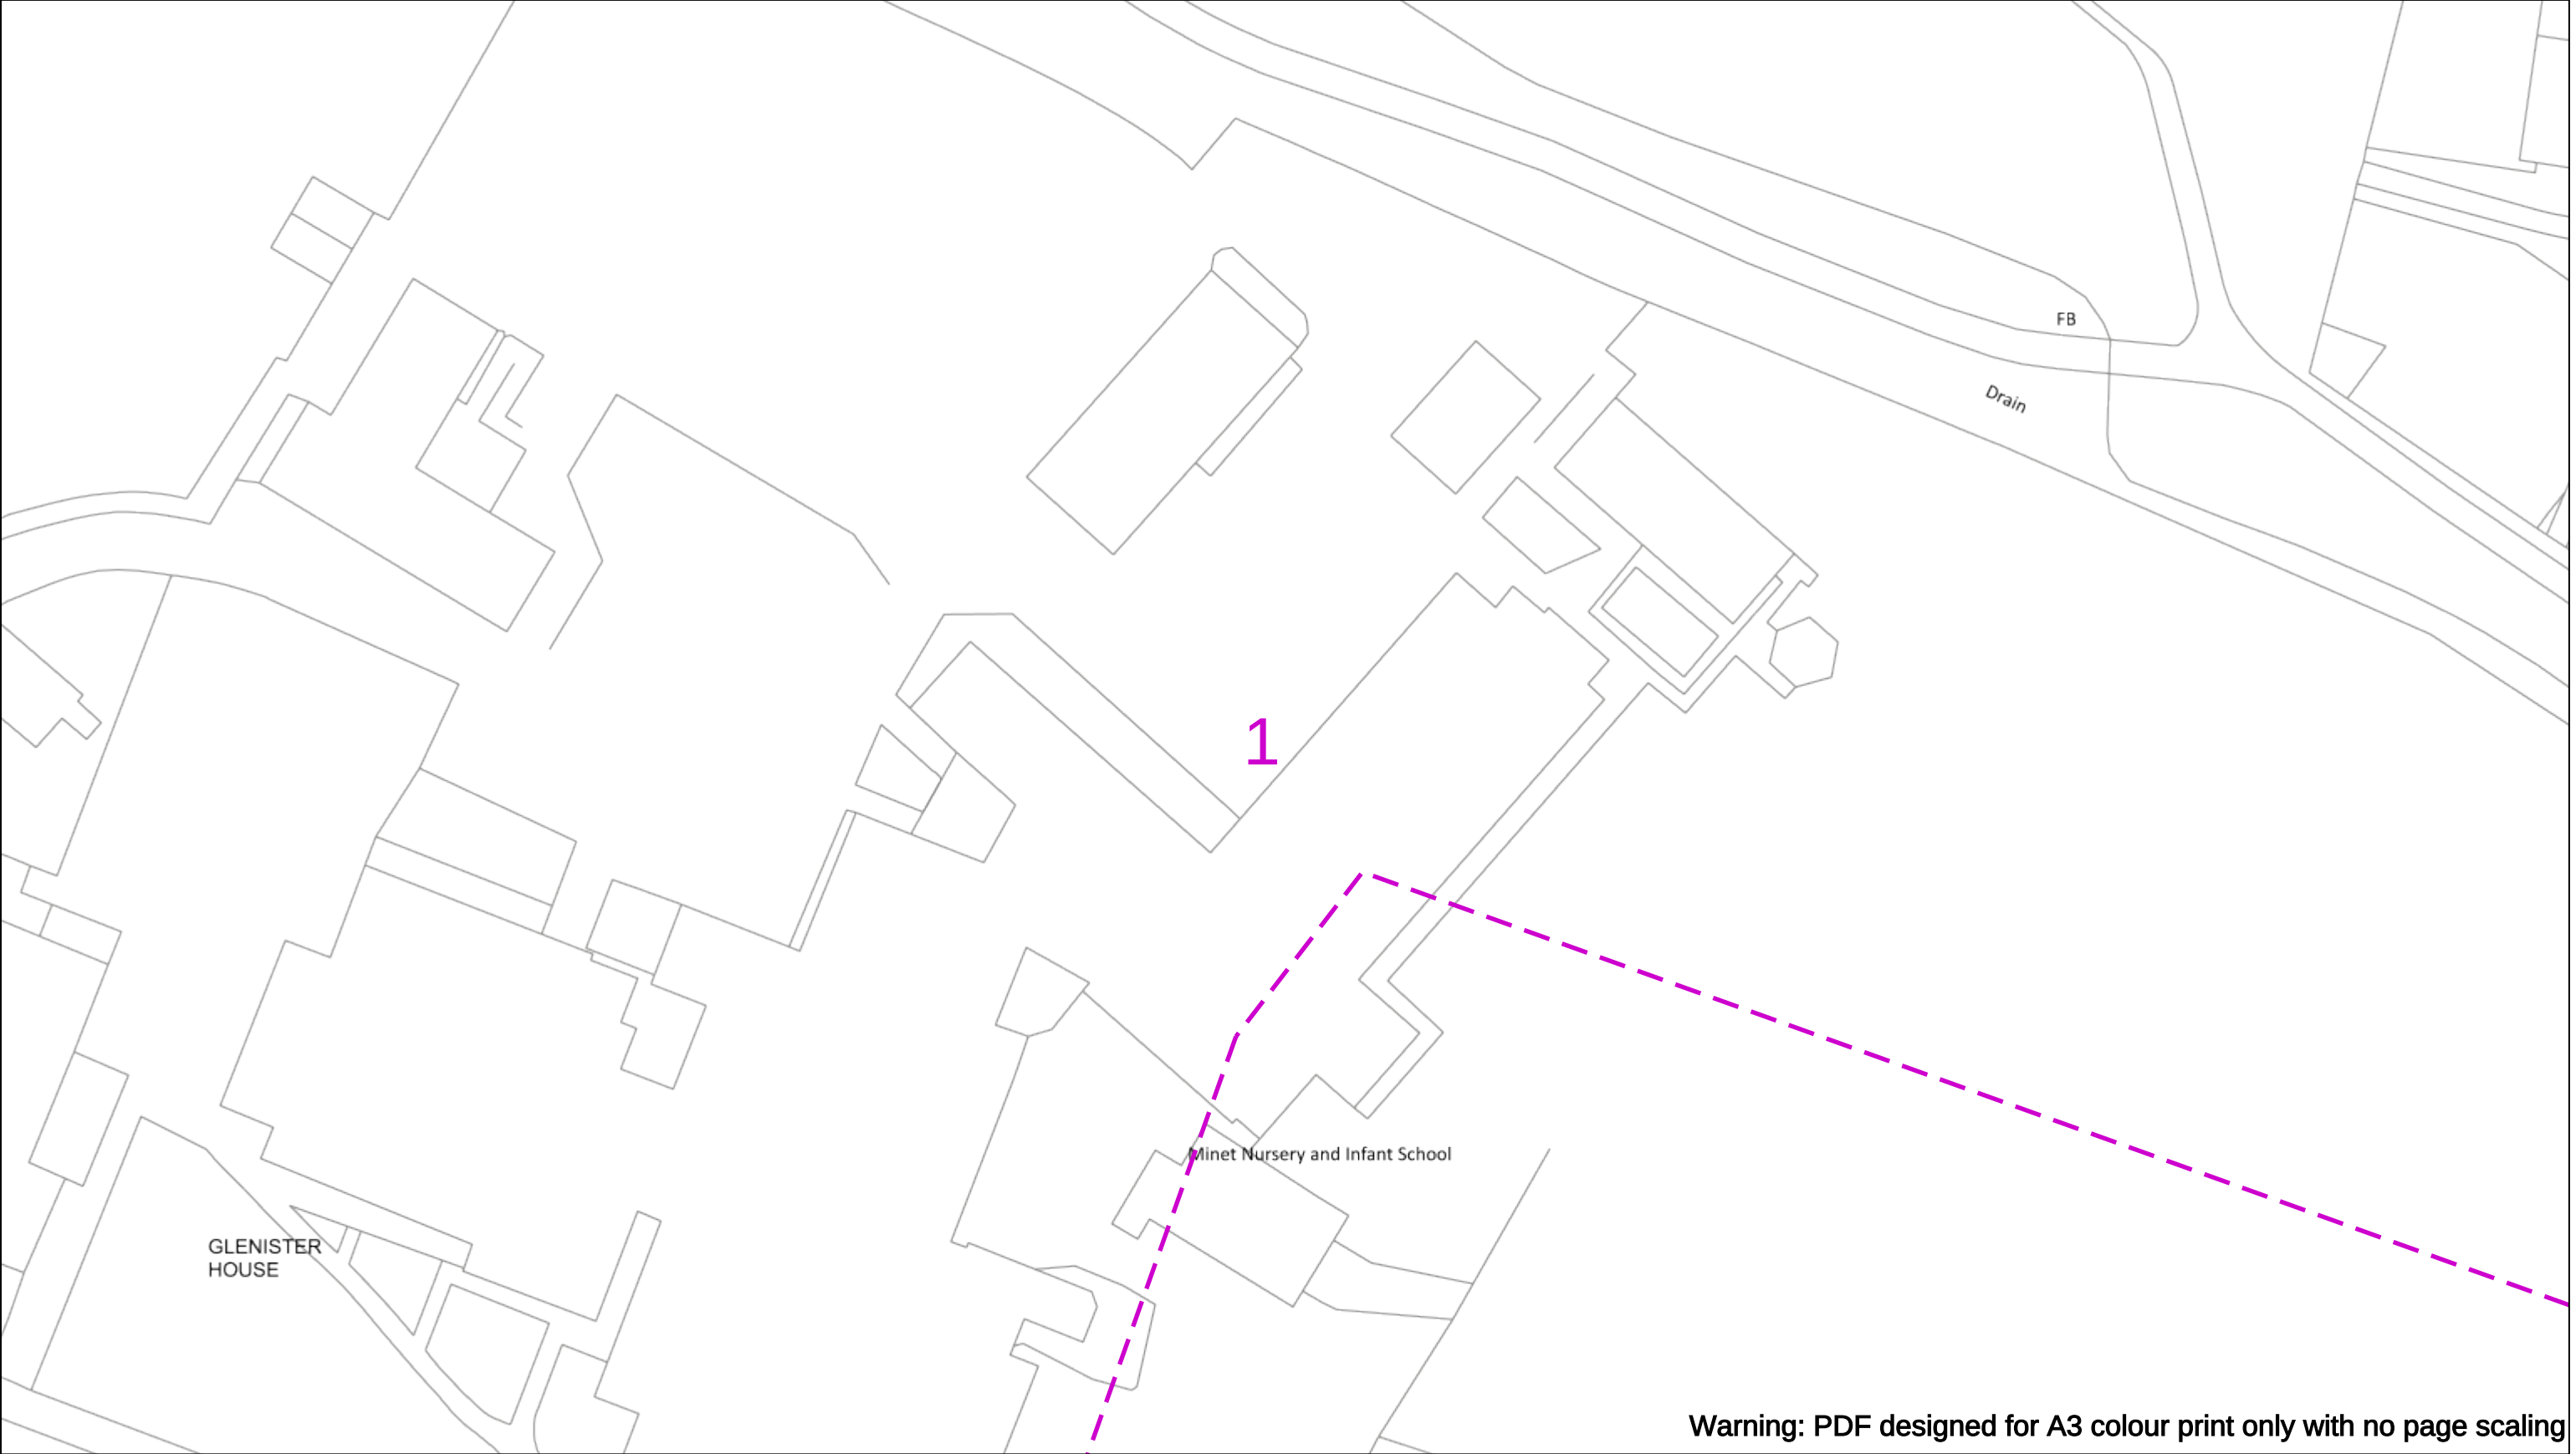

Warning: PDF designed for A3 colour print only with no page scaling

050m

Dig Sites

Area:

Line:

Date Requested: 15/09/2021

Job Reference: 23270156

Site Location: 510755 180225

Requested by:
Mr Brian McMaster

Your Scheme/Reference:
NOC/BGJHM742

WARNING

There may have been subsequent alteration to the surface levels. Trial holes must be undertaken to determine position and depths of cables. HS (G) 47 Booklet from the Health and Safety Executive – Avoiding Danger from Buried Cables – should be consulted before commencing excavation work.

WHEN WORKING IN THE VICINITY OF OVERHEAD LINES THE HEALTH AND SAFETY GUIDANCE NOTES GS6 SHOULD BE CONSULTED (AVAILABLE FROM THE HSE WEBSITE)

Voltages (V)				
LV (Low Voltage) and Services	Up to 1,000V			
HV (High Voltage)	Over 1,000V to 11,000V			
EHV (Extra High Voltage)	22,000V to 132,000V			
Transmission	275,000V and 400,000V			

NORMAL DEPTH TO THE TOP OF THE CABLE WHEN LAID				
	Services	LV	HV	EHV
Footpath/Unmade	0.45m	0.45m	0.6m	0.8m
Road Crossing	0.6m	0.6m	0.75m	0.9m
Agricultural	1m	1m	1m	1.1m

Legend

Service Cable

LV Mains

2 – 3.3kV

6.6kV

11kV

22kV

33kV

66kV

132kV

275kV

400kV

Fibre Optic

Pilot Cable

Distribution Structures (Electric)

Pole, Existing Location

Pole Structure, Existing Location - Single

Pole Structure, Existing Location - H

Duct Route

Cross Section Route

N

E

S

W

Scottish & Southern

Electricity Networks

Southern Electric Power Distribution plc

Registered Office: No.1 Forbury Place

43 Forbury Road Reading RG1 3JH

Registered In England & Wales No.04094290

If you're unsure & need to seek advice before commencing excavations please contact:

General Enquiries: 0800 048 3516

Subject to revision – Master held by SSEN Asset Data Team:


Asset.Data@sse.com

01256 337 294

Scale: 1:500 (When plotted at A3)

BASED UPON THE ORDNANCE SURVEY MAP WITH THE SANCTION OF THE CONTROLLER OF H.M STATIONERY OFFICE CROWN COPYRIGHT RESERVED.

This copy has been made by or with the authority of Scottish and Southern Energy Power Distribution Ltd. Pursuant to section 47 of the Copyright, Designs and Patents Act 1988 ('The Act'). Unless the Act provides a relevant exception to copyright the copy must not be copied without prior permission of the copyright owner. Plans generated by DigSAFE Pro™ software provided by LinesearchbeforeUdig.

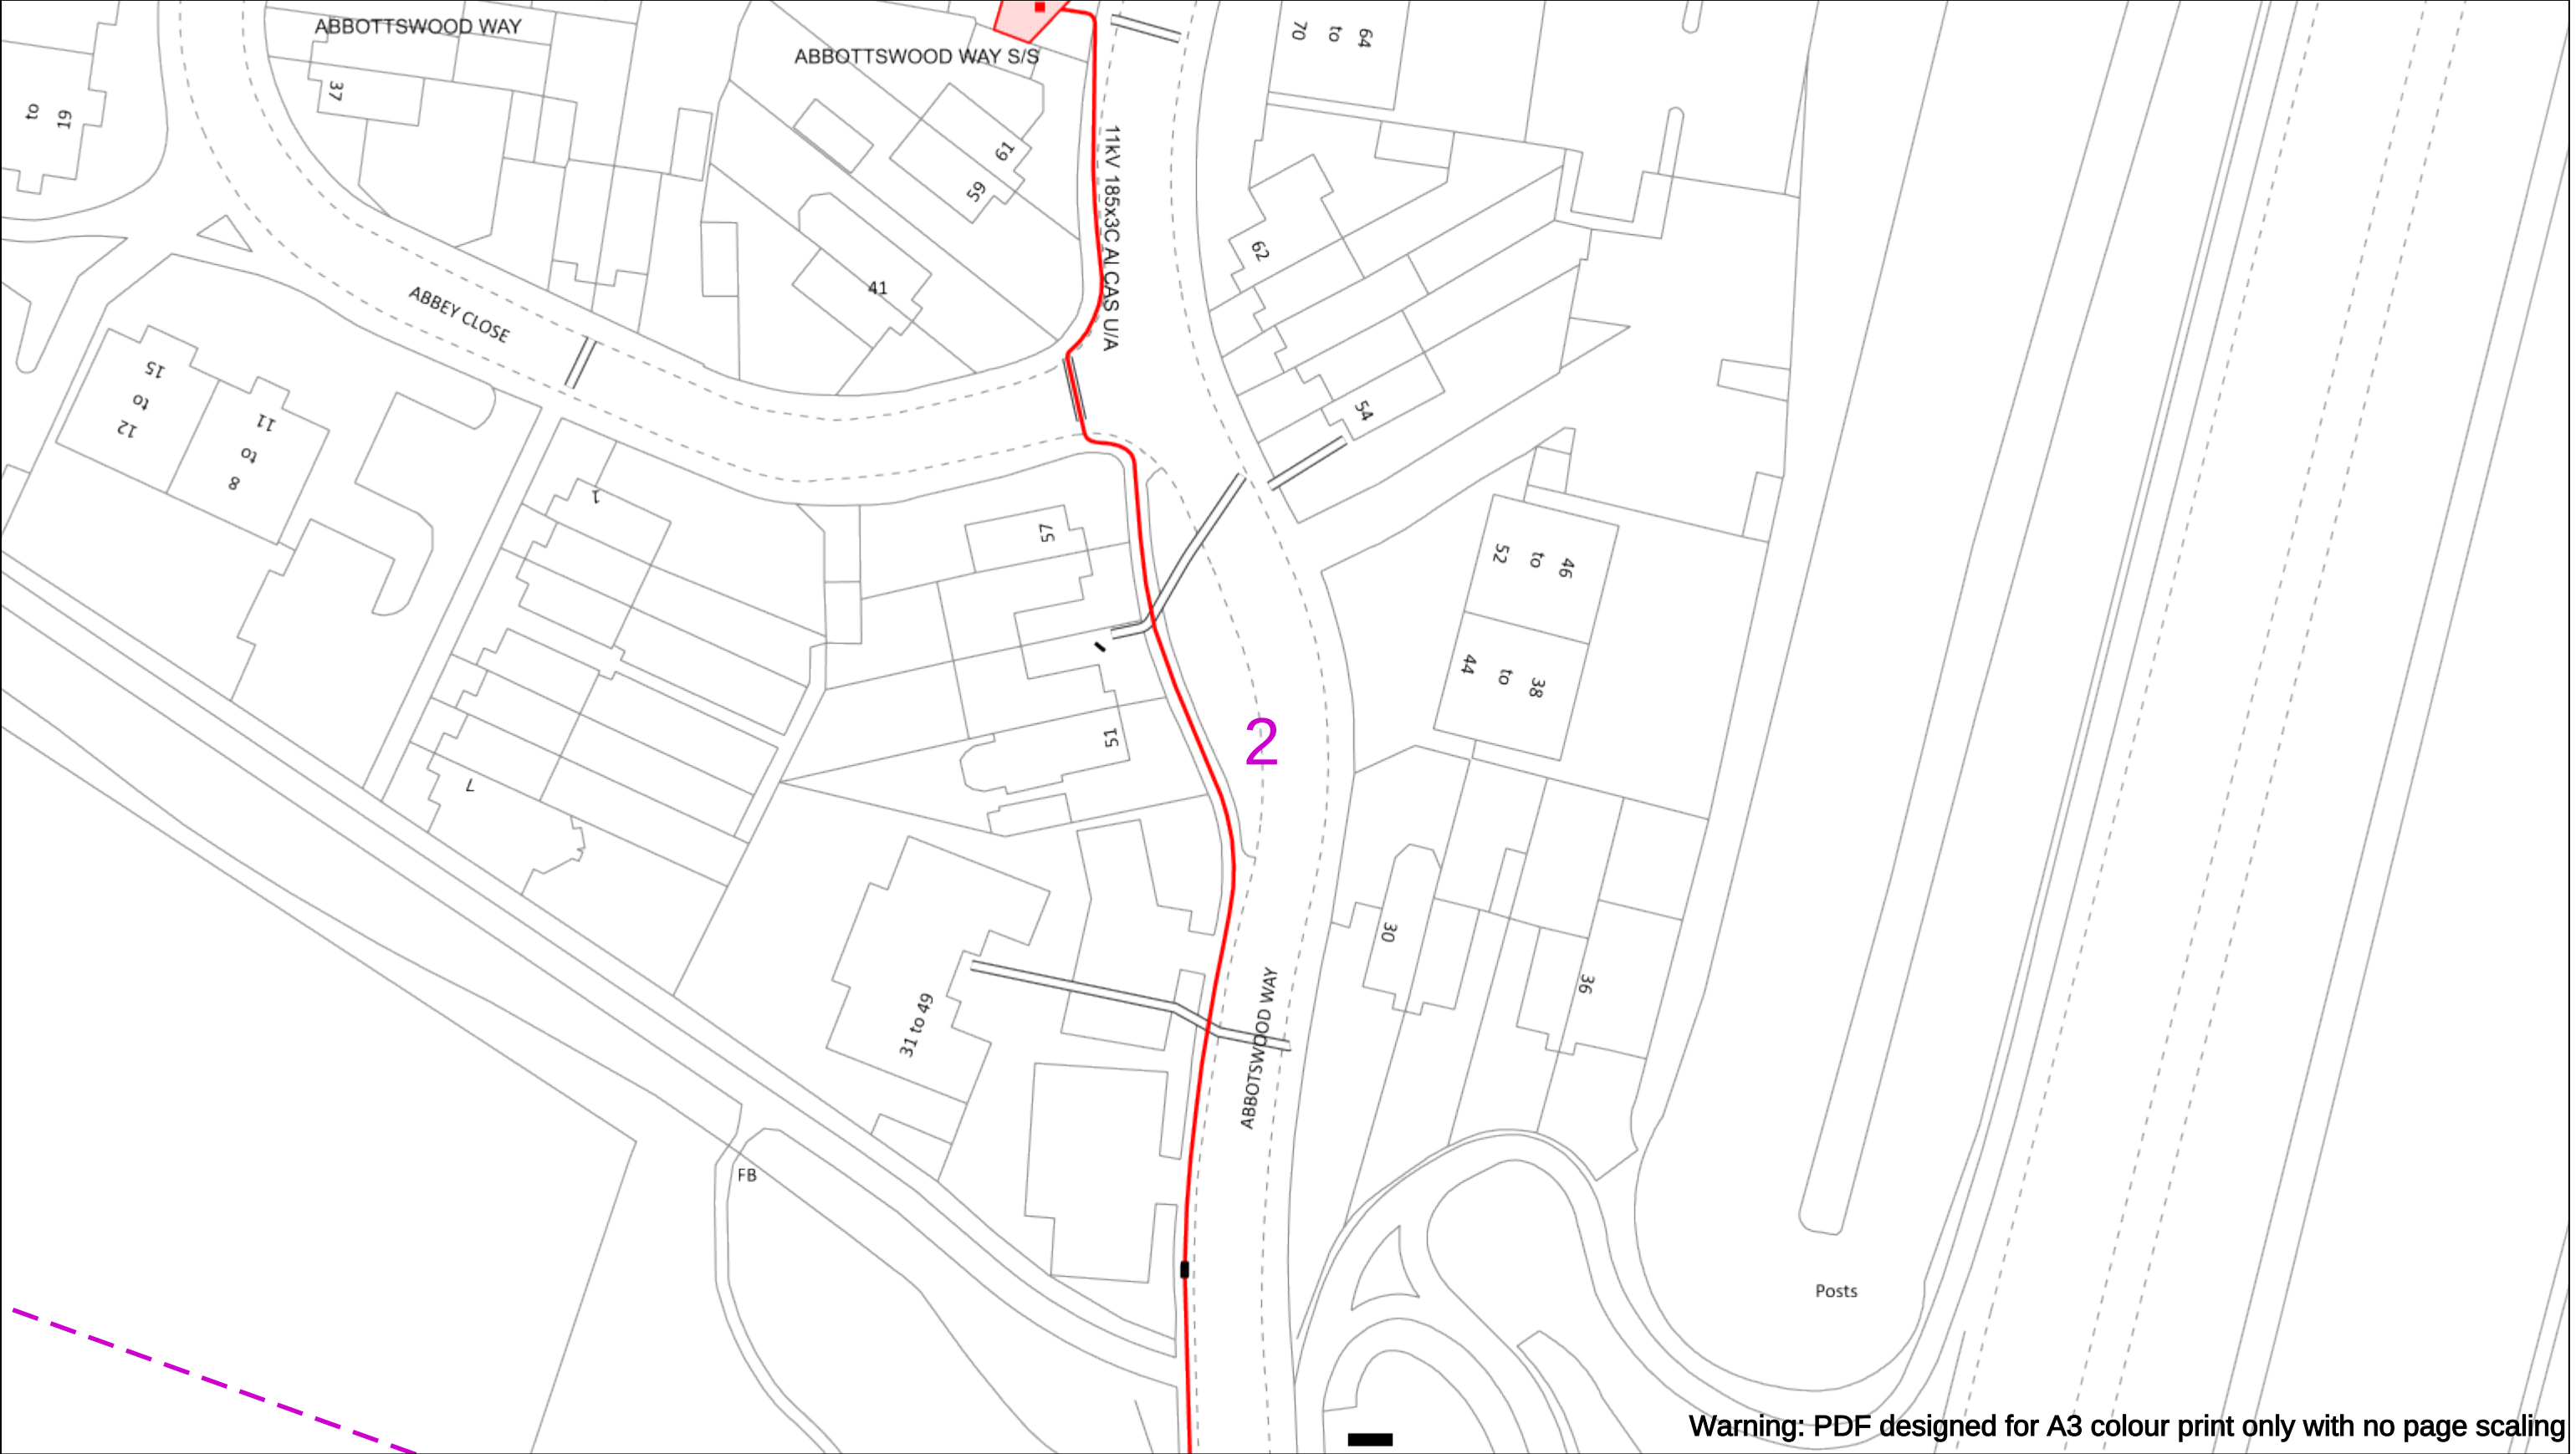

050m

Dig Sites

Area: ----

Line: ----

Date Requested: 15/09/2021

Job Reference: 23270156

Site Location: 510755 180225

Requested by:
Mr Brian McMaster

Your Scheme/Reference:
NOC/BGJHM742

WARNING

There may have been subsequent alteration to the surface levels. Trial holes must be undertaken to determine position and depths of cables. HS (G) 47 Booklet from the Health and Safety Executive – Avoiding Danger from Buried Cables – should be consulted before commencing excavation work.

WHEN WORKING IN THE VICINITY OF OVERHEAD LINES THE HEALTH AND SAFETY GUIDANCE NOTES GS6 SHOULD BE CONSULTED (AVAILABLE FROM THE HSE WEBSITE)

Voltages (V)				
LV (Low Voltage) and Services	Up to 1,000V			
HV (High Voltage)	Over 1,000V to 11,000V			
EHV (Extra High Voltage)	22,000V to 132,000V			
Transmission	275,000V and 400,000V			

NORMAL DEPTH TO THE TOP OF THE CABLE WHEN LAID				
	Services	LV	HV	EHV
Footpath/Unmade	0.45m	0.45m	0.6m	0.8m
Road Crossing	0.6m	0.6m	0.75m	0.9m
Agricultural	1m	1m	1m	1.1m

Legend

Service Cable

LV Mains

2 – 3.3kV

6.6kV

11kV

22kV

33kV

66kV

132kV

275kV

400kV

Fibre Optic

Pilot Cable

Distribution Structures (Electric)

Pole, Existing Location

Pole Structure, Existing Location - Single

Pole Structure, Existing Location - H

Duct Route

Cross Section Route

N

E

S

W

Scottish & Southern
Electricity Networks

Southern Electric Power Distribution plc


Registered Office: No.1 Forbury Place
43 Forbury Road Reading RG1 3JH
Registered In England & Wales No.04094290

If you're unsure & need to seek advice before commencing excavations please contact:
General Enquiries: 0800 048 3516

Subject to revision – Master held by SSEN Asset Data Team:
Asset.Data@sse.com
01256 337 294

Scale: 1:500 (When plotted at A3)

BASED UPON THE ORDNANCE SURVEY MAP WITH THE SANCTION OF THE CONTROLLER OF H.M STATIONERY OFFICE CROWN COPYRIGHT RESERVED.
This copy has been made by or with the authority of Scottish and Southern Energy Power Distribution Ltd. Pursuant to section 47 of the Copyright, Designs and Patents Act 1988 ('The Act'). Unless the Act provides a relevant exception to copyright the copy must not be copied without prior permission of the copyright owner. Plans generated by DigSAFE Pro™ software provided by LinesearchbeforeUdig.

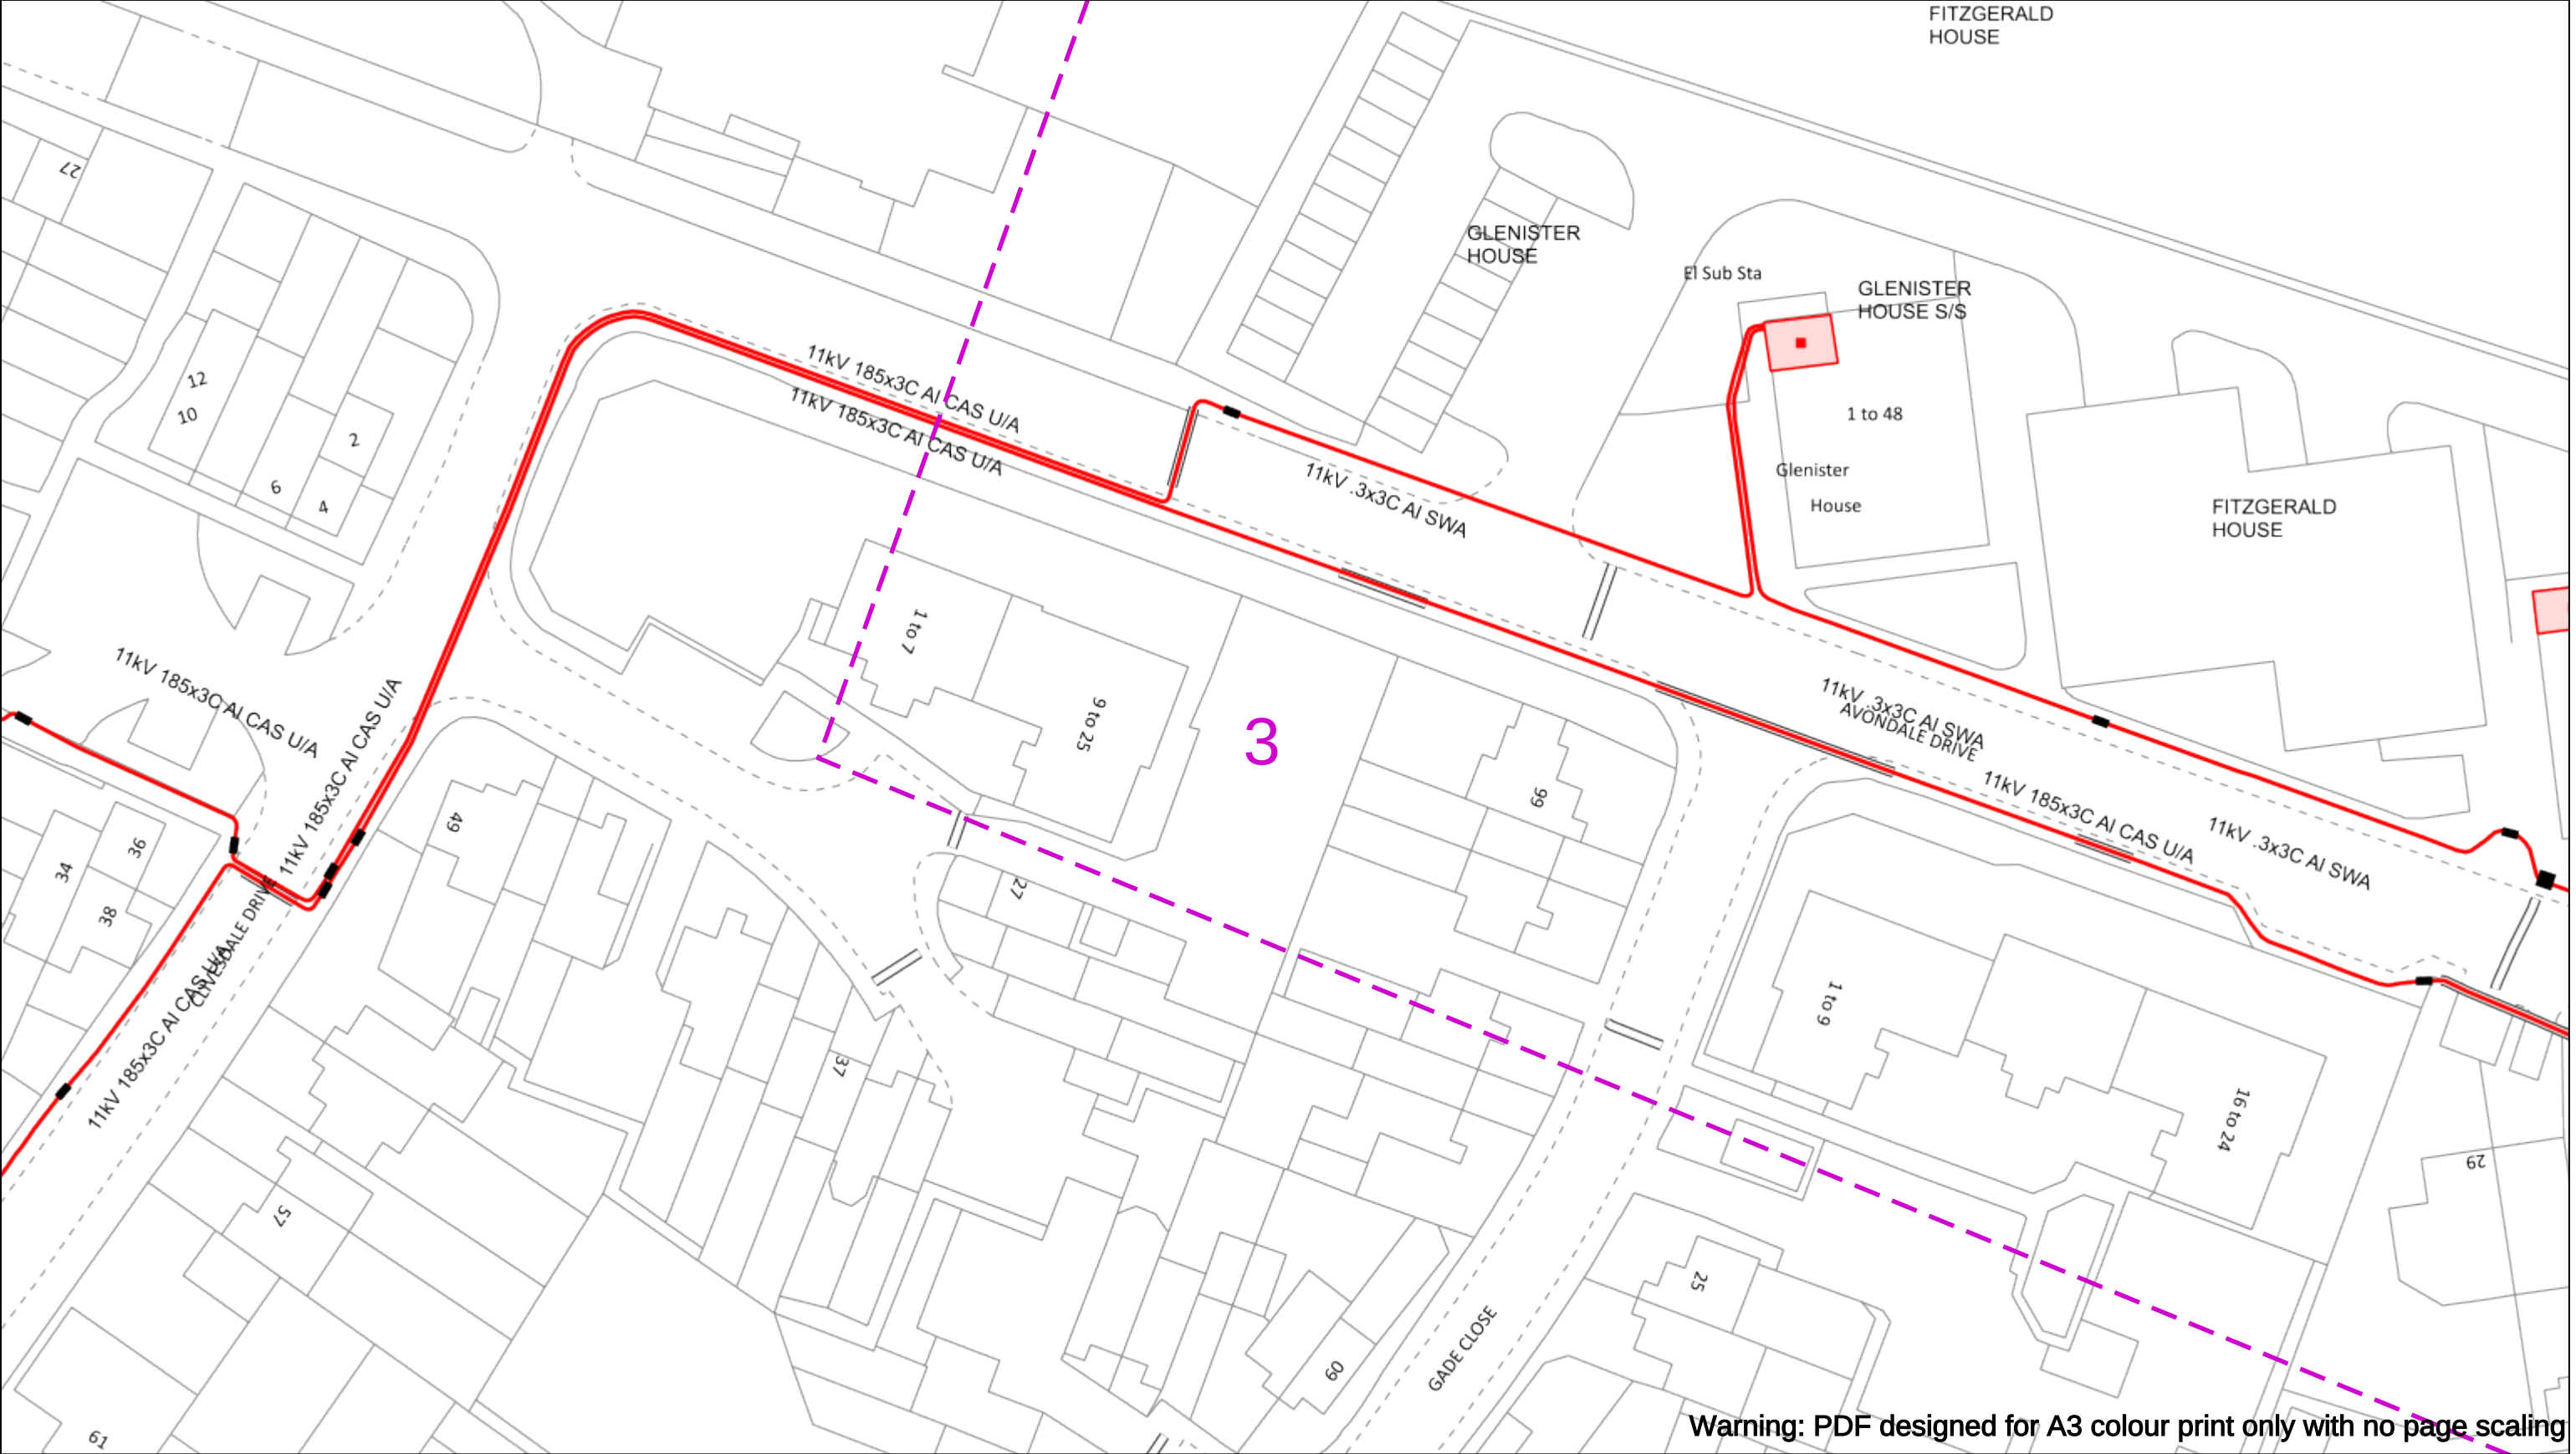

Warning: PDF designed for A3 colour print only with no page scaling

050m

Dig Sites

Area:

Line:

Date Requested: 15/09/2021

Job Reference: 23270156

Site Location: 510755 180225

Requested by:

Mr Brian McMaster

Your Scheme/Reference:

NOC/BGJHM742

WARNING

There may have been subsequent alteration to the surface levels. Trial holes must be undertaken to determine position and depths of cables. HS (G) 47 Booklet from the Health and Safety Executive – Avoiding Danger from Buried Cables – should be consulted before commencing excavation work.

WHEN WORKING IN THE VICINITY OF OVERHEAD LINES THE HEALTH AND SAFETY GUIDANCE NOTES GS6 SHOULD BE CONSULTED (AVAILABLE FROM THE HSE WEBSITE)

Voltages (V)				
LV (Low Voltage) and Services	Up to 1,000V			
HV (High Voltage)	Over 1,000V to 11,000V			
EHV (Extra High Voltage)	22,000V to 132,000V			
Transmission	275,000V and 400,000V			

NORMAL DEPTH TO THE TOP OF THE CABLE WHEN LAID				
	Services	LV	HV	EHV
Footpath/Unmade	0.45m	0.45m	0.6m	0.8m
Road Crossing	0.6m	0.6m	0.75m	0.9m
Agricultural	1m	1m	1m	1.1m

Legend

Service Cable

LV Mains

2 – 3.3kV

6.6kV

11kV

22kV

33kV

66kV

132kV

275kV

400kV

Fibre Optic

Pilot Cable

Distribution Structures (Electric)

Pole, Existing Location

Pole Structure, Existing Location - Single

Pole Structure, Existing Location - H

Duct Route

Cross Section Route

Scottish & Southern

Electricity Networks

Southern Electric Power Distribution plc

Registered Office: No.1 Forbury Place

43 Forbury Road Reading RG1 3JH

Registered In England & Wales No.04094290

If you're unsure & need to seek advice before commencing excavations please contact:

General Enquiries: 0800 048 3516

Subject to revision – Master held by SSEN Asset Data Team:

Asset.Data@sse.com

01256 337 294

Scale: 1:500 (When plotted at A3)

BASED UPON THE ORDNANCE SURVEY MAP WITH THE SANCTION OF THE CONTROLLER OF H.M STATIONERY OFFICE CROWN COPYRIGHT RESERVED.


This copy has been made by or with the authority of Scottish and Southern Energy Power Distribution Ltd. Pursuant to section 47 of the Copyright, Designs and Patents Act 1988 ('The Act'). Unless the Act provides a relevant exception to copyright the copy must not be copied without prior permission of the copyright owner. Plans generated by DigSAFE Pro™ software provided by LinesearchbeforeUdig.



Dig Sites Area: Line:



This copy has been made by or with the authority of Scottish and Southern Energy Power Distribution Ltd. Pursuant to section 47 of the Copyright, Designs and Patents Act 1988 ('The Act'). Unless the Act provides a relevant exception to copyright the copy must not be copied without prior permission of the copyright owner. Plans generated by DigSAFE Pro™ software provided by LinesearchbeforeUdig.

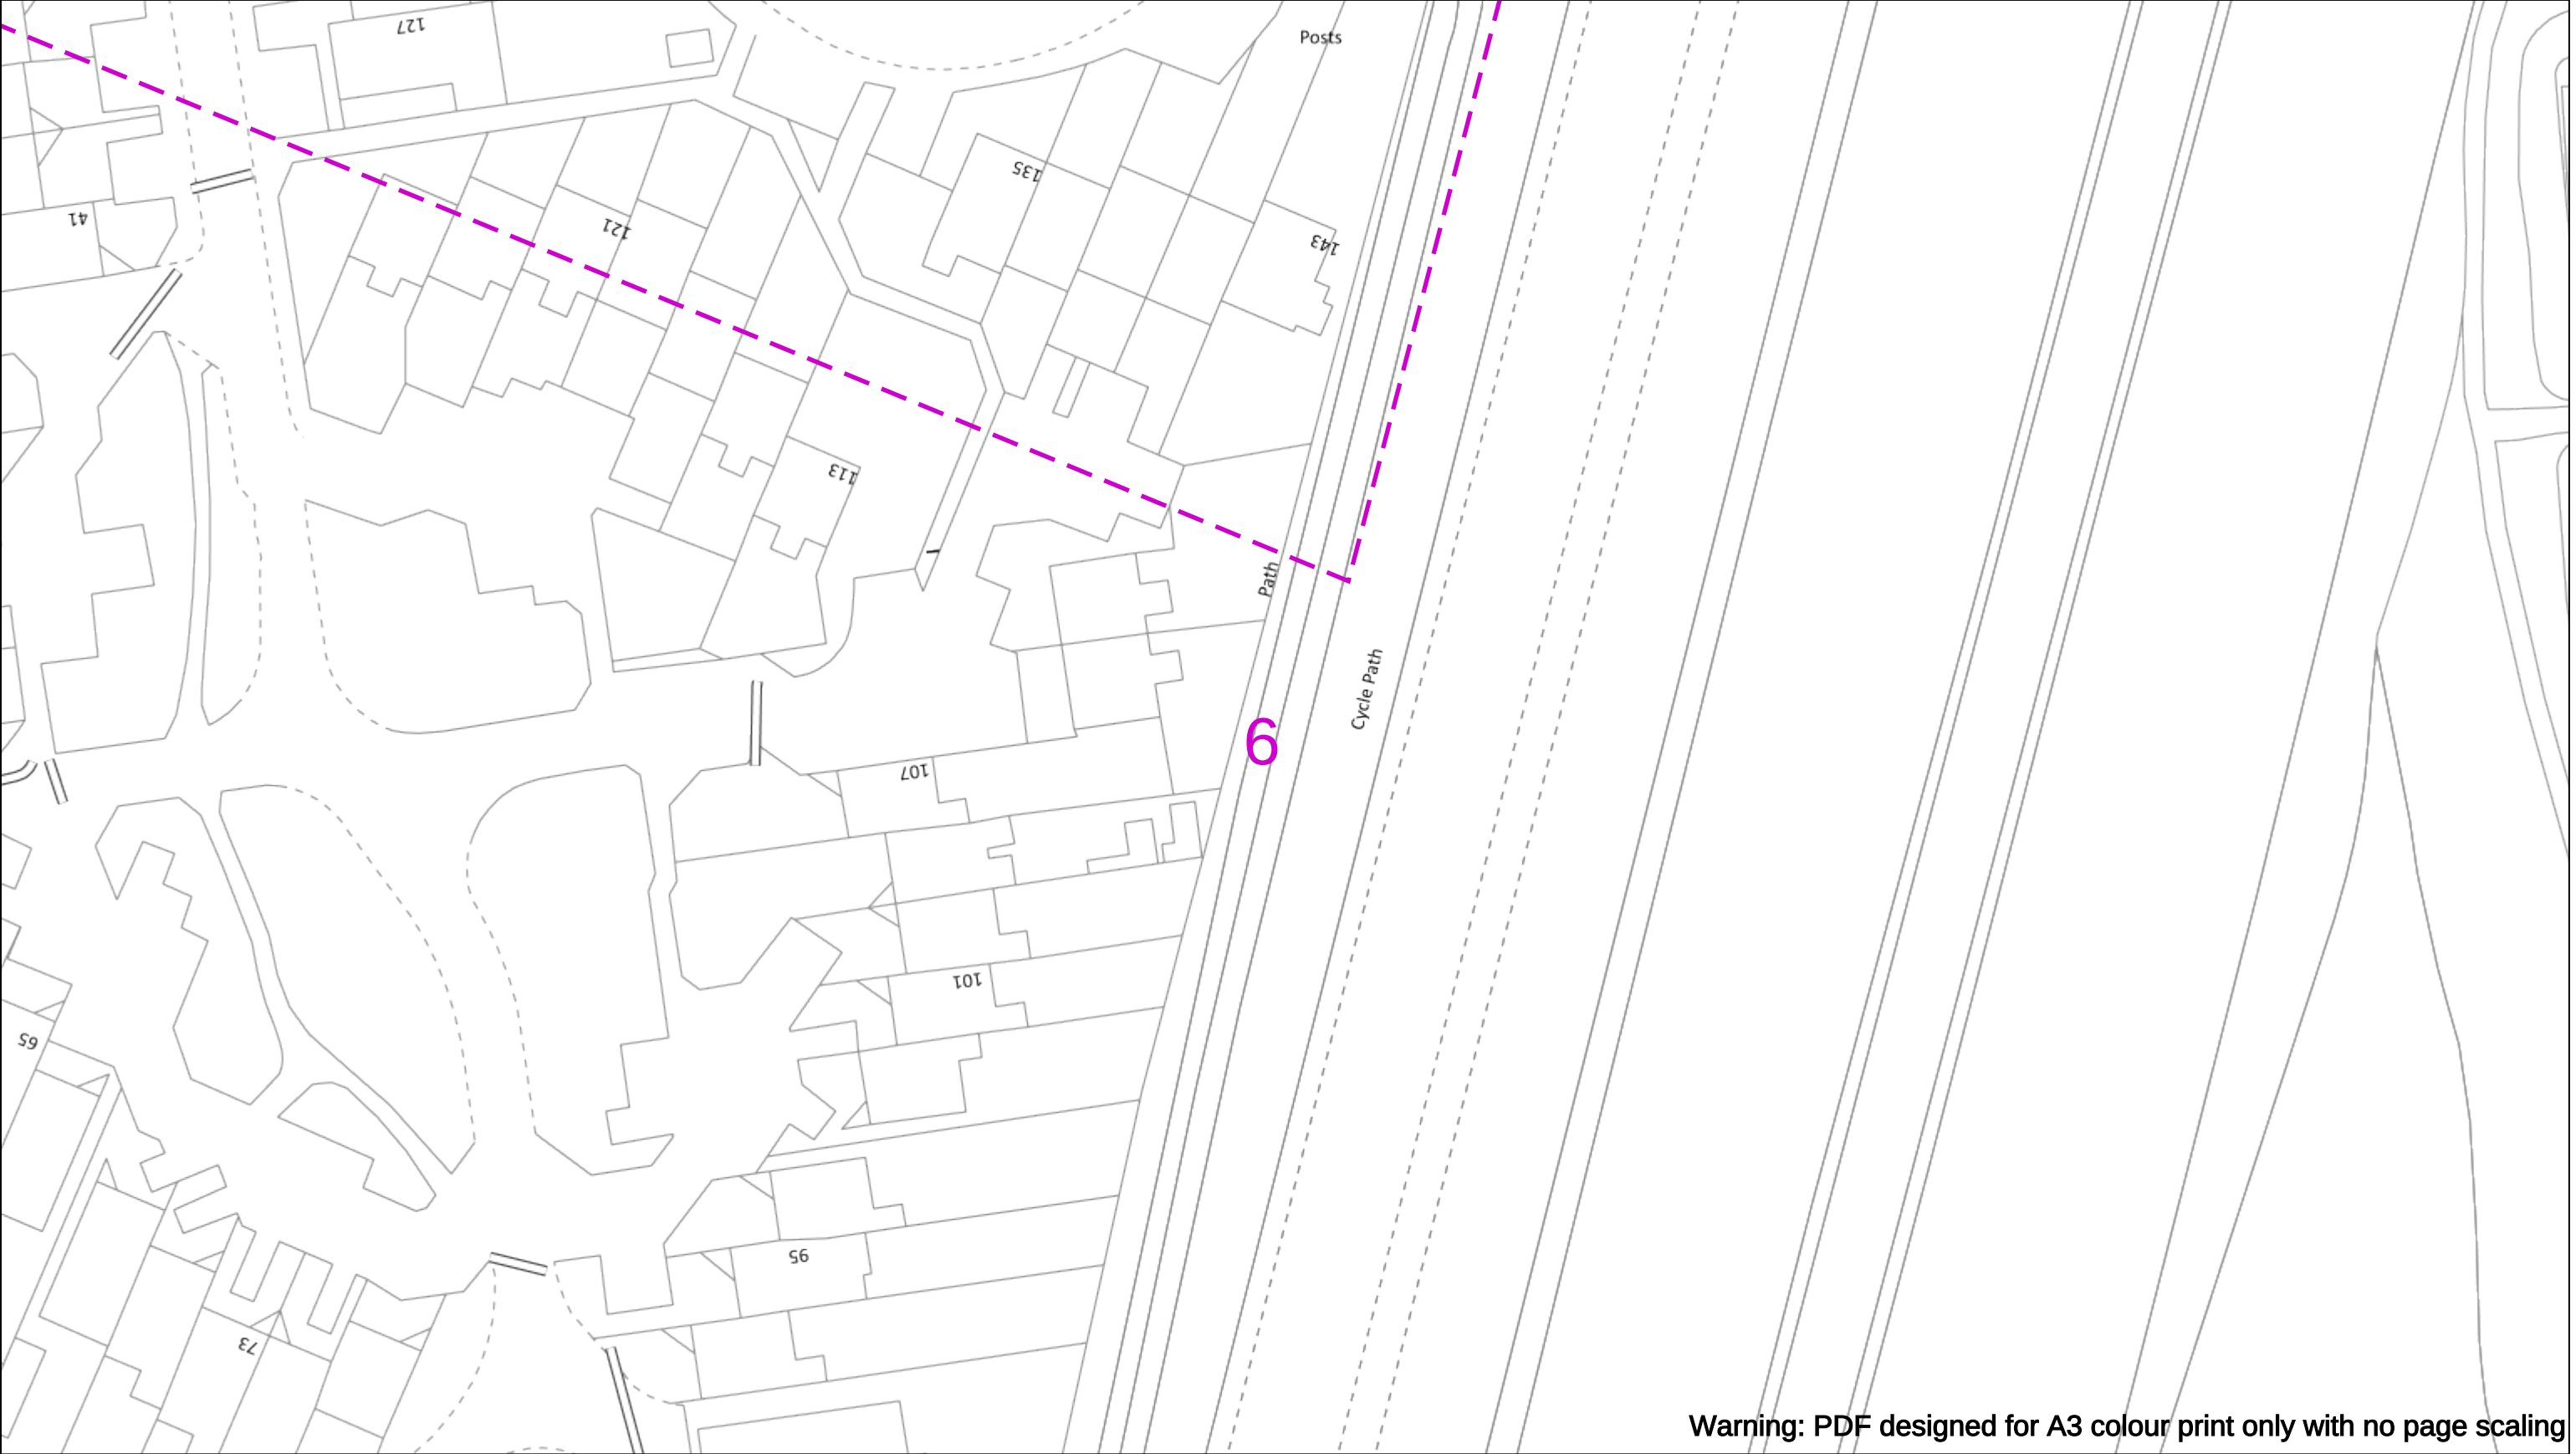

Warning: PDF designed for A3 colour print only with no page scaling

050m

Dig Sites

Area:

Line:

Date Requested: 15/09/2021

Job Reference: 23270156

Site Location: 510755 180225

Requested by:
Mr Brian McMaster
Your Scheme/Reference:
NOC/BGJHM742

WARNING

There may have been subsequent alteration to the surface levels. Trial holes must be undertaken to determine position and depths of cables. HS (G) 47 Booklet from the Health and Safety Executive – Avoiding Danger from Buried Cables – should be consulted before commencing excavation work.

WHEN WORKING IN THE VICINITY OF OVERHEAD LINES THE HEALTH AND SAFETY GUIDANCE NOTES GS6 SHOULD BE CONSULTED (AVAILABLE FROM THE HSE WEBSITE)

	Voltages (V)			
LV (Low Voltage) and Services	Up to 1,000V			
HV (High Voltage)	Over 1,000V to 11,000V			
EHV (Extra High Voltage)	22,000V to 132,000V			
Transmission	275,000V and 400,000V			

	NORMAL DEPTH TO THE TOP OF THE CABLE WHEN LAID			
	Services	LV	HV	EHV
Footpath/Unmade	0.45m	0.45m	0.6m	0.8m
Road Crossing	0.6m	0.6m	0.75m	0.9m
Agricultural	1m	1m	1m	1.1m

Legend

Service Cable

LV Mains

2 – 3.3kV

6.6kV

11kV

22kV

33kV

66kV

132kV

275kV

400kV

Fibre Optic

Pilot Cable

Distribution Structures (Electric)

Pole, Existing Location

Pole Structure, Existing Location - Single

Pole Structure, Existing Location - H

Duct Route

Cross Section Route

Southern Electric Power Distribution plc
Registered Office: No.1 Forbury Place
43 Forbury Road Reading RG1 3JH
Registered In England & Wales No.04094290


If you're unsure & need to seek advice before commencing excavations please contact:
General Enquiries: 0800 048 3516

Subject to revision – Master held by SSEN Asset Data Team:
Asset.Data@sse.com
01256 337 294

Scale: 1:500 (When plotted at A3)


BASED UPON THE ORDNANCE SURVEY MAP WITH THE SANCTION OF THE CONTROLLER OF H.M STATIONERY OFFICE CROWN COPYRIGHT RESERVED.

This copy has been made by or with the authority of Scottish and Southern Energy Power Distribution Ltd. Pursuant to section 47 of the Copyright, Designs and Patents Act 1988 ('The Act'). Unless the Act provides a relevant exception to copyright the copy must not be copied without prior permission of the copyright owner. Plans generated by DigSAFE Pro™ software provided by LinesearchbeforeUdig.

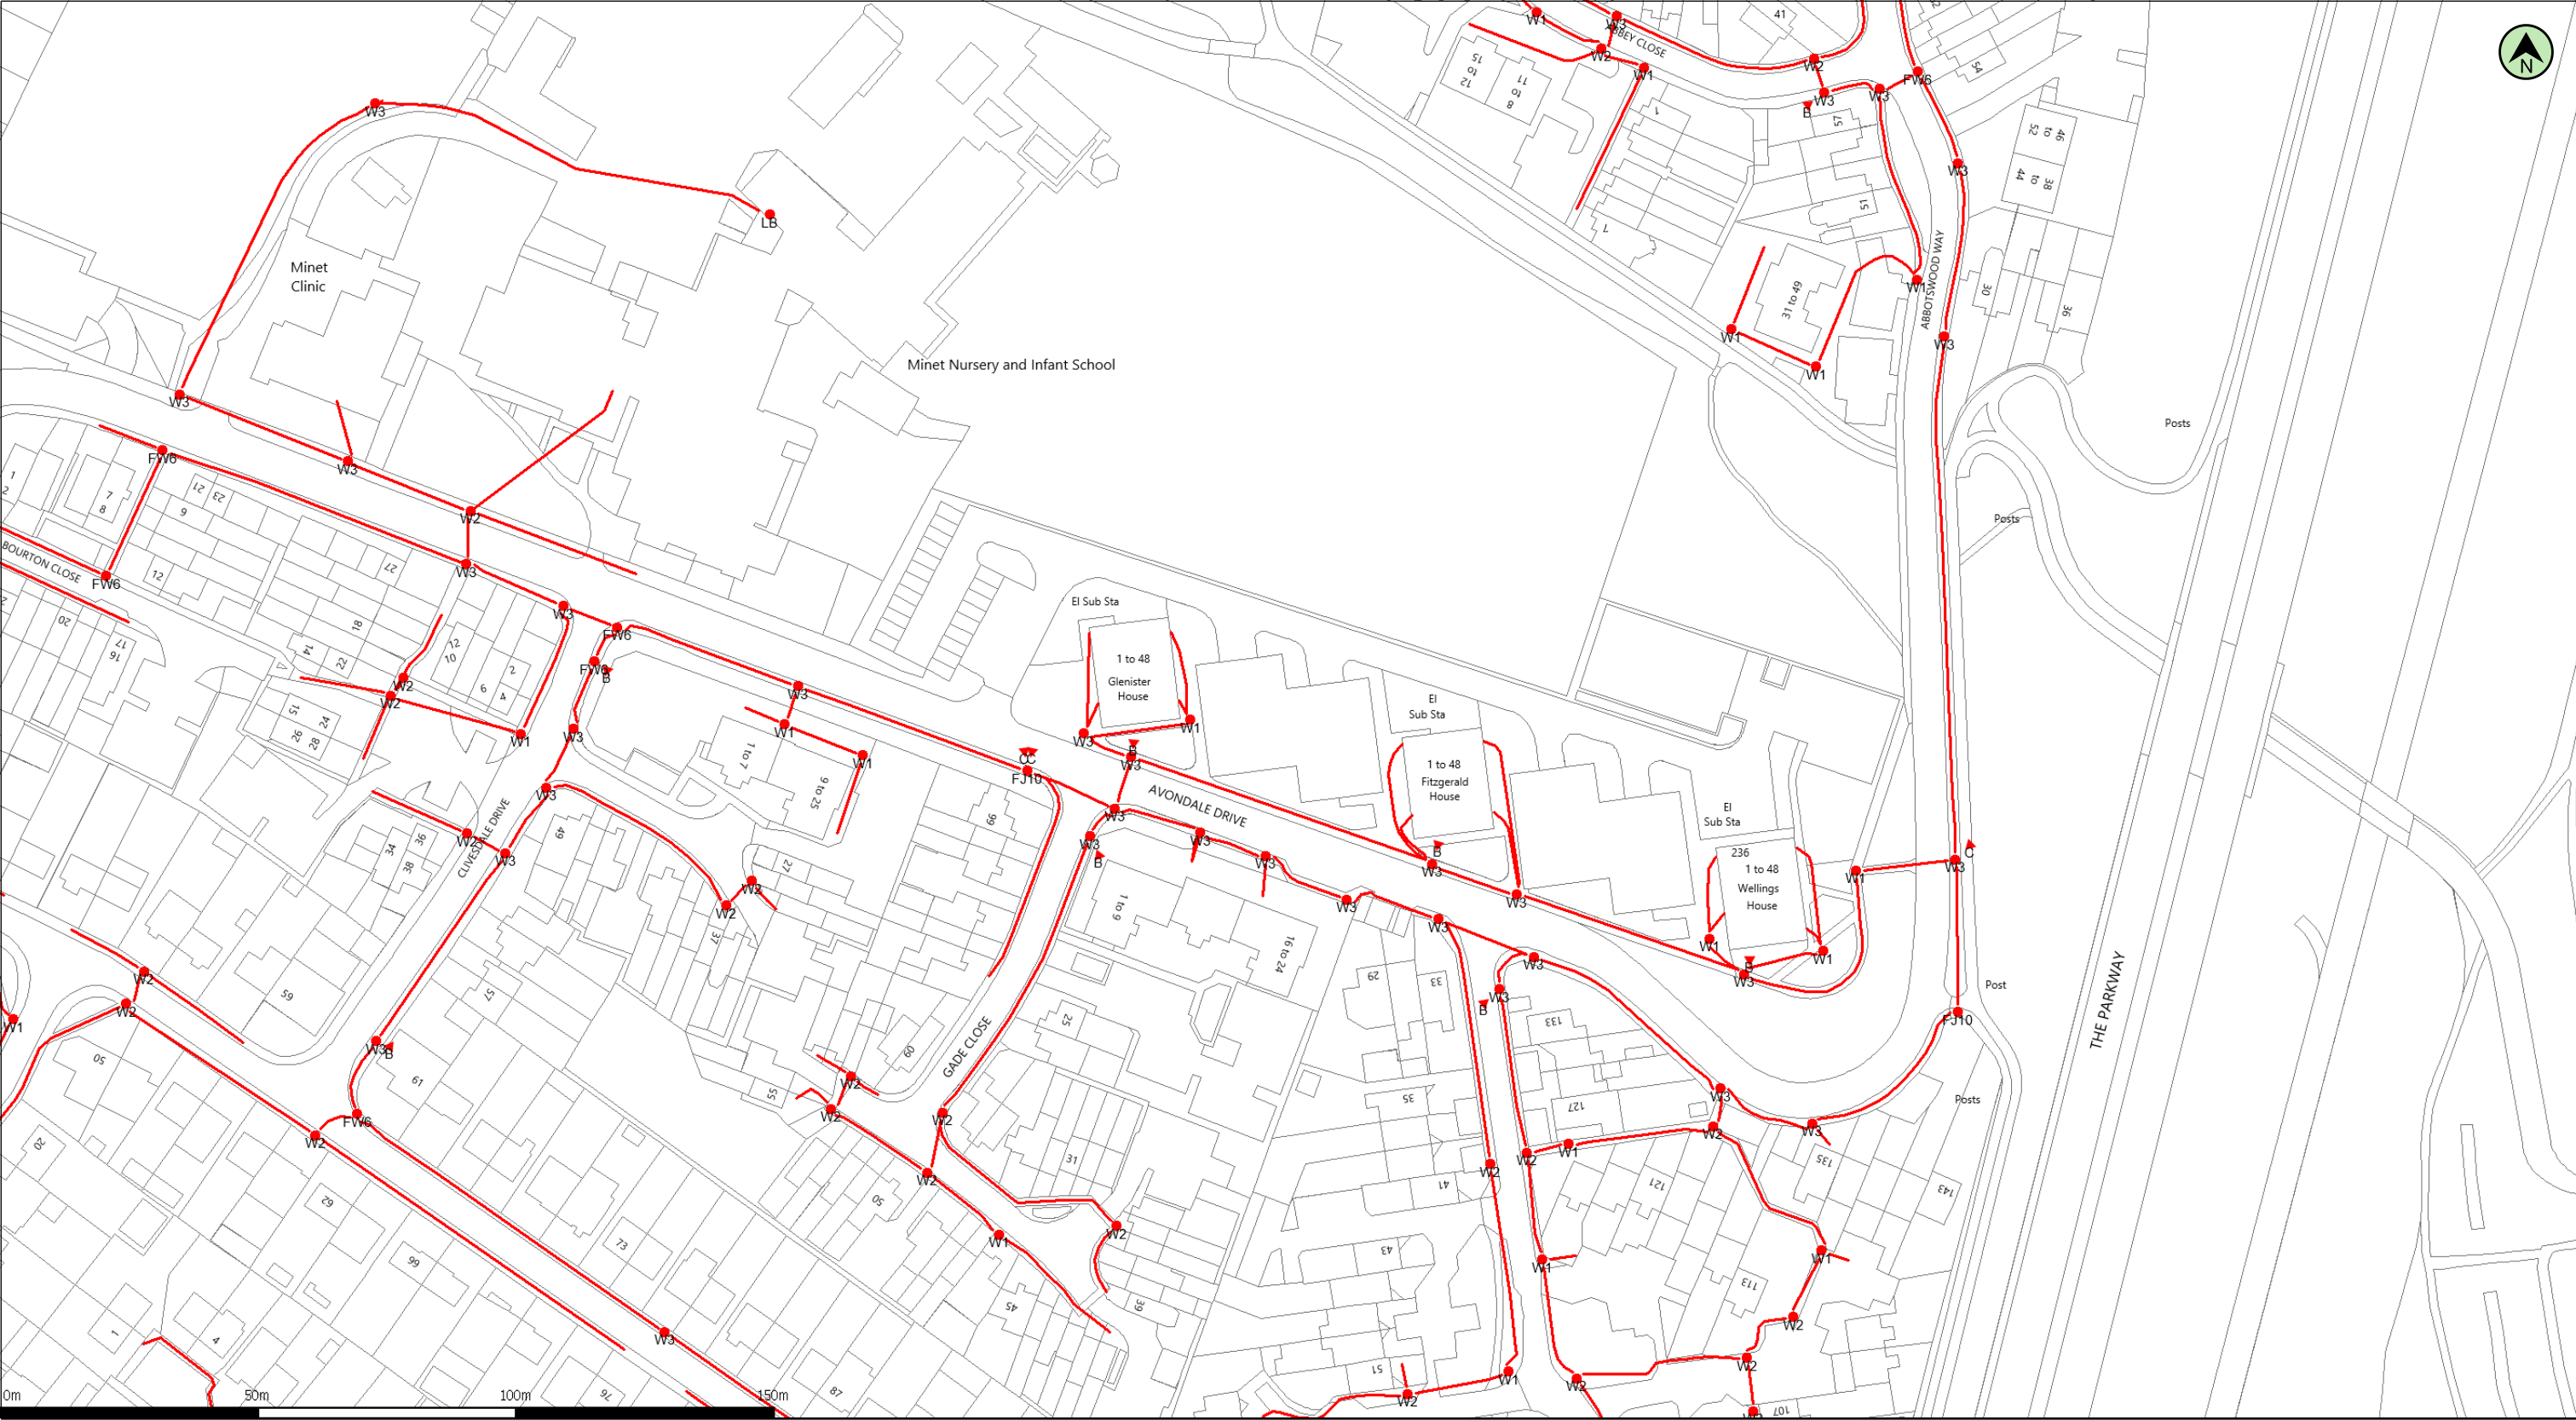

(c) Crown copyright and database rights 2021 Ordnance Survey 100019209 Date: 15/09/21 Scale: 1:1250 Map Centre: 510678,180293 Data updated: 01/08/21 Our Ref: 649458 - 2 Telecoms Plan A3

Important Information - please read The purpose of this plan is to identify Virgin Media apparatus. We have tried to make it as accurate as possible but we cannot warrant its accuracy. In addition, we caution that within Virgin Media apparatus there may be instances where mains voltage power cables have been placed inside green, rather than black ducting. Further details can be found using the "Affected Postcodes.pdf", which can be downloaded from this website. Therefore, you must not rely solely on this plan if you are carrying out any excavation or other works in the vicinity of Virgin Media apparatus. The actual position of any underground service must be verified by cable detection equipment, etc. and established on site before any mechanical plant is used. Accordingly, unless it is due to the negligence of Virgin Media, its employees or agents, Virgin Media will not have any liability for any omissions or inaccuracies in the plan or for any loss or damage caused or arising from the use of and/or any reliance on this plan. This plan is produced by Virgin Media Limited (c) Crown copyright and database rights 2021 Ordnance Survey 100019209.

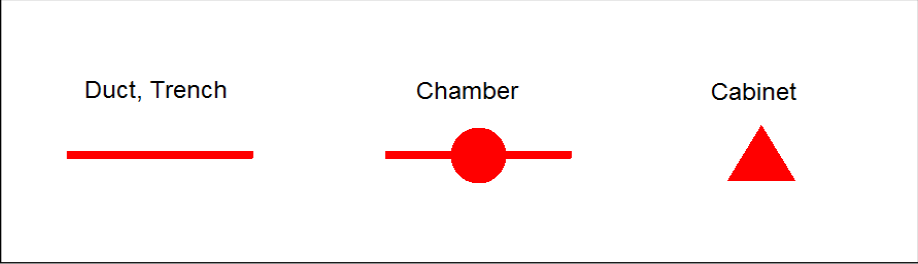

brian.mcmaster@national-one-call.co.uk
NOC/BGJHM742



National One Call Plan To Dig
Mill Place, 1 Li, Mill Place

WEST LOTHIAN
EH49 7TL

Search address supplied Avondale Drive
Hayes
UB3 3PW

Your reference NOC/BGJHM742

Our reference ALS/ALS Standard/2021_4505245

Search date 15 September 2021

Knowledge of features below the surface is essential for every development

The benefits of this knowledge not only include ensuring due diligence and avoiding risk, but also being able to ascertain the feasibility of any development.

Did you know that Thames Water Property Searches can also provide a variety of utility searches including a more comprehensive view of utility providers' assets (across up to 35-45 different providers), as well as more focused searches relating to specific major utility companies such as National Grid (gas and electric).

Contact us to find out more.



Thames Water Utilities Ltd
Property Searches, PO Box 3189, Slough SL1 4WW
DX 151280 Slough 13



searches@thameswater.co.uk
www.thameswater-propertysearches.co.uk



0800 009 4540

Search address supplied: Avondale Drive, Hayes, UB3 3PW

Dear Sir / Madam

An Asset Location Search is recommended when undertaking a site development. It is essential to obtain information on the size and location of clean water and sewerage assets to safeguard against expensive damage and allow cost-effective service design.

The following records were searched in compiling this report: - the map of public sewers & the map of waterworks. Thames Water Utilities Ltd (TWUL) holds all of these.

This search provides maps showing the position, size of Thames Water assets close to the proposed development and also manhole cover and invert levels, where available.

Please note that none of the charges made for this report relate to the provision of Ordnance Survey mapping information. The replies contained in this letter are given following inspection of the public service records available to this company. No responsibility can be accepted for any error or omission in the replies.

You should be aware that the information contained on these plans is current only on the day that the plans are issued. The plans should only be used for the duration of the work that is being carried out at the present time. Under no circumstances should this data be copied or transmitted to parties other than those for whom the current work is being carried out.

Thames Water do update these service plans on a regular basis and failure to observe the above conditions could lead to damage arising to new or diverted services at a later date.

Contact Us

If you have any further queries regarding this enquiry please feel free to contact a member of the team on 0800 009 4540, or use the address below:

Thames Water Utilities Ltd
Property Searches
PO Box 3189
Slough
SL1 4WW

Email: searches@thameswater.co.uk

Web: www.thameswater-propertysearches.co.uk

Waste Water Services

Please provide a copy extract from the public sewer map.

Enclosed is a map showing the approximate lines of our sewers. Our plans do not show sewer connections from individual properties or any sewers not owned by Thames Water unless specifically annotated otherwise. Records such as "private" pipework are in some cases available from the Building Control Department of the relevant Local Authority.

Where the Local Authority does not hold such plans it might be advisable to consult the property deeds for the site or contact neighbouring landowners.

This report relates only to sewerage apparatus of Thames Water Utilities Ltd, it does not disclose details of cables and or communications equipment that may be running through or around such apparatus.

The sewer level information contained in this response represents all of the level data available in our existing records. Should you require any further Information, please refer to the relevant section within the 'Further Contacts' page found later in this document.

For your guidance:

- The Company is not generally responsible for rivers, watercourses, ponds, culverts or highway drains. If any of these are shown on the copy extract they are shown for information only.
- Any private sewers or lateral drains which are indicated on the extract of the public sewer map as being subject to an agreement under Section 104 of the Water Industry Act 1991 are not an 'as constructed' record. It is recommended these details be checked with the developer.

Clean Water Services

Please provide a copy extract from the public water main map.

With regard to the fresh water supply, this site falls within the boundary of another water company. For more information, please redirect your enquiry to the following address:

Affinity Water Ltd
Tamblin Way
Hatfield
AL10 9EZ
Tel: 0345 3572401



For your guidance:

- Assets other than vested water mains may be shown on the plan, for information only.
- If an extract of the public water main record is enclosed, this will show known public water mains in the vicinity of the property. It should be possible to estimate the likely length and route of any private water supply pipe connecting the property to the public water network.

Payment for this Search

A charge will be added to your suppliers account.