


GENERAL NOTES

1. THE CONTRACTOR MUST CHECK ALL DIMENSIONS ON SITE BEFORE COMMENCING WORK
2. ANY DISCREPANCIES MUST BE IMMEDIATELY BROUGHT TO THE ATTENTION OF THE DESIGNER
3. ALL WORK MUST CONFORM TO CURRENT BUILDING REGULATIONS, BRITISH STANDARDS & CODES OF PRACTICE AND NHBC STANDARDS
4. THESE DRAWINGS ARE TO BE READ IN CONJUNCTION WITH ALL RELEVANT DESIGNER, ENGINEER OR SPECIALIST DRAWINGS AND SPECIFICATIONS
5. ALL DIMENSIONS ARE IN MILLIMETERS UNLESS STATED OTHERWISE
6. ALL MATERIALS ARE TO BE USED AND INSTALLED IN STRICT COMPLIANCE WITH THE RELEVANT MANUFACTURERS' RECOMMENDATIONS
7. THE CONTRACTOR IS RESPONSIBLE FOR PROVIDING ALL NECESSARY TEMPORARY SUPPORT TO THE BUILDING AND ANY ADJACENT STRUCTURES
8. ALL CONSTRUCTION MUST BE BUILT WITHIN THE ACTUAL PROPERTY BOUNDARIES UNLESS PARTY WALL AGREEMENT ALLOWS OTHERWISE

HATCH/LINE LEGEND		DRAINAGE ABBREVIATIONS	
concrete	demolish	mh = manhole	ic = inspection chamber
brickwork	above/beyond	re = rodding eye	boundary
blockwork	boundary	g = gully	svp = soil vent pipe
	drain	rwp = rain water pipe	swp = stub pipe
	insulation/stud partition	ss = stub stack	rainwater drainage to contractor design
			electrical layout to client design

REVISION	DESCRIPTION	DATE

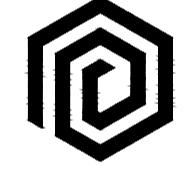

DRAW AND PLAN

T: 020 8243 8779

E: info@drawandplan.com

W: www.drawandplan.com

Location

**15 MYRTLE AVENUE RUISLIP
HILLINGDON
HA4 8SA**

Drawing title

**GENERAL ARRANGEMENT
LAWFUL CERTIFICATE**

Date Scale

20/06/2023 1:50@A1


Job no. Dwg no. Revision

23023 PGA021 -


1:50	0m	5m
1:100	0m	10m
1:200	0m	20m
1:500	0m	50m




PROPOSED SITE/BLOCK PLAN 1:500

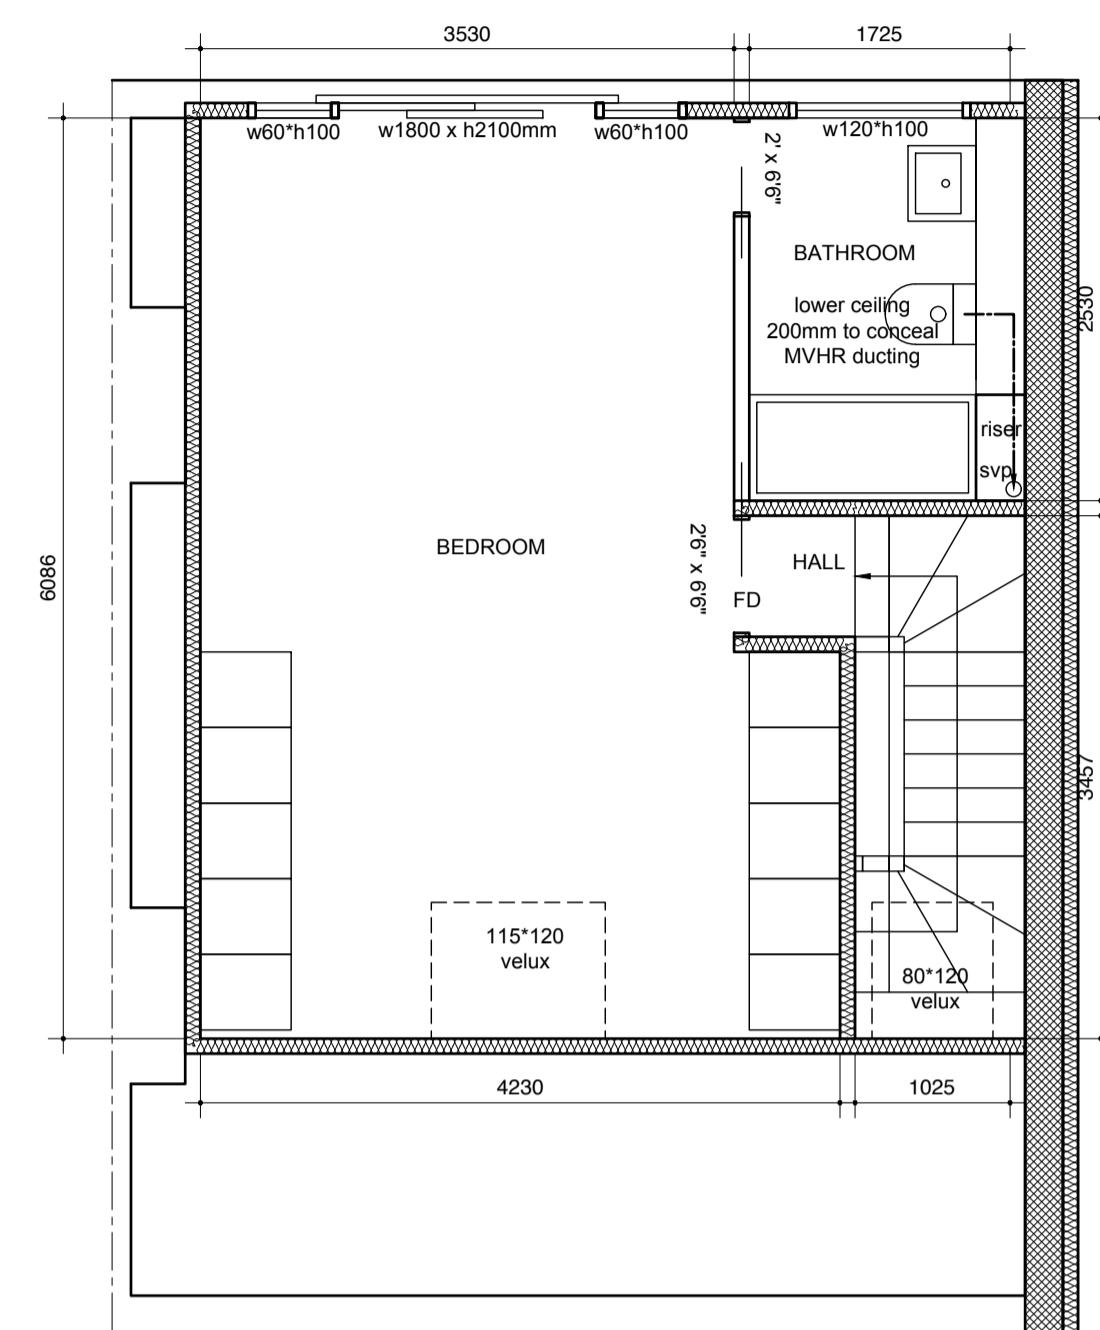


PROPOSED LOFT PLAN

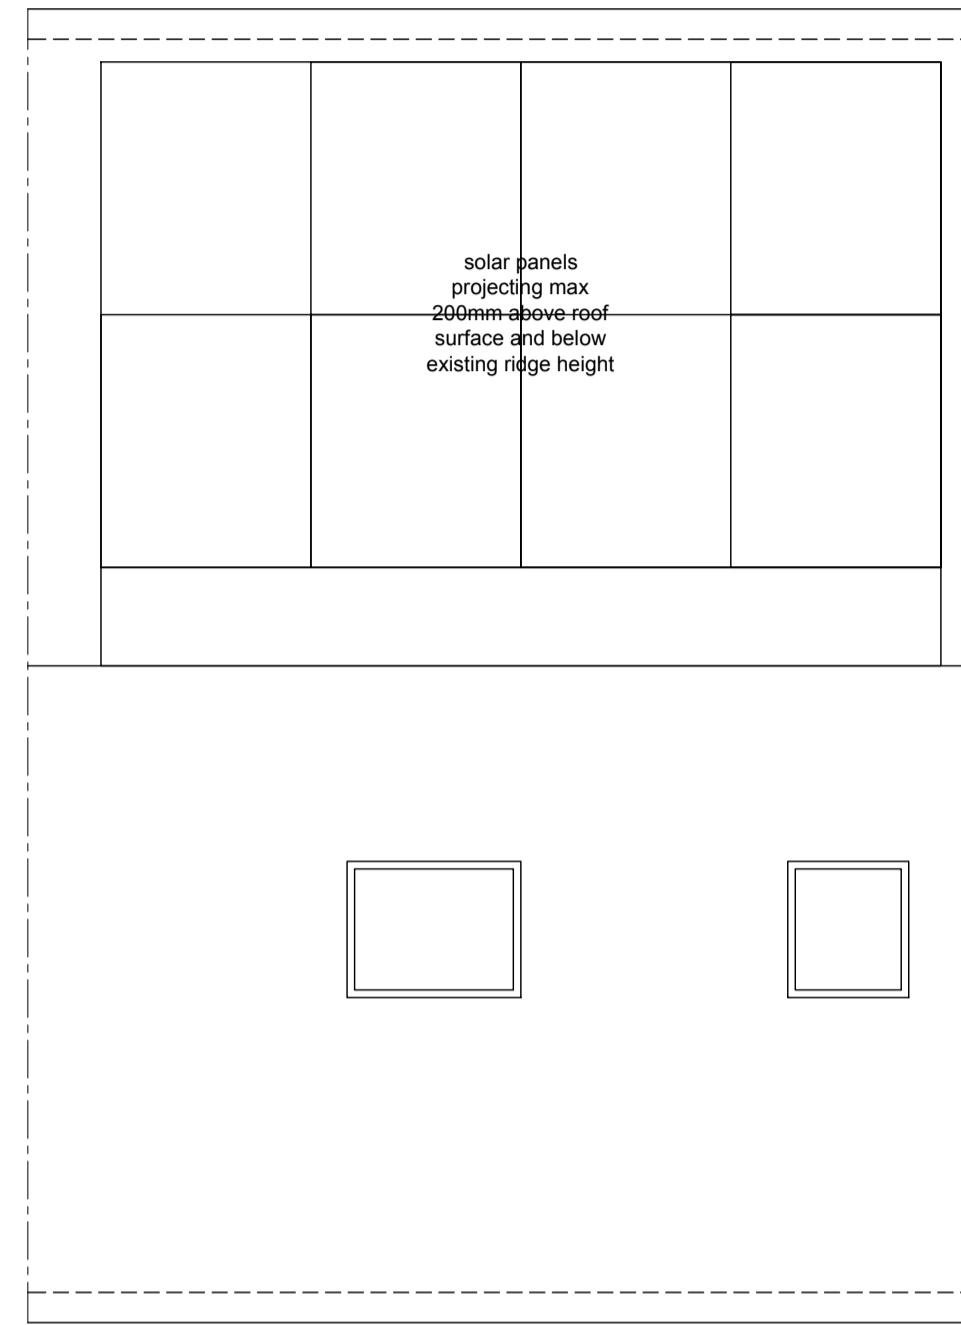

PROPOSED ROOF PLAN

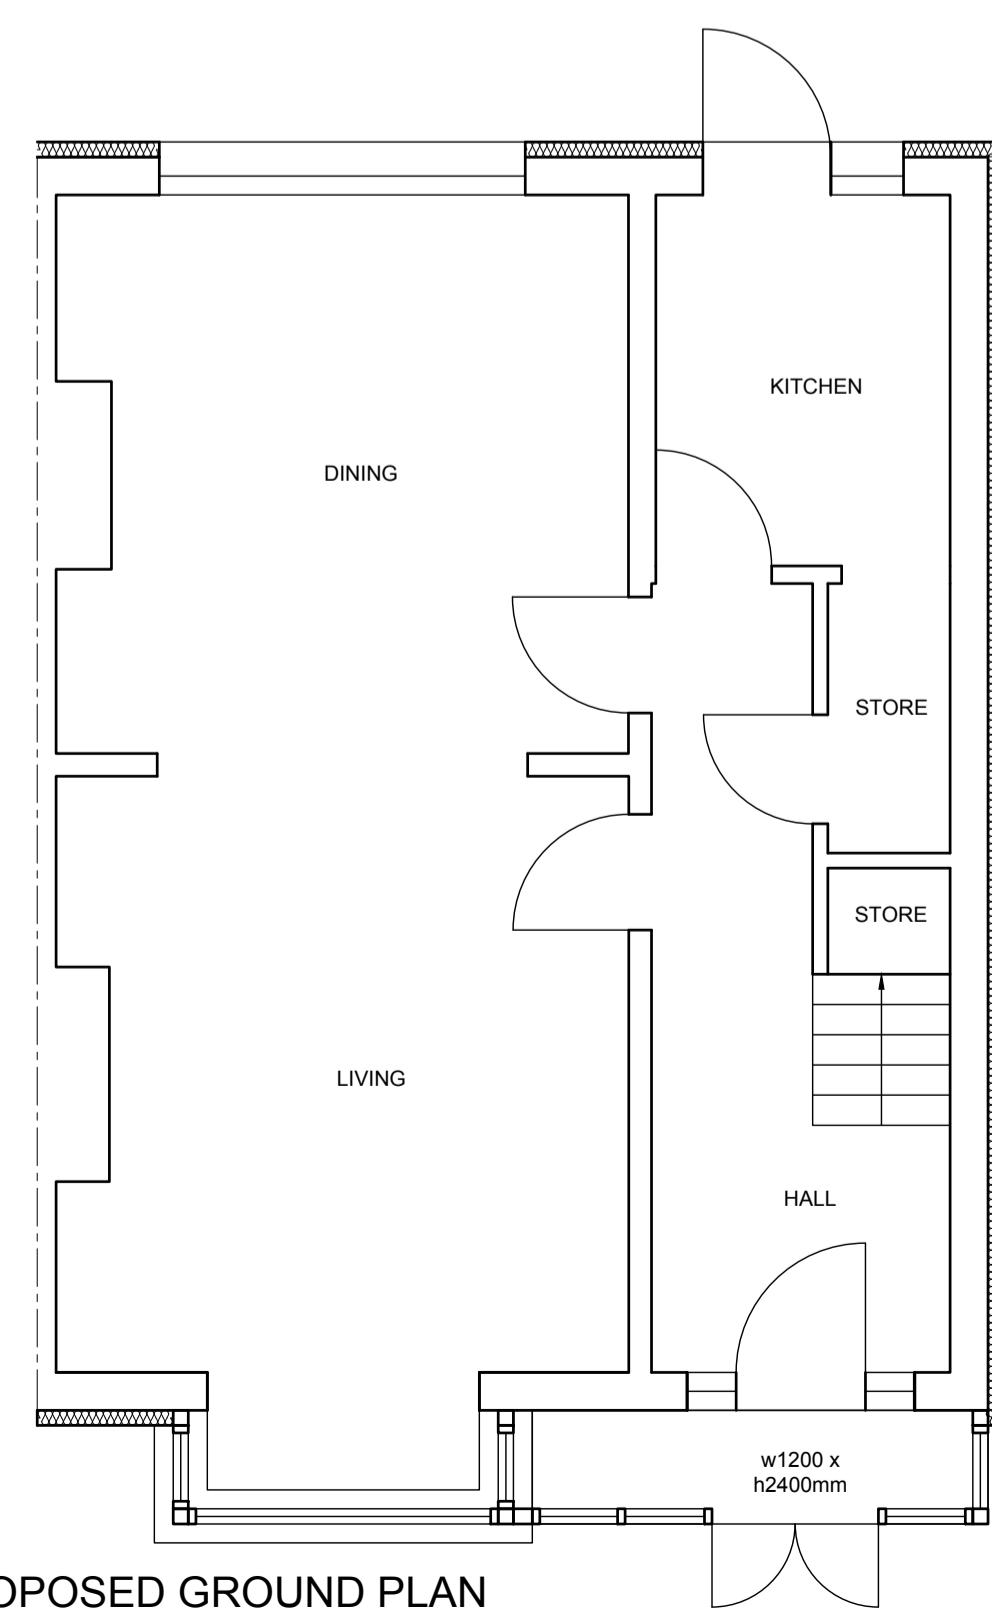

PROPOSED GROUND PLAN

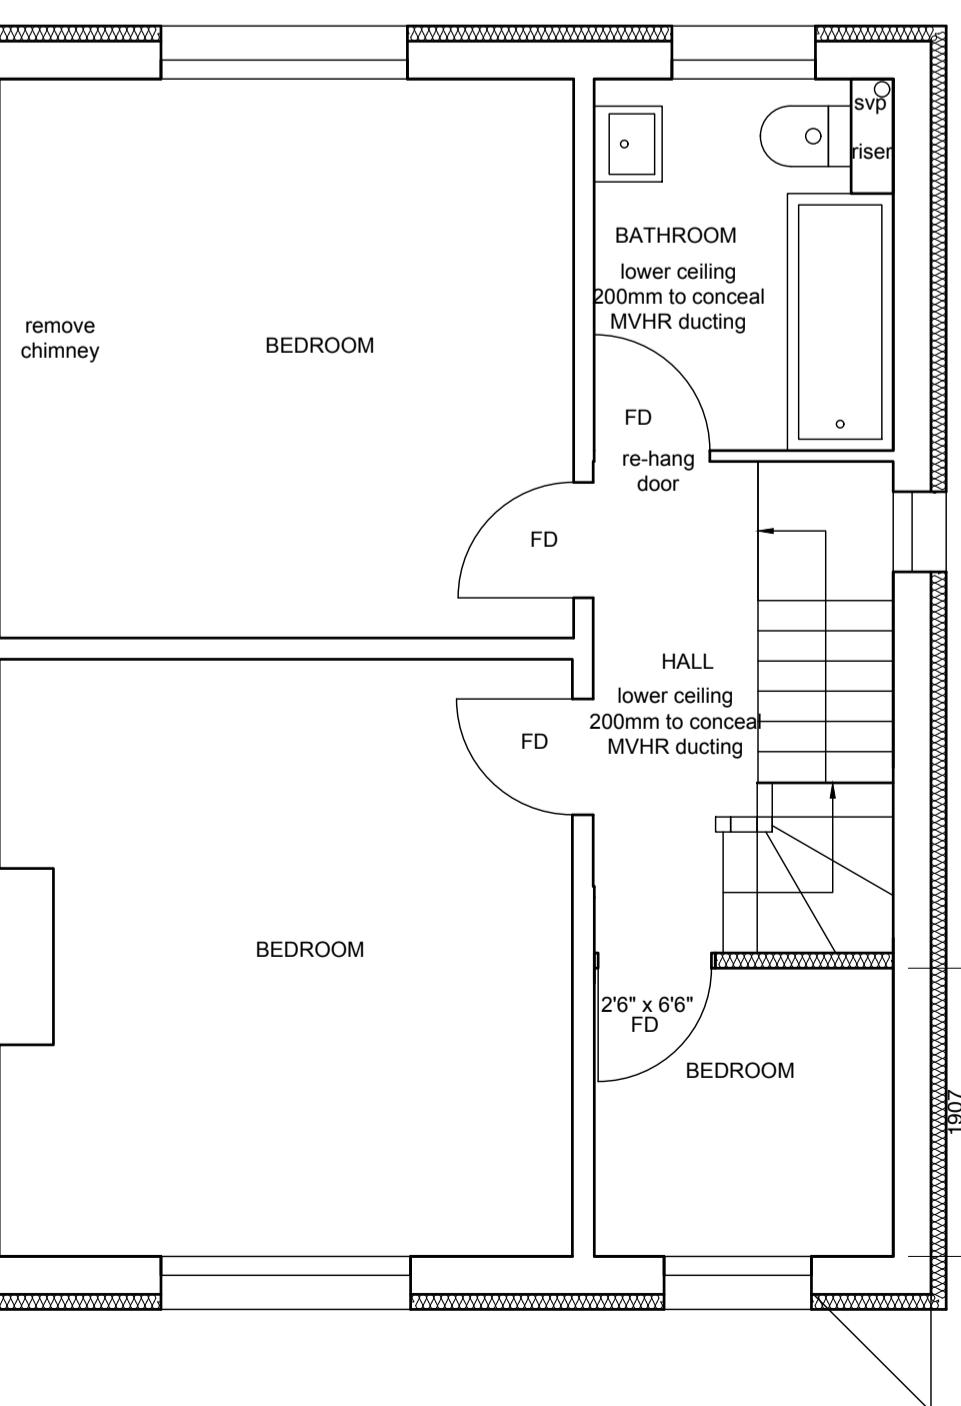

PROPOSED FIRST PLAN