



Location Plan

Scale 1:1250

© Crown Copyright and database rights 2022
OS 100047474



Existing Block Plan

Scale 1:500


© Crown Copyright and database rights 2022
OS 100047474



Proposed Block Plan


Scale 1:500

© Crown Copyright and database rights 2022
OS 100047474

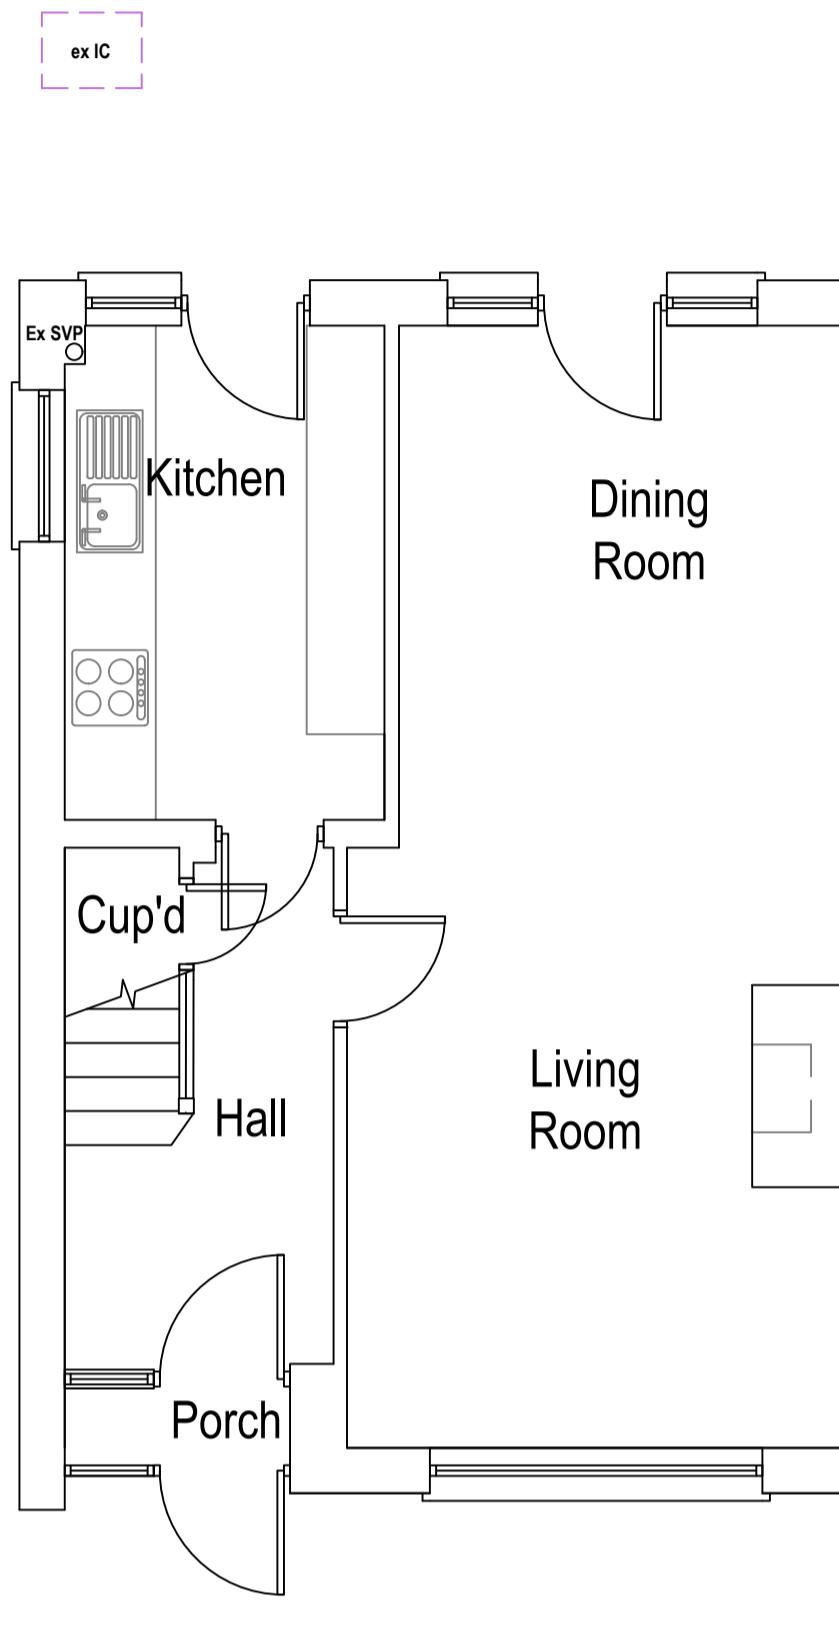


Existing Ground Floor Plan


Scale 1:50

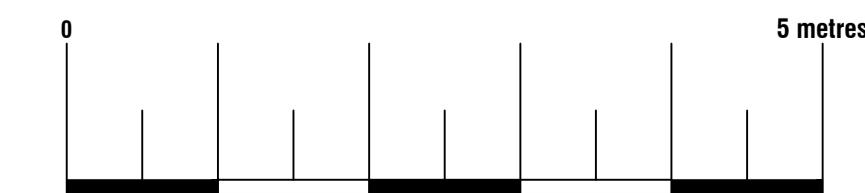


| | |
|--|-------------------------|
| Arkiplan | |
| 74 Cardiff Road, CF15 7QE • Enquiries@ArkiPlan.co.uk | |
| Site | Date 29.07.2022 |
| | Sheet 22-1633 D02 REV 0 |
| Job | New Extension |
| Scale | As Shown@A1 |
| Title Number | - |
| Title | As Shown |

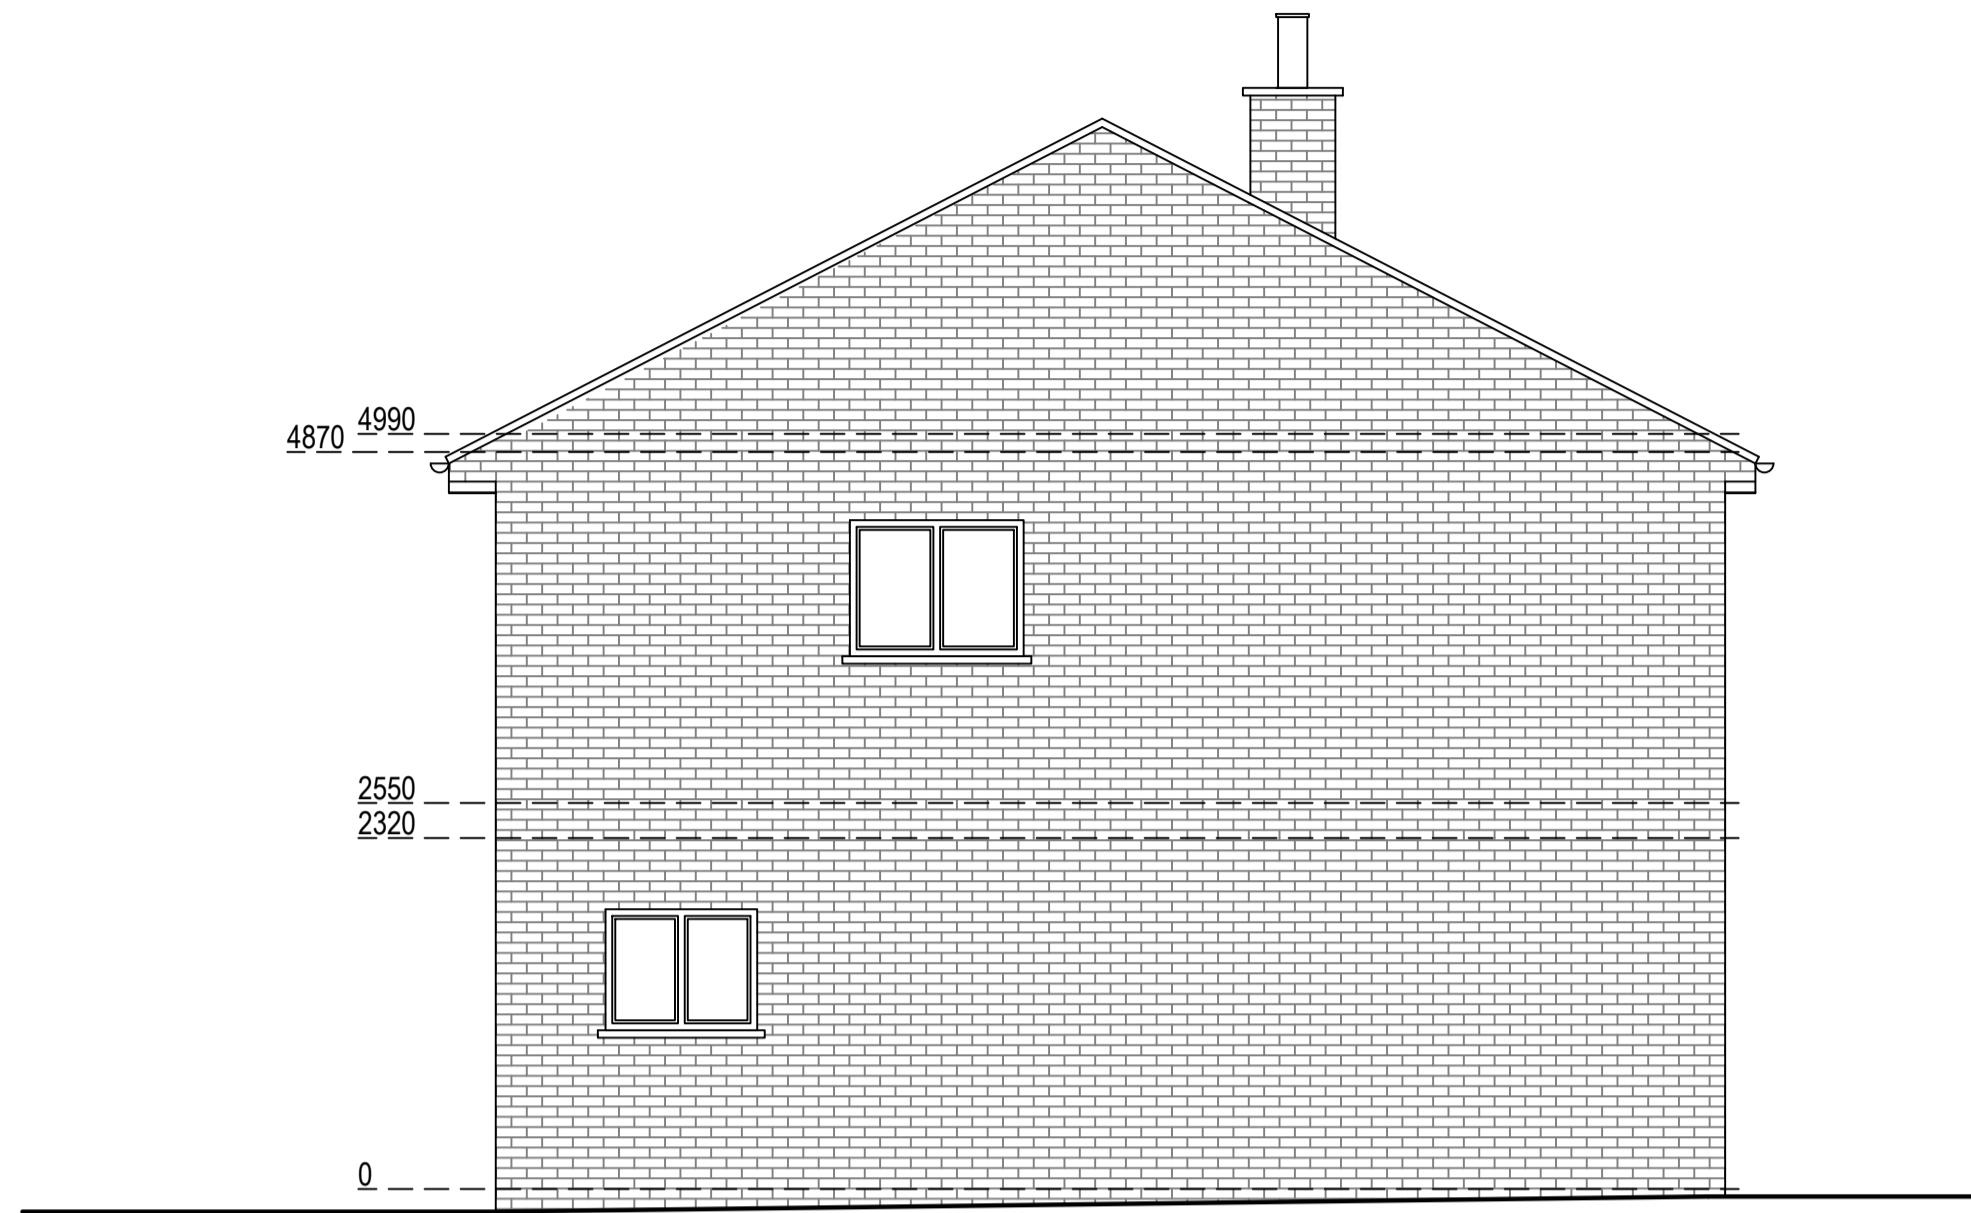


Existing Northeast Elevation
Scale 1:50

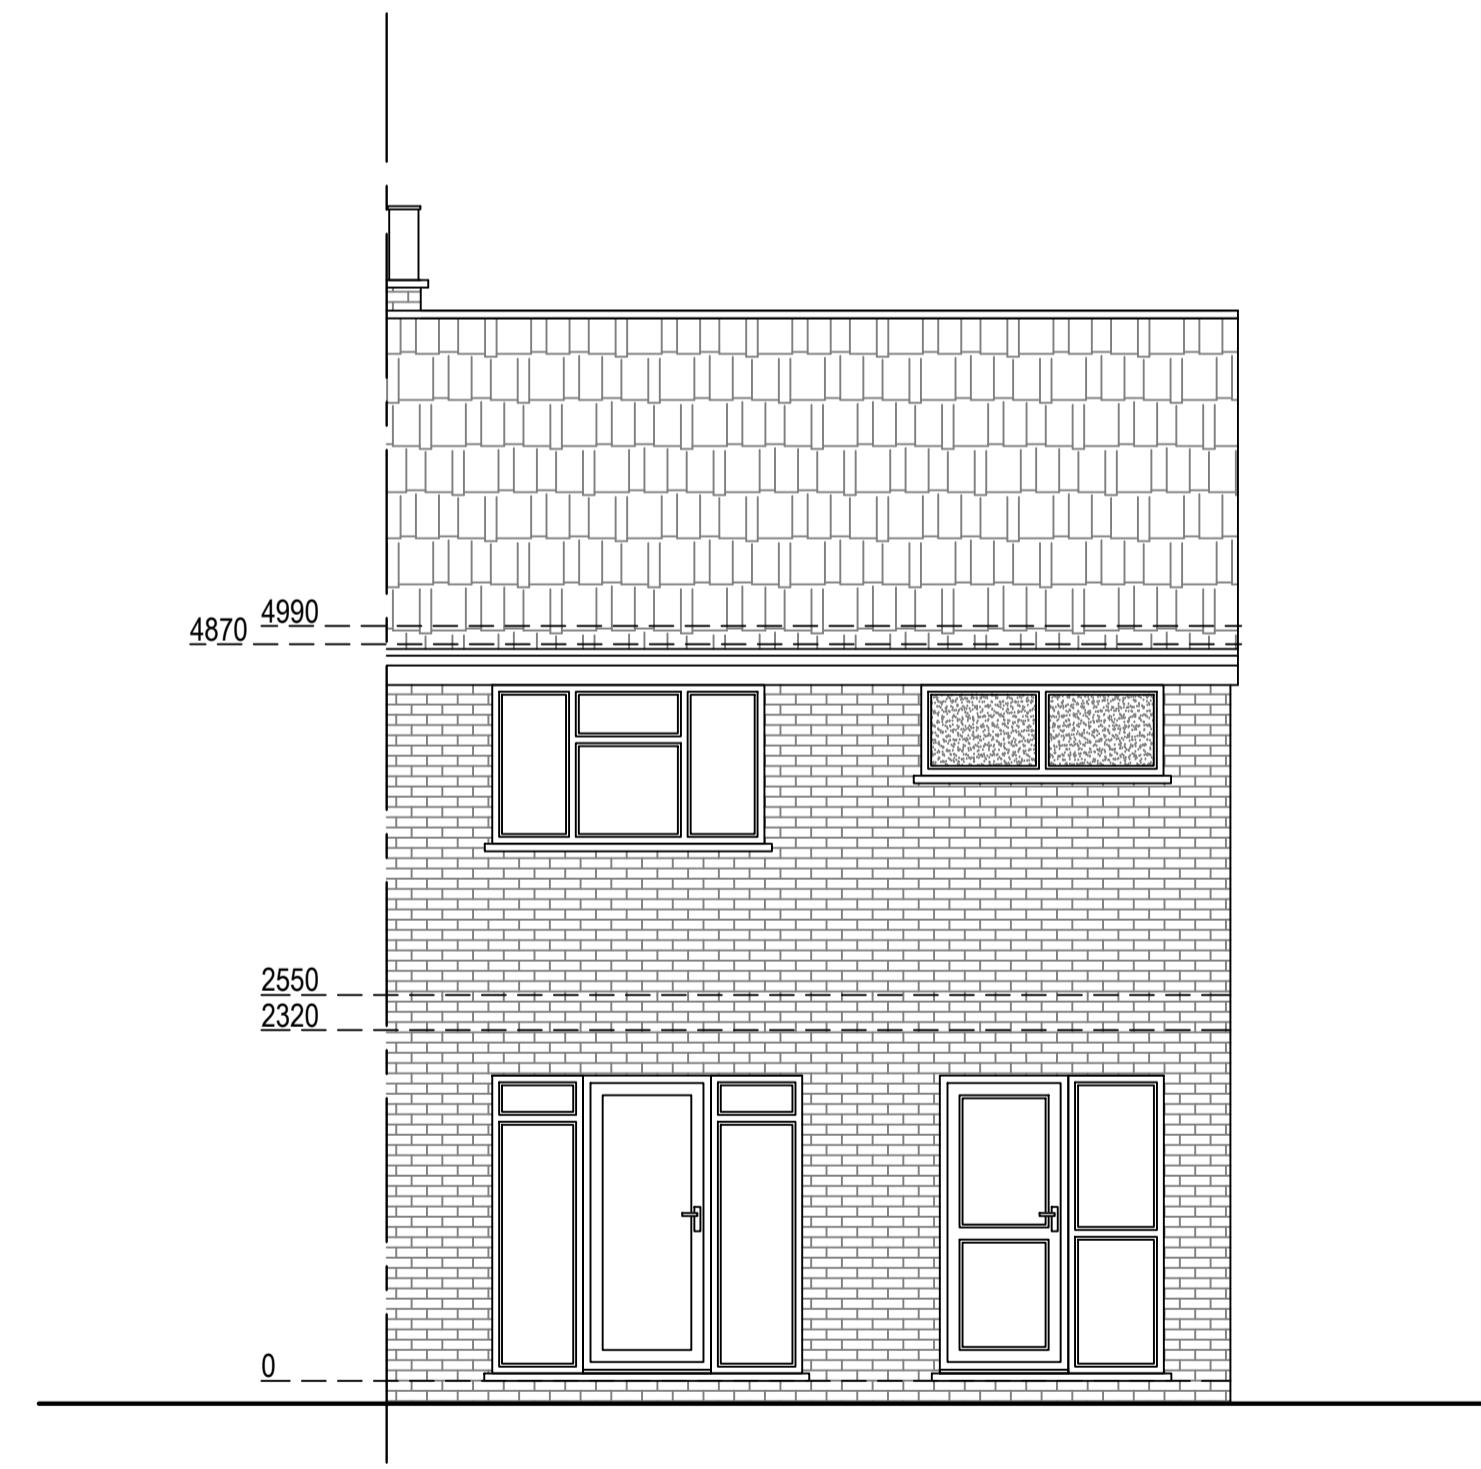

Existing Southeast Elevation
Scale 1:50

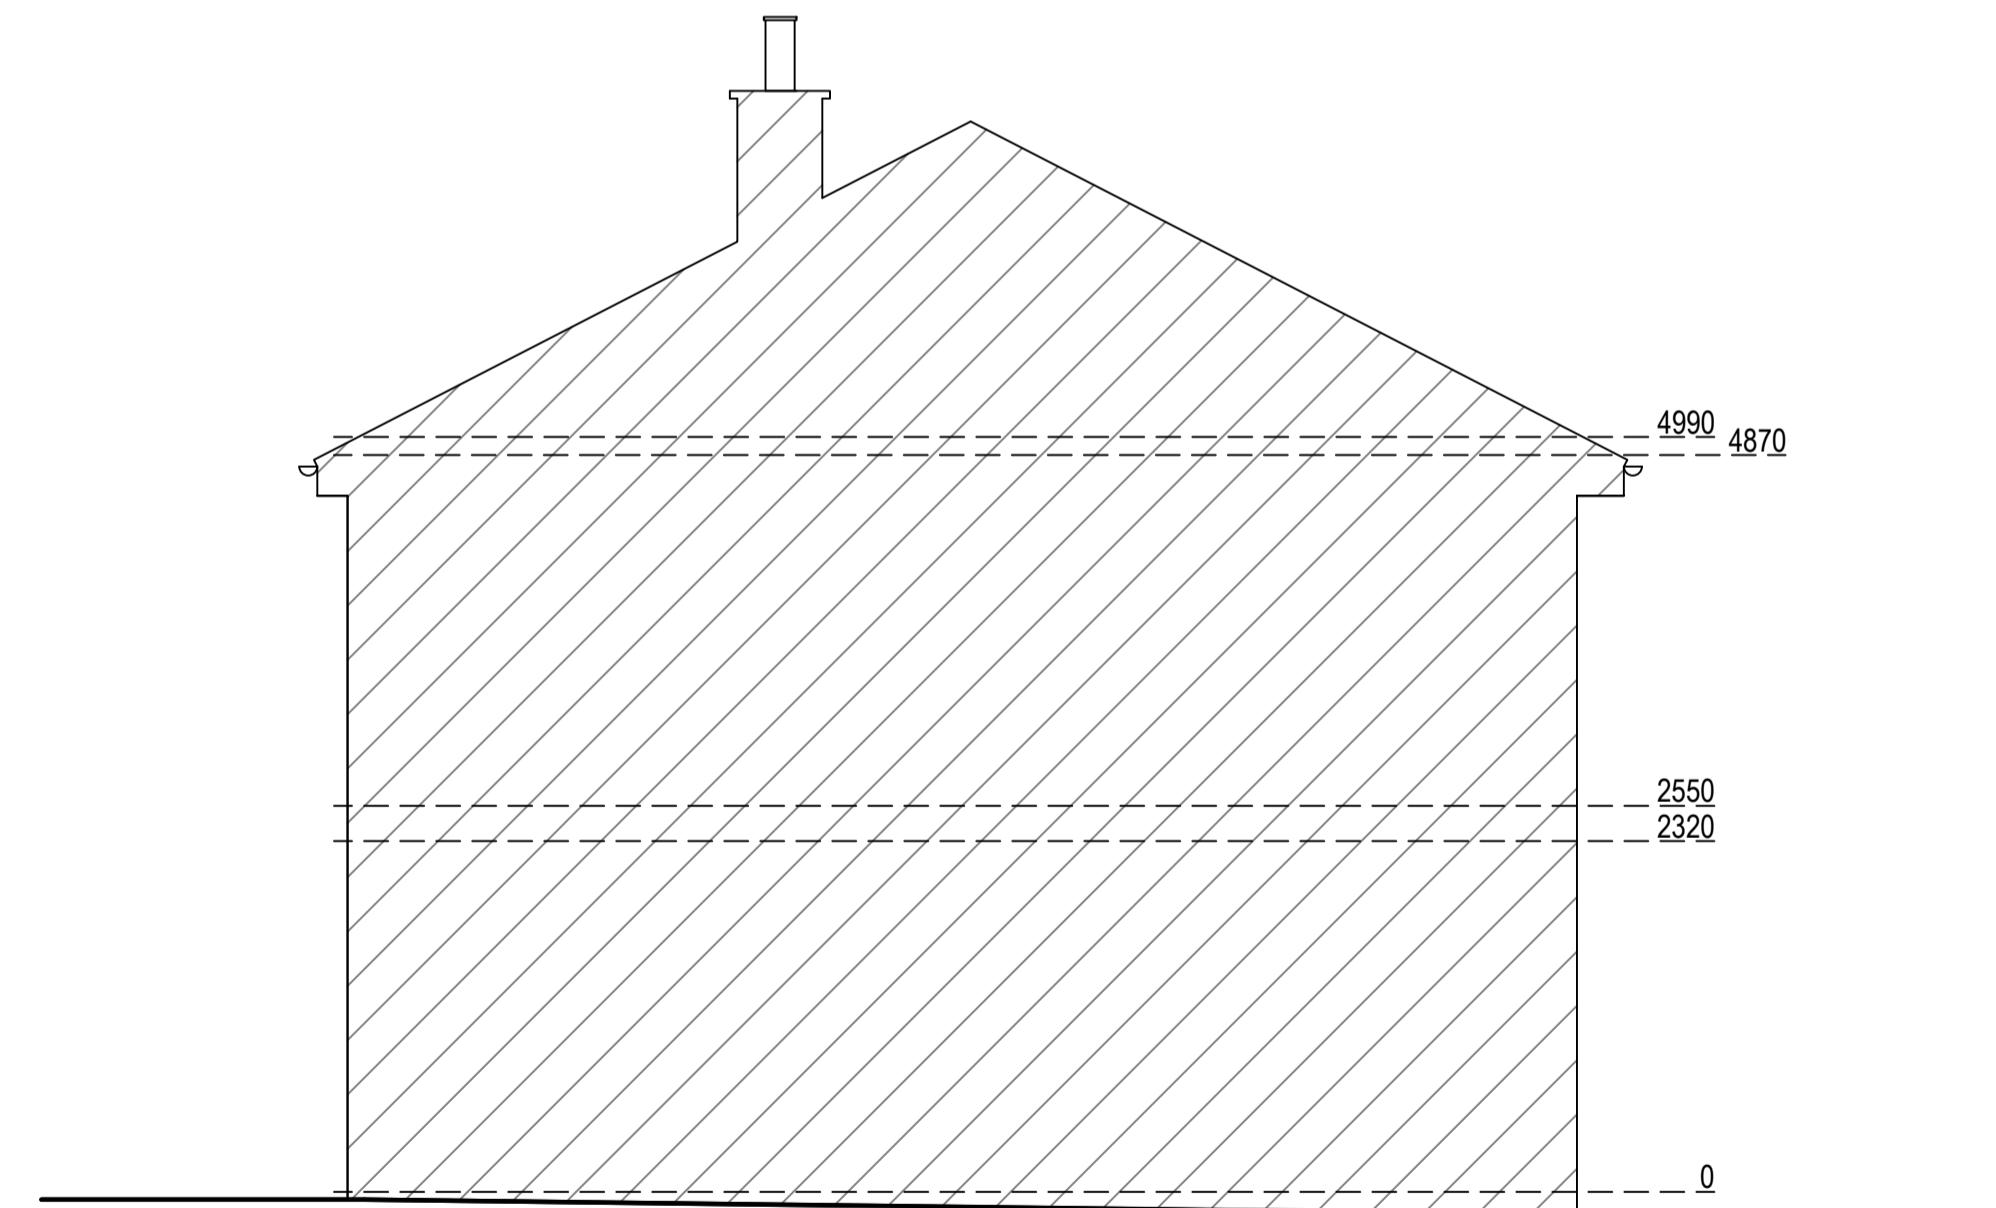

Existing Southwest Elevation
Scale 1:50

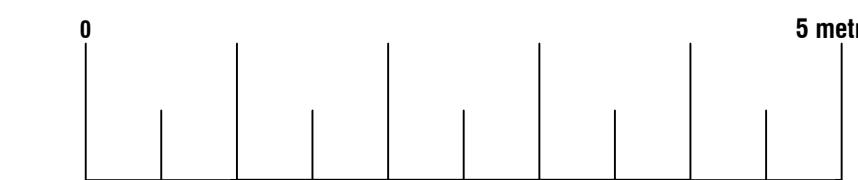

| | | | |
|---------------------|--|-------------|------------|
| Site | 4 Wyteleaf Close, Ruislip, Middlesex HA4 7SP | Date | 29.07.2022 |
| Sheet | 22-1633 | D03 | REV 0 |
| Job | New Extension | | |
| Scale | As Shown@A1 | | |
| Title Number | - | | |
| Title | As Shown | | |

Arkiplan

74 Cardiff Road, CF15 7QE • Enquiries@ArkiPlan.co.uk

Symbol Key:


| |
|---|
| Boundary line |
| Rainwater drainage layout |
| Waste drainage layout |
| Details above |
| timber/steel beam above sized and specified by Structural Engineer - fire proofed as per spec. and detail drawing |

1

47 x 150mm C24 rafters above as per spec. and detail drawing @ 400mm crs

Proposed drainage layout is indicative only and has not been surveyed. Existing foul drainage layout to be surveyed by Contractor on site and exact layout and connections are to be agreed on site with BCO before any works commence. All pipes sizes and falls as per spec. and detail drawings

This drawing is the property of Arkiplan Architectural Ltd. Copyright is reserved by the company and the drawing is issued on the condition that it is not copied, reproduced, retained or disclosed to any unauthorised person, either wholly or in part without consent in writing. Dimensions are provided as a guide only. All dimensions are approximate and to be checked on site prior to commencement of any works. All the works should be executed in compliance with the specification. Parts of this project may require new structural steelwork or timberwork. Structural Engineer to provide the necessary calculations and beam sizes/connections to satisfy Building Control Officer requirements. If the proposed area of any new glazing accounts for more than 25% of the new floor area (minus the area of existing glazing being removed) the client may be required to obtain SAP Calculations from a SAP Assessor before Building Control can fully approve the plans. If in doubt please contact Arkiplan: Arkiplan Architectural Ltd Lytchett House, 13 Freeland Park, Wareham Road, Pool, Dorset BH16 6FA 0845 852 0852 enquiries@arkiplan.co.uk

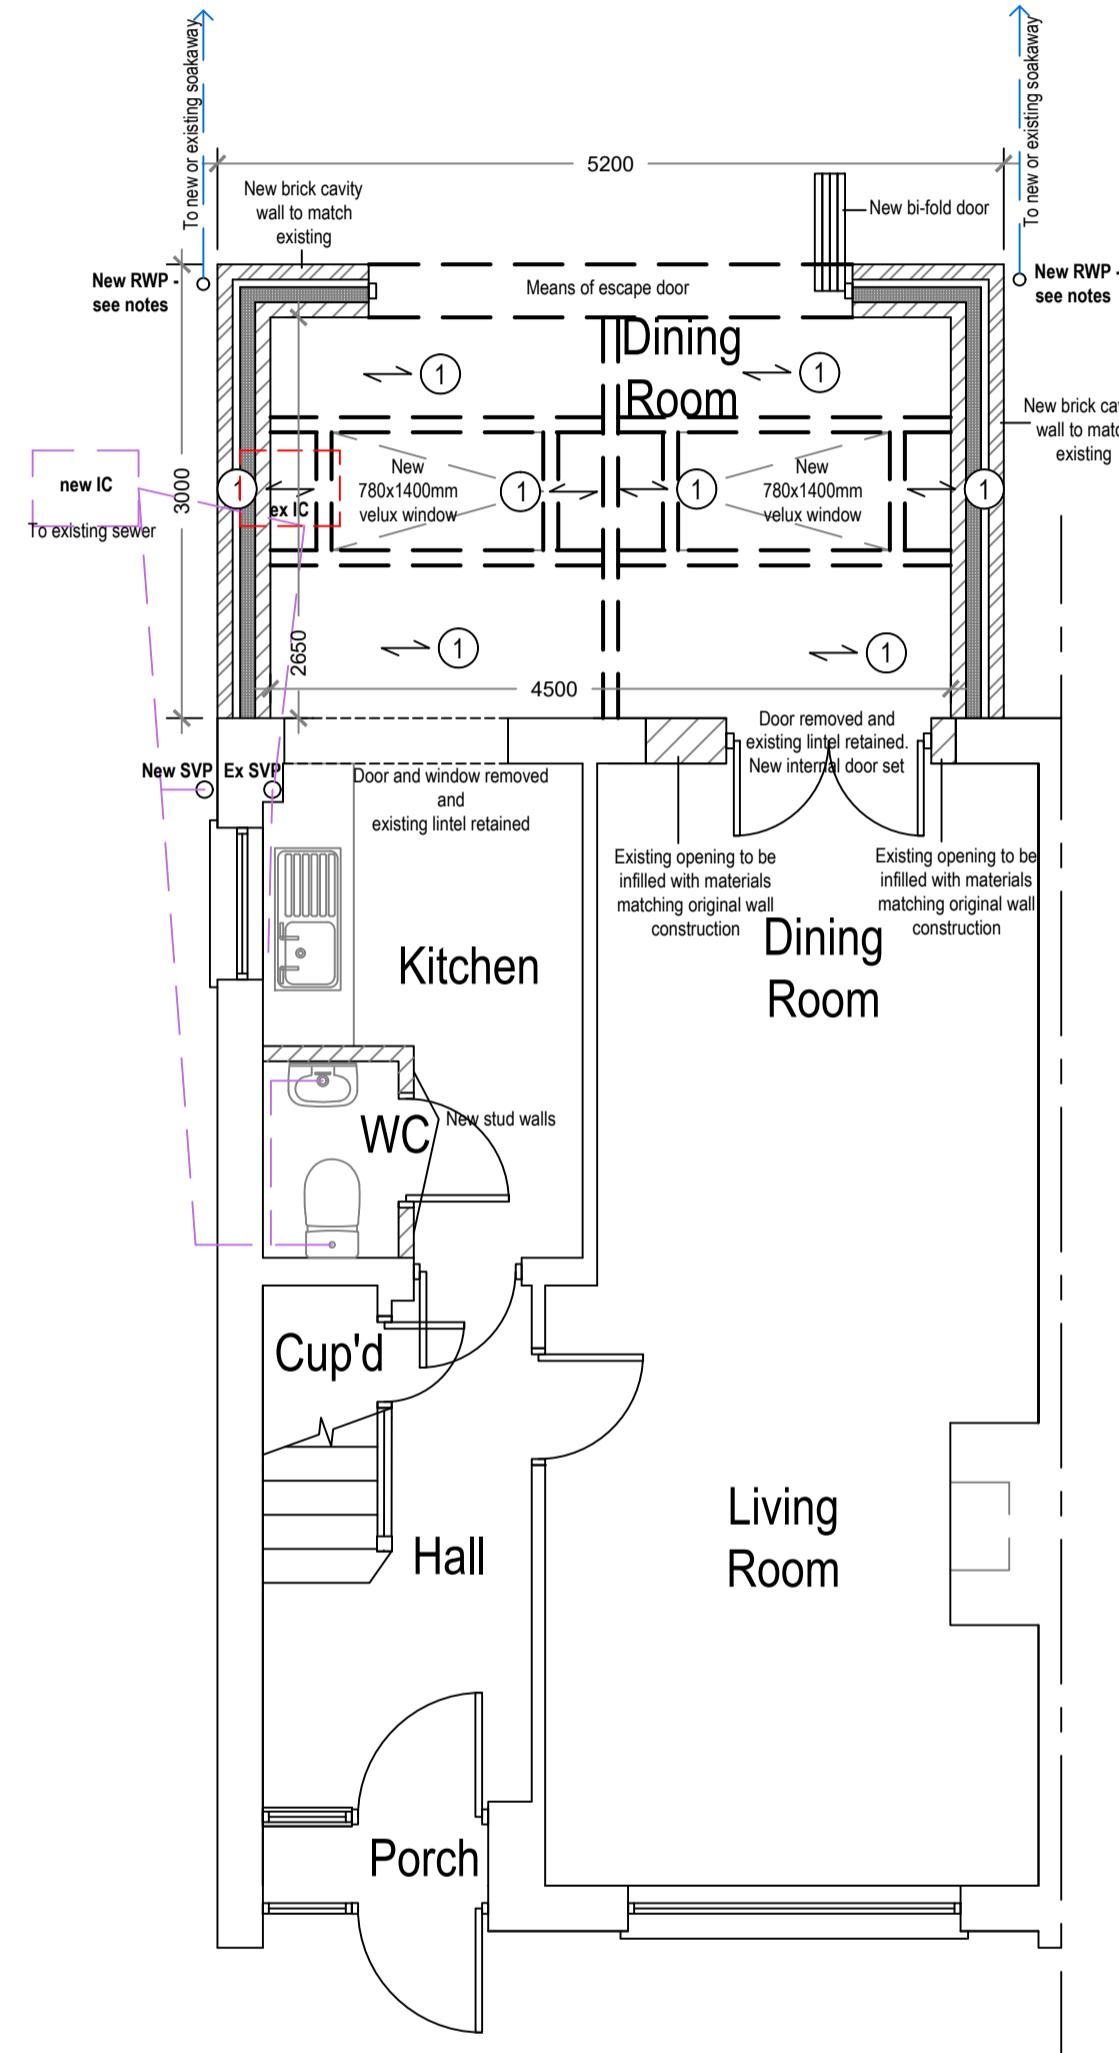

Proposed Ground Floor Plan


Scale 1:50



Arkiplan


74 Cardiff Road, CF15 7QE • Enquiries@ArkiPlan.co.uk

| | |
|--------------|--|
| Date | 29.07.2022 |
| Sheet | 22-1633 D04 REV 0 |
| Site | 4 Wyteleaf Close, Ruislip, Middlesex HA4 7SP |
| Job | New Extension |
| Scale | As Shown@A1 |
| Title Number | - |
| Title | As Shown |

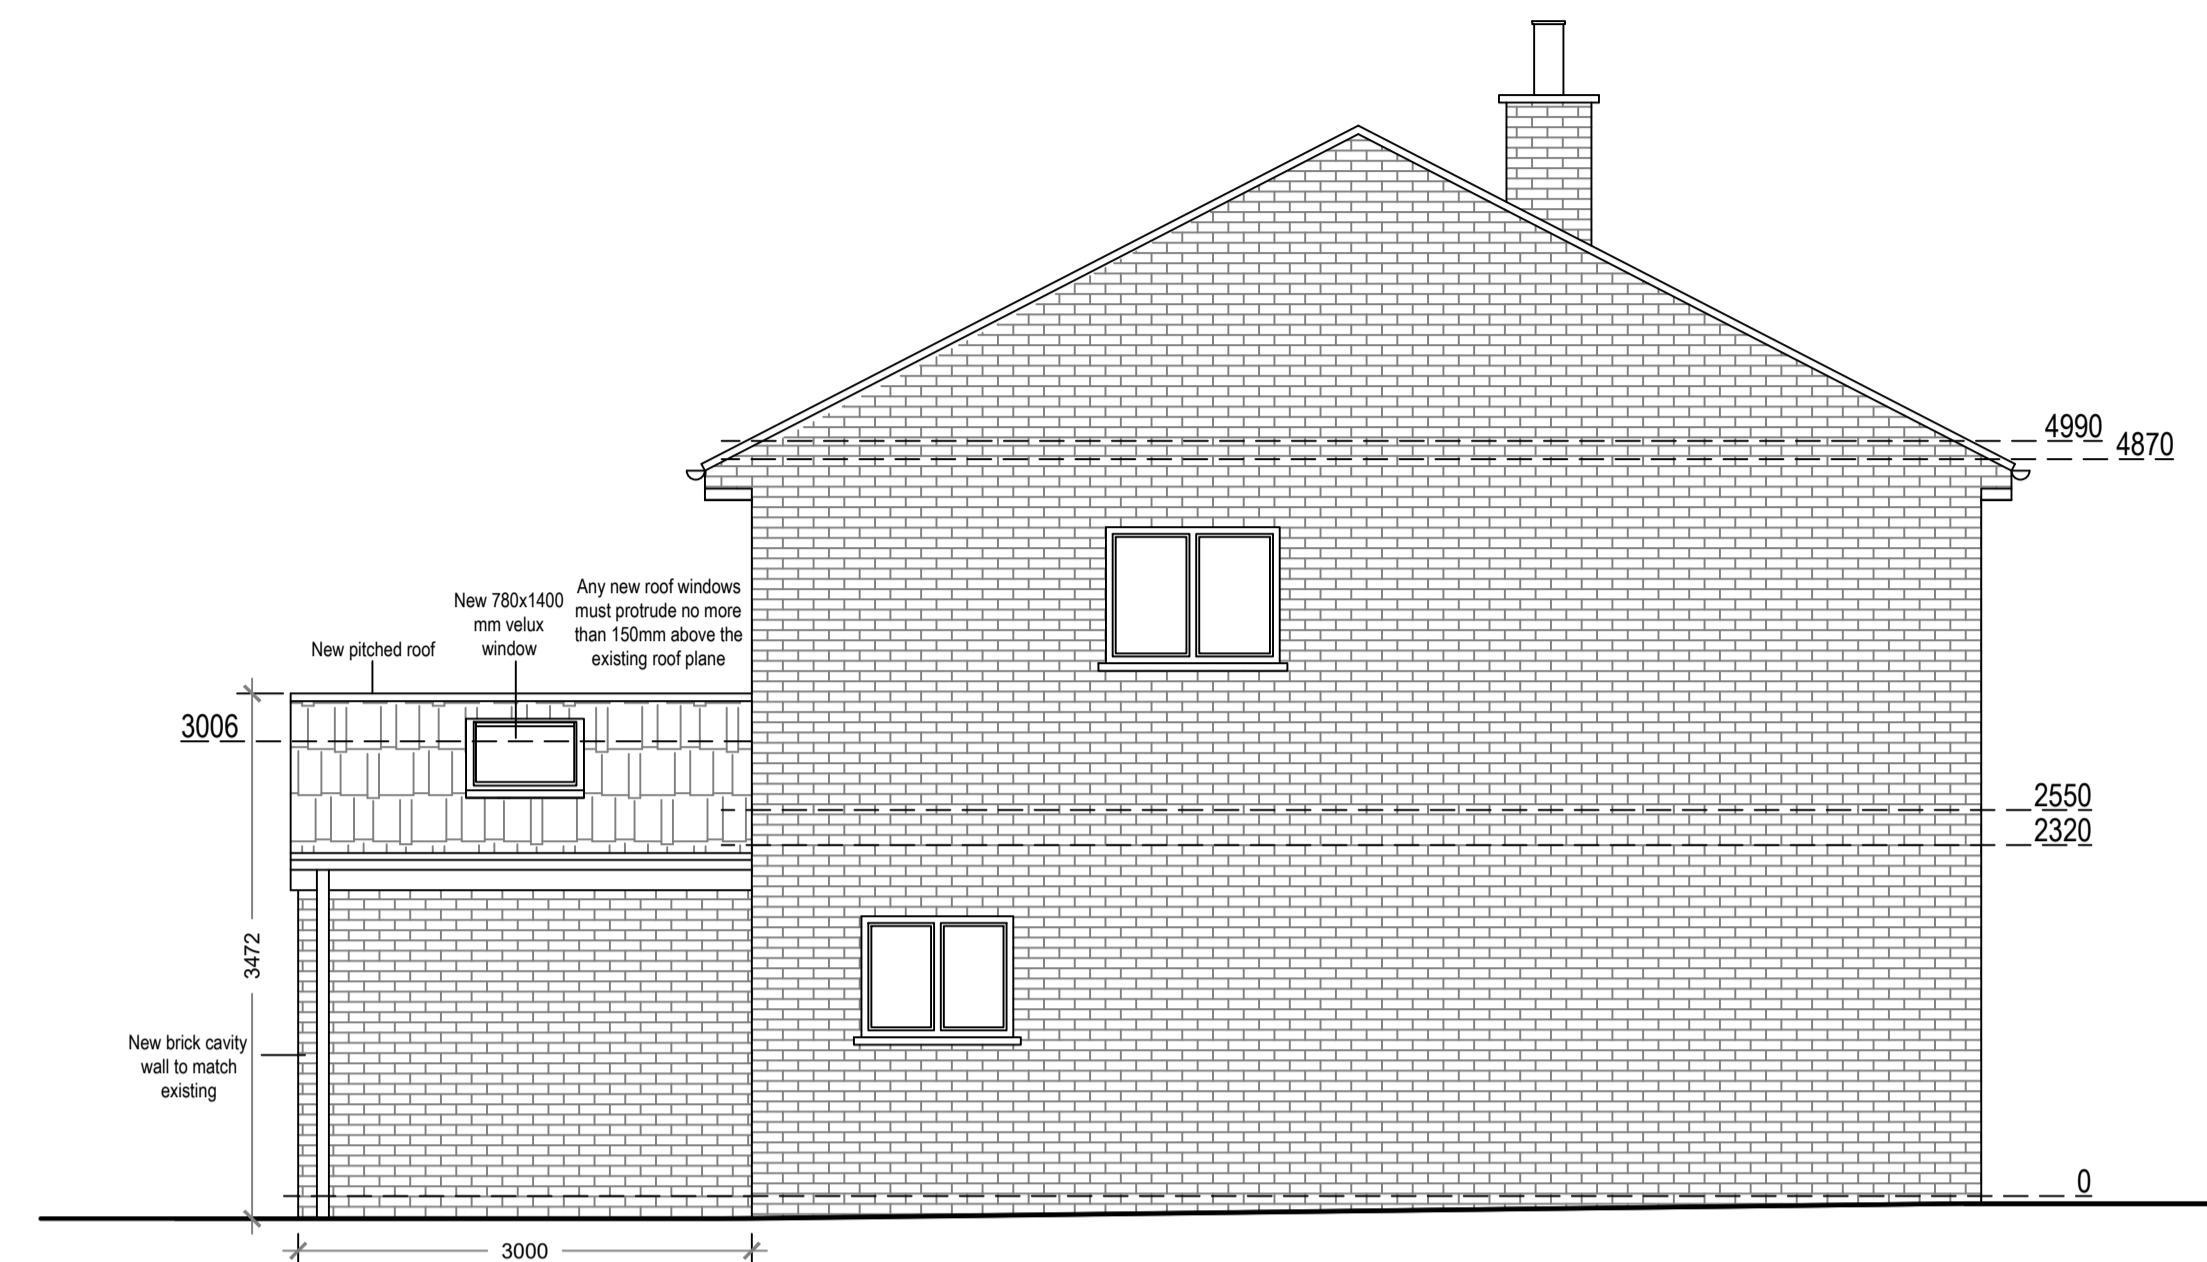


Proposed Northeast Elevation

Scale 1:50

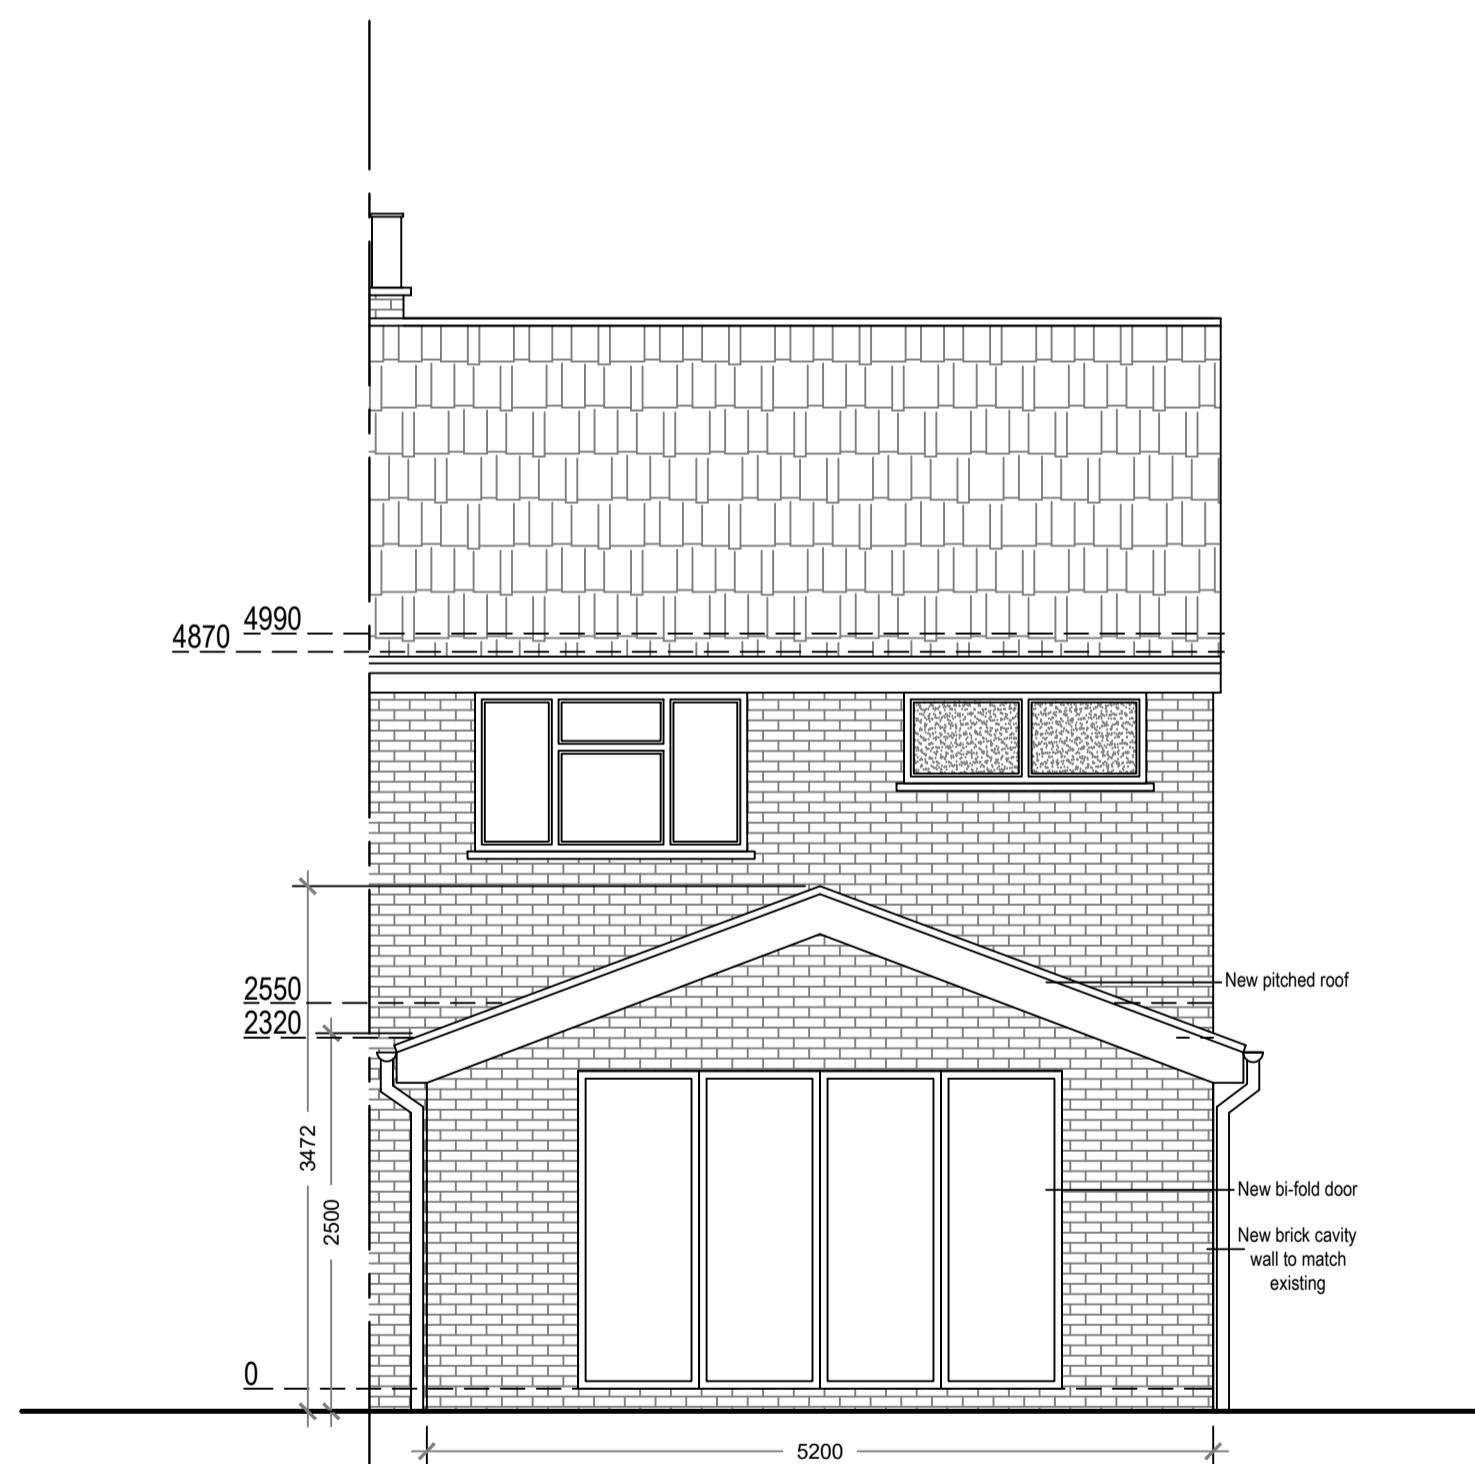


Proposed Southeast Elevation

Scale 1:50

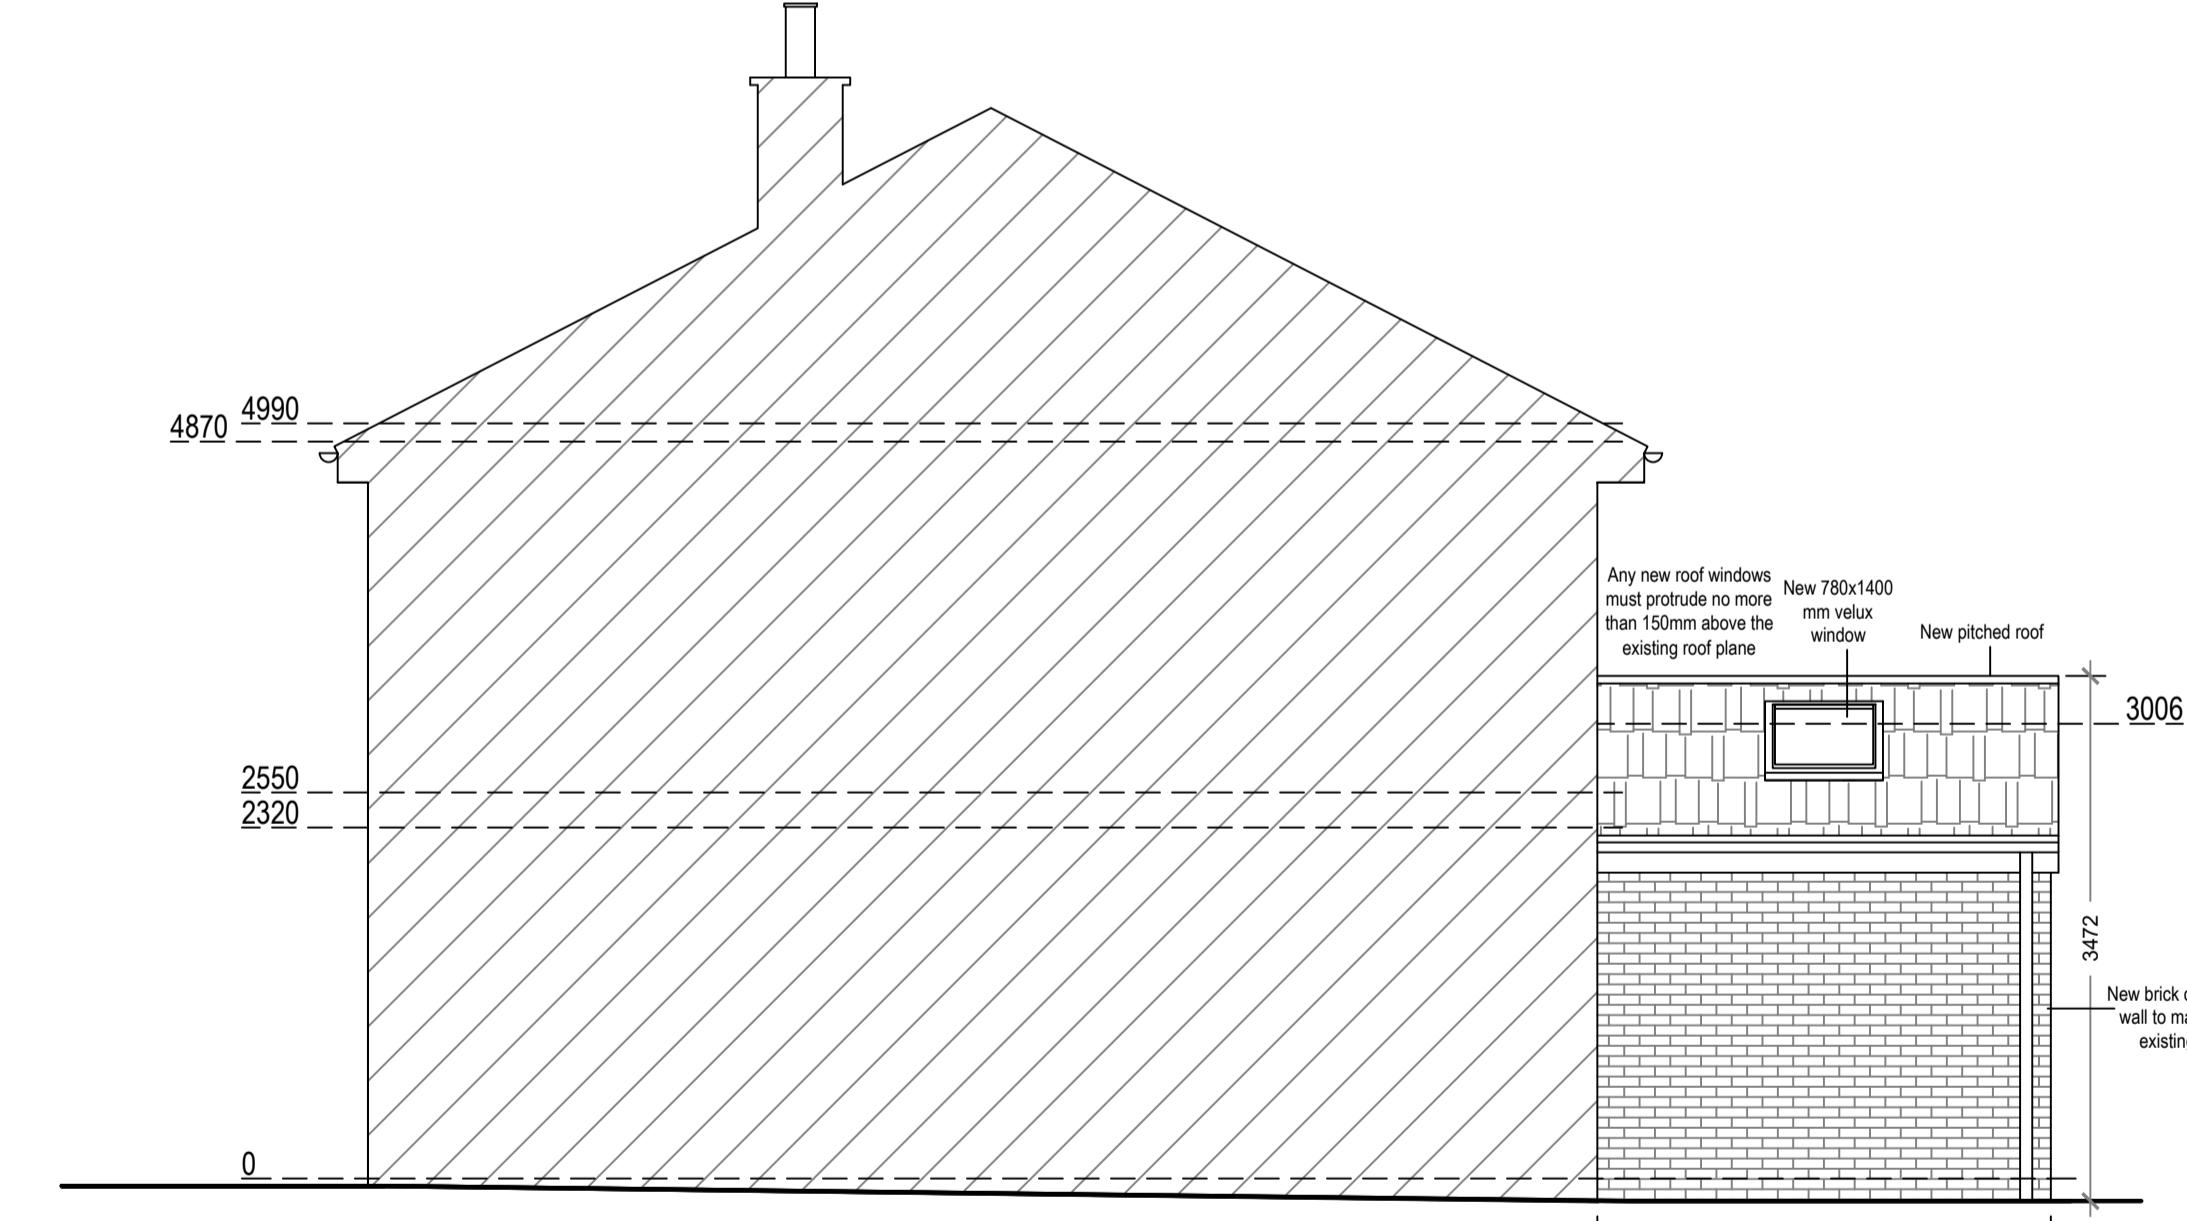

Proposed Southwest Elevation

Scale 1:50

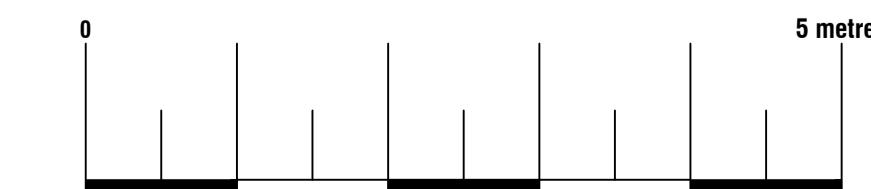

| | | | |
|---------------------|--|-------------|------------|
| Site | 4 Wyteleaf Close, Ruislip, Middlesex HA4 7SP | Date | 29.07.2022 |
| Sheet | 22-1633 | D05 | REV 0 |
| Job | New Extension | | |
| Scale | As Shown@A1 | | |
| Title Number | - | | |
| Title | As Shown | | |

Arkiplan

74 Cardiff Road, CF15 7QE • Enquiries@ArkiPlan.co.uk